 


SITE LOCATION




Reproduced by permission of Ordnance Survey on behalf of the Controller of Her Majesty's Stationary Office
All rights reserved. © Crown Copyright licence no. 100062043

SITE AREA PLAN




SITE PHOTOGRAPH

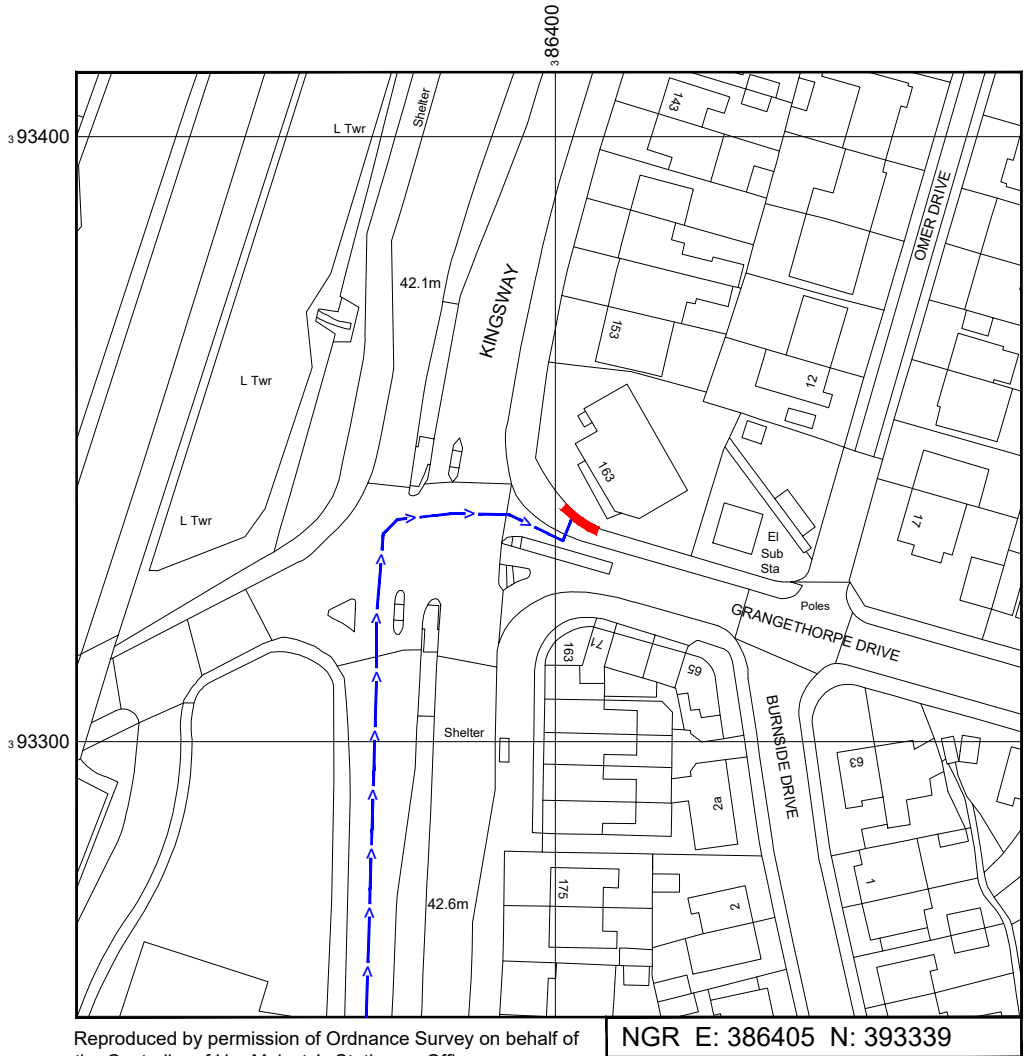

Reproduced by permission of Ordnance Survey on behalf of the Controller of Her Majesty's Stationary Office
All rights reserved. © Crown Copyright licence no. 100062043

NGR E: 386405 N: 393339

 SITE LOCATION PLAN



GOOGLE MAPS QR CODE

GOOGLE MAPS - <https://goo.gl/maps/JHdfu7ePEQ2kmWAg7>

GOOGLE STREETVIEW - <https://goo.gl/maps/mGxEkYbeqrt3geMS6>

NOTES:

1. ALL DIMENSIONS IN MM UNLESS OTHERWISE NOTED.
- DIRECTIONS TO SITE:
Head north-east on M56. At junction 1, exit onto Kingsway/A34 towards City Centre/Didsbury. Turn right onto Grangethorpe Dr and site location is on the left hand side.



Master:	MBNL / EE:	Project:	Purpose of Issue:	Issue:
M001	MBNL	3UK DNSW	Planning	A
Date:	17/04/2023	Revision / Upgrade Description:		
Drawn:	CDN	First Issue - Site nomination dated: TBC		
Checked:	DH			
Approved:	SD			

CK Hutchison
Networks (UK)
Limited

Green Park
450 Longwater Avenue
Reading
RG30 3UR

Design Consultant & Principal Contractor:



WHP Telecoms
Unit 1 Maple Park,
Low Fields Avenue, Leeds
LS12 6HH

Tel: 01133023550
e-mail: info@whptelecoms.com

Site Name:
GRANGETHORPE DRIVE STREETWORKS

Site ID:
MAN23606

Address:
GRANGETHORPE DRIVE, LADYBARN,
BURNAGE, MANCHESTER, GREATER
MANCHESTER, ENGLAND,
M19 2JN


Title:
002 SITE LOCATION PLAN

Project:
3UK DNSW

Purpose of Issue:
PLANNING

EE Cell ID:	MBNL Cell ID:	Cell ID:
TBC	TBC	M1455

Master Drawing No:	Issue:
MAN23606_M001	A

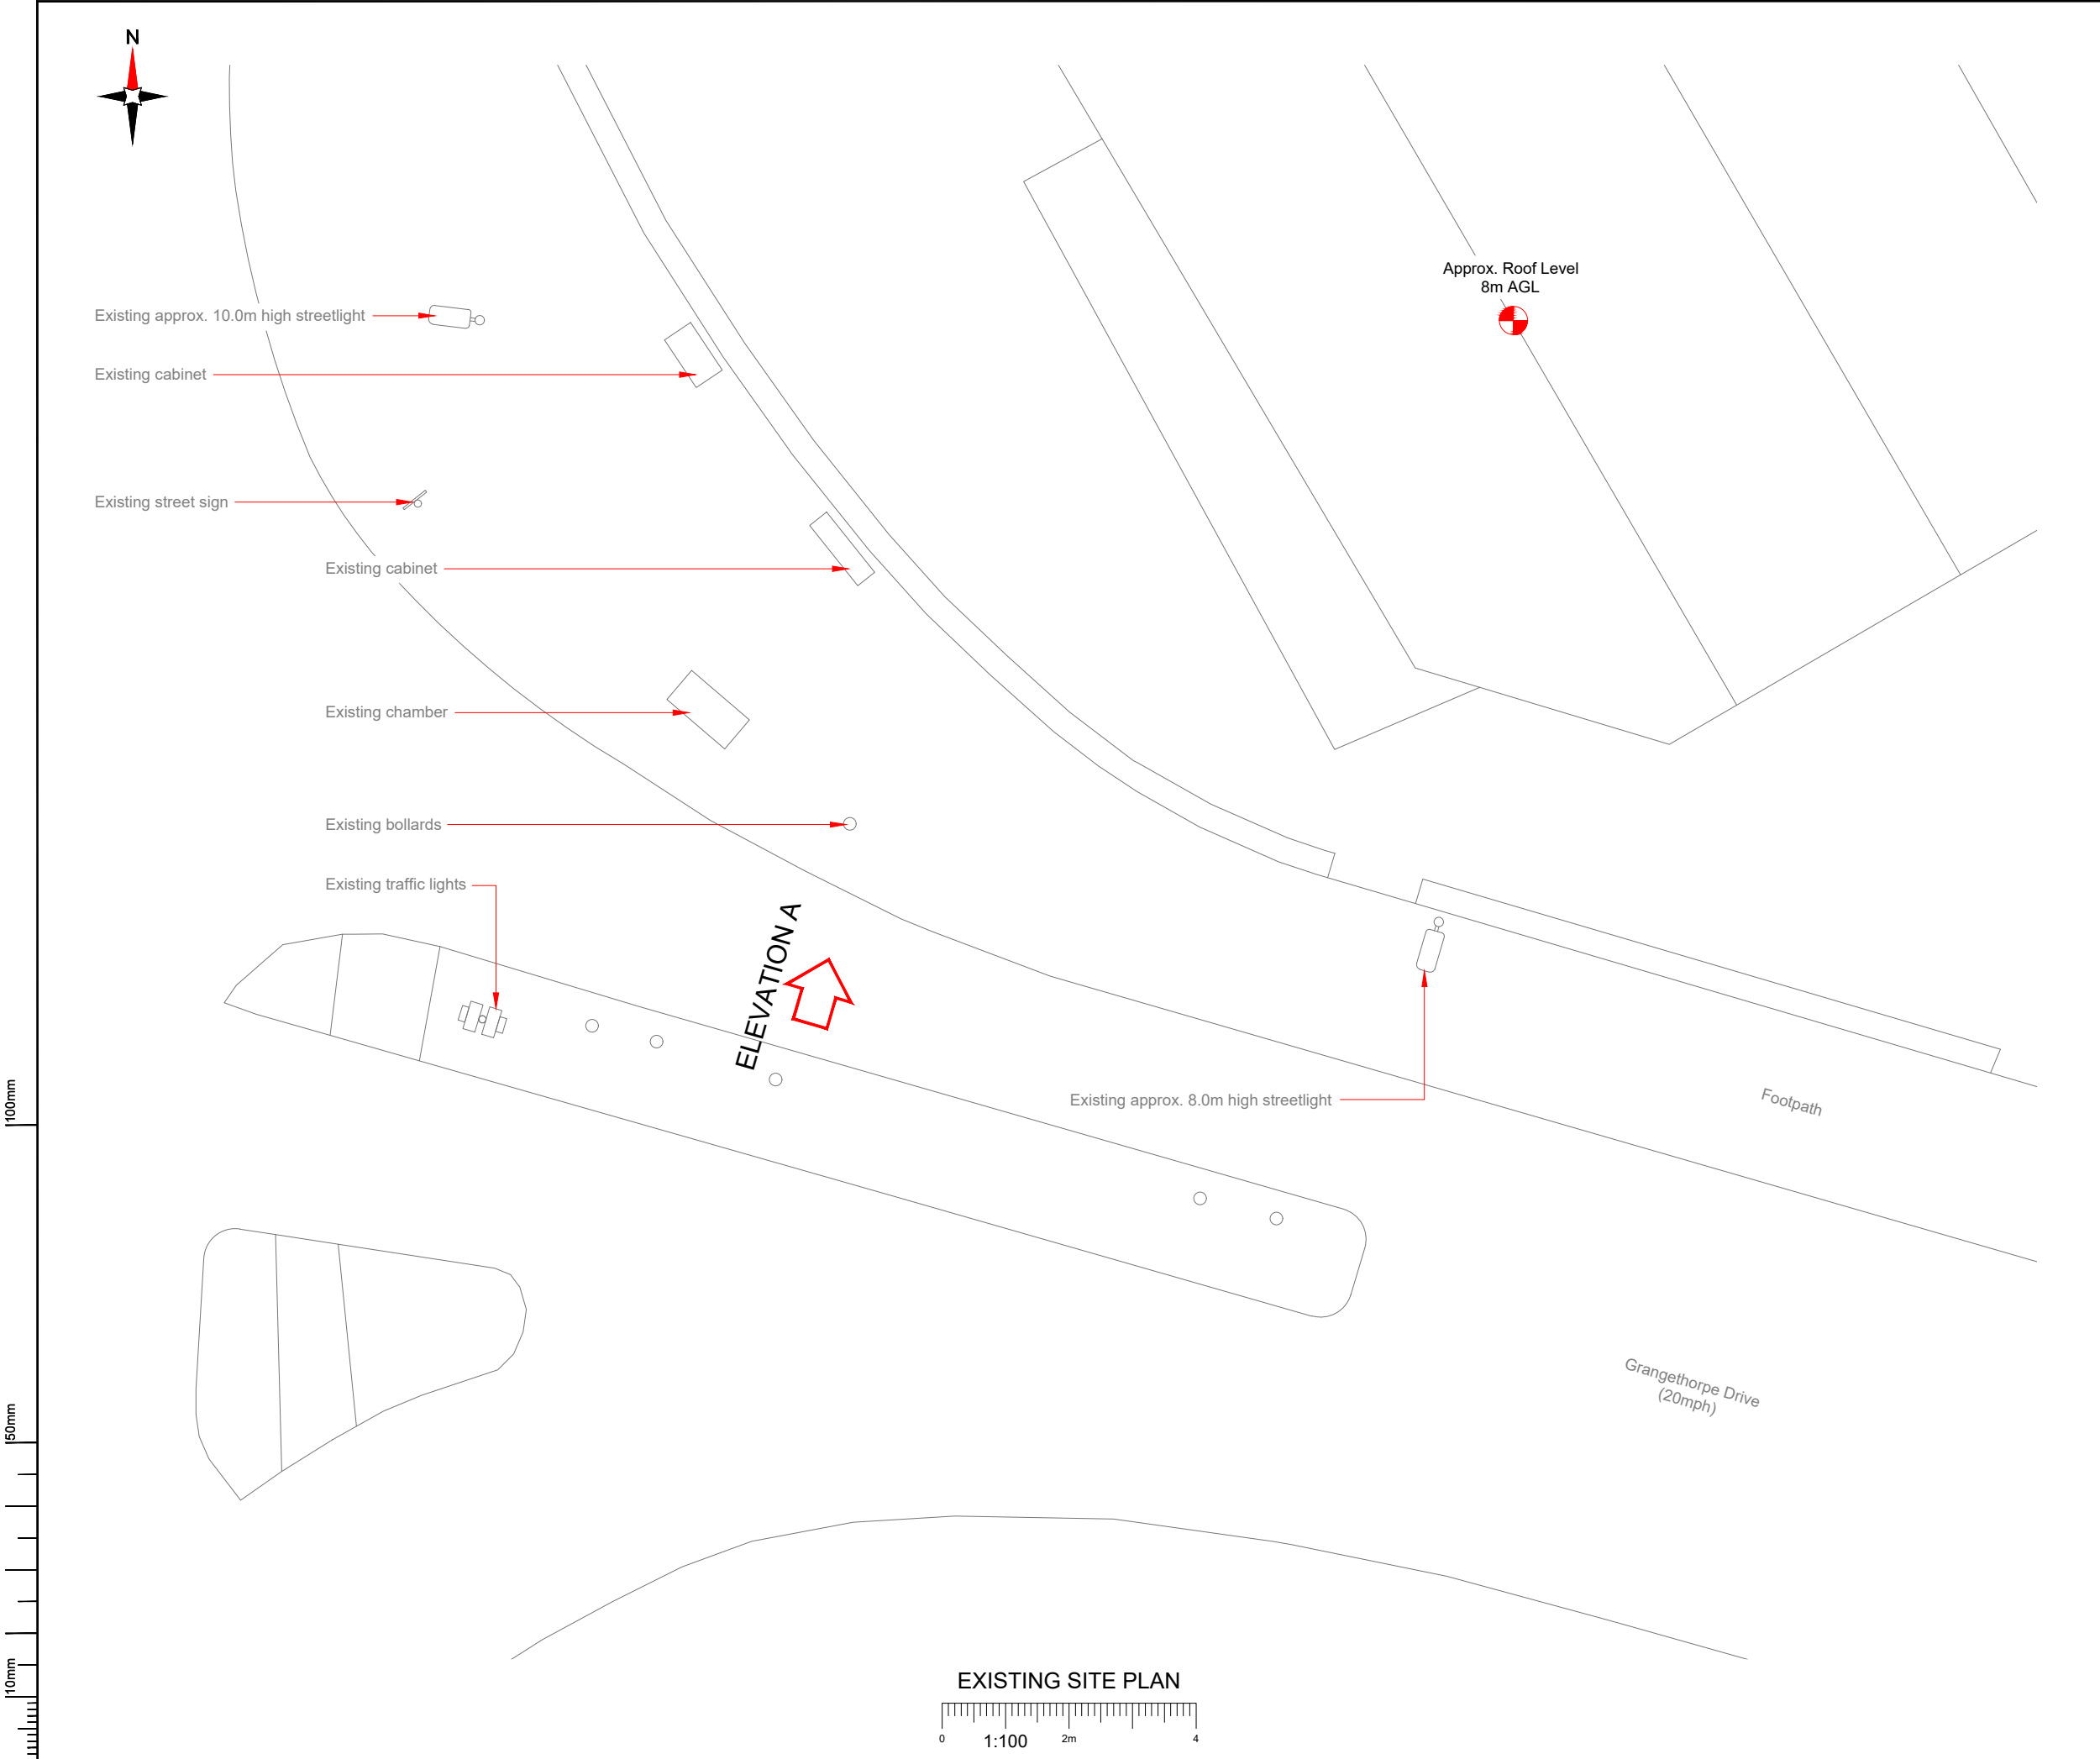

NOTES:

1. ALL DIMENSIONS IN MM UNLESS OTHERWISE NOTED.

Master:	MBNL / EE:	Project:	Purpose of Issue:	Issue:
M001	MBNL	3UK DNSW	Planning	A
Date:	17/04/2023	Revision / Upgrade Description:		
Drawn:	CDN	First Issue - Site nomination dated: TBC		
Checked:	DH			
Approved:	SD			

CK Hutchison Networks (UK) Limited

Green Park
450 Longwater Avenue
Reading
RG30 3UR

Design Consultant & Principal Contractor:



WHP Telecoms
Unit 1 Maple Park,
Low Fields Avenue, Leeds
LS12 6HH

Tel: 01133023550
e-mail: info@whptelecoms.com

Site Name:

GRANGETHORPE DRIVE STREETWORKS

Site ID:

MAN23606

Address:

**GRANGETHORPE DRIVE, LADYBARN,
BURNAGE, MANCHESTER, GREATER
MANCHESTER, ENGLAND,
M19 2JN**

Title:

100 EXISTING SITE PLAN

Project:

3UK DNSW

Purpose of Issue:

PLANNING

EE Cell ID:	MBNL Cell ID:	Cell ID:
TBC	TBC	M1455


Master Drawing No:

MAN23606_M001


Issue:

A

100mm
50mm
10mm

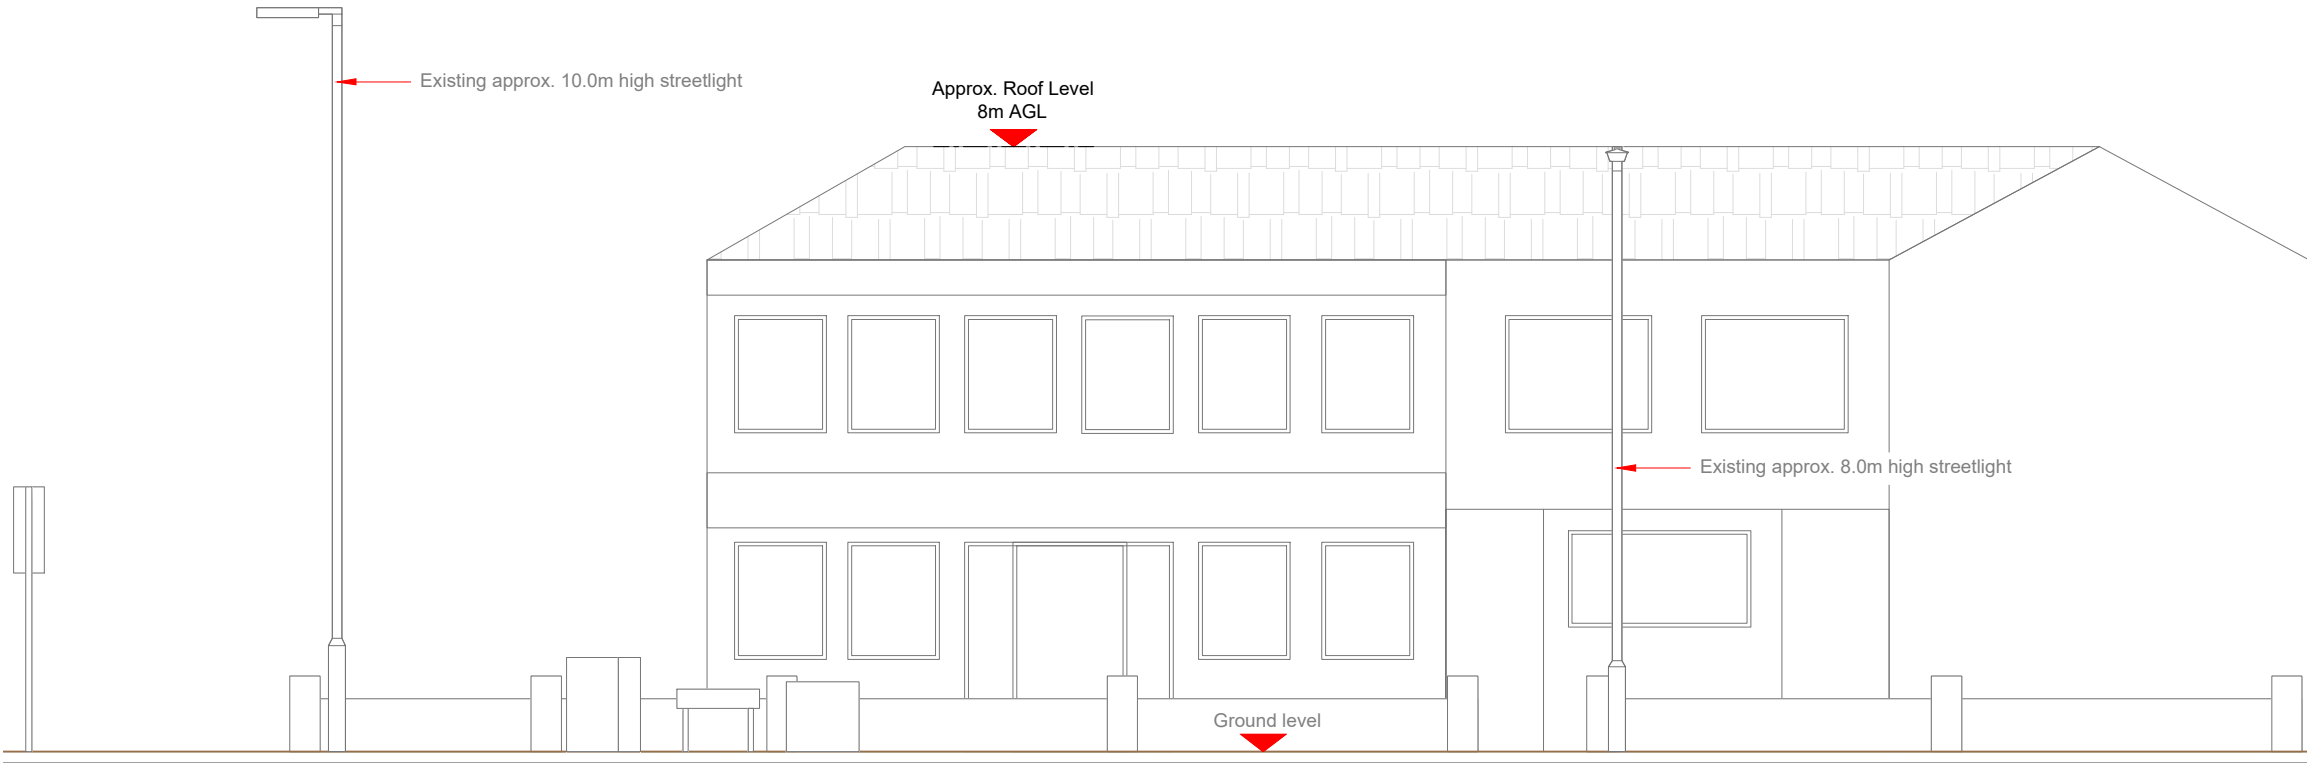

EXISTING ELEVATION A

 

- NOTES:
- ALL DIMENSIONS IN MM UNLESS OTHERWISE NOTED.

Master:	MBNL / EE:	Project:	Purpose of Issue:	Issue:
M001	MBNL	3UK DNSW	Planning	A
Date:	17/04/2023	Revision / Upgrade Description:		
Drawn:	CDN	First Issue - Site nomination dated: TBC		
Checked:	DH			
Approved:	SD			

CK Hutchison
Networks (UK)
Limited

Green Park
450 Longwater Avenue
Reading
RG30 3UR

Design Consultant & Principal Contractor:



WHP Telecoms
Unit 1 Maple Park,
Low Fields Avenue, Leeds
LS12 6HH

Tel: 01133023550
e-mail: info@whptelecoms.com

Site Name:
GRANGETHORPE DRIVE STREETWORKS

Site ID:
MAN23606

Address:
GRANGETHORPE DRIVE, LADYBARN,
BURNAGE, MANCHESTER, GREATER
MANCHESTER, ENGLAND,
M19 2JN

Title:
150 EXISTING ELEVATION A

Project:
3UK DNSW

Purpose of Issue:
PLANNING

EE Cell ID: TBC	MBNL Cell ID: TBC	Cell ID: M1455
--------------------	----------------------	-------------------

Master Drawing No: MAN23606_M001	Issue: A
-------------------------------------	-------------



Existing approx. 10.0m high streetlight

Existing cabinet

Existing street sign

Existing cabinet

Existing chamber

Existing bollards

Existing traffic lights

ELEVATION A

Existing approx. 8.0m high streetlight

Approx. Roof Level
8m AGL

Proposed 2No. cabinets

 
Proposed Phase 8 monopole

Proposed G-100876 cabinet

Footpath

Grangethorpe Drive
(20mph)

PROPOSED SITE PLAN



Antenna Aperture ID	Proposed 4G/5G Bearing
A1	0°
A2	0°
B1	120°
B2	120°
C1	240°
C2	240°

NOTES:

1. ALL DIMENSIONS IN MM UNLESS OTHERWISE NOTED.

Master:	MBNL / EE:	Project:	Purpose of Issue:	Issue:
M001	MBNL	3UK DNSW	Planning	A
Date:	17/04/2023	Revision / Upgrade Description:		
Drawn:	CDN	First Issue - Site nomination dated: TBC		
Checked:	DH			
Approved:	SD			

CK Hutchison
Networks (UK)
Limited

Green Park
450 Longwater Avenue
Reading
RG30 3UR

Design Consultant & Principal Contractor:



WHP Telecoms

Unit 1 Maple Park,
Low Fields Avenue, Leeds
LS12 6HH

Tel: 01133023550
e-mail: info@whptelecoms.com

Site Name:

GRANGETHORPE DRIVE STREETWORKS

Site ID:

MAN23606

Address:

GRANGETHORPE DRIVE, LADYBARN,
BURNAGE, MANCHESTER, GREATER
MANCHESTER, ENGLAND,
M19 2JN

Title:

210 PROPOSED SITE PLAN

Project:

3UK DNSW

Purpose of Issue:

PLANNING

EE Cell ID:

TBC

MBNL Cell ID:

TBC

Cell ID:

M1455

Master Drawing No:

MAN23606_M001

Issue:


A



Antenna Aperture ID	Proposed 4G/5G Bearing
A1	0°
A2	0°
B1	120°
B2	120°
C1	240°
C2	240°

NOTES:

1. ALL DIMENSIONS IN MM UNLESS OTHERWISE NOTED.

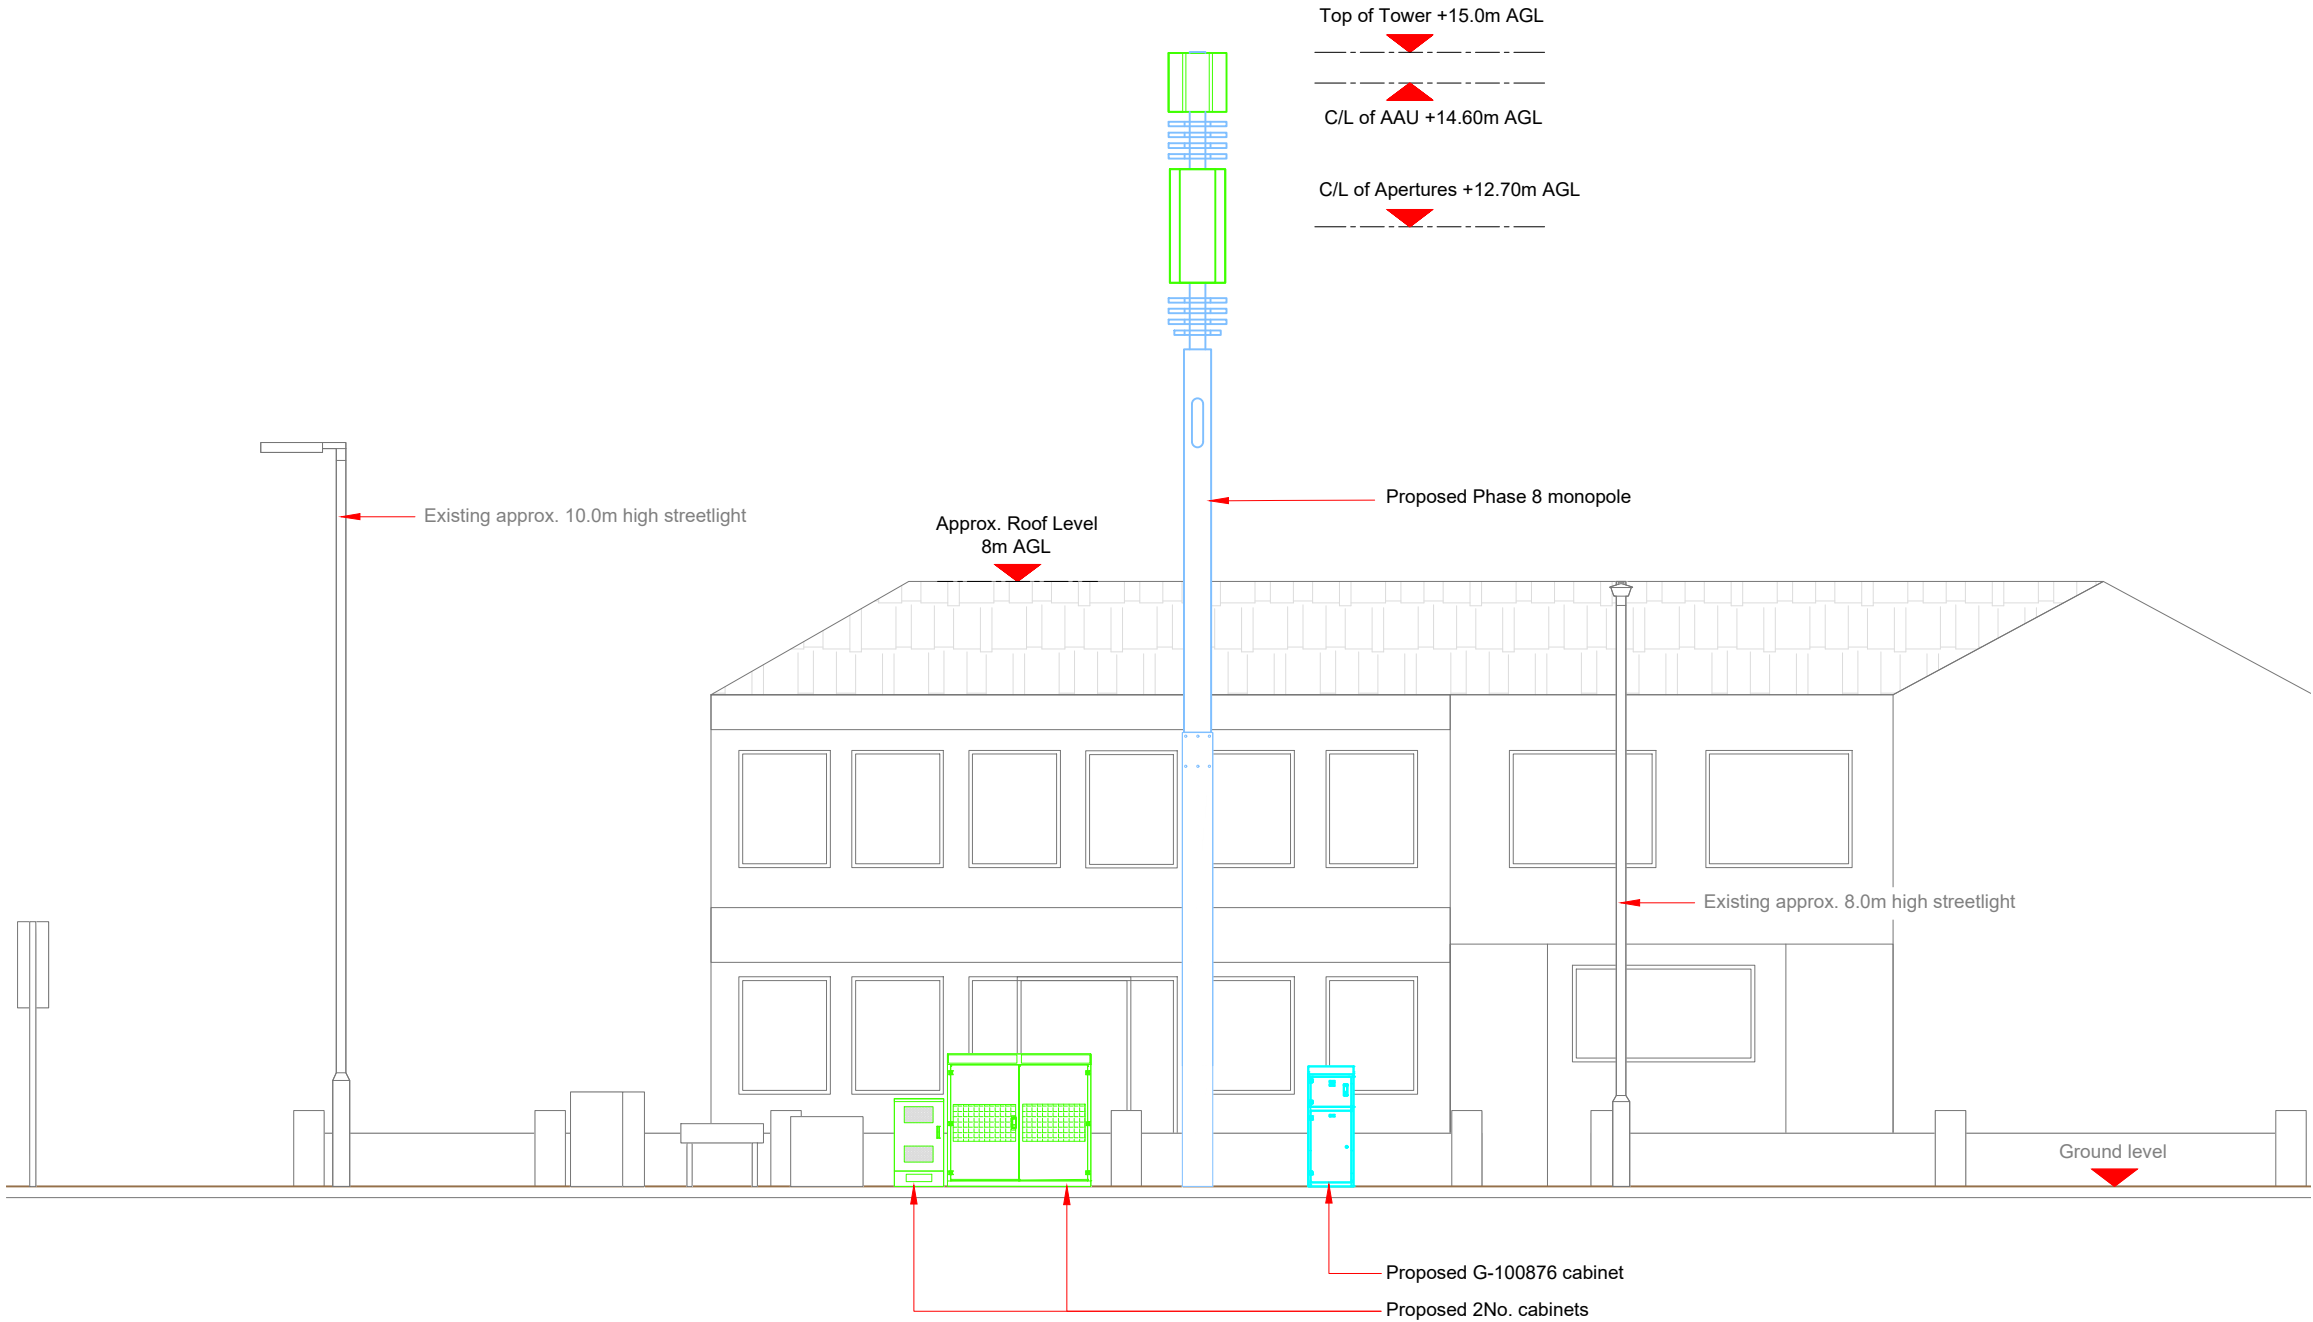

Master:	MBNL / EE:	Project:	Purpose of Issue:	Issue:
M001	MBNL	3UK DNSW	Planning	A
Date:	17/04/2023	Revision / Upgrade Description:		
Drawn:	CDN	First Issue - Site nomination dated: TBC		
Checked:	DH			
Approved:	SD			

CK Hutchison Networks (UK) Limited
Green Park
450 Longwater Avenue
Reading
RG30 3UR

Design Consultant & Principal Contractor:



WHP Telecoms
Unit 1 Maple Park,
Low Fields Avenue, Leeds
LS12 6HH

Tel: 01133023550
e-mail: info@whptelecoms.com

Site Name:
GRANGETHORPE DRIVE STREETWORKS

Site ID:
MAN23606

Address:
**GRANGETHORPE DRIVE, LADYBARN,
BURNAGE, MANCHESTER, GREATER
MANCHESTER, ENGLAND,
M19 2JN**

Title:
260 PROPOSED ELEVATION

Project:
3UK DNSW

Purpose of Issue:
PLANNING

EE Cell ID:	MBNL Cell ID:	Cell ID:
TBC	TBC	M1455

Master Drawing No:	Issue:
MAN23606_M001	A