


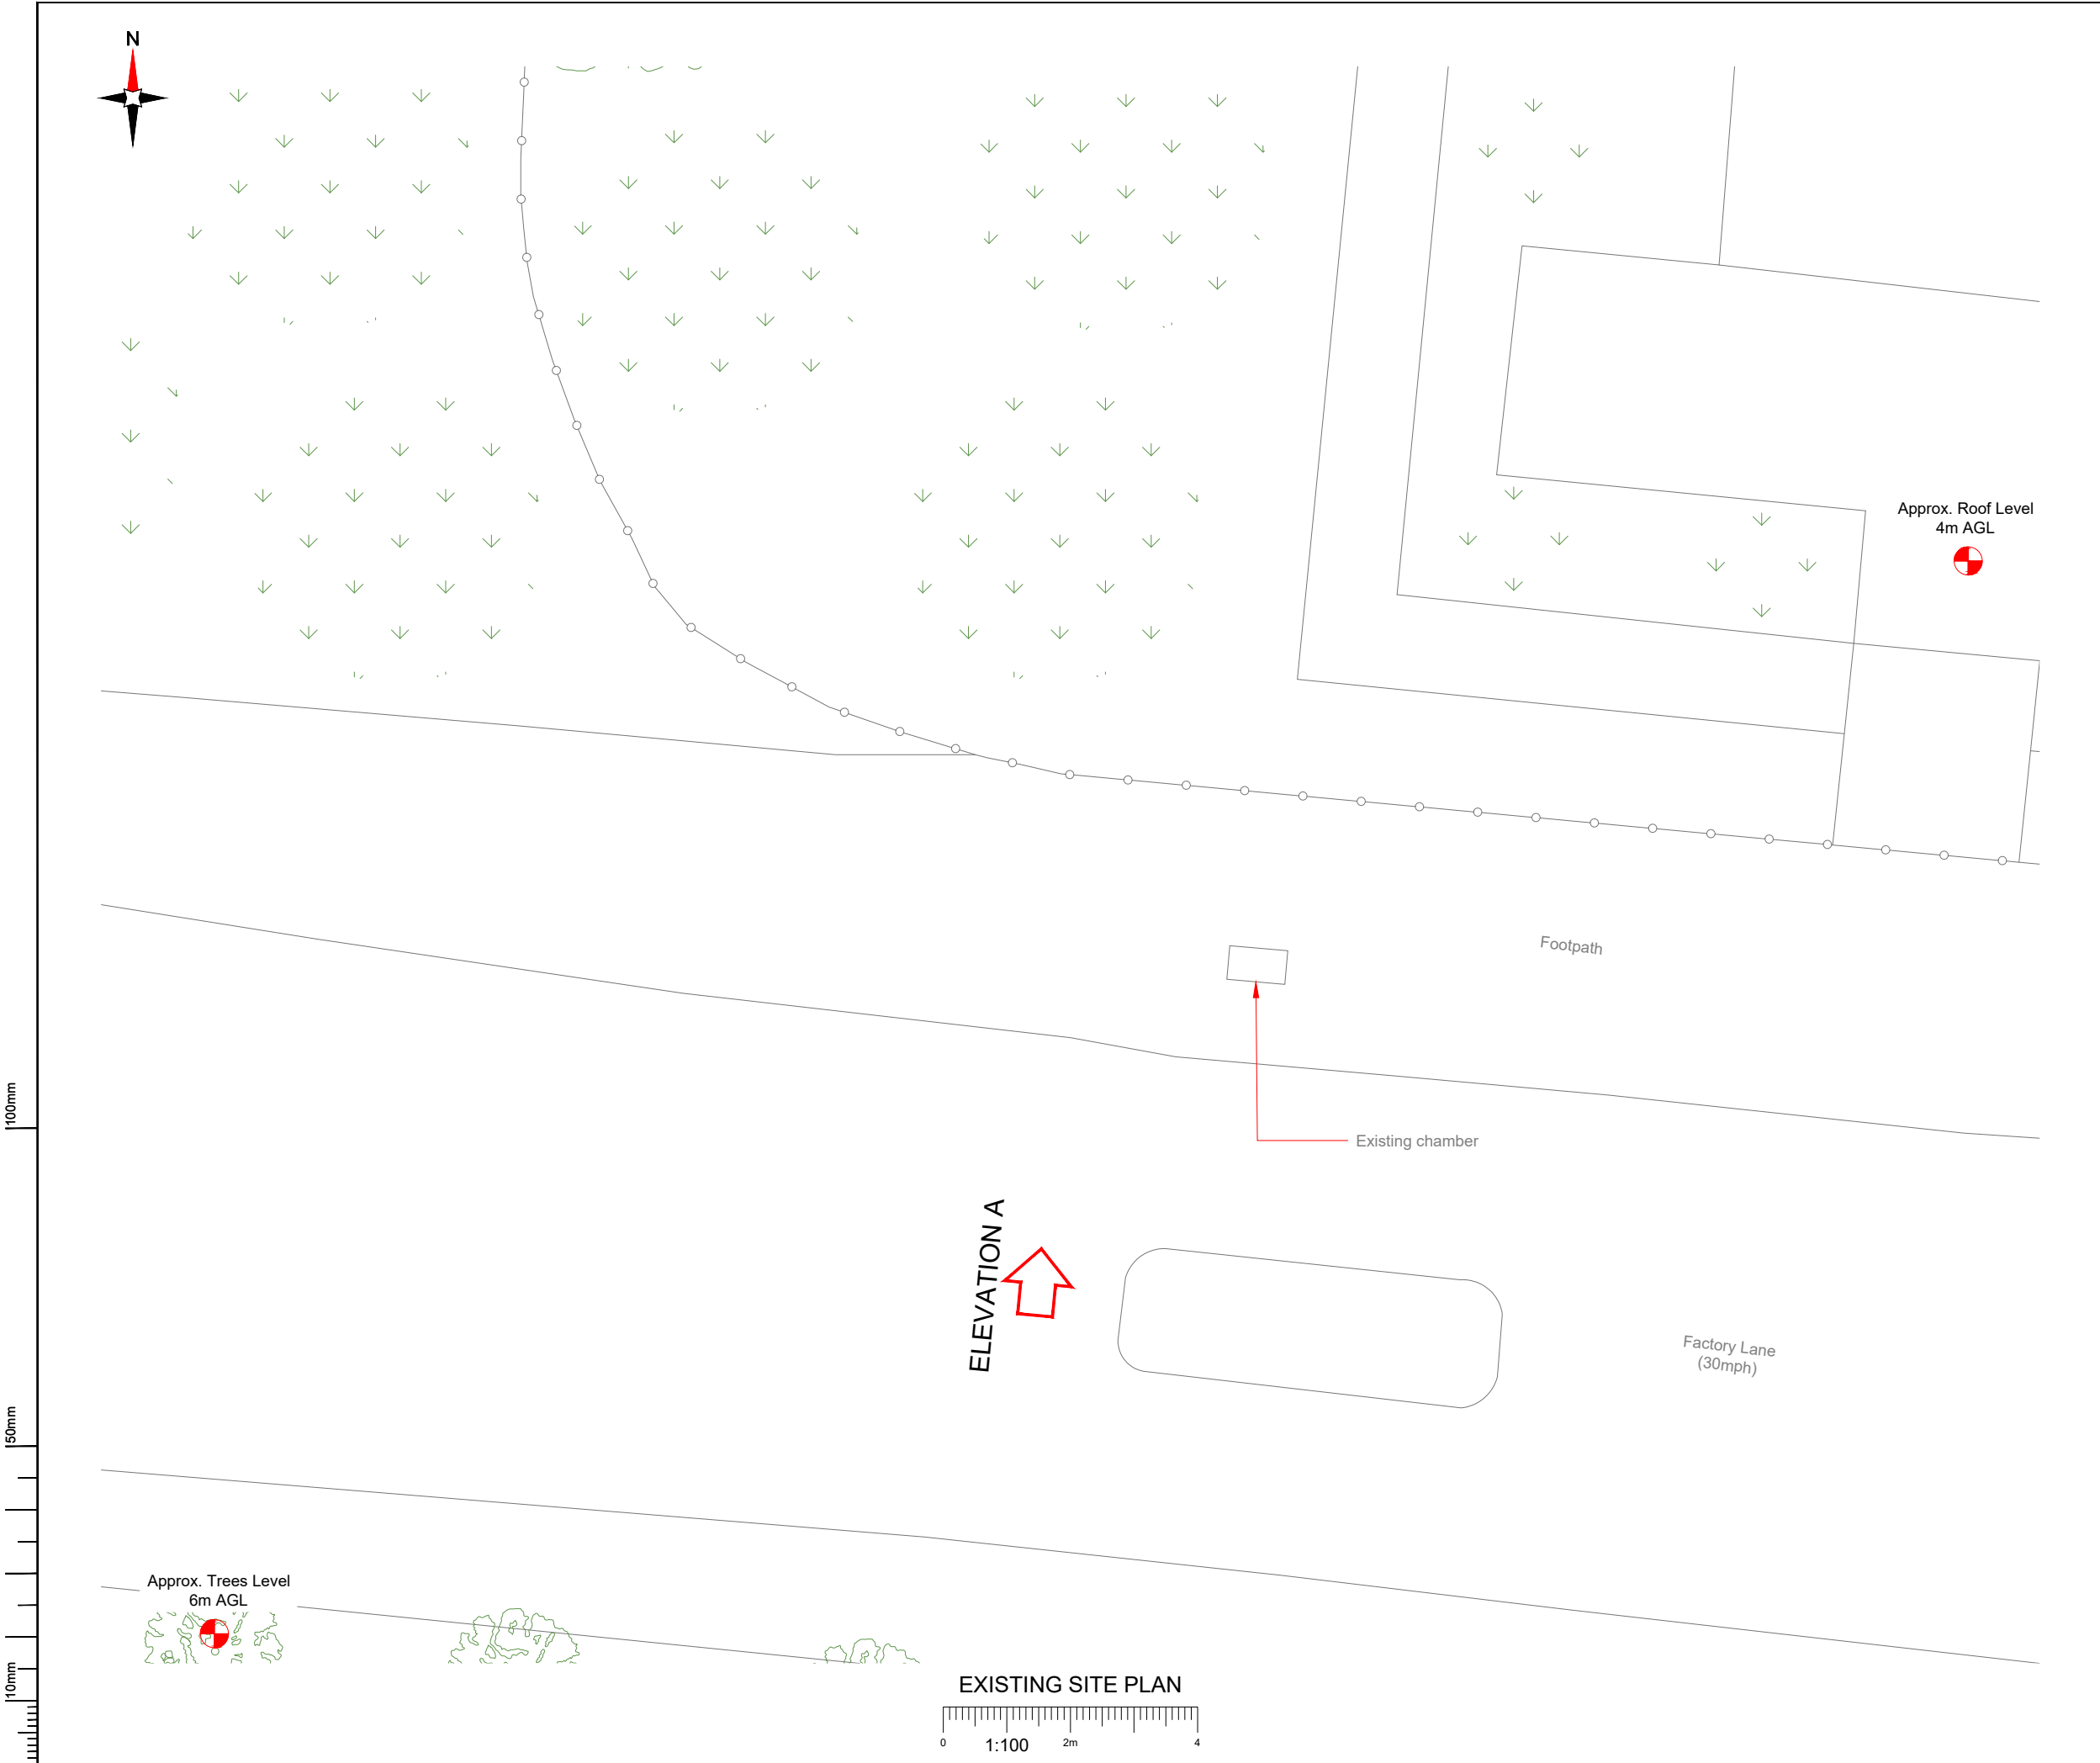

NOTES:

1. ALL DIMENSIONS IN MM UNLESS OTHERWISE NOTED.

Master:	MBNL / EE:	Project:	Purpose of Issue:	Issue:
M001	MBNL	3UK DNSW	Planning	A
Date:	30/01/2023	Revision / Upgrade Description:		
Drawn:	CDN	First Issue - Site nomination dated: TBC		
Checked:	DH			
Approved:	SD			

CK Hutchison Networks (UK) Limited

Great Brighams Mead,
Vastern Road, Reading,
Berkshire, England,
RG1 8DJ

Design Consultant & Principal Contractor:



WHP Telecoms
Unit 1 Maple Park,
Low Fields Avenue, Leeds
LS12 6HH

Tel: 01133023550
e-mail: info@whptelecoms.com

Site Name:		
FACTORY LANE STREETWORKS		
Site ID:		
MAN24033		
Address:		
FACTORY LANE, HARPURHEY, MANCHESTER, GREATER MANCHESTER, ENGLAND, M9 8AB		
Title:		
100 EXISTING SITE PLAN		
Project:		
3UK DNSW		
Purpose of Issue:		
PLANNING		
EE Cell ID:	MBNL Cell ID:	Cell ID:
88222	MAN639	M1429
Master Drawing No:		Issue:
MAN24033_M001		A

 
100mm

50mm

10mm



EXISTING ELEVATION A



- NOTES:
1. ALL DIMENSIONS IN MM UNLESS OTHERWISE NOTED.

Master:	MBNL / EE:	Project:	Purpose of Issue:	Issue:
M001	MBNL	3UK DNSW	Planning	A
Date:	30/01/2023	Revision / Upgrade Description:		
Drawn:	CDN	First Issue - Site nomination dated: TBC		
Checked:	DH			
Approved:	SD			

**CK Hutchison
Networks (UK)
Limited**

Great Brighams Mead,
Vastern Road, Reading,
Berkshire, England,
RG1 8DJ

Design Consultant & Principal Contractor:



WHP Telecoms
Unit 1 Maple Park,
Low Fields Avenue, Leeds
LS12 6HH

Tel: 01133023550
e-mail: info@whptelecoms.com

Site Name:
FACTORY LANE STREETWORKS

Site ID:
MAN24033

Address:
**FACTORY LANE, HARPURHEY,
MANCHESTER, GREATER MANCHESTER,
ENGLAND,
M9 8AB**

Title:
150 EXISTING ELEVATION A

Project:
3UK DNSW

Purpose of Issue:
PLANNING

EE Cell ID:	MBNL Cell ID:	Cell ID:
88222	MAN639	M1429
Master Drawing No:		
MAN24033_M001		
Issue:		
A		






Antenna Aperture ID	Proposed 4G/5G Bearing
A1	0°
A2	0°
B1	120°
B2	120°
C1	240°
C2	240°

NOTES:

1. ALL DIMENSIONS IN MM UNLESS OTHERWISE NOTED.

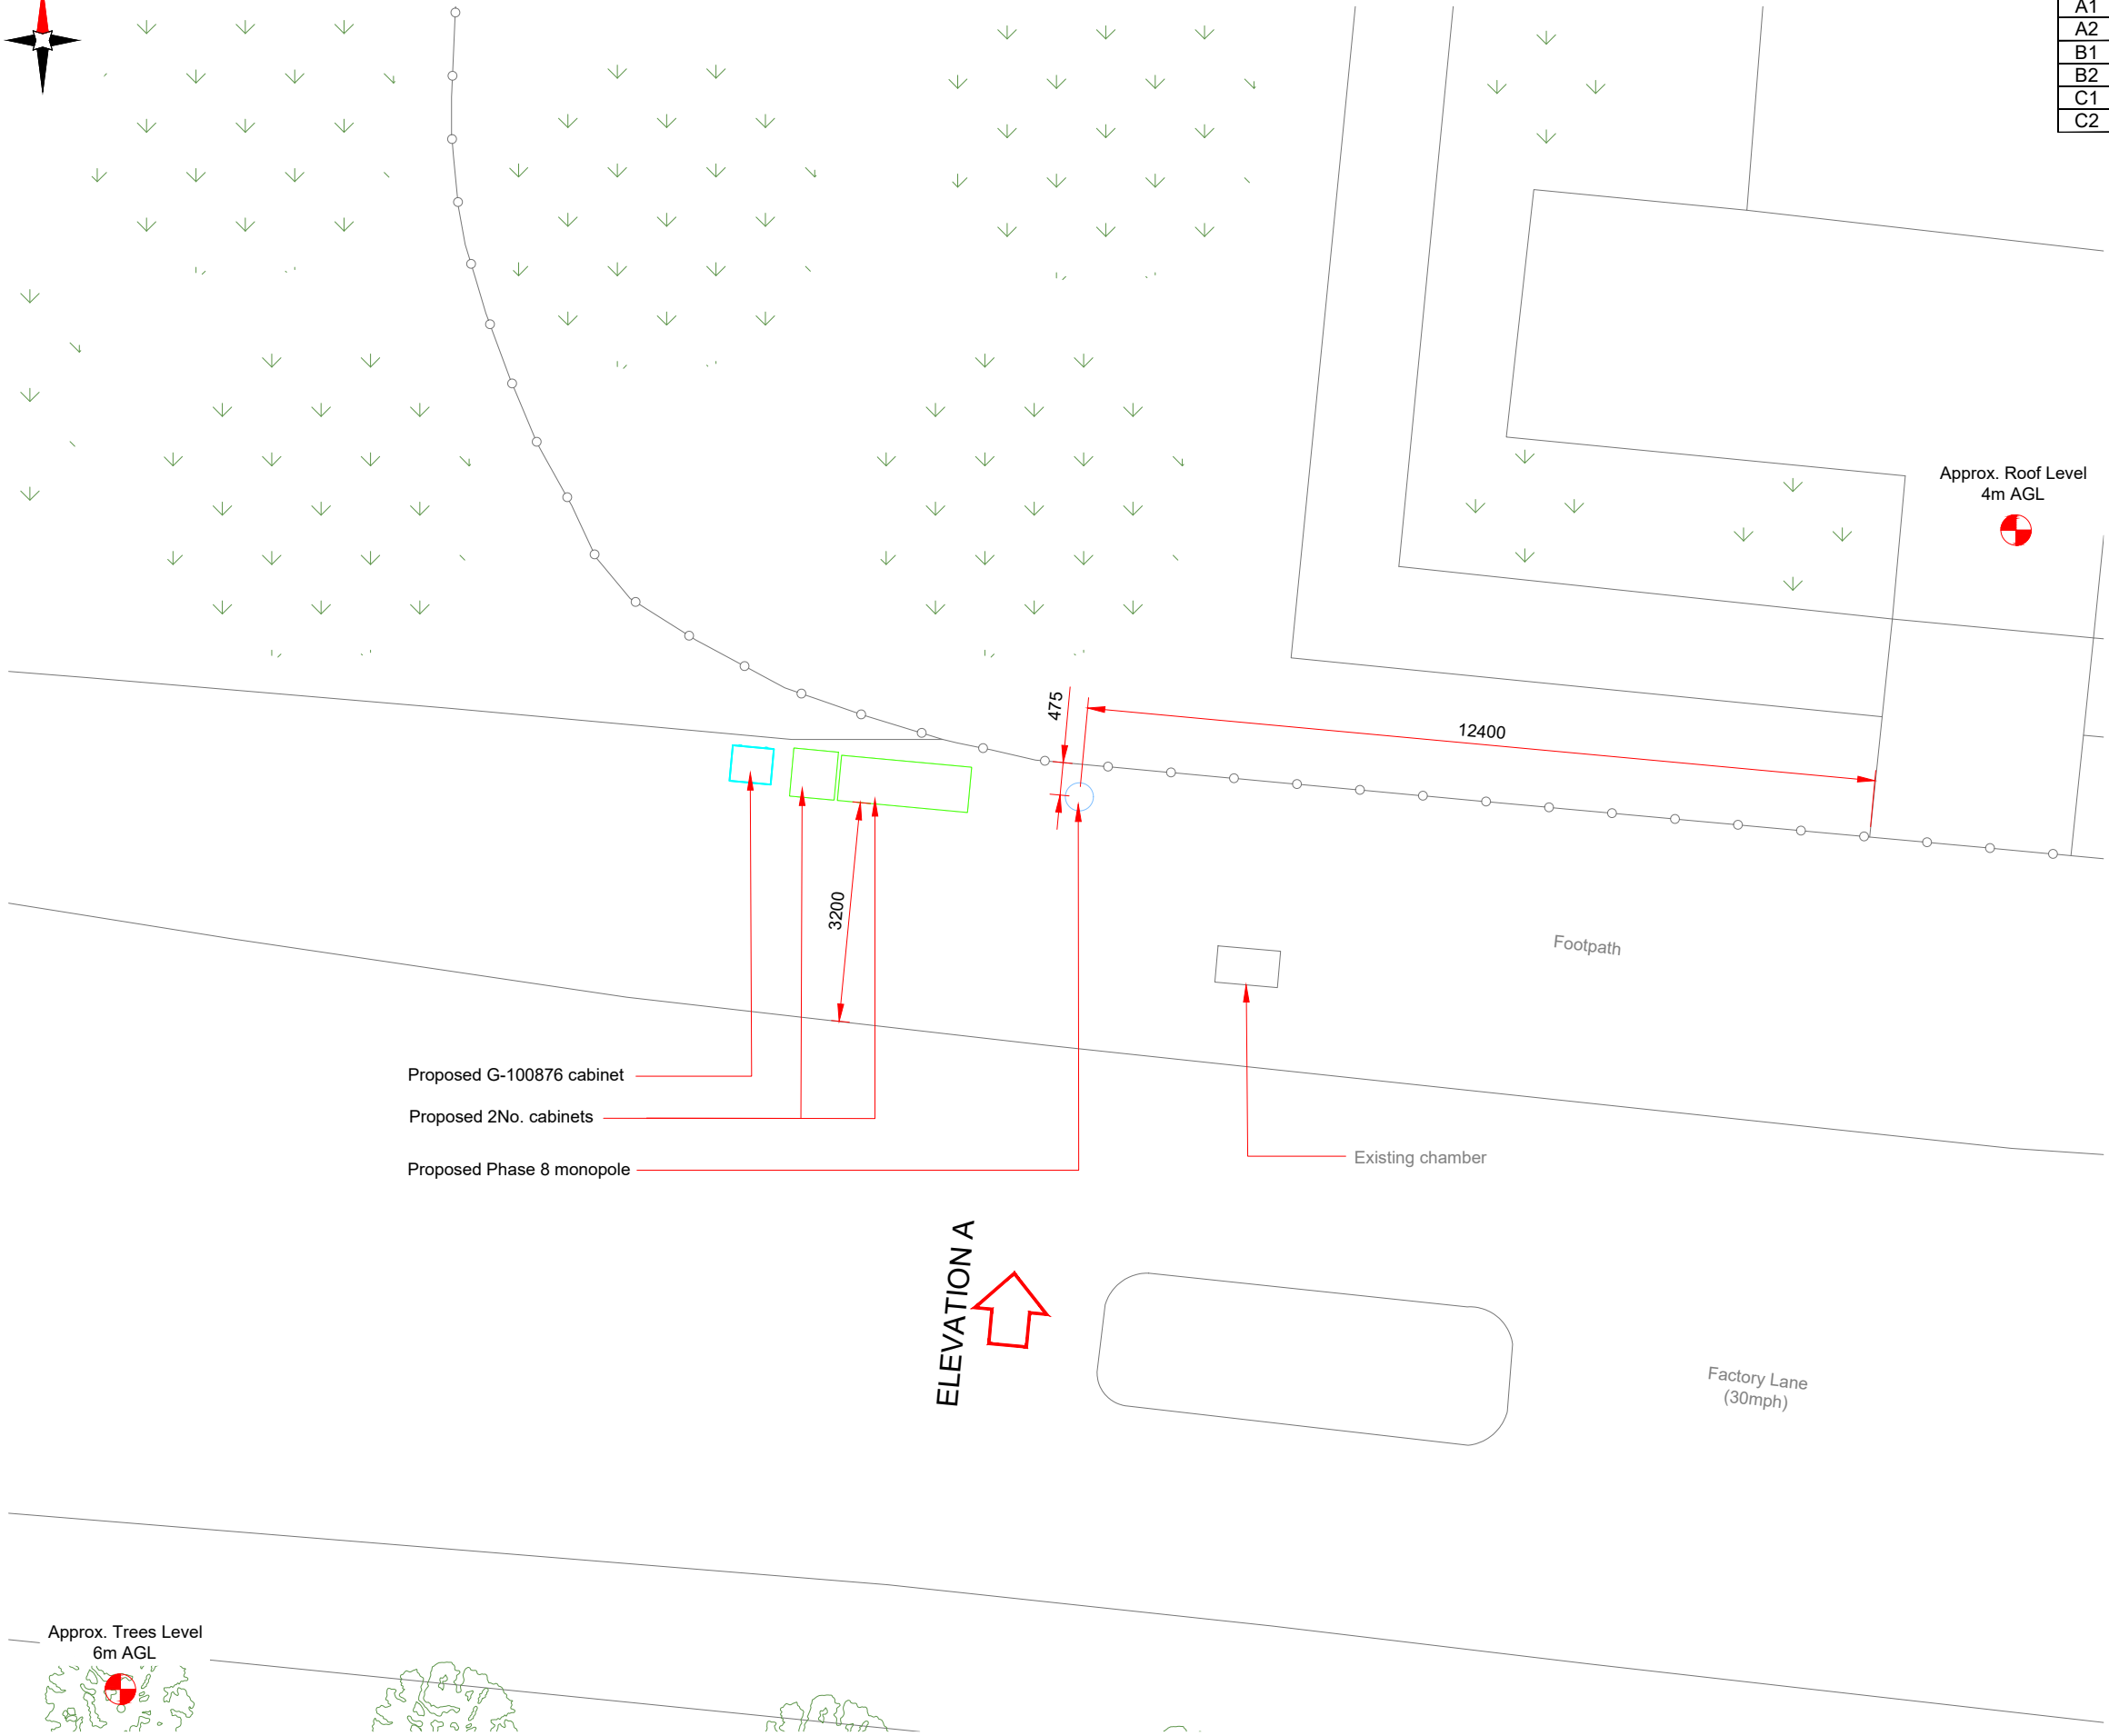


Proposed G-100876 cabinet

Proposed 2No. cabinets

Proposed Phase 8 monopole

Existing chamber

 ELEVATION A



Master:	MBNL / EE:	Project:	Purpose of Issue:	Issue:
M001	MBNL	3UK DNSW	Planning	A
Date:	30/01/2023	Revision / Upgrade Description:		
Drawn:	CDN	First Issue - Site nomination dated: TBC		
Checked:	DH			
Approved:	SD			

CK Hutchison Networks (UK) Limited

Great Brighams Mead,
Vastern Road, Reading,
Berkshire, England,
RG1 8DJ



WHP Telecoms

Unit 1 Maple Park,
Low Fields Avenue, Leeds
LS12 6HH


Tel: 01133023550
e-mail: info@whptelecoms.com

Site Name:		
FACTORY LANE STREETWORKS		
Site ID:		
MAN24033		
Address:		
FACTORY LANE, HARPURHEY, MANCHESTER, GREATER MANCHESTER, ENGLAND, M9 8AB		
Title:		
210 PROPOSED SITE PLAN		
Project:		
3UK DNSW		
Purpose of Issue:		
PLANNING		
EE Cell ID:	MBNL Cell ID:	Cell ID:
88222	MAN639	M1429
Master Drawing No:		Issue:
MAN24033_M001		A

Antenna Aperture ID	Proposed 4G/5G Bearing
A1	0°
A2	0°
B1	120°
B2	120°
C1	240°
C2	240°

NOTES:

1. ALL DIMENSIONS IN MM UNLESS OTHERWISE NOTED.

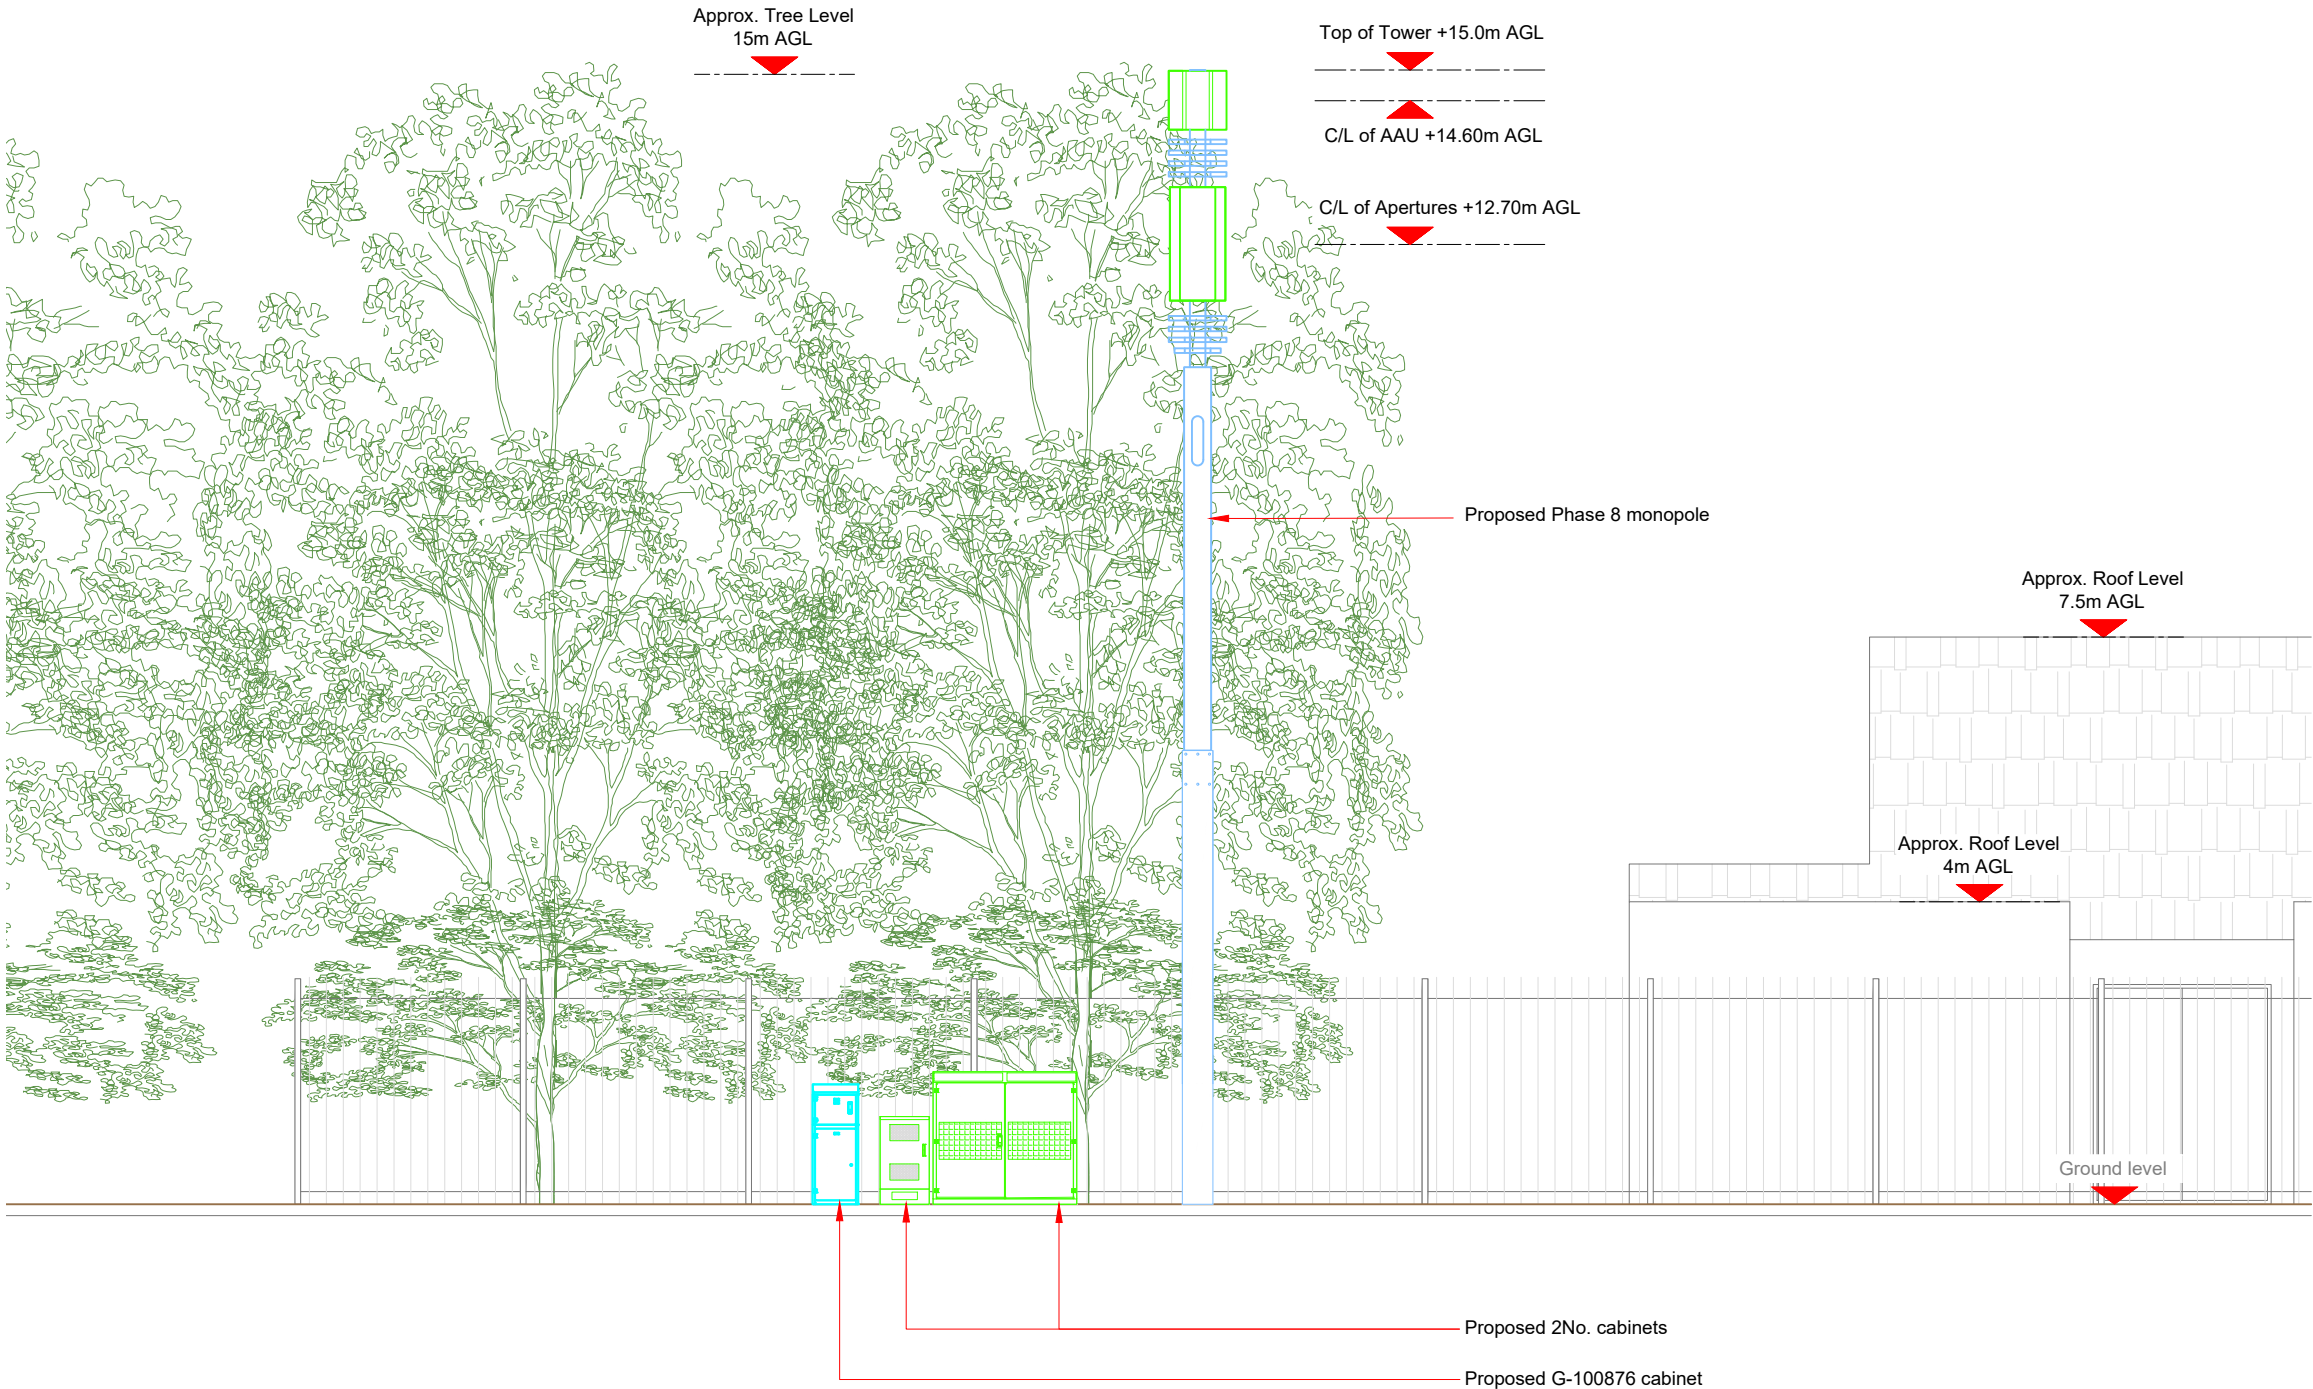

Master: M001	MBNL / EE: MBNL	Project: 3UK DNSW	Purpose of Issue: Planning	Issue: A
Date: 30/01/2023	Revision / Upgrade Description: First Issue - Site nomination dated: TBC			
Drawn: CDN				
Checked: DH				
Approved: SD				
CK Hutchison Networks (UK) Limited Great Brighams Mead, Vastern Road, Reading, Berkshire, England, RG1 8DJ				
Design Consultant & Principal Contractor:				
 WHP Telecoms Unit 1 Maple Park, Low Fields Avenue, Leeds LS12 6HH Tel: 01133023550 e-mail: info@whptelecoms.com				
Site Name: FACTORY LANE STREETWORKS				
Site ID: MAN24033				
Address: FACTORY LANE, HARPURHEY, MANCHESTER, GREATER MANCHESTER, ENGLAND, M9 8AB				
Title: 260 PROPOSED ELEVATION				
Project: 3UK DNSW				
Purpose of Issue: PLANNING				
EE Cell ID: 88222		MBNL Cell ID: MAN639		Cell ID: M1429
Master Drawing No: MAN24033_M001				Issue: A