




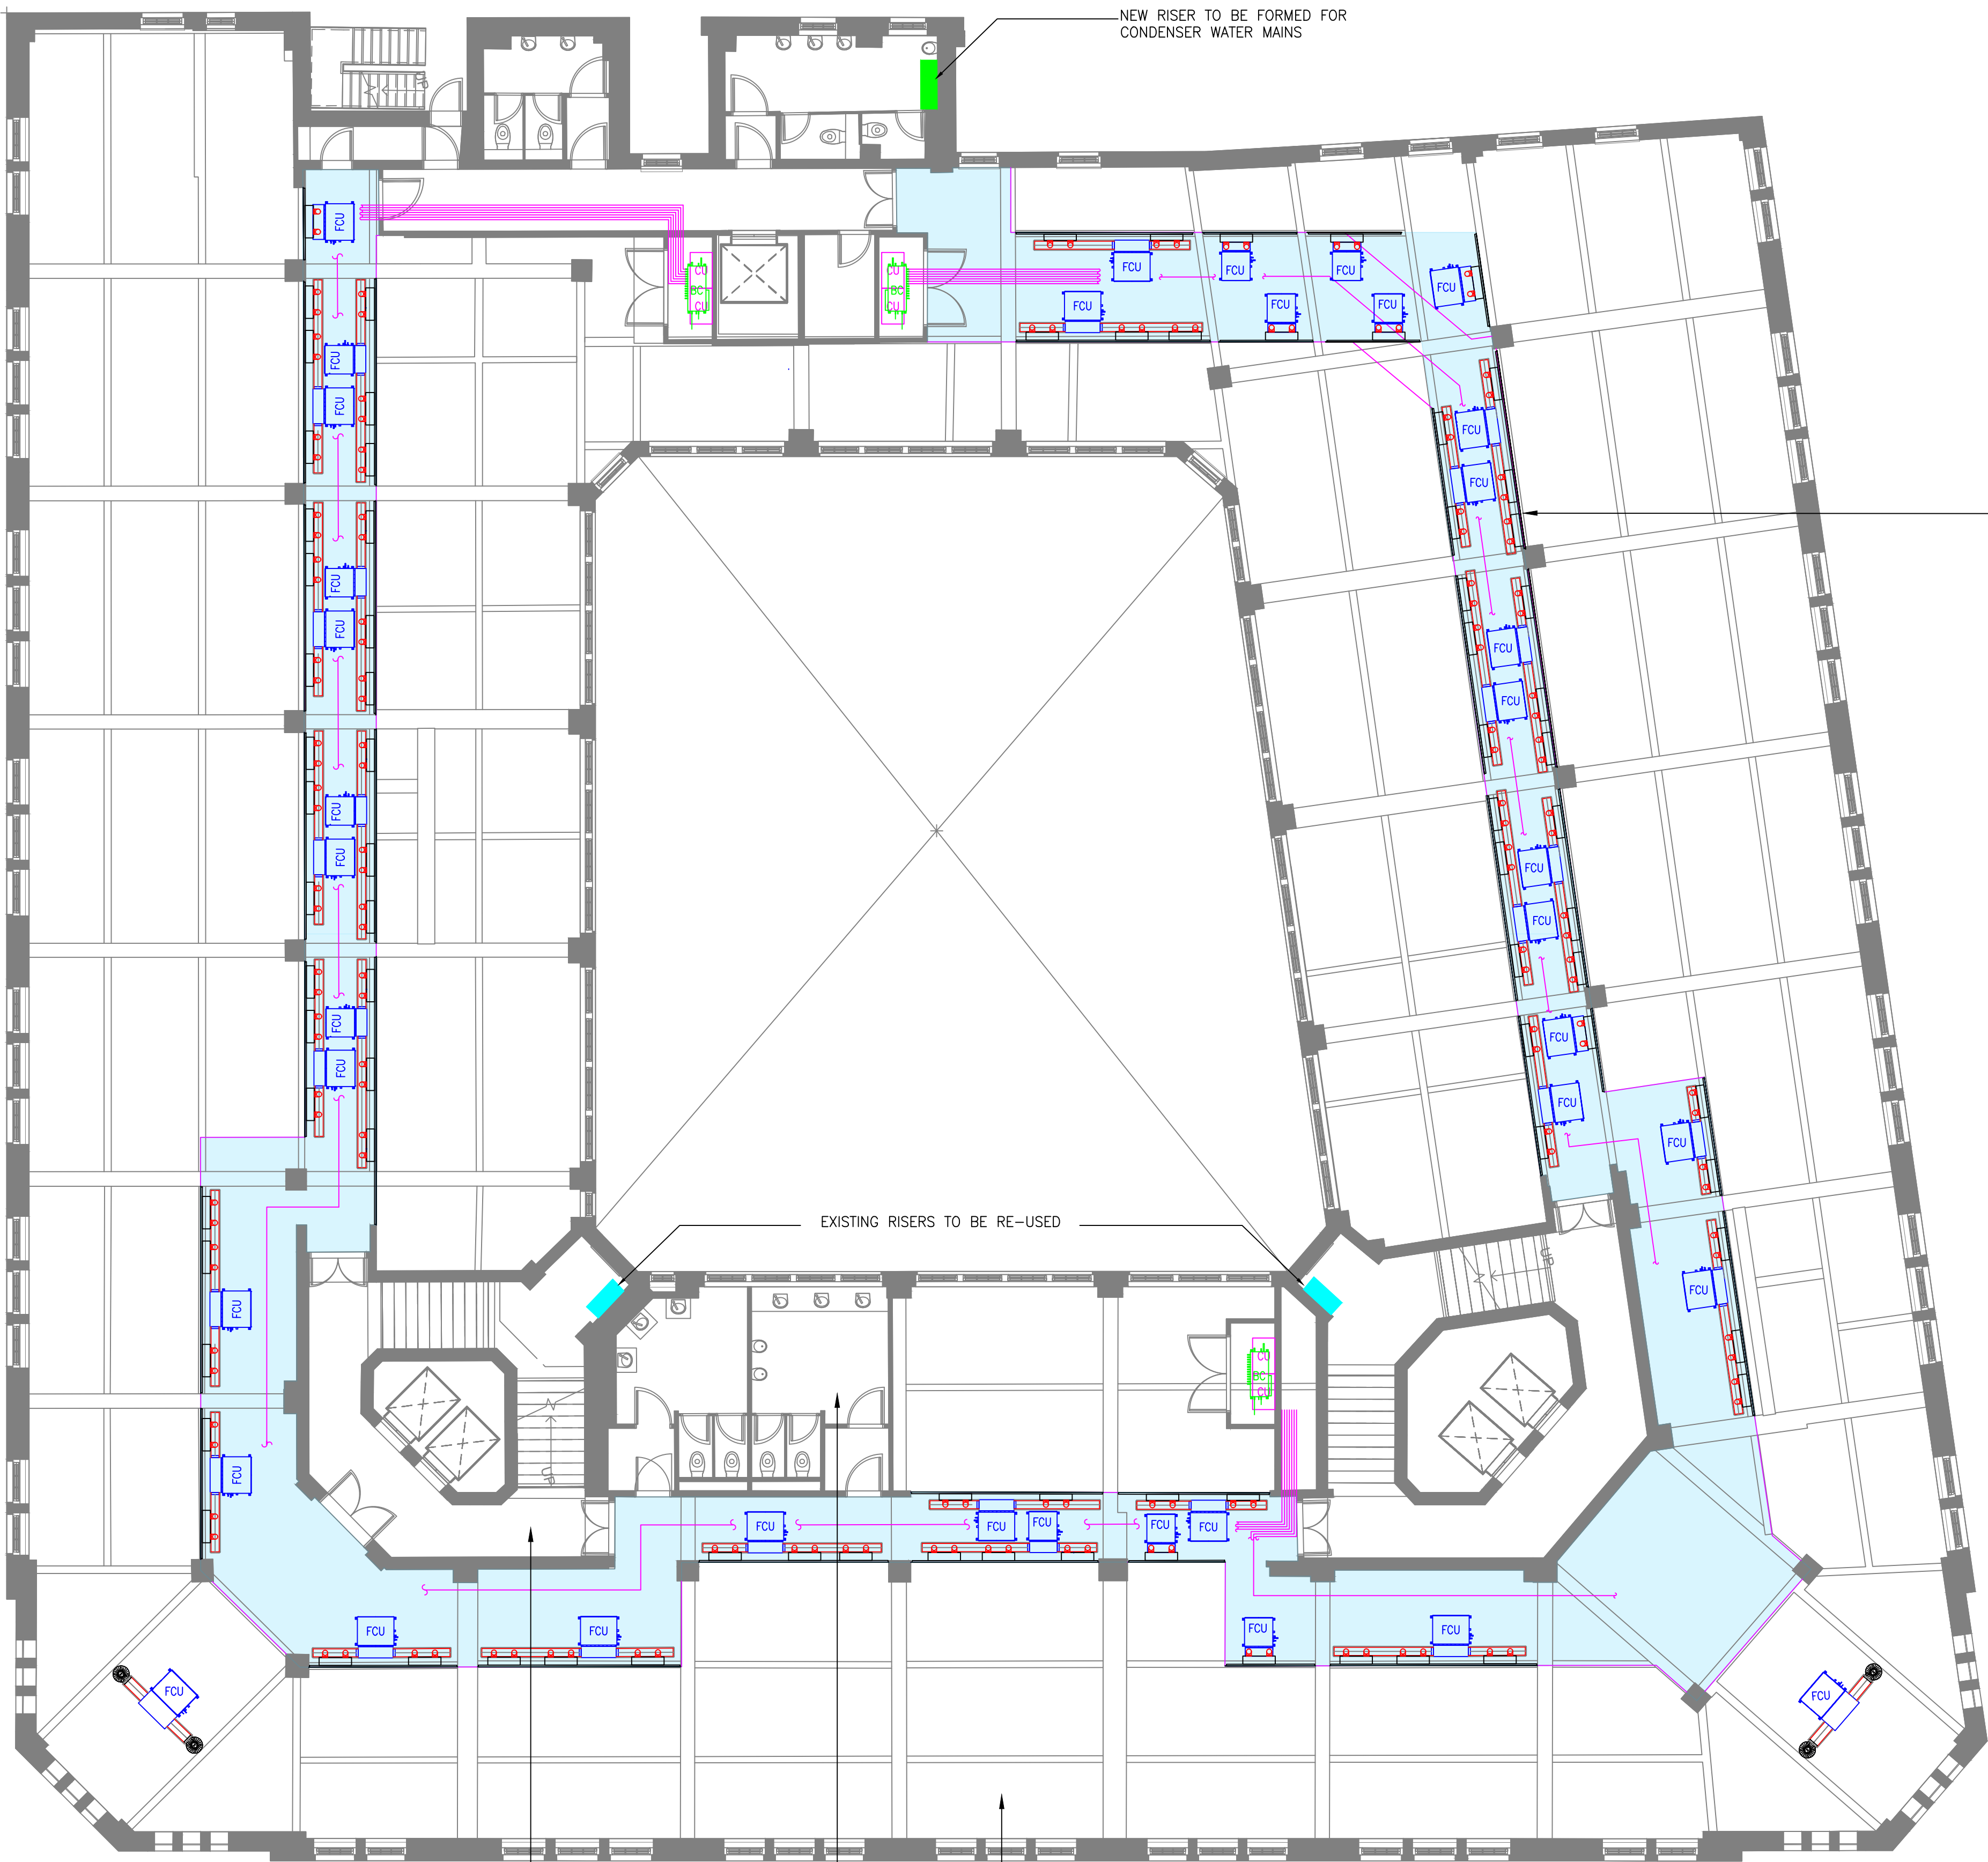

- LEGEND
- FCU CEILING VOID MOUNTED DUCTED FANCOIL UNIT
 - BC BRANCH CONTROLLER BOX MOUNTED AT HIGH LEVEL
 - CU WATER COOLED CONDENSER UNIT MOUNTED AT LOW LEVEL
 - CONTINUOUS LINEAR BAR GRILLE
 - EXISTING RISER TO BE RE-USED
 - NEW RISER TO BE RE-USED
 - HIGH LEVEL REFRIGERANT PIPEWORK
 - PROPOSED BULKHEAD

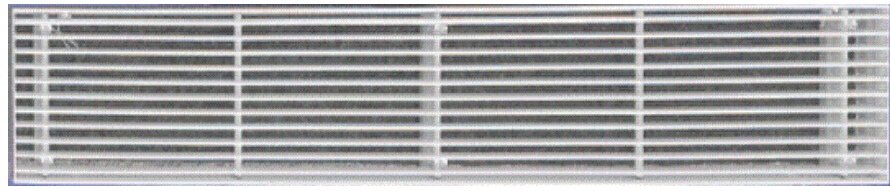


Proposed Continuous Linear Bar Grille - Mounted on side of bulkhead

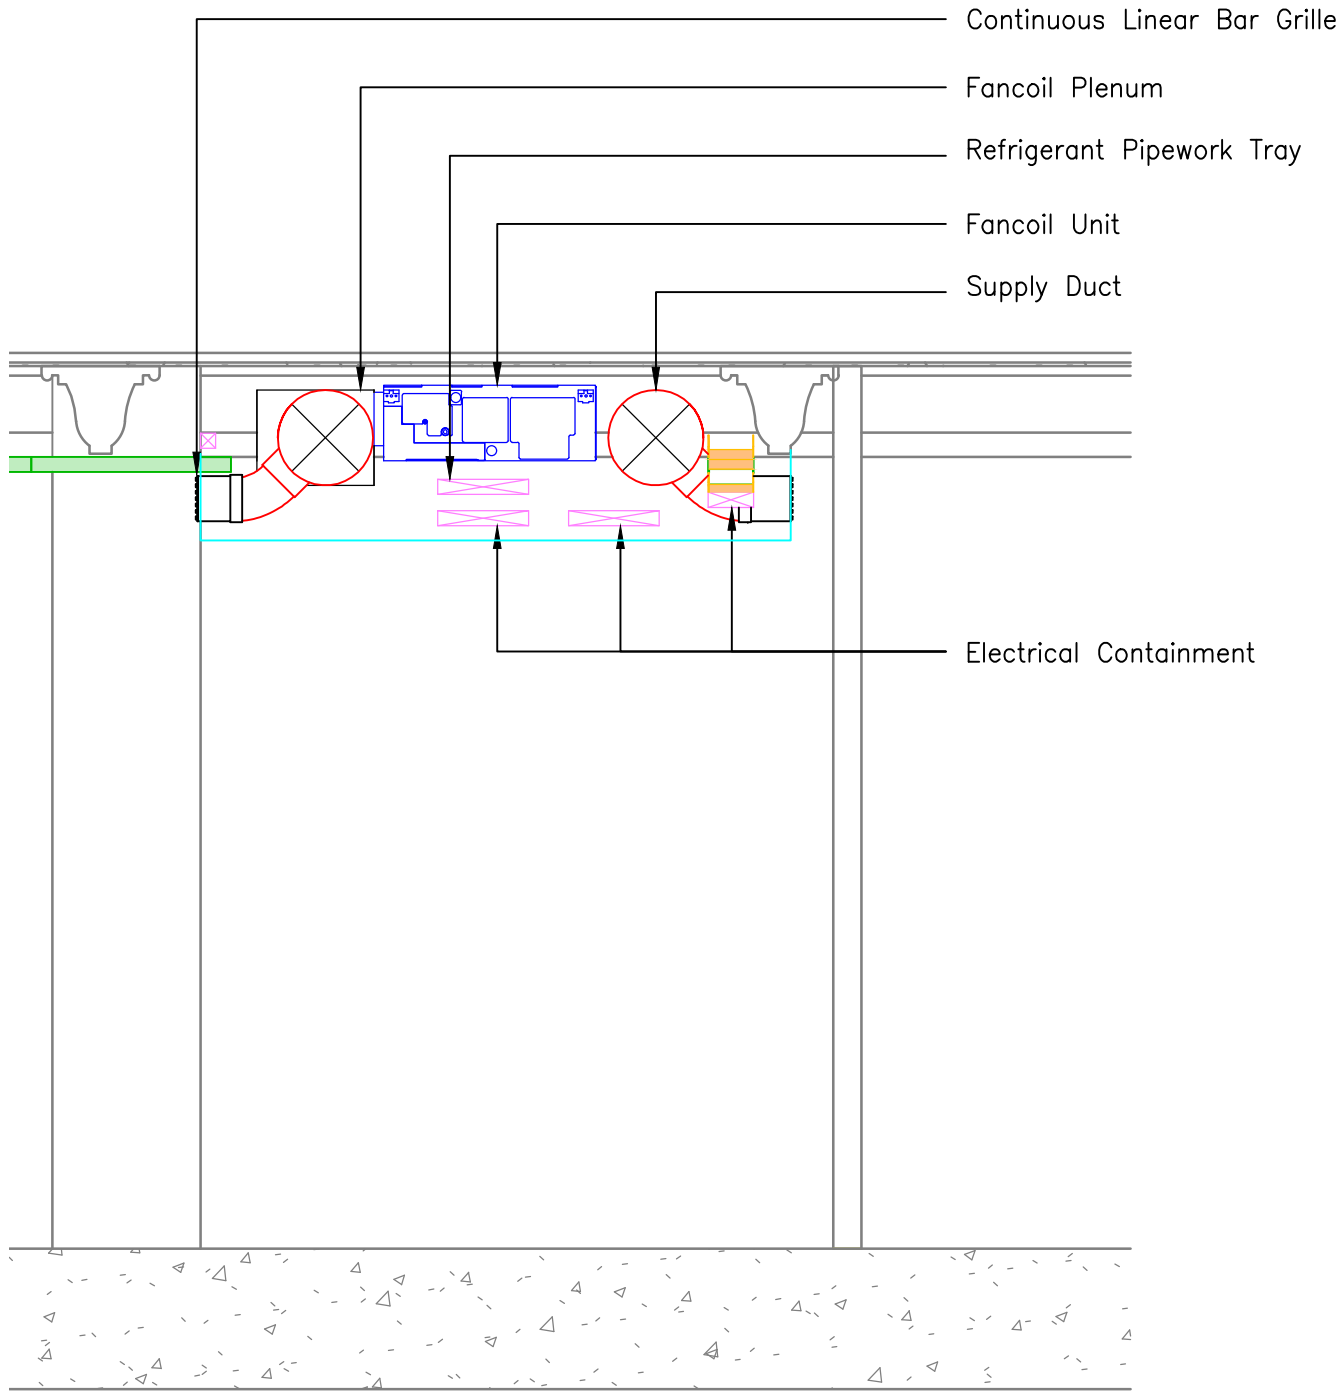

Indicative Bulkhead Section NTS

Proposed Circulation Wall/Ceiling Radiant Panel

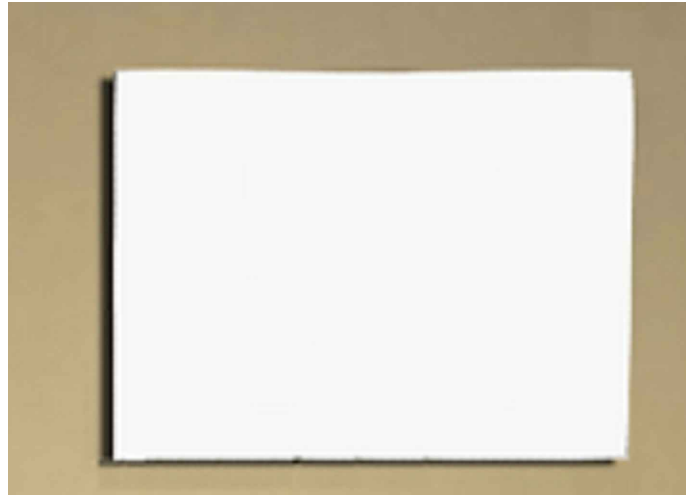

Typical Toilet Electric Column Radiator



Typical Office Floor Ceiling Strategy



Notes:

- This drawing is subject to copyright and is not to be reproduced in part or whole without approval.
- Do not scale this drawing - check all dimensions on site.
- This drawing shall be read in conjunction with the project specifications and all other contract documentation.
- All dimensions are in millimetres unless otherwise stated.

DESIGN NOTES

- THE CONTRACTOR WILL BE RESPONSIBLE FOR DEVELOPING THE DESIGN AS PART OF A 'DESIGN & BUILD' CONTRACT TO PROVIDE A COMPLETE SYSTEM TO COVER ALL AREAS OF THE DEVELOPMENT. COORDINATING AND AGREEING THE LOCATIONS OF ALL EQUIPMENT ETC WITH THE PROJECT ARCHITECT.
- THIS DRAWING IS PART OF A TENDER PACKAGE FOR A DESIGN AND BUILD CONTRACT. INFORMATION ON THE DRAWING IS PROVIDED WITHOUT PREJUDICE AND DOES NOT ABSOLVE THE CONTRACTOR FROM HIS DESIGN DUTIES AND RESPONSIBILITY.
- MECHANICAL SERVICES CONTRACTOR TO LIAISE WITH ELECTRICAL SERVICES CONTRACTOR TO ENSURE FULL CO-ORDINATION OF SERVICES.
- THE EXACT POSITION OF ALL SERVICES AND EQUIPMENT SHALL BE AGREED BY THE CONTRACT ADMINISTRATOR AND SHALL BE SET OUT OFF INTERIOR DESIGNERS LAYOUT DRAWINGS.
- ALL EQUIPMENT TO BE FULLY CO-ORDINATED BY MECHANICAL CONTRACTOR.
- THE MECHANICAL SERVICES CONTRACTOR SHALL LIAISE CLOSELY WITH THE PROJECT INTERIOR DESIGNER/ARCHITECT TO ENSURE ALL CO-ORDINATION OF DECORATIVE ELEMENTS ARE PROVIDED, PRIOR TO ANY 1ST FIX IS CARRIED OUT.

P1	20.01.23	PLANNING APPROVAL	M.H
Rev:	Date:	Status/Amendments:	By:

King Associates
2nd Floor Queens Chambers
5 John Dalton St
Manchester
M2 6ET
Email: info@kingassociates.uk
www.kingassociates.uk



Client:

KINRISE

Project:

SUNLIGHT HOUSE
MANCHESTER

Drawing Title:

MECHANICAL SERVICES
TYPICAL OFFICE FLOOR (8th)
PROPOSED REFLECTED CEILING PLAN

Engineer: M.H	Checked By: R.H	Cad By: M.E
Scale: 1:100	Paper Size: A1	Date Created: JAN 2023
Drawing Number: 4048-KIN-XX-08-DR-M-5700	Drawing Revision: P1	