


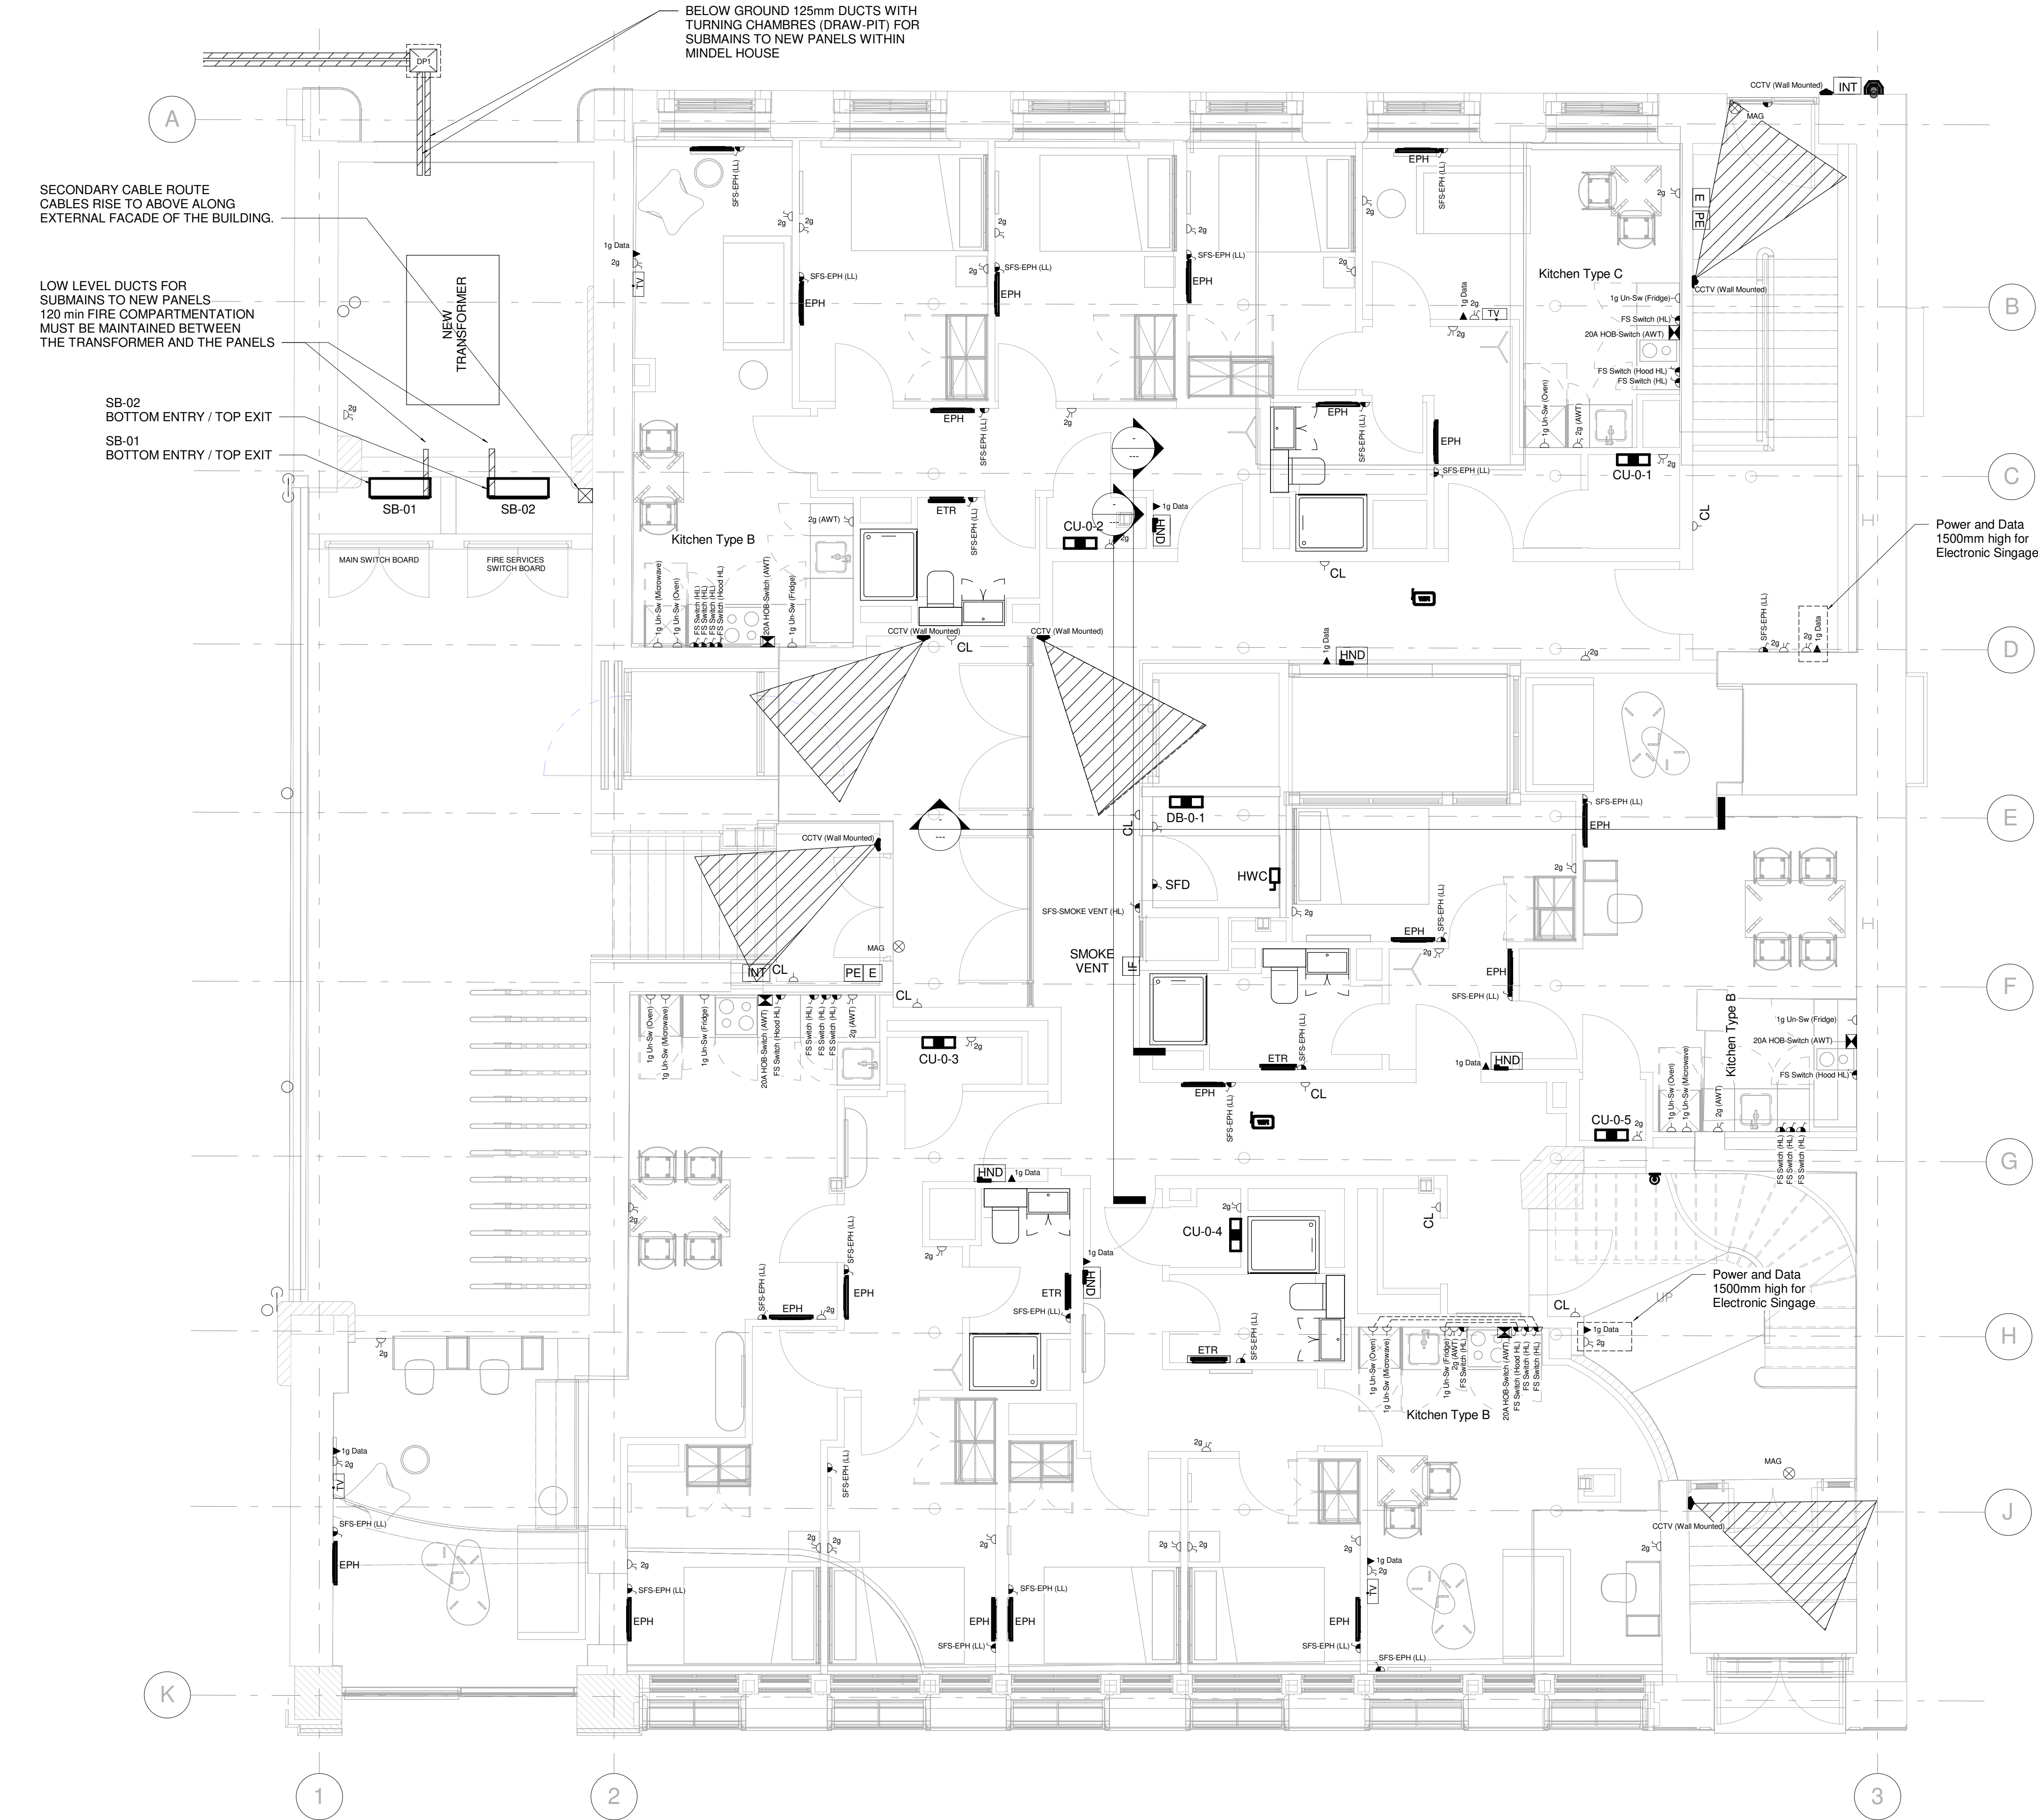

SMALL POWER LENGEND :

- CLEANERS UN-SWITCHED SINGLE SOCKET
- DOUBLE SWITCHED SOCKET OUTLET
- SIGNLE SWITCHED SOCKET OUTLET
- UN-SWITCHED FUSED SPUR
- SWITCHED FUSED SPUR
- 3 PHASE ISOLATOR
- DISTRIBUTION BOARD
- APARTMENT CONSUMER UNIT
- 45A HOB SWITCH
- SHAVING SOCKET
- 1g DATA POINT
- TV POINT
- Wifi POINT
- ELECTRICAL PANEL HEATER
- ELECTRICAL TOWEL RAIL

ABBREVIATIONS

- LL LOW LEVEL
- AWT ABOVE WORK TOP
- FS-Switch FUSED SPUR SWITCH
- SFS SWITCHED FUSE SPUR
- FS FUSED SPUR
- DB DISTRIBUTION BOARD
- CU CONSUMER UNIT
- CL CLEANERS SOCKET
- SFD SMOKE FIRE DAMPER
- EPH ELECTRICAL PANEL HEATER
- ETR ELECTRICAL TOWEL RAIL

SECURITY LEGEND :

- CCTV
- CCTV DIRECTION OF COVERAGE
- PUSH TO EXIT
- EMERGENCY BREAK GLASS (GREEN)
- INTERCOM / ACCESS PANEL
- MAG LOCK
- APARTMENT INTERCOM / ACCESS

GENERAL NOTES :

- ALL SERVICE ROUTES DETAILED ARE APPROXIMATE. THE CONTRACTOR SHALL BE RESPONSIBLE FOR DETERMINING THE EXACT ROUTES AND POSITIONS OF ALL INSTALLED SERVICES AND EQUIPMENT.
- THE EXACT POSITION OF ALL SERVICES AND EQUIPMENT SHALL BE AGREED BY THE CONTRACT ADMINISTRATOR.
- THE CONTRACTOR SHALL BE RESPONSIBLE FOR FULLY CO-ORDINATING ANY SERVICES INSTALLED WITH THE BUILDING FABRIC AND SERVICES INSTALLED BY OTHERS.
- THIS DRAWING SHALL BE READ IN CONJUNCTION WITH ALL MECHANICAL, ELECTRICAL, ARCHITECTURAL AND STRUCTURAL DRAWINGS, CONTRACT DOCUMENTATION AND SPECIFICATION FOR THE WORKS.
- THIS DRAWING FORMS PART OF THE SPECIFICATION FOR THE WORKS.
- ALL DIMENSIONS SHOWN ARE IN MILLIMETRES.
- DO NOT SCALE FROM THIS DRAWING
- THIS DRAWING SHOULD BE READ IN CONJUNCTION WITH THE REVIT MODEL PROVIDED.

Rev	Description	Issue Date
T3	Issued For Tender	06-05-22
T2	Issued For Tender	20-01-22
T1	Issued For Tender	10-09-21

Client Name :
BEECH CONSTRUCTION

Project :
BLOOM STREET

Title :
Ground Floor - Small Power, Data and Security Layout



- Burnham House, 373 Bury New Road, Manchester, M25 1AW. Tel: 0161 773 1177 manchester@parker-wilson.co.uk
- 2nd Floor, 72, Cannon Street, London EC4N 6AE. Tel: 0207 251 4500 london@parker-wilson.co.uk

www.parker-wilson.co.uk

PWC PROJECT No. 4087	Drawn by : MK	Checked by : AL
Scale 1 : 50	Size A1	Date : Issue Date
Drawing Number 4087-PWC-BS-00-PL-E-0081	Rev T3	

00 - Small Power and Security Layout
1 : 50

14/11/2022 17:23:59