


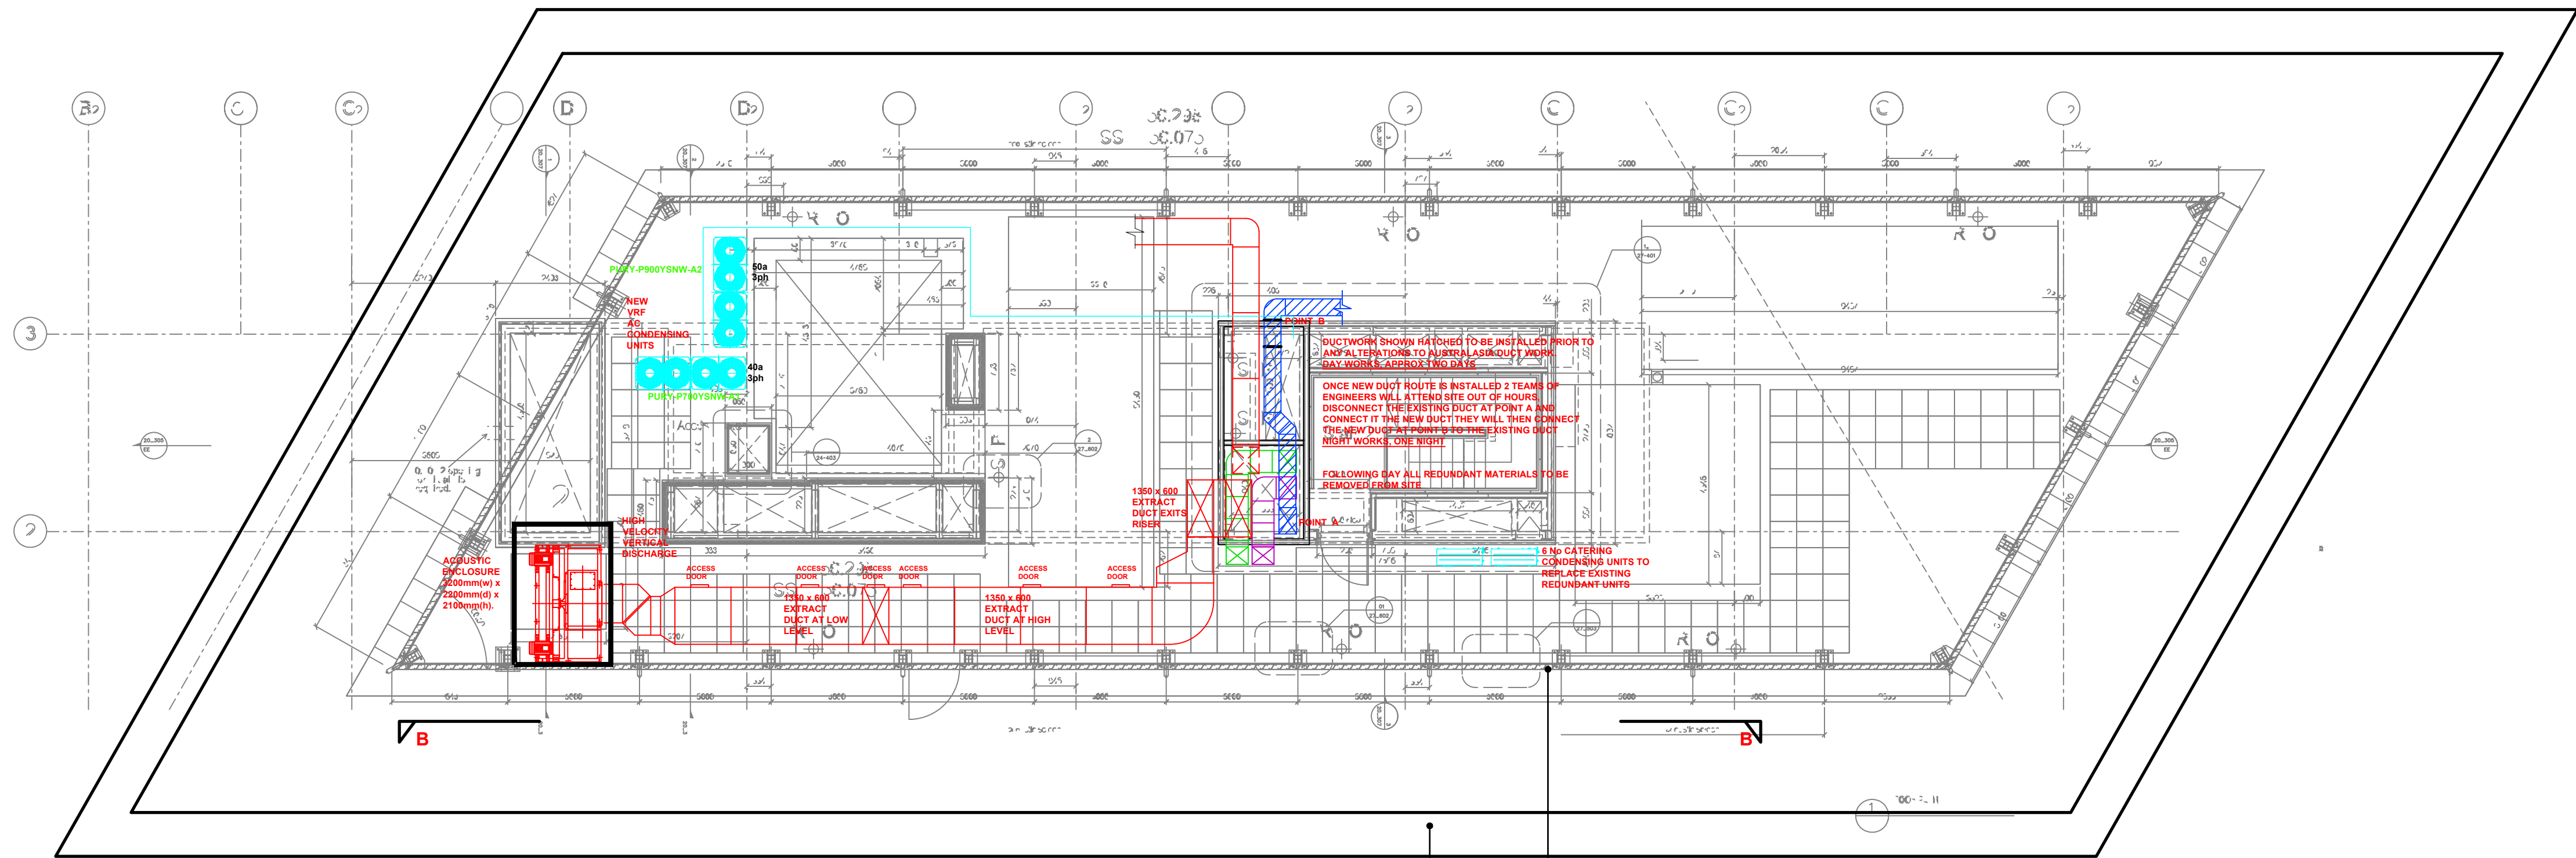

FOR MORE DETAILED PLAN REFER
TO FWP DRAWING 21368 021

LINE OF PARAPET WALL

LINE PLANT SCREENING

-	-	-
-	-	-
-	-	-
-	-	-
Rev	Date	Description

FWP
UK LTD
REFRIGERATION-AIR CONDITIONING-VENTILATION
17 Calverton Business Park
Hoyle Road
Calverton
Nottingham NG14 6QL

tel: 0115 965 5042
web: fwpuk.com

Drawn:	Checked:	Date:
-	-	--/--/----

Issue:
Provisional ☒ Approved ☐ As Built ☐ Current ☐

Site Address:
Sexy Fish
Manchester

Drawing Title:
Proposed Roof Plan

Drawing Number:	Rev:	Paper size:	Scale:
21368/022	-	A1	1:100