


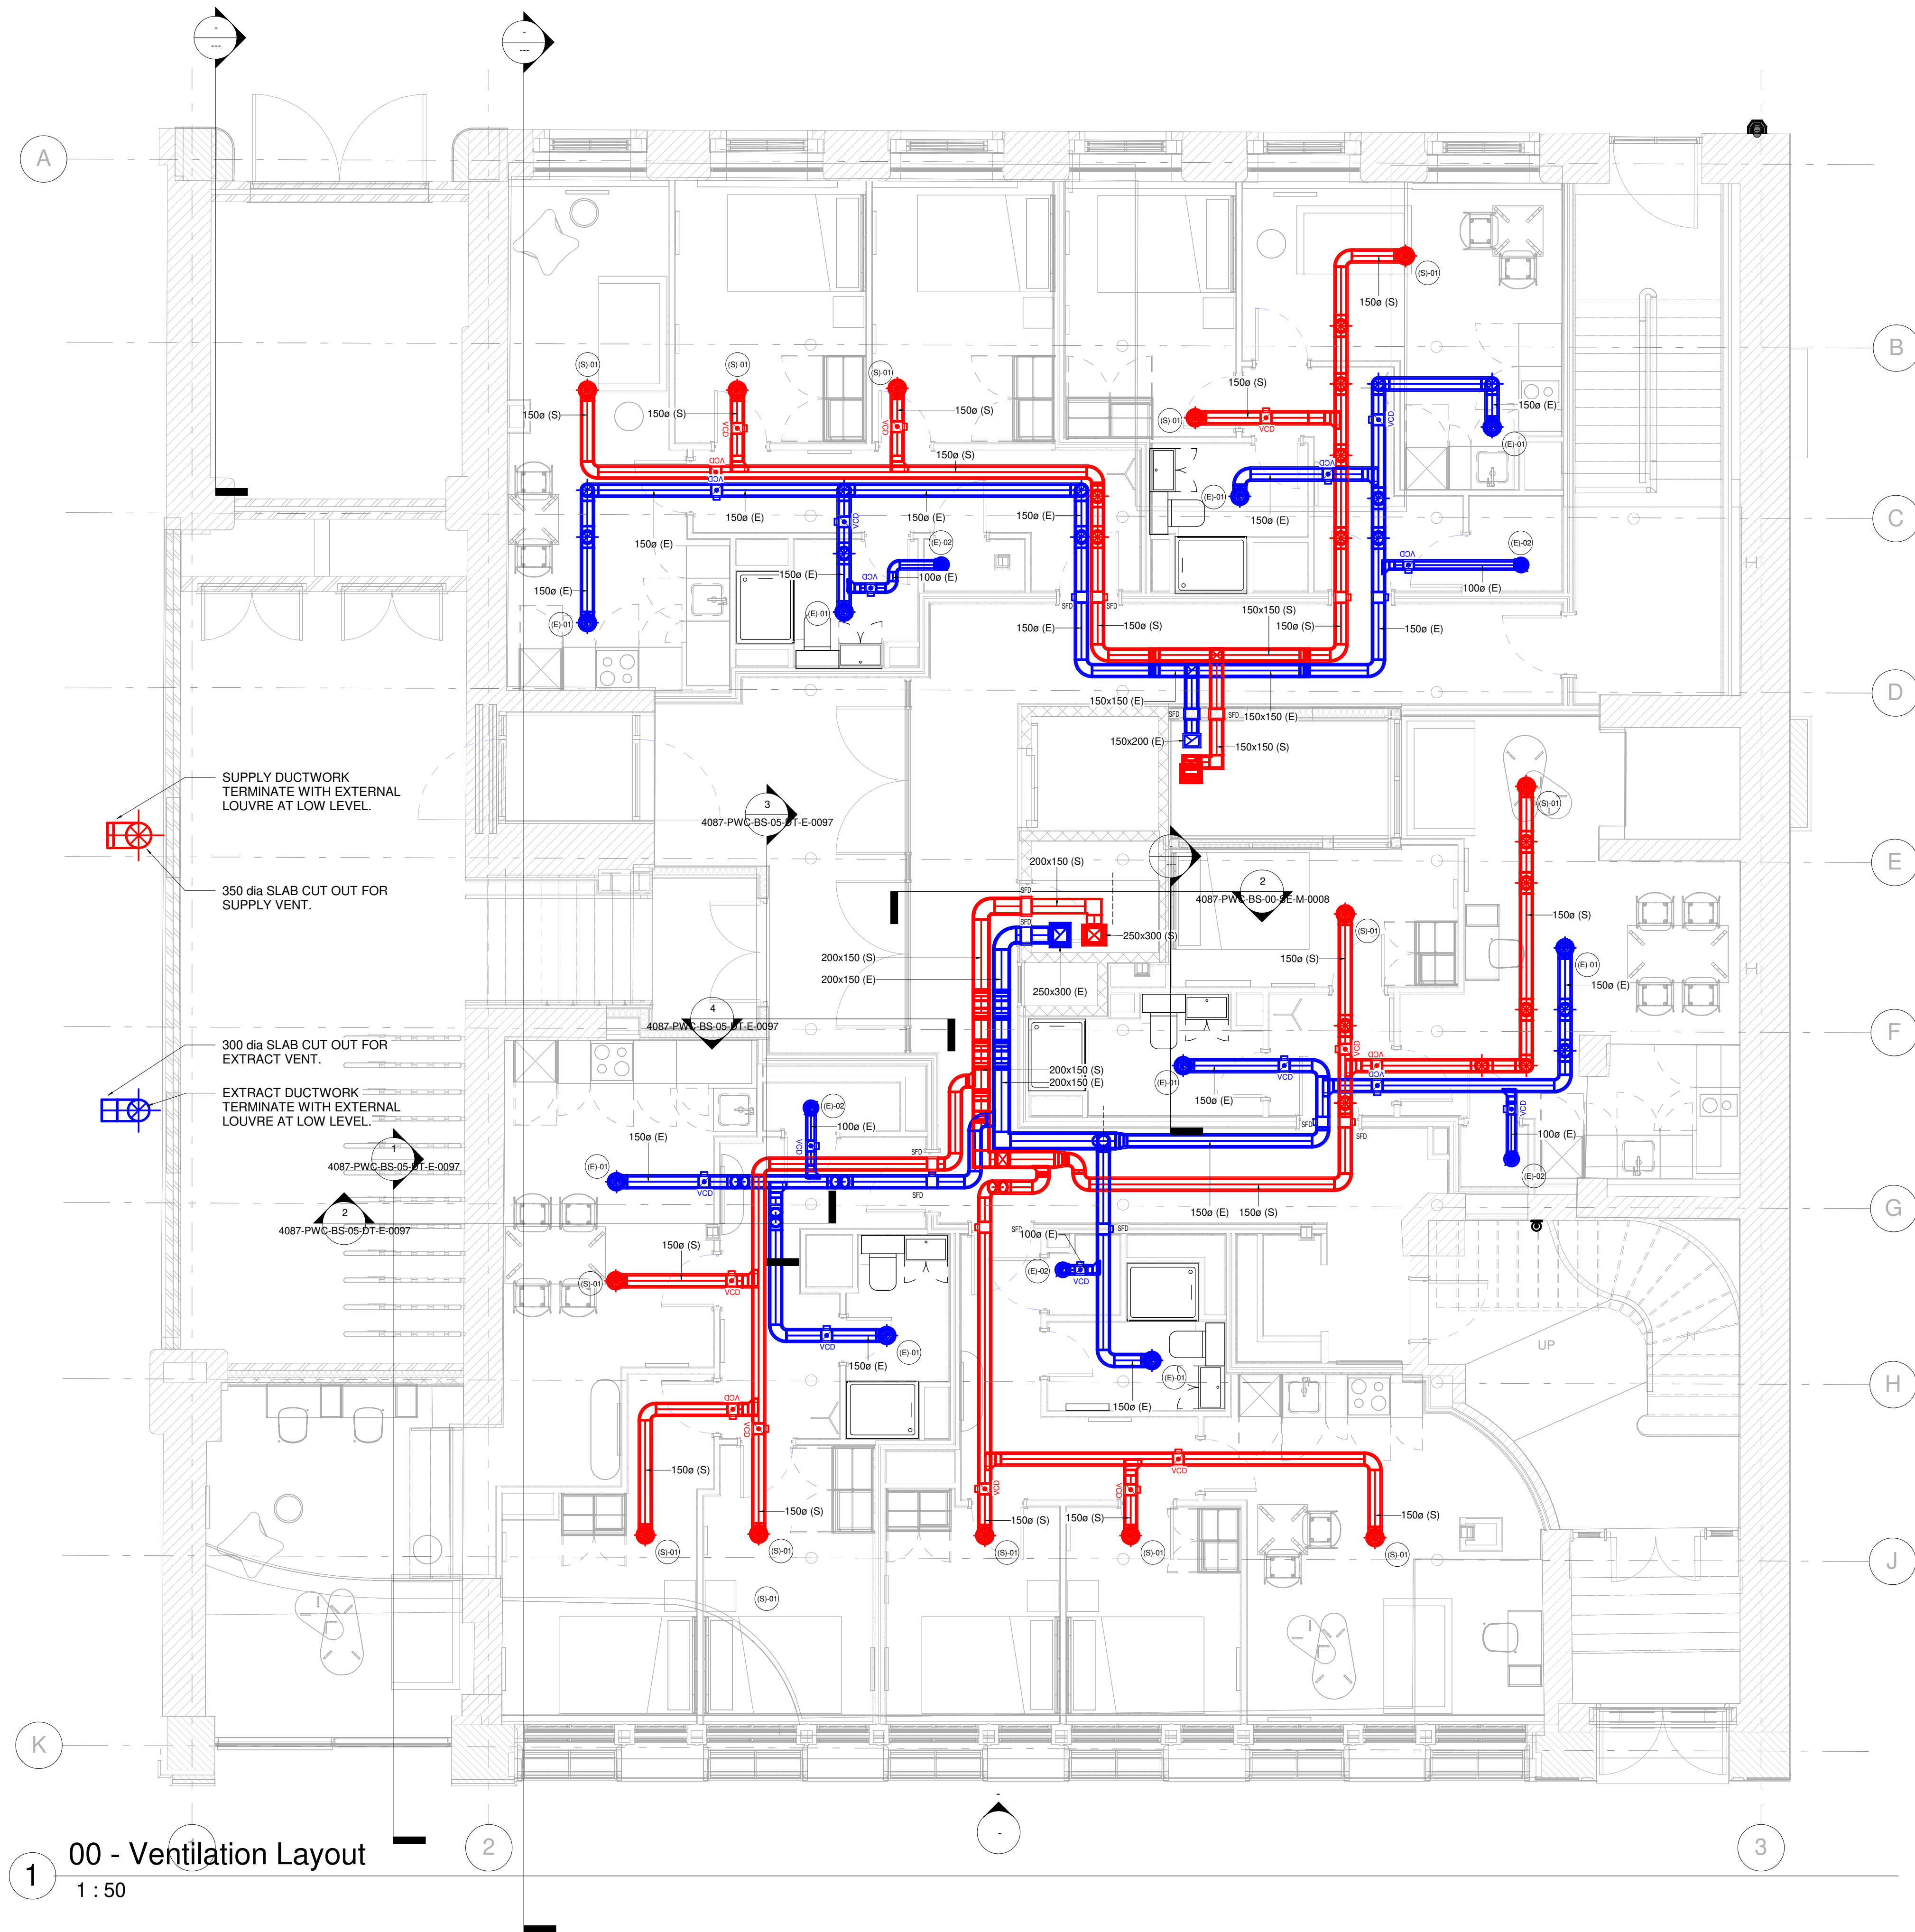

- GENERAL NOTES :
1. ALL SERVICE ROUTES DETAILED ARE APPROXIMATE. THE CONTRACTOR SHALL BE RESPONSIBLE FOR DETERMINING THE EXACT ROUTES AND POSITIONS OF ALL INSTALLED SERVICES AND EQUIPMENT.
 2. THE EXACT POSITION OF ALL SERVICES AND EQUIPMENT SHALL BE AGREED BY THE CONTRACT ADMINISTRATOR.
 3. THE CONTRACTOR SHALL BE RESPONSIBLE FOR FULLY CO-ORDINATING ANY SERVICES INSTALLED WITH THE BUILDING FABRIC AND SERVICES INSTALLED BY OTHERS.
 4. THIS DRAWING SHALL BE READ IN CONJUNCTION WITH ALL MECHANICAL, ELECTRICAL, ARCHITECTURAL AND STRUCTURAL DRAWINGS, CONTRACT DOCUMENTATION AND SPECIFICATION FOR THE WORKS.
 5. THIS DRAWING FORMS PART OF THE SPECIFICATION FOR THE WORKS.
 6. ALL DIMENSIONS SHOWN ARE IN MILLIMETRES.
 7. DO NOT SCALE FROM THIS DRAWING
 8. THIS DRAWING SHOULD BE READ IN CONJUNCTION WITH THE REVIT MODEL PROVIDED.

VENTILATION LEGEND :

- SFD
VCD
EXTRACT VALVE
SUPPLY VALVE
EXTRACT GRILLE (SIDE WALL)
VAV UNIT
BOOST SWITCH (LOCATED IN KITCHEN, NEXT TO HOB)
SUPPLY GRILLE / VALVE REFERENCE No. (REFER TO SPECIFICATION FOR DETAILS)
EXTRACT GRILLE / VALVE REFERENCE No. (REFER TO SPECIFICATION FOR DETAILS)

T6	Issued For Tender	06-05-22
T5	Issued For Tender	20-01-22
T4	Issued For Tender	10-09-21
T3	Issued For Tender	01-07-21
T2	Issued For Tender	21-05-21
T1	Issued For Tender	16-04-21
Rev	Description	Issue Date
Client Name : BEECH CONSTRUCTION		
Project : BLOOM STREET		
Title : Ground Floor - Ventilation Layout		
 Burnham House, 373 Bury New Road, Manchester, M25 1AW. Tel: 0161 773 1177 manchester@parker-wilson.co.uk 2nd Floor, 72, Cannon Street, London EC4N 6AE. Tel: 0207 251 4500 london@parker-wilson.co.uk www.parker-wilson.co.uk		
PWC PROJECT No. 4087	Drawn by : MK	Checked by : PG
Scale 1 : 50	Size A1	Date : Issue Date
Drawing Number 4087-PWC-BS-00-PL-M-0002	Rev T6	

1 00 - Ventilation Layout
1 : 50