




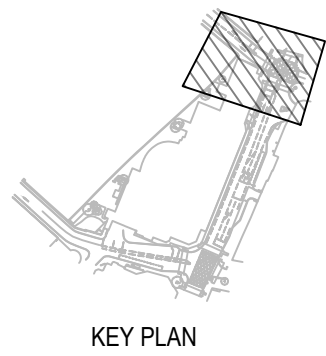

VIEW 001

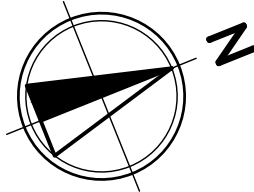

VIEW 002

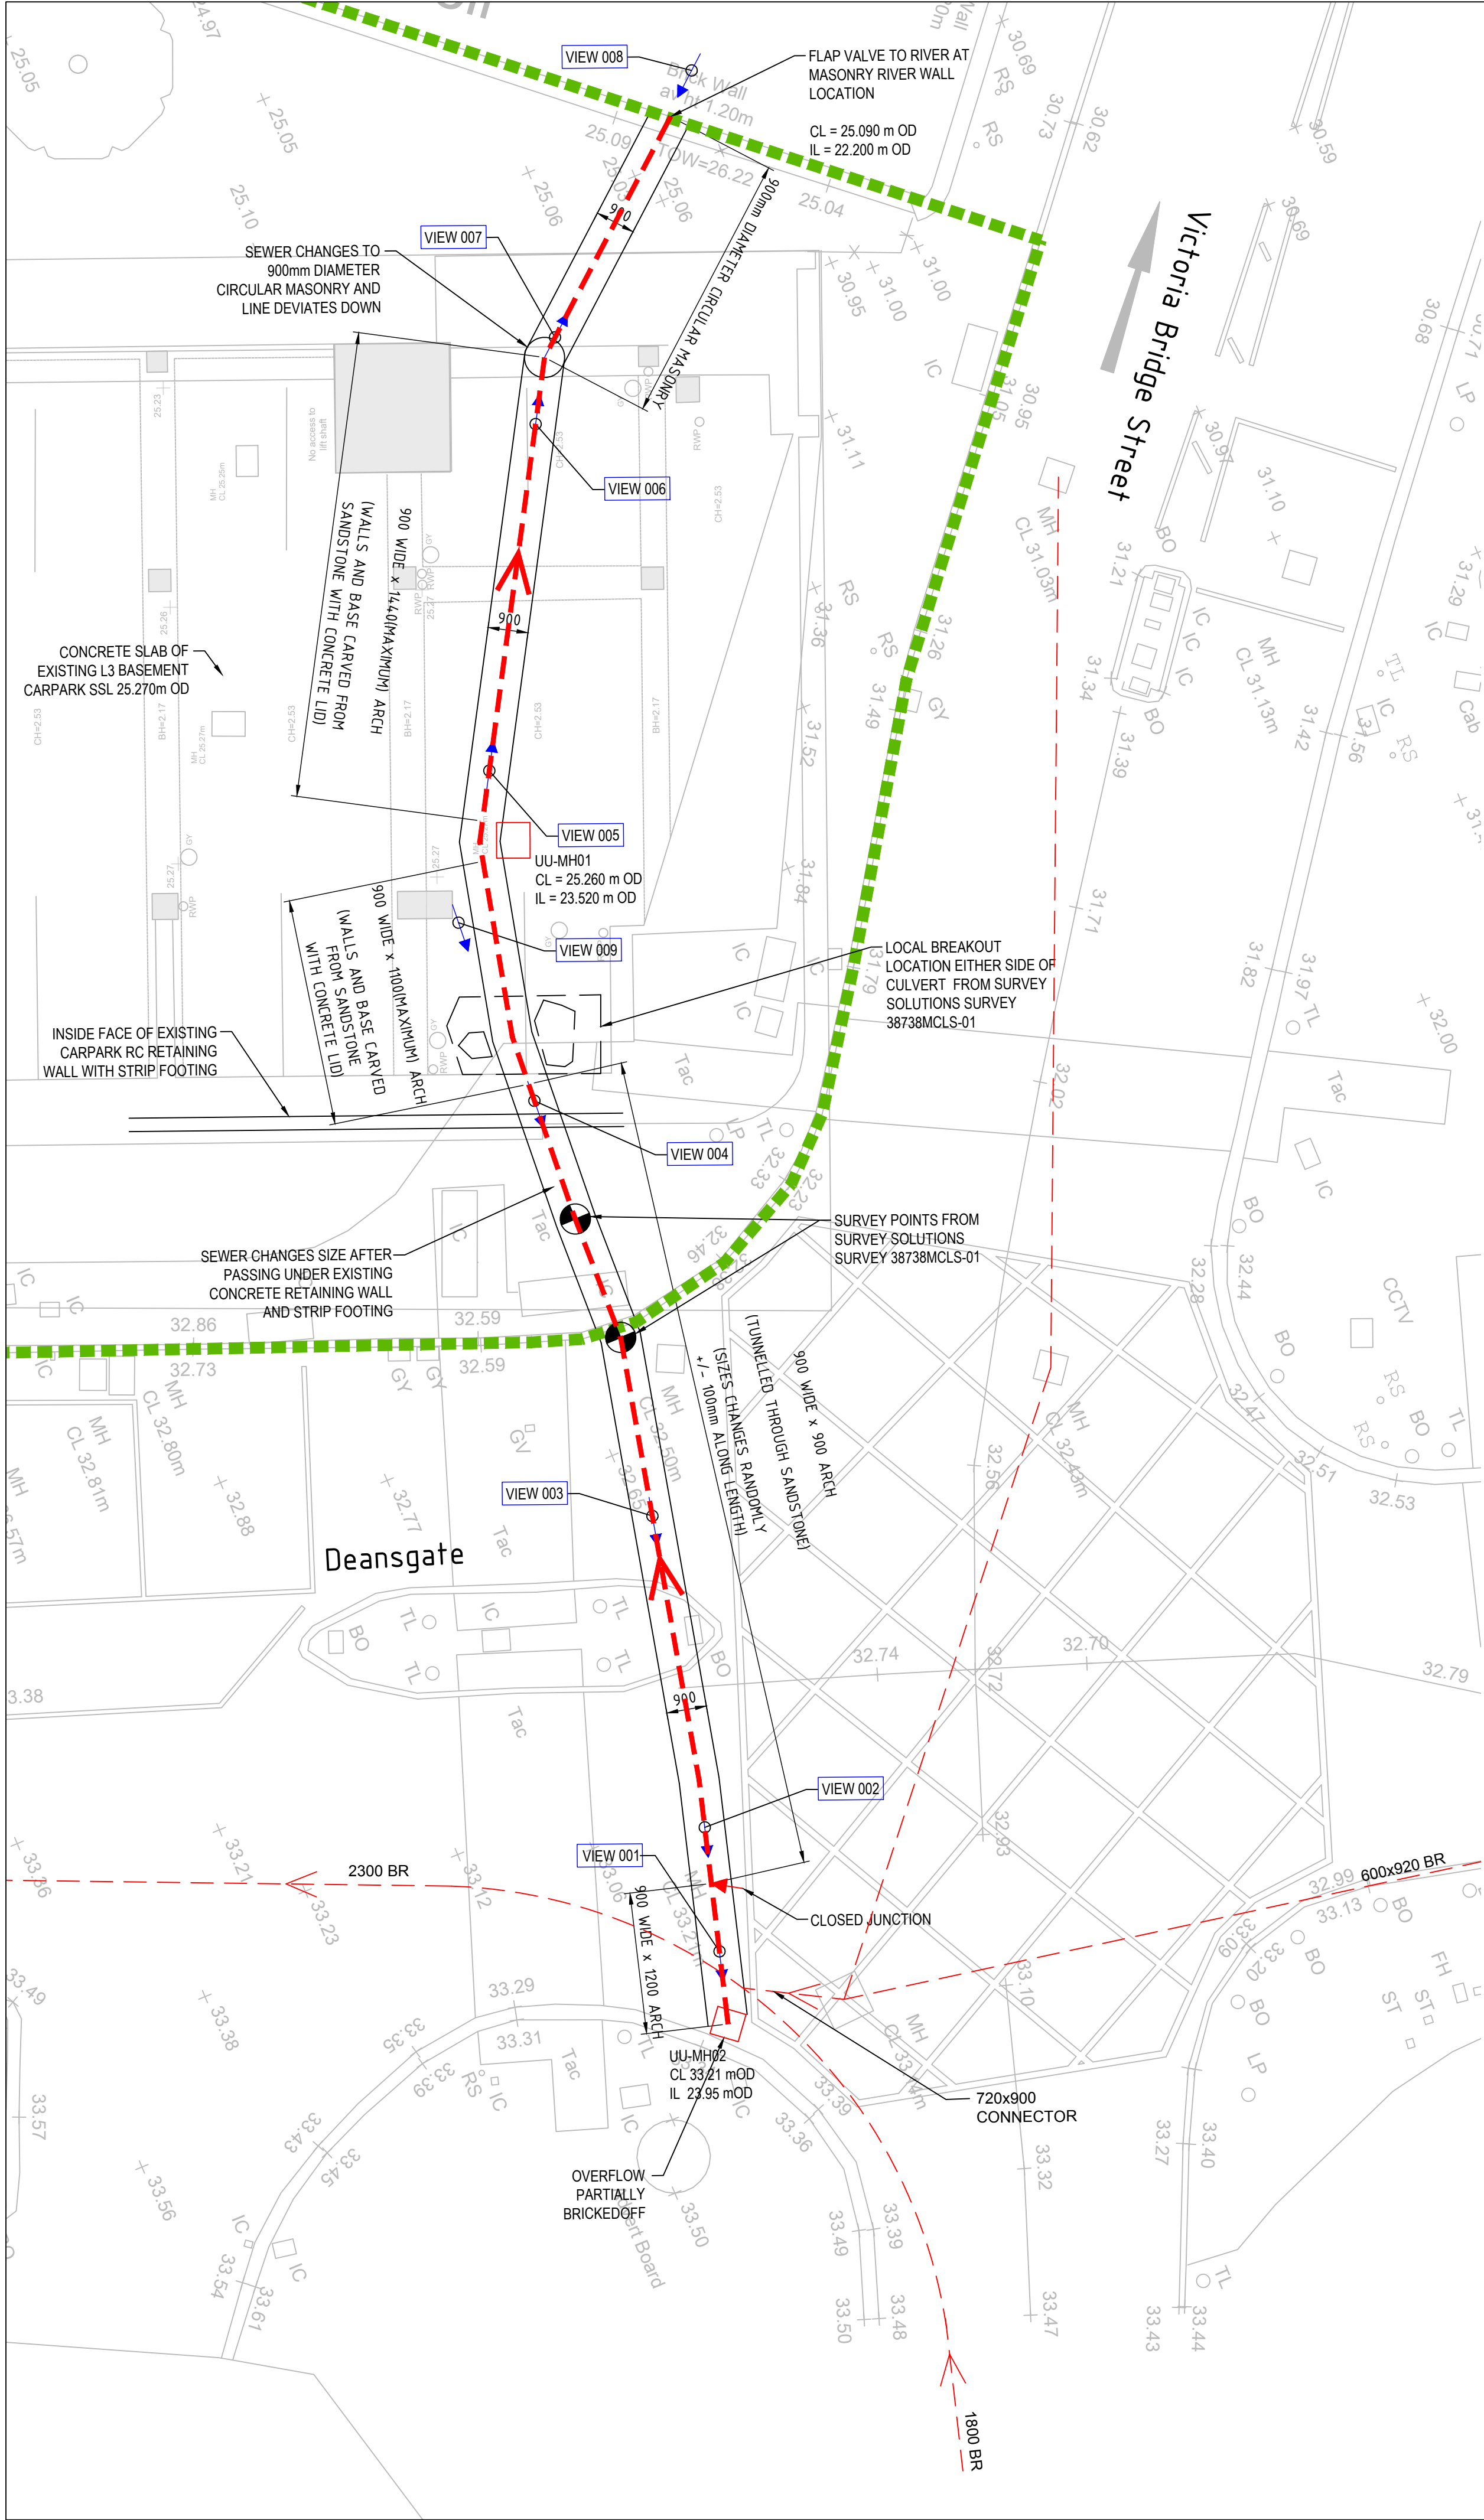

VIEW 003



VIEW 004



VIEW 005




VIEW 006



VIEW 007



VIEW 008

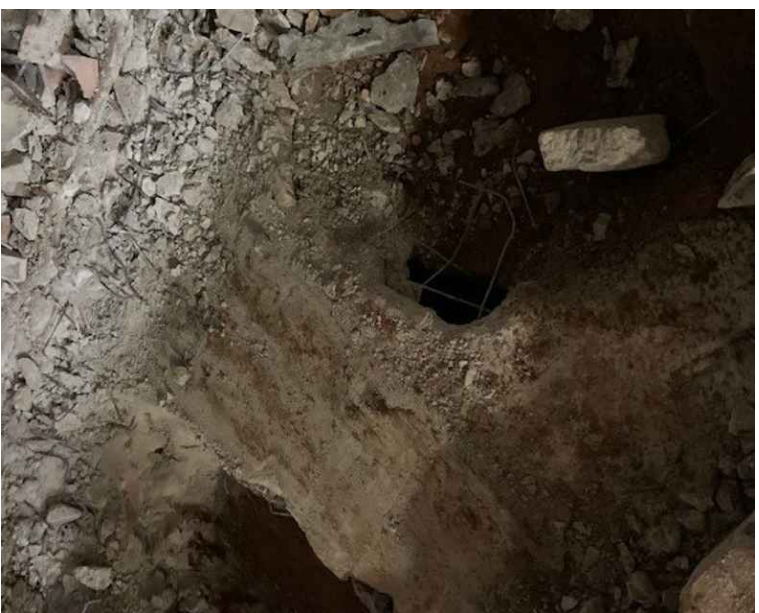

VIEW 009

NOTES:

- REFER TO SPECIFIC UNITED UTILITIES NORTHERN SEWER BUILD OVER NOTES ON DRAWING REN-BGE-C-GEN-035. THIS INCLUDES REQUIREMENTS FOR
  - ADDITIONAL POST DEMOLITION SURVEY;
  - UNITED UTILITIES APPROVAL;
  - TEMPORARY STAGE CONSTRUCTION SEQUENCING;
  - SURVEY DURING CONSTRUCTION;
  - SURVEY POST CONSTRUCTION;
- REFER TO GENERAL CIVIL NOTES DRAWING REN-BGE-C-GEN-005.
- THE COMPLETENESS OF THE UNDERGROUND SERVICE INFORMATION IS BASED ON CURRENT INFORMATION AND SURVEYS AND CANNOT BE GUARANTEED.
- TOPOGRAPHIC SURVEY AS PER ZS SURVEYS DRAWING: "AAP - Deansgate - Manchester 2074\_3-MBS" RECEIVED 03/02/2021.
- EXISTING STRUCTURE PLAN SURVEYS AS PER ZS SURVEYS DRAWINGS: "AAP - Deansgate, Manchester 2074\_3-MBS" RECEIVED 07/10/2021.
- UNITED UTILITIES SITE ADJACENT SEWER POSITIONS BASED ON THE FOLLOWING INFORMATION:
  - UNITED UTILITIES SEWER RECORDS "UU - 250037-19-02-2021-02-39-22" DATED 19/02/2021.
  - TEAM DRAINAGE CCTV SURVEY "MH CARD 7602 Deansgate Manchester" RECEIVED 28/07/2021.
- UNITED UTILITIES NORTHERN SEWER OVERRUN POSITION BASED ON THE FOLLOWING INFORMATION:
  - UNITED UTILITIES SEWER RECORDS "UU - 250037-19-02-2021-02-39-22" DATED 19/02/2021.
  - TEAM DRAINAGE CCTV SURVEY "Blackfriar Street MCR 4\_11" DATED 05/11/2021.
  - SURVEY SOLUTIONS LOCAL BREAKOUT AND POSITION SURVEY "38738MCLS-01" RECEIVED 21/12/2021.

LEGEND

EXISTING

- PROPOSED PVC DRAINAGE PIPES
- EXISTING FOUL WATER DRAINAGE
- EXISTING UU SEWER
- EXISTING RAIN WATER DRAINAGE TO BE DEMOLISHED/DECOMMISSIONED
- EXISTING FOUL WATER DRAINAGE TO BE DEMOLISHED/DECOMMISSIONED
- EXISTING UU SEWER TO BE DEMOLISHED/DECOMMISSIONED
- PROPOSED SURFACE WATER CHANNEL DRAINS
- PROPOSED FOUL WATER DRAINAGE
- PROPOSED UU SEWER
- DEMOLITION LINE
- SITE PLANNING BOUNDARY

| REV | DATE       | DESCRIPTION                | BY     |
|-----|------------|----------------------------|--------|
| P01 | 16.08.2022 | ISSUED TO UNITED UTILITIES | EG     |
| P00 | 14.02.2022 | ISSUED FOR STAGE 2 TENDER  | DF(CE) |
| REV | DATE       | DESCRIPTION                | RVD    |

CLIENT

PROPERTY ALLIANCE GROUP LTD

ALLIANCE

London Office —

163 Tower Bridge Road,  
London SE1 3LW  
P / +44 (0) 7999 968 245  
E / info@bgeeng.com  
bgeeng.com —

BG & E

PROJECT

RENAISSANCE

CIVIL

GENERAL

STATUS

ISSUED FOR INFORMATION


NOT TO BE ISSUED FOR CONSTRUCTION

| DRAWN  | DESIGNED | CHECKED | APPROVED   |
|--------|----------|---------|------------|
| JW     | JP(CE)   | DF(CE)  | LJK        |
| DATUM  | GRID     | SCALE   | AT A3 SIZE |
| OSGB36 | BNG      | 1:200   |            |

TITLE

UNITED UTILITIES - EXISTING NORTHERN SEWER OVERRUN - SHEET 1

| PROJECT No. | DRAWING No.       | REV |
|-------------|-------------------|-----|
| L20081      | REN-BGE-C-GEN-030 | P01 |

 

DRAWING TO BE PRINTED IN COLOUR

07/10/2022 3:46 PM