


Notes:

*Please Note:
Plans & layouts provided by others (MCC), AA Projects accept no responsibility for their accuracy or completeness.*

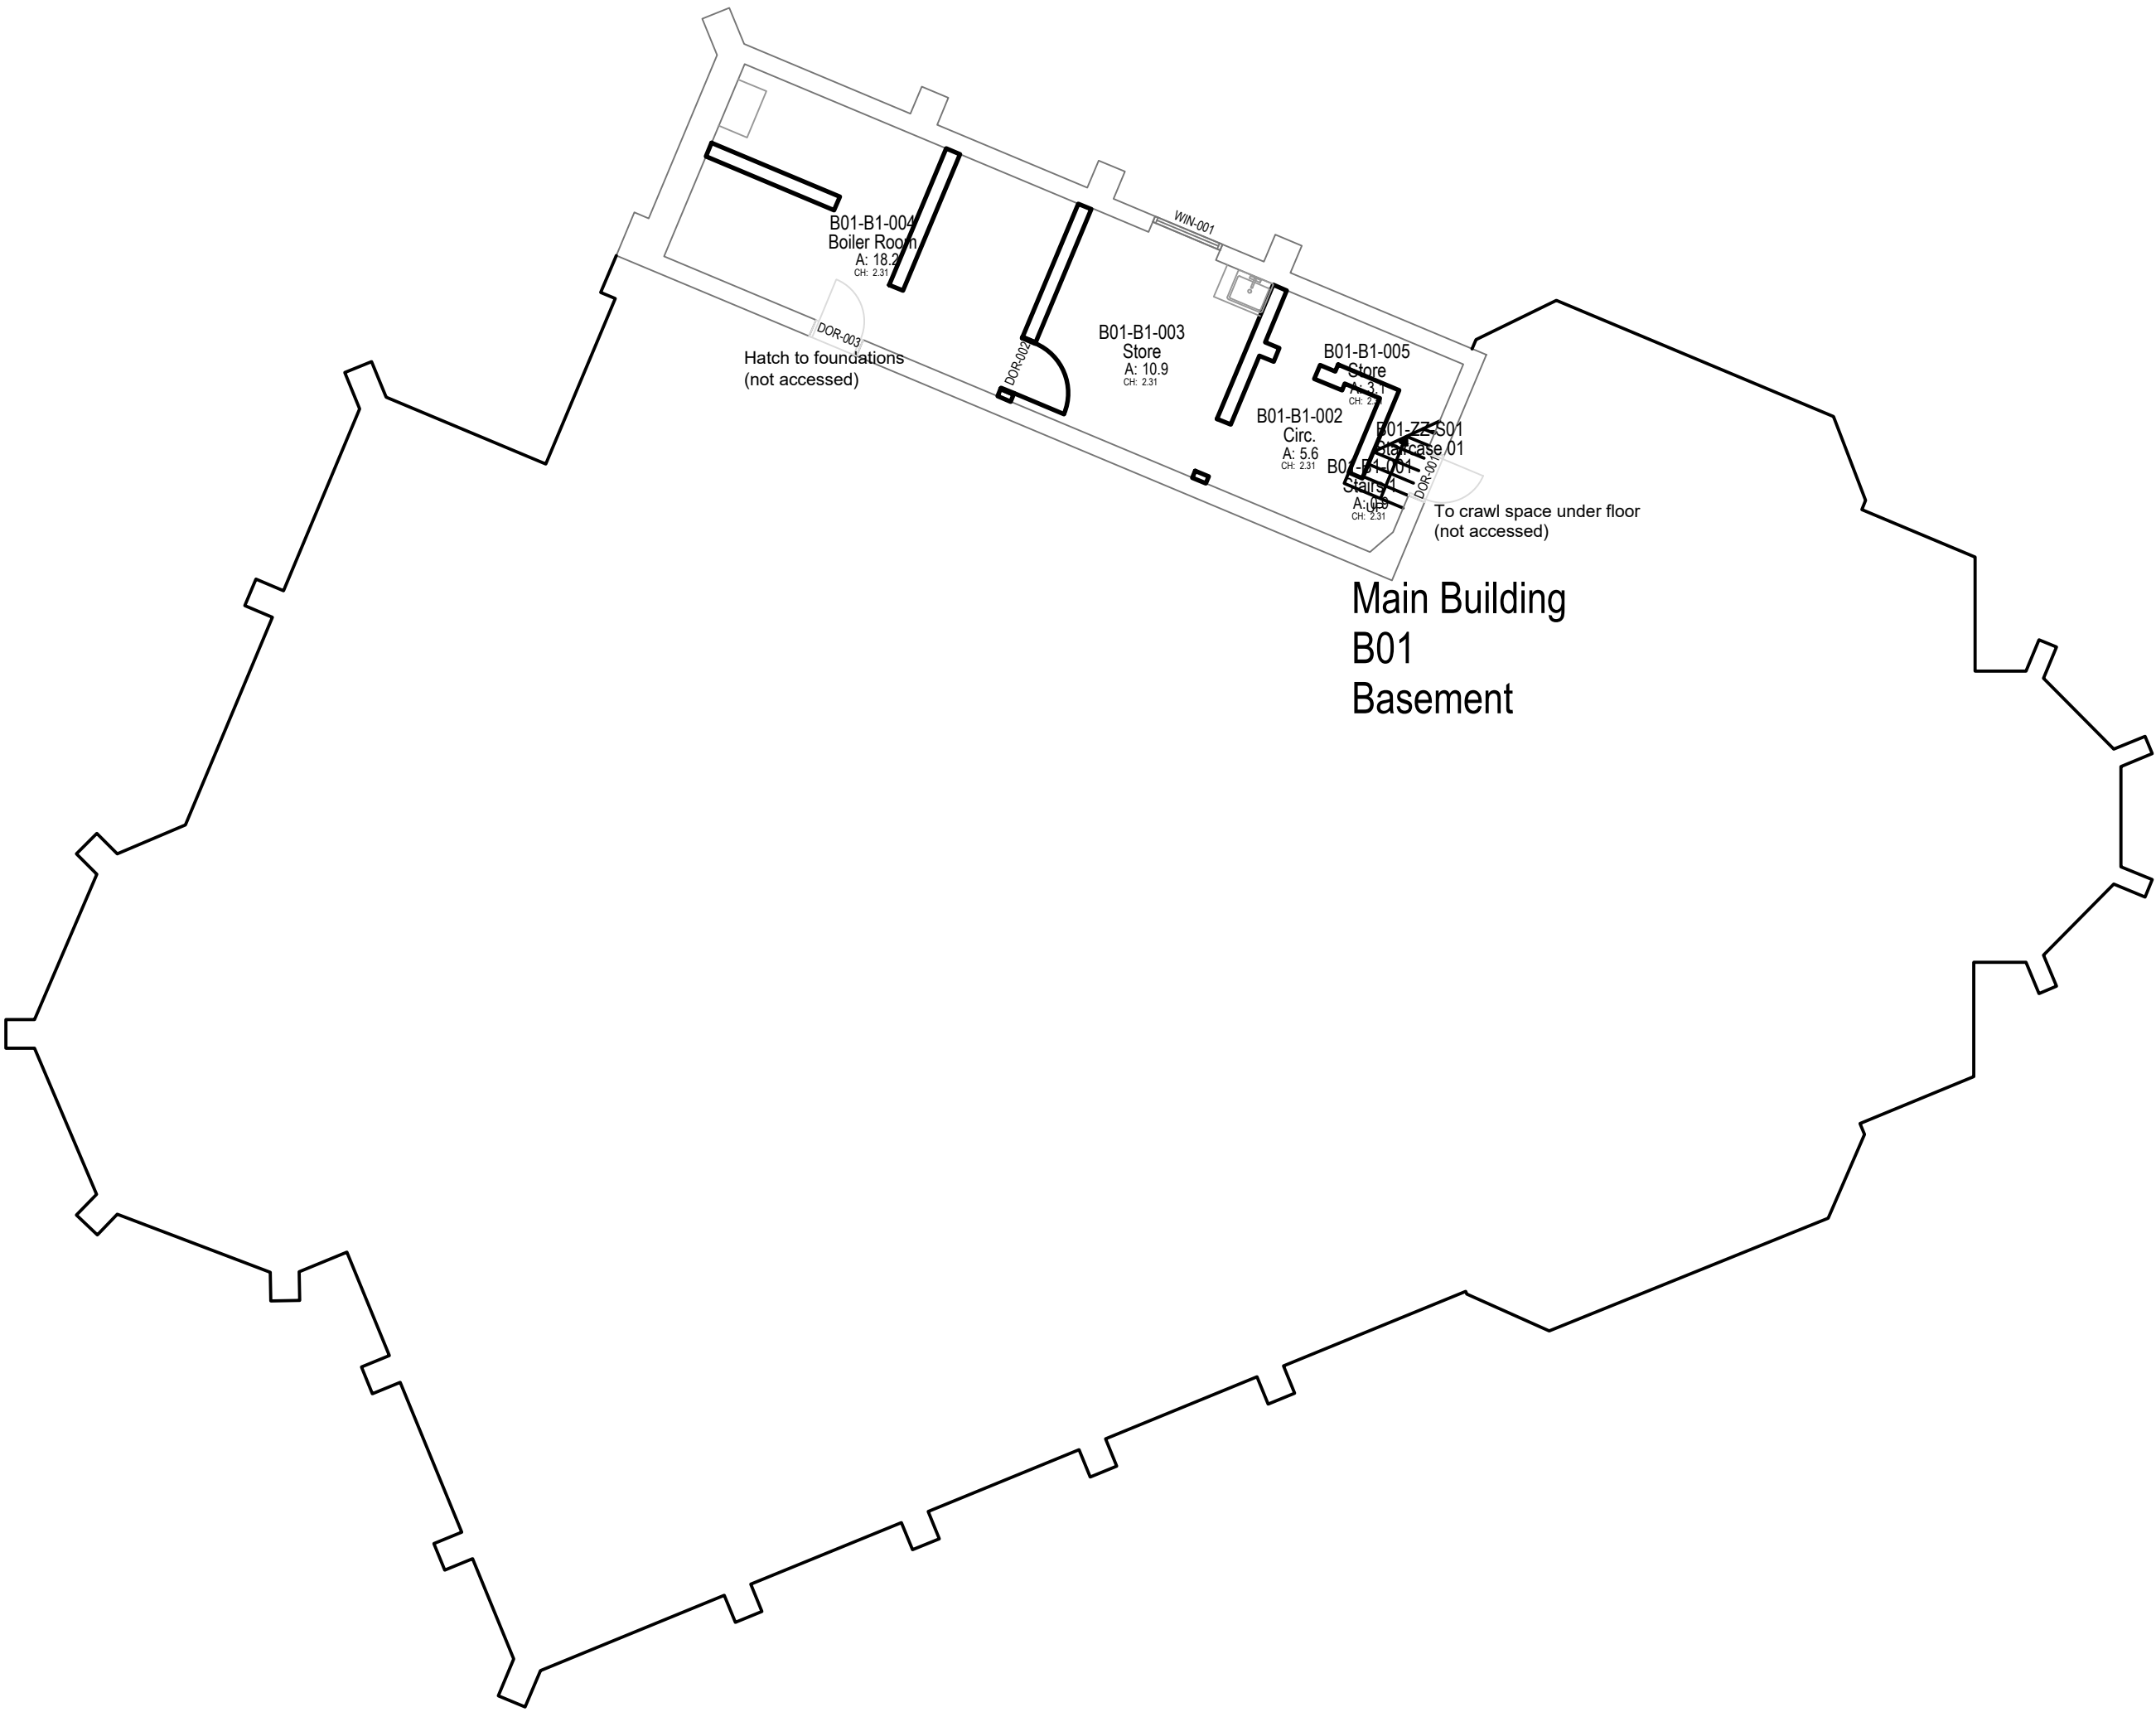

Main Building
B01
Basement

Copyright: All rights reserved. This drawing must not be reproduced without permission from AA Projects Ltd. Do not scale off this drawing. All dimensions are to be checked on site by contractor / sub contractor. Any discrepancies to be reported to AA Projects Ltd.

Rev	Date	Revision notes	By	Check	

Suite 1.06
Part First Floor
South Harrington
Brunswick Business Park
Liverpool
L3 2BQ
Tel: 0151 430 2340

Office Locations
Birmingham, Leeds, Liverpool, London, Manchester, Oxford, Rugby, Newcastle
www.aaprojects.co.uk

Client Equans MCC	Drawing Title Didsbury Library Basement Floor Plan
Project Title Didsbury Library	Drawn TR Date 11/22
	Checked PT Date 11/22
DWG No: 19972-DL-100	Scale: 1:100 Revision: -