
 
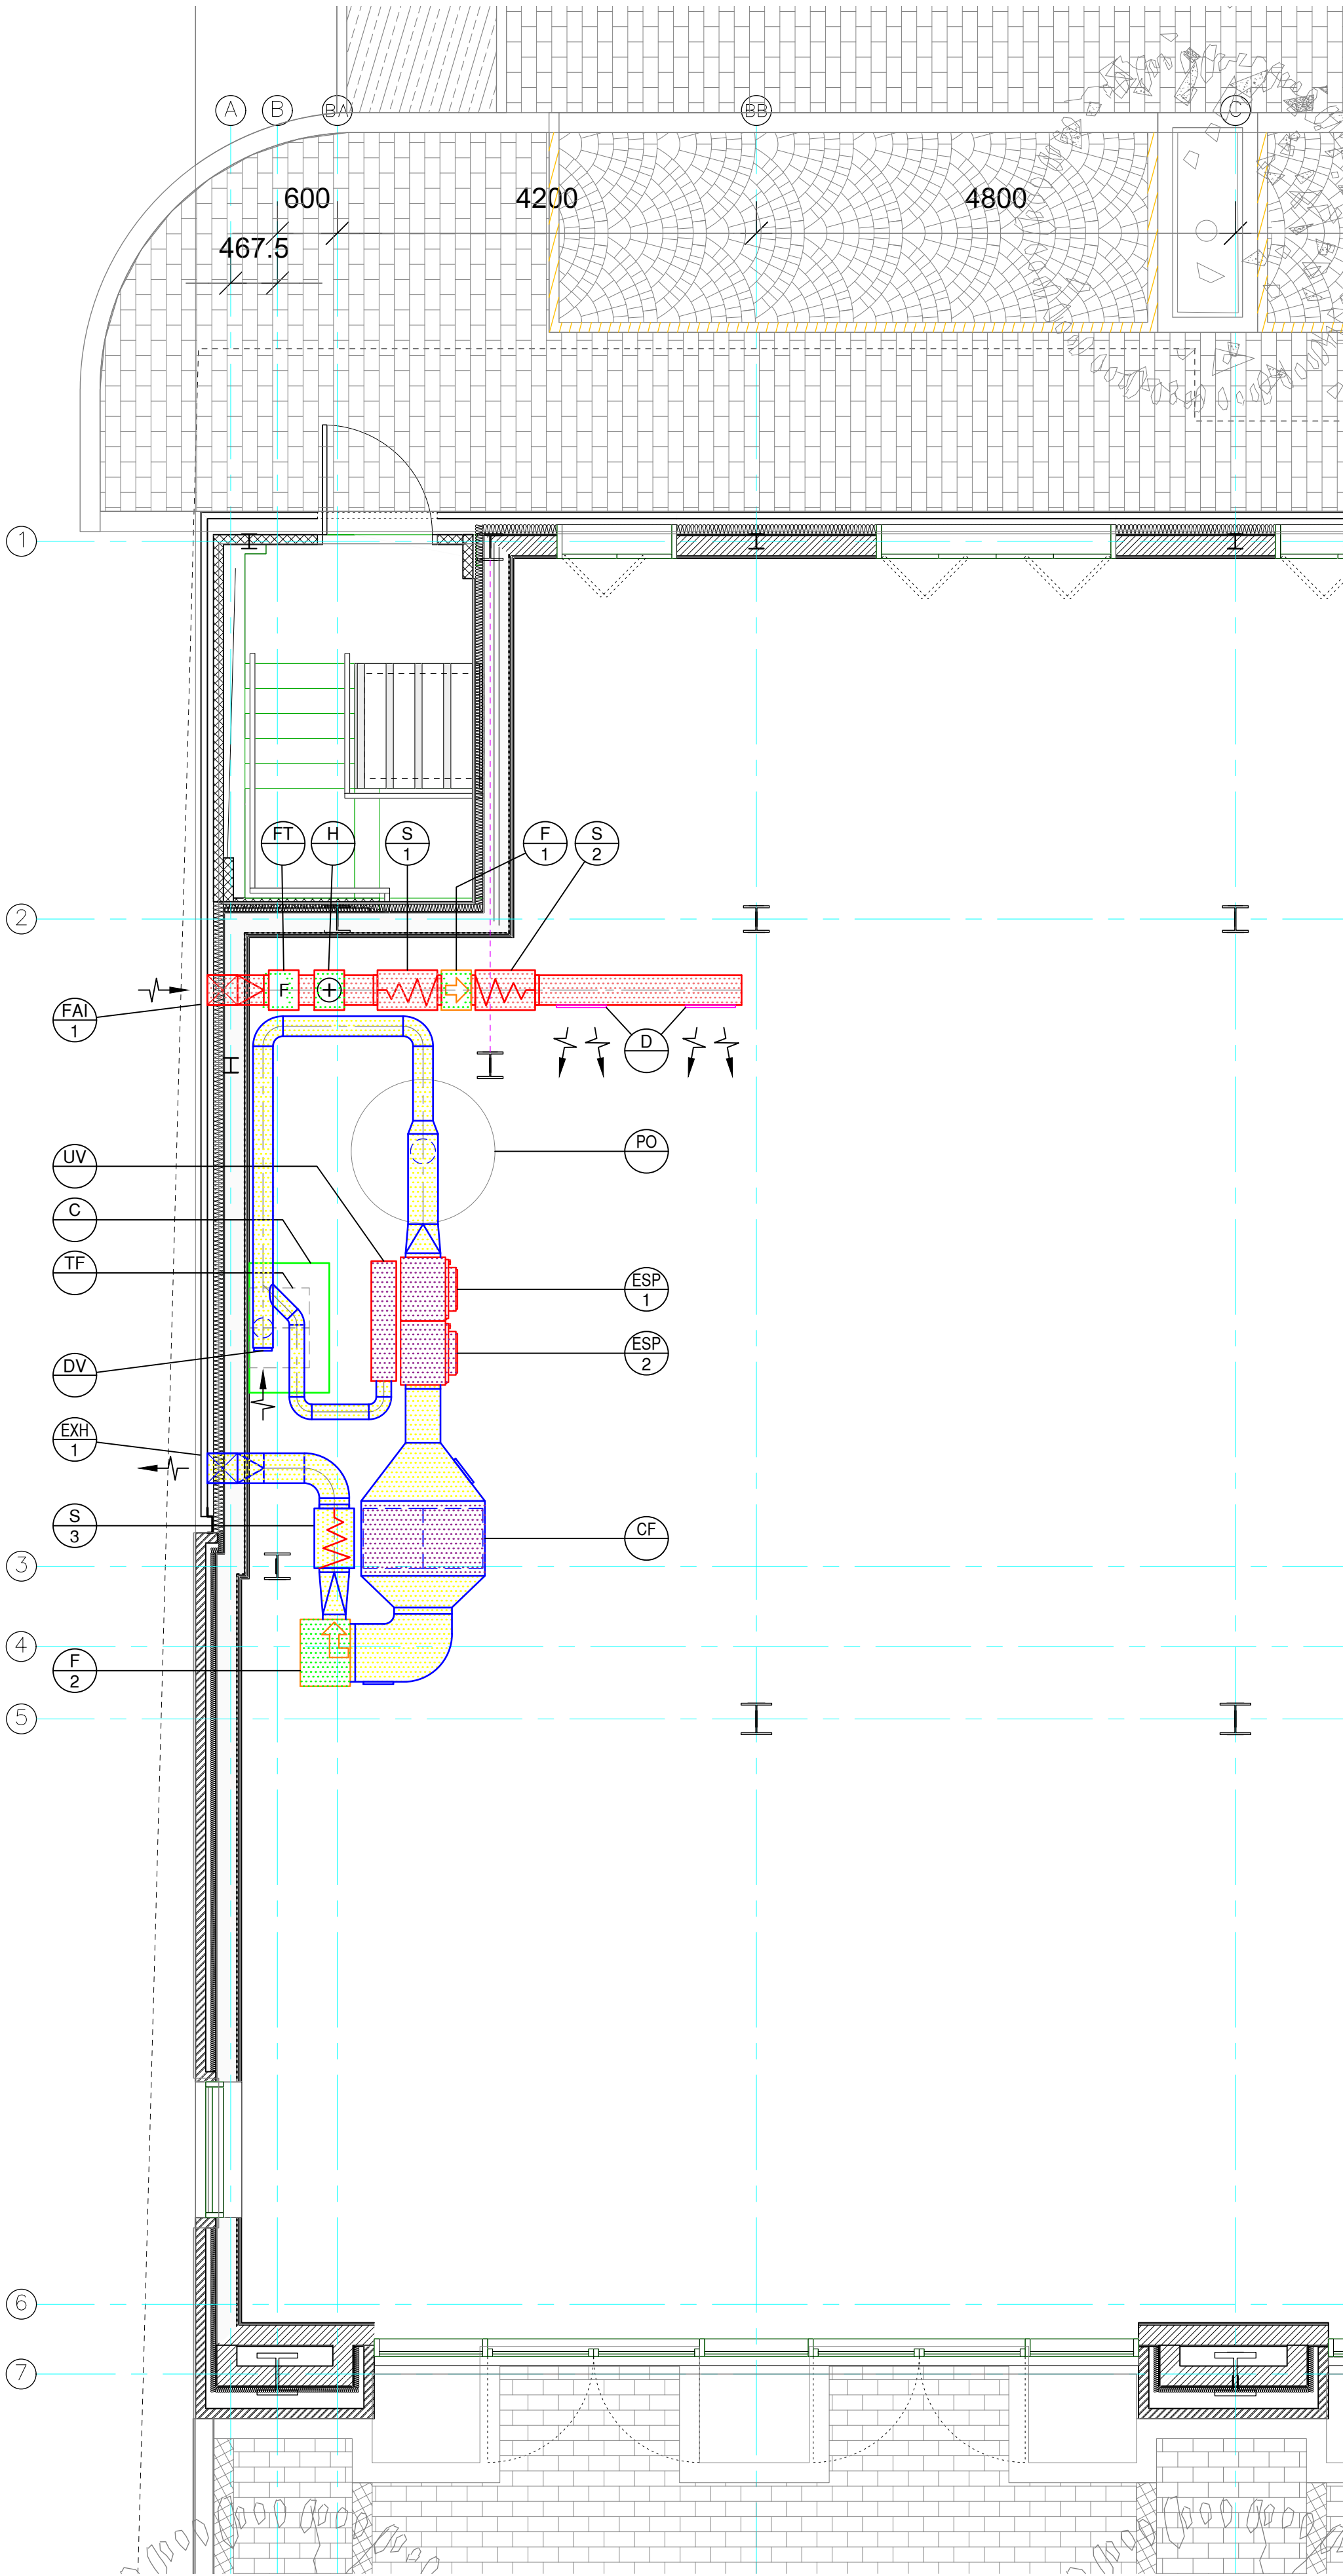




LEGEND	
REF	DESCRIPTION
C	CANOPY OVER TWIN FRYERS
CF	PURIFIED AIR CARBON FILTER MODULE, CONTAINING 6x SITE SAFE CARBON FILTERS (600mm x 600mm x 200mm NOMINAL)
D	FRESH AIR DUCT MOUNTED DIFFUSERS
DV	DILUTION VALVE AT END OF DUCT, WITH COUNTERBALANCE WEIGHTED DAMPER
ESP1	PURIFIED AIR ESP1500 MODULE
ESP2	PURIFIED AIR ESP1500 MODULE
F1	FRESH AIR SUPPLY FAN
F2	EXTRACT FAN, HIGH TEMPERATURE, MOTOR OUT OF AIR STREAM
FT	FRESH AIR FILTER MODULE
H	FRESH AIR ELECTRIC HEATER MODULE, WITH INTEGRATED, AUTOMATIC CONTROLS
FAI 1	FRESH AIR INTAKE DUCT, 300mm WIDE x 1350mm HIGH
EXH 1	EXHAUST AIR DUCT, 300mm WIDE x 1350mm HIGH
PO	PIZZA OVEN
S1	FRESH AIR PRE-FAN SOUND ATTENUATOR
S2	FRESH AIR POST-FAN SOUND ATTENUATOR
S3	EXHAUST AIR POST-FAN SOUND ATTENUATOR
TF	TWIN FRYERS
UV	PURIFIED AIR UVO1000 MODULE

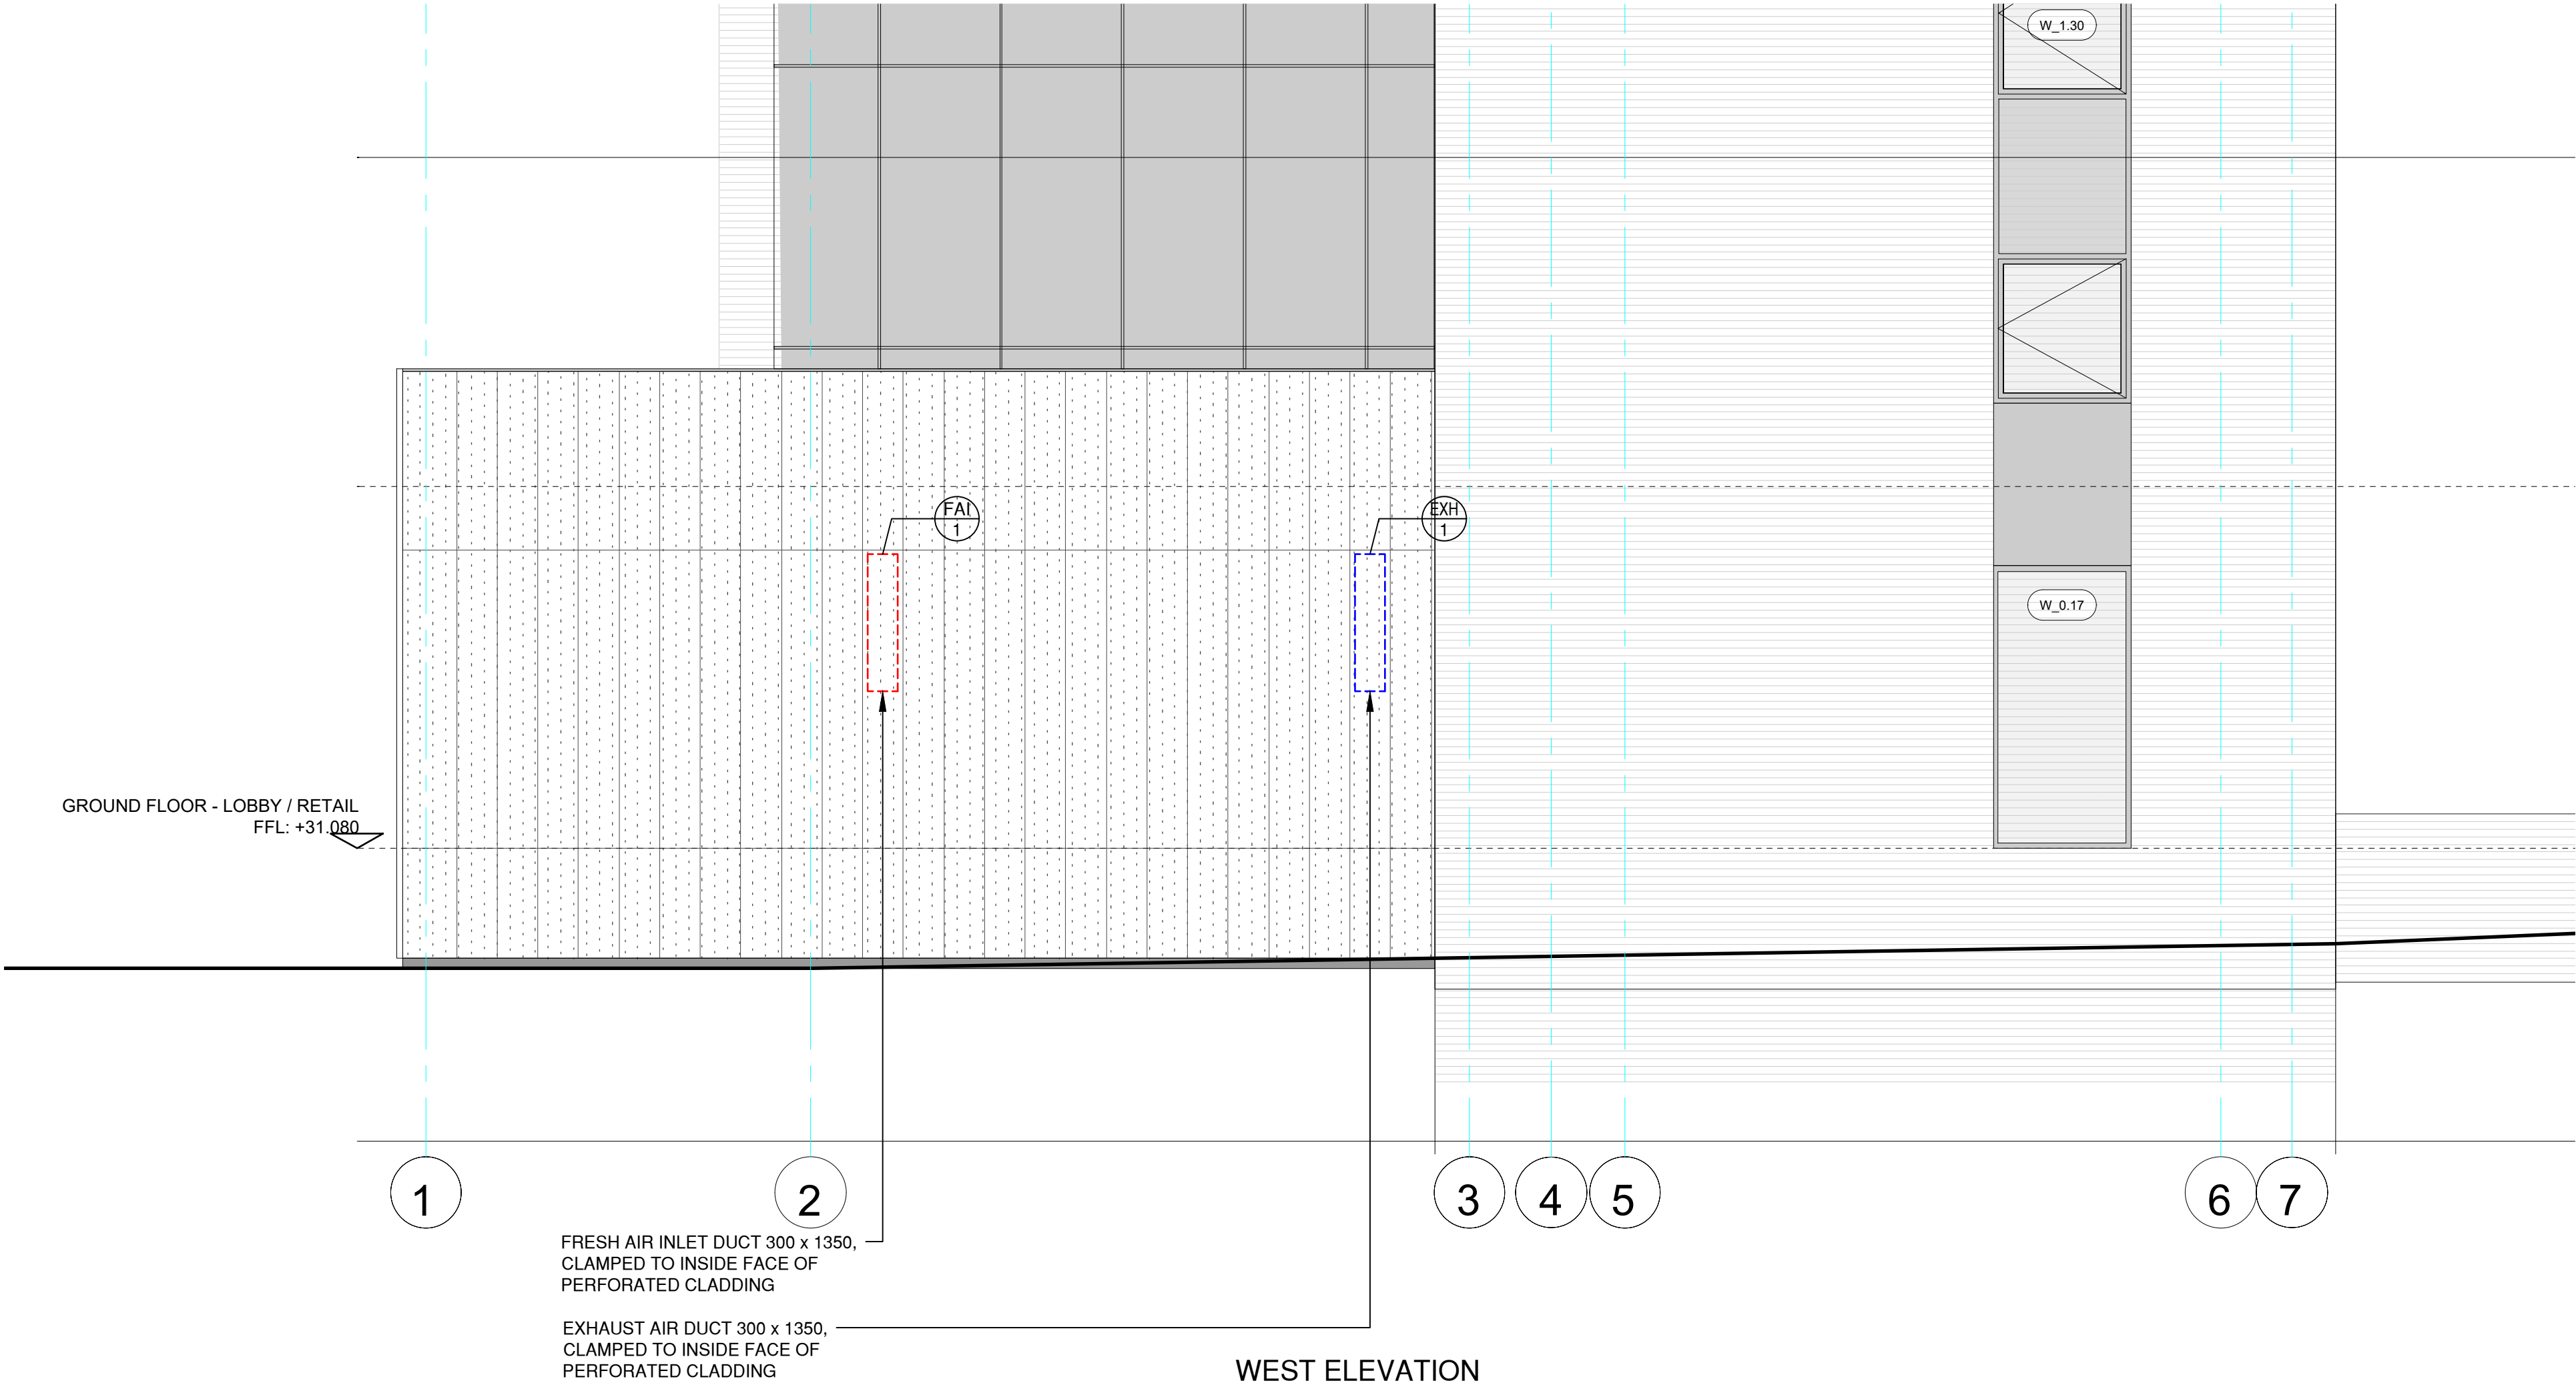

B	7.10.22	LOUVRES REMOVED, REPLACED WITH DUCTS BUTTED UP TO PERFORATED CLADDING.	PAS
A	3.8.22	WEST ELEVATION ADDED	PAS
Rev	Date	Description	By
SWAN Projects			
tel: 0161 300 3465 fax: 0161 959 2093 E mail: info@swan-projects.com			
Client CIAOOO PIZZERIA			
Project SKY GARDENS			
Title PIZZA OVEN EXTRACT VENTILATION			
Scale	1:50	Drawing Number	Rev
Date	13.7.2022	C705/1	B
Drawn	PAS		
Checked			