


02
832

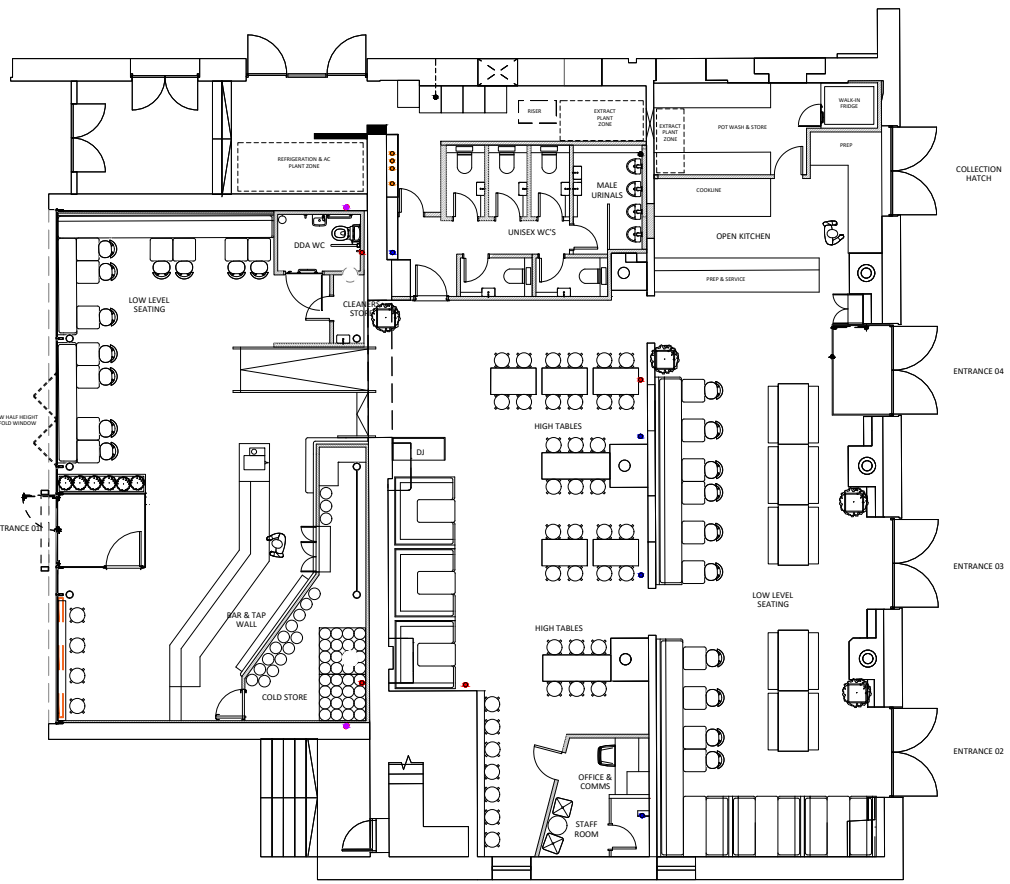


01
832
GROUND FLOOR PLAN AS PROPOSED
SCALE - 1:200 @ A1
PLAN




02
132
WEST FACING ELEVATION AS PROPOSED
SCALE - 1:50 @ A1
ELEVATION

NEW INDIVIDUAL LETTERS APPROXIMATELY 540mm HIGH, WHITE LETTERS WITH BLACK ALUMINIUM RETURNS AND REAR FACING, TO BE EXTERNALLY MOUNTED ON POWDER COATED METAL FRAMEWORK FIXED TO THE EXTERNAL FABRIC OF THE UNIT.

INDIVIDUAL LETTERS TO BE EXTERNALLY MOUNTED ON POWDER COATED METAL FRAMEWORK FIXED TO THE TO THE UNDERSIDE OF CEILING.

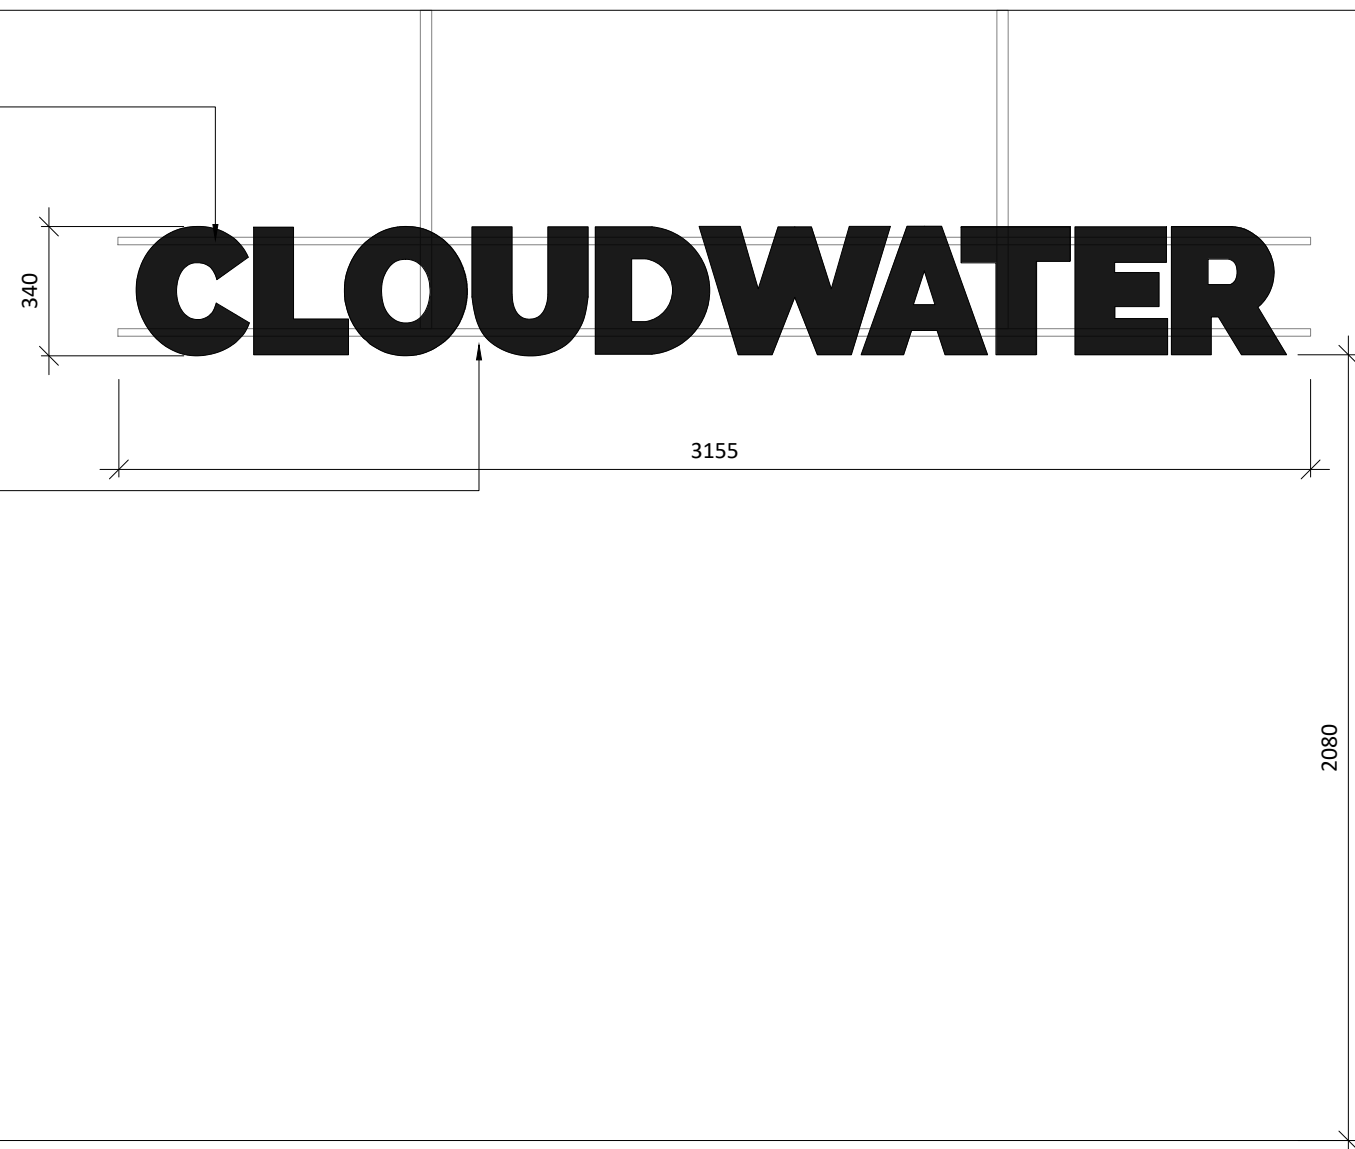


SQUARE HOLLOW SECTION SUPPORT RAILS AFFIXED TO THE TIMBER SOFFIT, TO BE FINISHED IN MATT BLACK POWDER COATING. POWER FEED TO RUN THROUGH SHS SO NOT VISIBLE

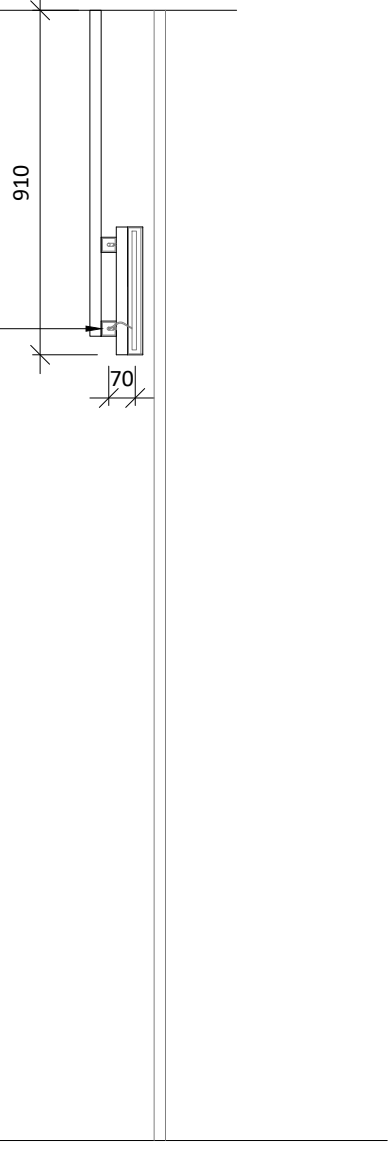


03
832
ILLUMINATED SIGN AS PROPOSED
SCALE - 1:20 @ A1
ELEVATION

04
832
ILLUMINATED SIGN AS PROPOSED
SCALE - 1:20 @ A1
ELEVATION

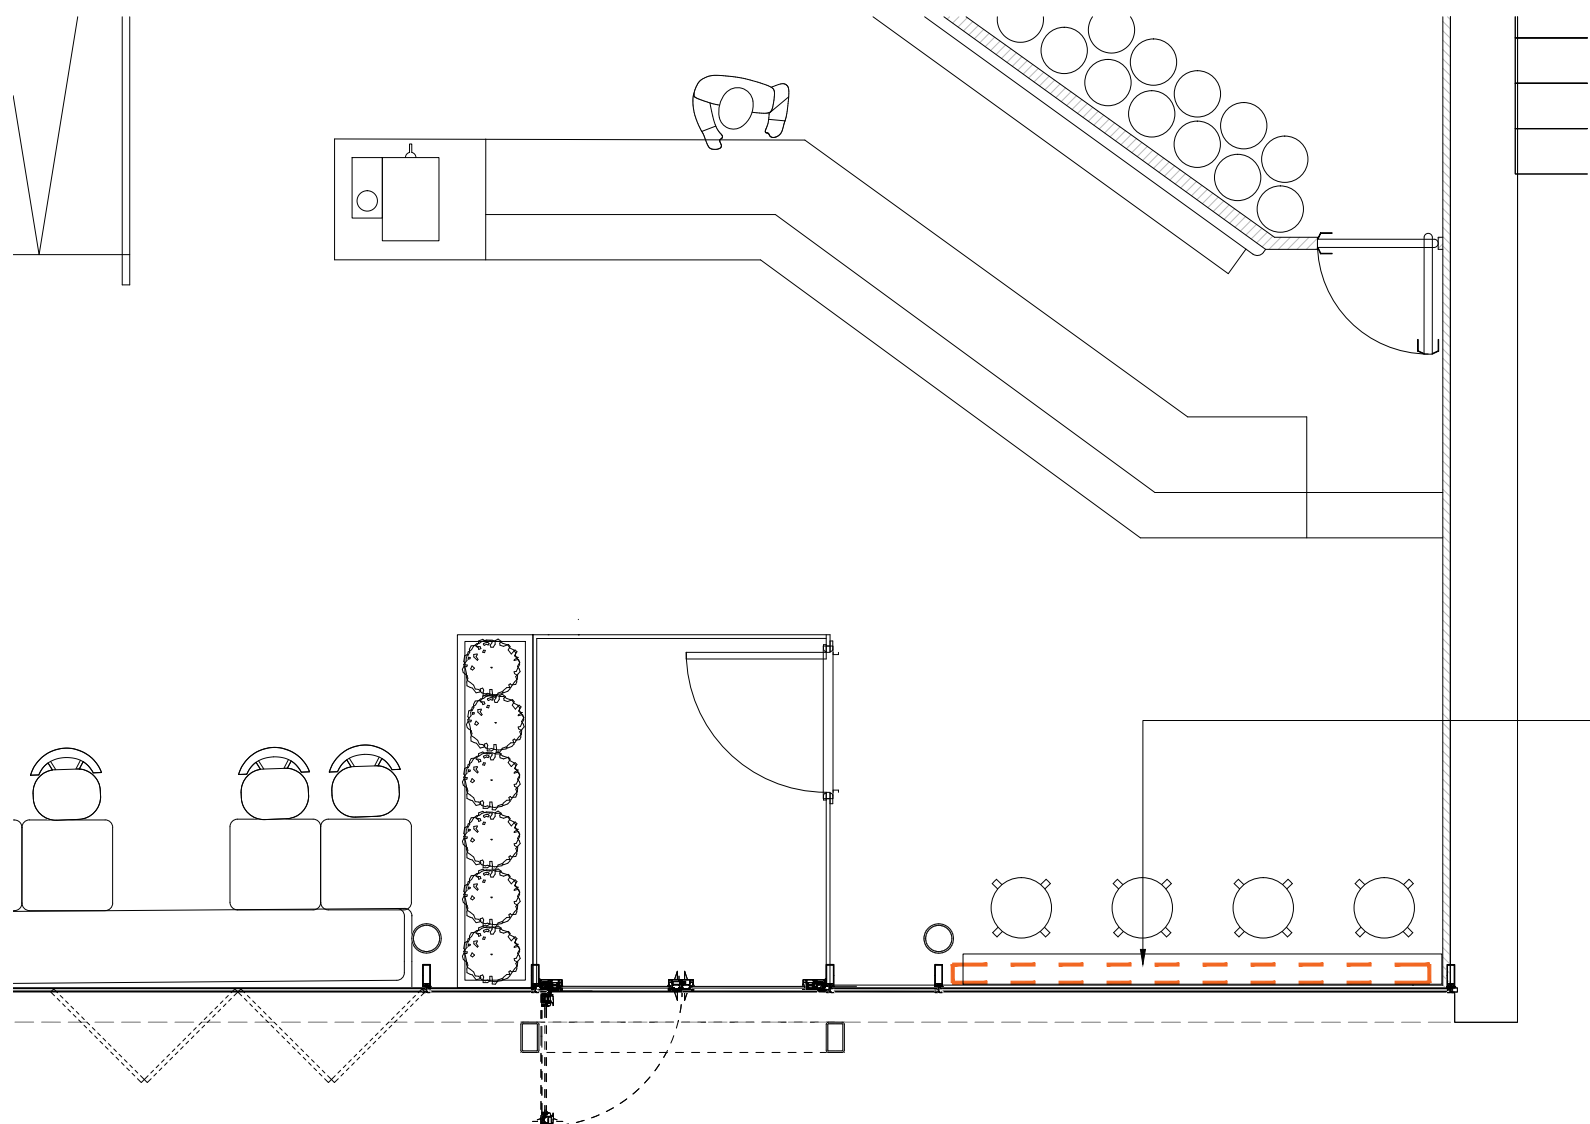


06
832
GROUND FLOOR PLAN AS PROPOSED
SCALE - 1:50 @ A1
PLAN

'CLOUDWATER' SIGN TO HANG INTERNALLY ABOVE POSEUR SHELF WITH ADEQUATE DISTANCE GIVEN BETWEEN TO AVOID HEAD RESTRAINT CLASHES

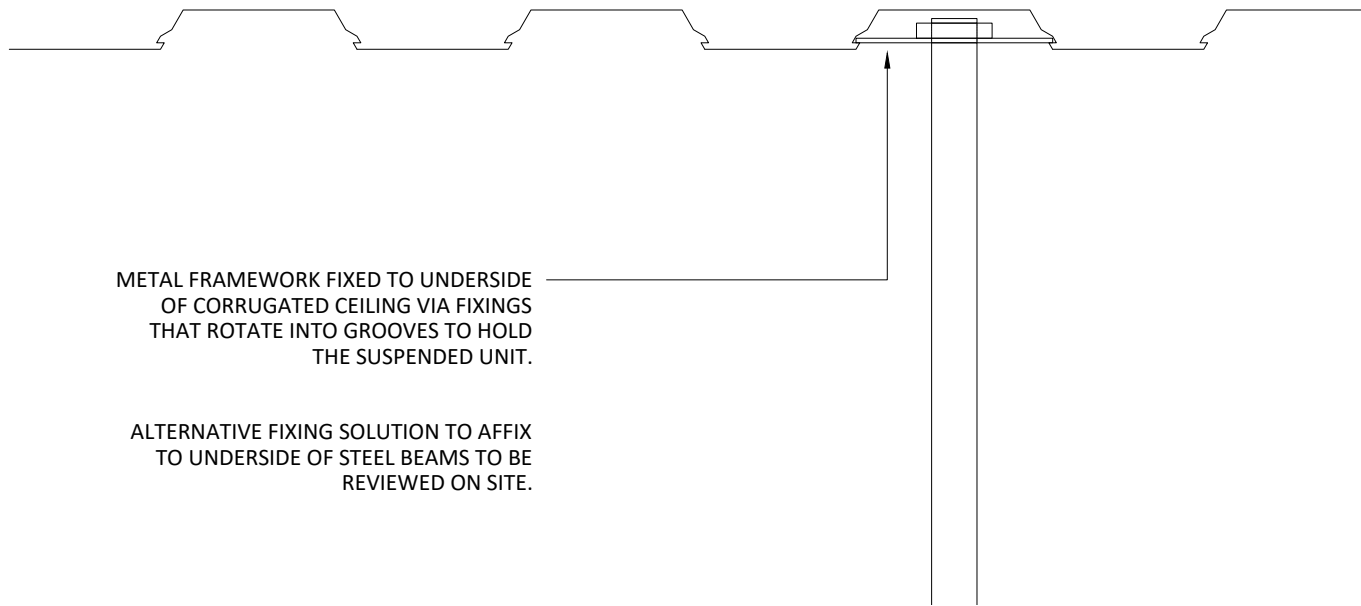

05
832
FRAME UNIT FIXING AS PROPOSED
SCALE - 1:5 @ A1
ELEVATION

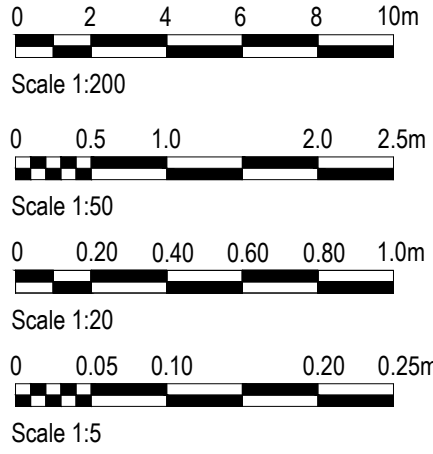

NOTES

DO NOT SCALE FROM THIS DRAWING.
ALL DIMENSIONS TO BE CHECKED ON SITE.
(DRAWINGS MAYBE SCALED FOR LOCAL AUTHORITY & PLANNING PURPOSE ONLY)
COPYRIGHT PROTECTED.

FOR PLANNING
DO NOT USE FOR CONSTRUCTION

CONSULTANT REFERENCES IN DRAWING:

STRUCTURAL - REF/REVISION

GENERAL NOTES:

THE CONTRACTOR IS NOT TO SCALE FROM THIS DRAWING BUT FOLLOW THE WRITTEN FINISHED DIMENSIONS. ANY DISCREPANCIES BETWEEN THE DRAWING AND THE OTHER CONTRACT DOCUMENTS OR ANY DISCREPANCIES WITHIN A DRAWING OR BETWEEN DRAWINGS MUST BE REPORTED IMMEDIATELY TO THE ARCHITECT.

THE CONTRACTOR IS TO INSPECT THE SITE PRIOR TO TENDER AND IS RESPONSIBLE FOR STRIPPING OUT IN ACCORDANCE WITH THE DRAWINGS ENSURING THAT THE WORK IS UNDERTAKEN SAFELY.

THE CONTRACTOR WILL BE RESPONSIBLE FOR THE SETTING OUT OF THE WORKS.

CONTRACTOR IS TO ALLOW FOR ALL FIRE STOPPING THROUGH WALLS, CEILINGS AND FLOORS.

THE ELECTRICAL INSTALLATION IS TO BE IN ACCORDANCE WITH THE CURRENT EDITION OF THE IEE REGULATIONS AND ALL CABLEING TO BE LSF.

THE CONTRACTOR IS RESPONSIBLE FOR THE DETAILED SERVICES DESIGN INCLUDING LOADINGS, CABLE AND PIPEWORK ROUTES AND PIPEWORK / CABLE SIZING AND SPECIFICATION. ALL CABLE TRAY, MS CONDUIT AND OTHER SERVICES ARE TO BE EXPOSED BELOW SLAB/ CEILINGS.

ANY H&V PROPOSAL IS INDICATIVE ONLY AND THE SPECIALIST CONTRACTOR IS TO BE RESPONSIBLE FOR THE DETAIL DESIGN & ALL SWITCH/ SOCKET OUTLETS TO COMPLY WITH CLIENT'S STANDARD SPECIFICATION. ANY SOCKETS IN RETAIL AREA TO BE FINISHED BRUSHED STAINLESS STEEL.

NOTE - ALL EXISTING FIRE RESISTING ENCLOSURES TO SERVICE RISERS TO BE MAINTAINED OR MADE GOOD WHERE DISTURBED. NEW AND EXISTING CABLES, PIPES AND DUCTS PASSING THROUGH FIRE RESISTING CONSTRUCTION TO BE ADEQUATELY FIRE STOPPED. NEW AND EXISTING DUCTWORK PASSING THROUGH FIRE RESISTING CONSTRUCTION TO HAVE FIRE DAMPERS.

ANY WALL, CEILING LININGS TO BE TO EUROCLASS A (CLASS O EQUIVALENT).

CONTRACTOR AND SUPPLIERS OF SPECIALIST JOINERY/ EQUIPMENT TO ENSURE ALL TIMBER MATERIALS ARE TREATED WITH FIRE RETARDANT FINISH TO ACHIEVE CLASS O RATING. MDF TO BE ACHIEVE CLASS O RATED.

CONTRACTOR AND SUPPLIERS OF SPECIALIST EQUIPMENT TO PROVIDE FIRE RATING CERTIFICATES FOR ALL SPECIALIST LININGS AND LAMINATES TO BE USED FOR NWR APPROVAL.

ALL PAINTS TO BE WATER BASED

ALL DIMENSIONS TO BE CHECKED ON SITE PRIOR TO ANY MANUFACTURE OR CONSTRUCTION OF EQUIPMENT, FINISH, SIGNAGE ETC.

3.01	03/01/23	ISSUED FOR PLANNING	JW	ARB
3.00	03/01/23	Amendments made to signage following client discussion	JW	ARB
REV	DATE	DESCRIPTION	DRAWN	CHECKED

A X I

ADDRESS : 4th FLOOR CALICO 53-55 MOSLEY STREET, MANCHESTER, M2 3HQ
TELEPHONE : +44 (0)161 879 7337
EMAIL : www.ahx.studio
COMPANY No : 11847325

CLIENT



PROJECT

CLOUDWATER
KAMPUS, MINSULL ST
MANCHESTER

DRAWING REFERENCE

WEST FACING SIGNAGE DETAILS
AS PROPOSED

JOB REFERENCE	DRAWING SCALE	DATE	DRAWN	CHECKED
22 - 108	VAR @ A1	03/01/23	JW	ARB
DRAWING REFERENCE	STAGE	REV		
AXI - 832	3	01		