



PROPOSED JACKSON ROW ELEVATION
1:100


PROPOSED DEANSGATE ELEVATION
1:100

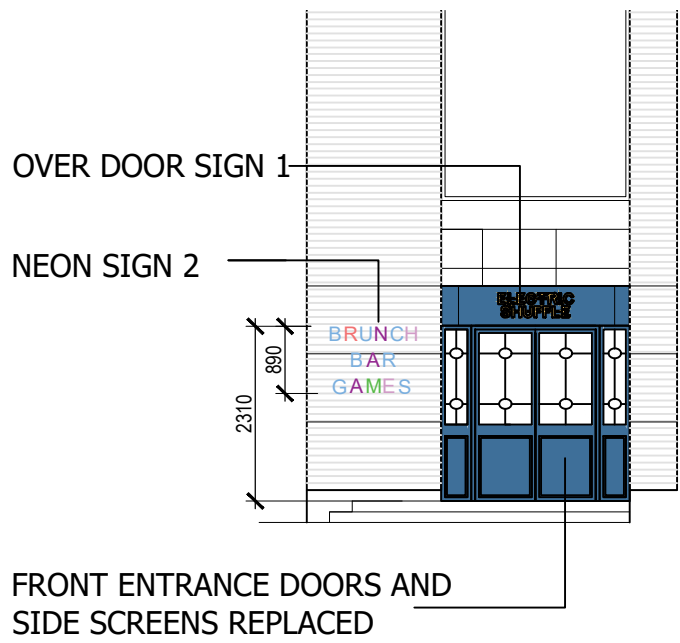


MAIN ENTRANCE ELEVATION
1:100

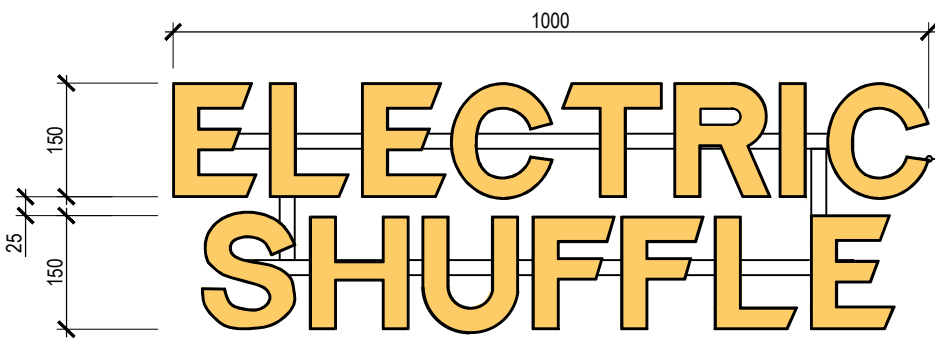


1 NEON SIGNAGE - FRONT ELEVATION
Scale: 1:10

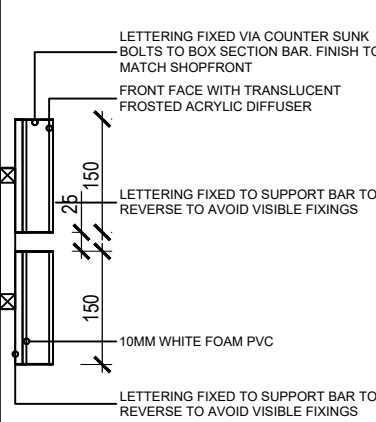


1 NEON SIGNAGE - SECTION
Scale: 1:10

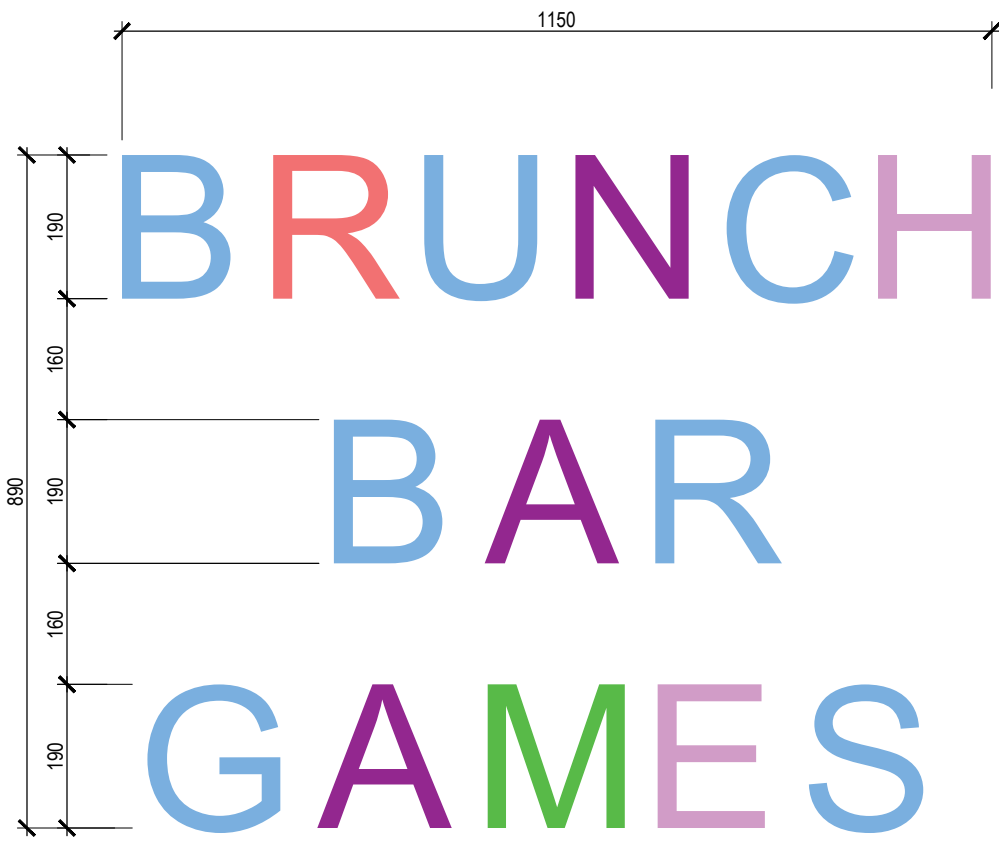


2 NEON SIGNAGE - FRONT ELEVATION
Scale: 1:10

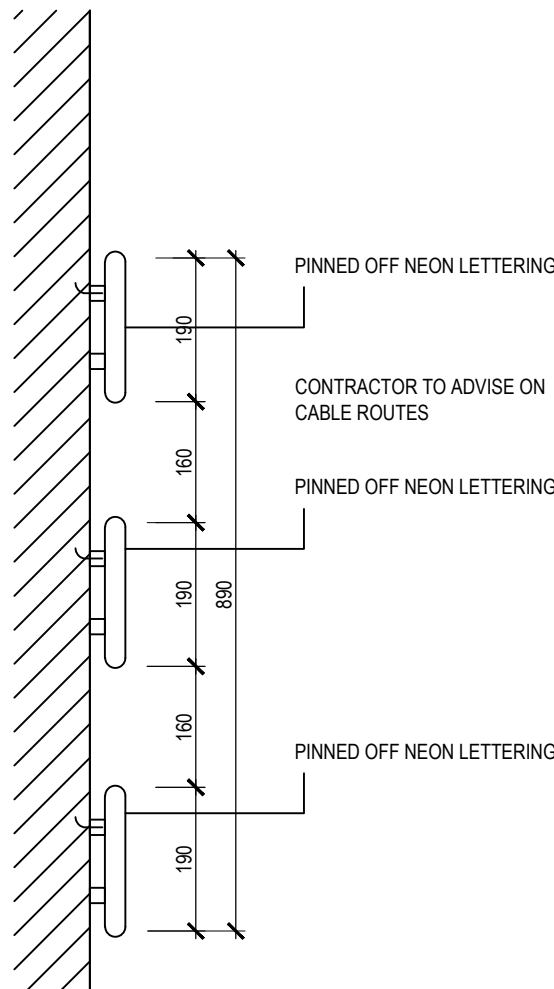

2 NEON SIGNAGE - SECTION
Scale: 1:10

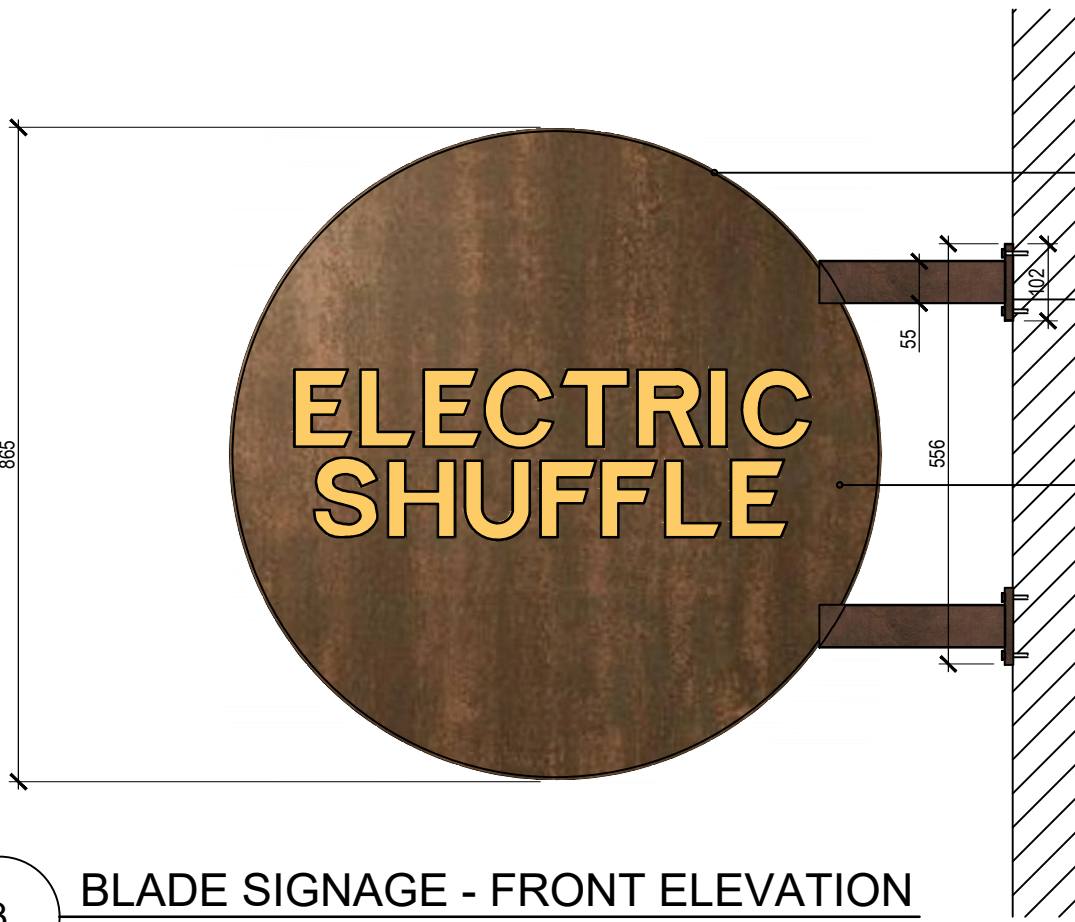

3 BLADE SIGNAGE - FRONT ELEVATION
Scale: 1:10

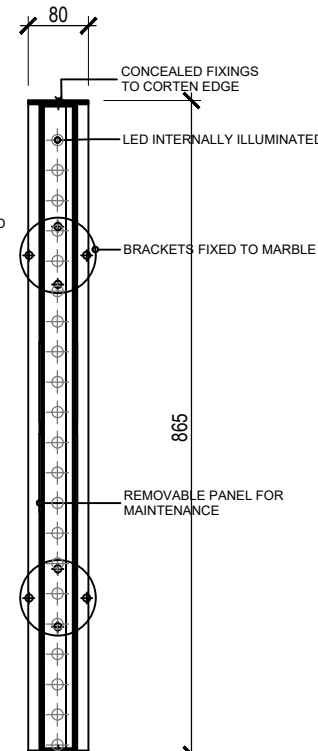

3 BLADE SIGNAGE - SECTION
Scale: 1:5

SIGNAGE DETAILS

-	-	-	-	-	-
Rev	Date	Description	Drawn	Checked	
Amendments					
Drawing Status					
Planning					



Construction Consultants				
PROJECT Electric Shuffle 201 Deansgate Manchester M3 3NW				
CLIENT Red Engine				
TITLE Proposed Elevations and Signage Details				
SCALE 1:100 / 5 @ A1			DATE Feb 2023	
DRAWN BY LC	CHECKED BY DH	DRAWING No. 7855_03		REV -