



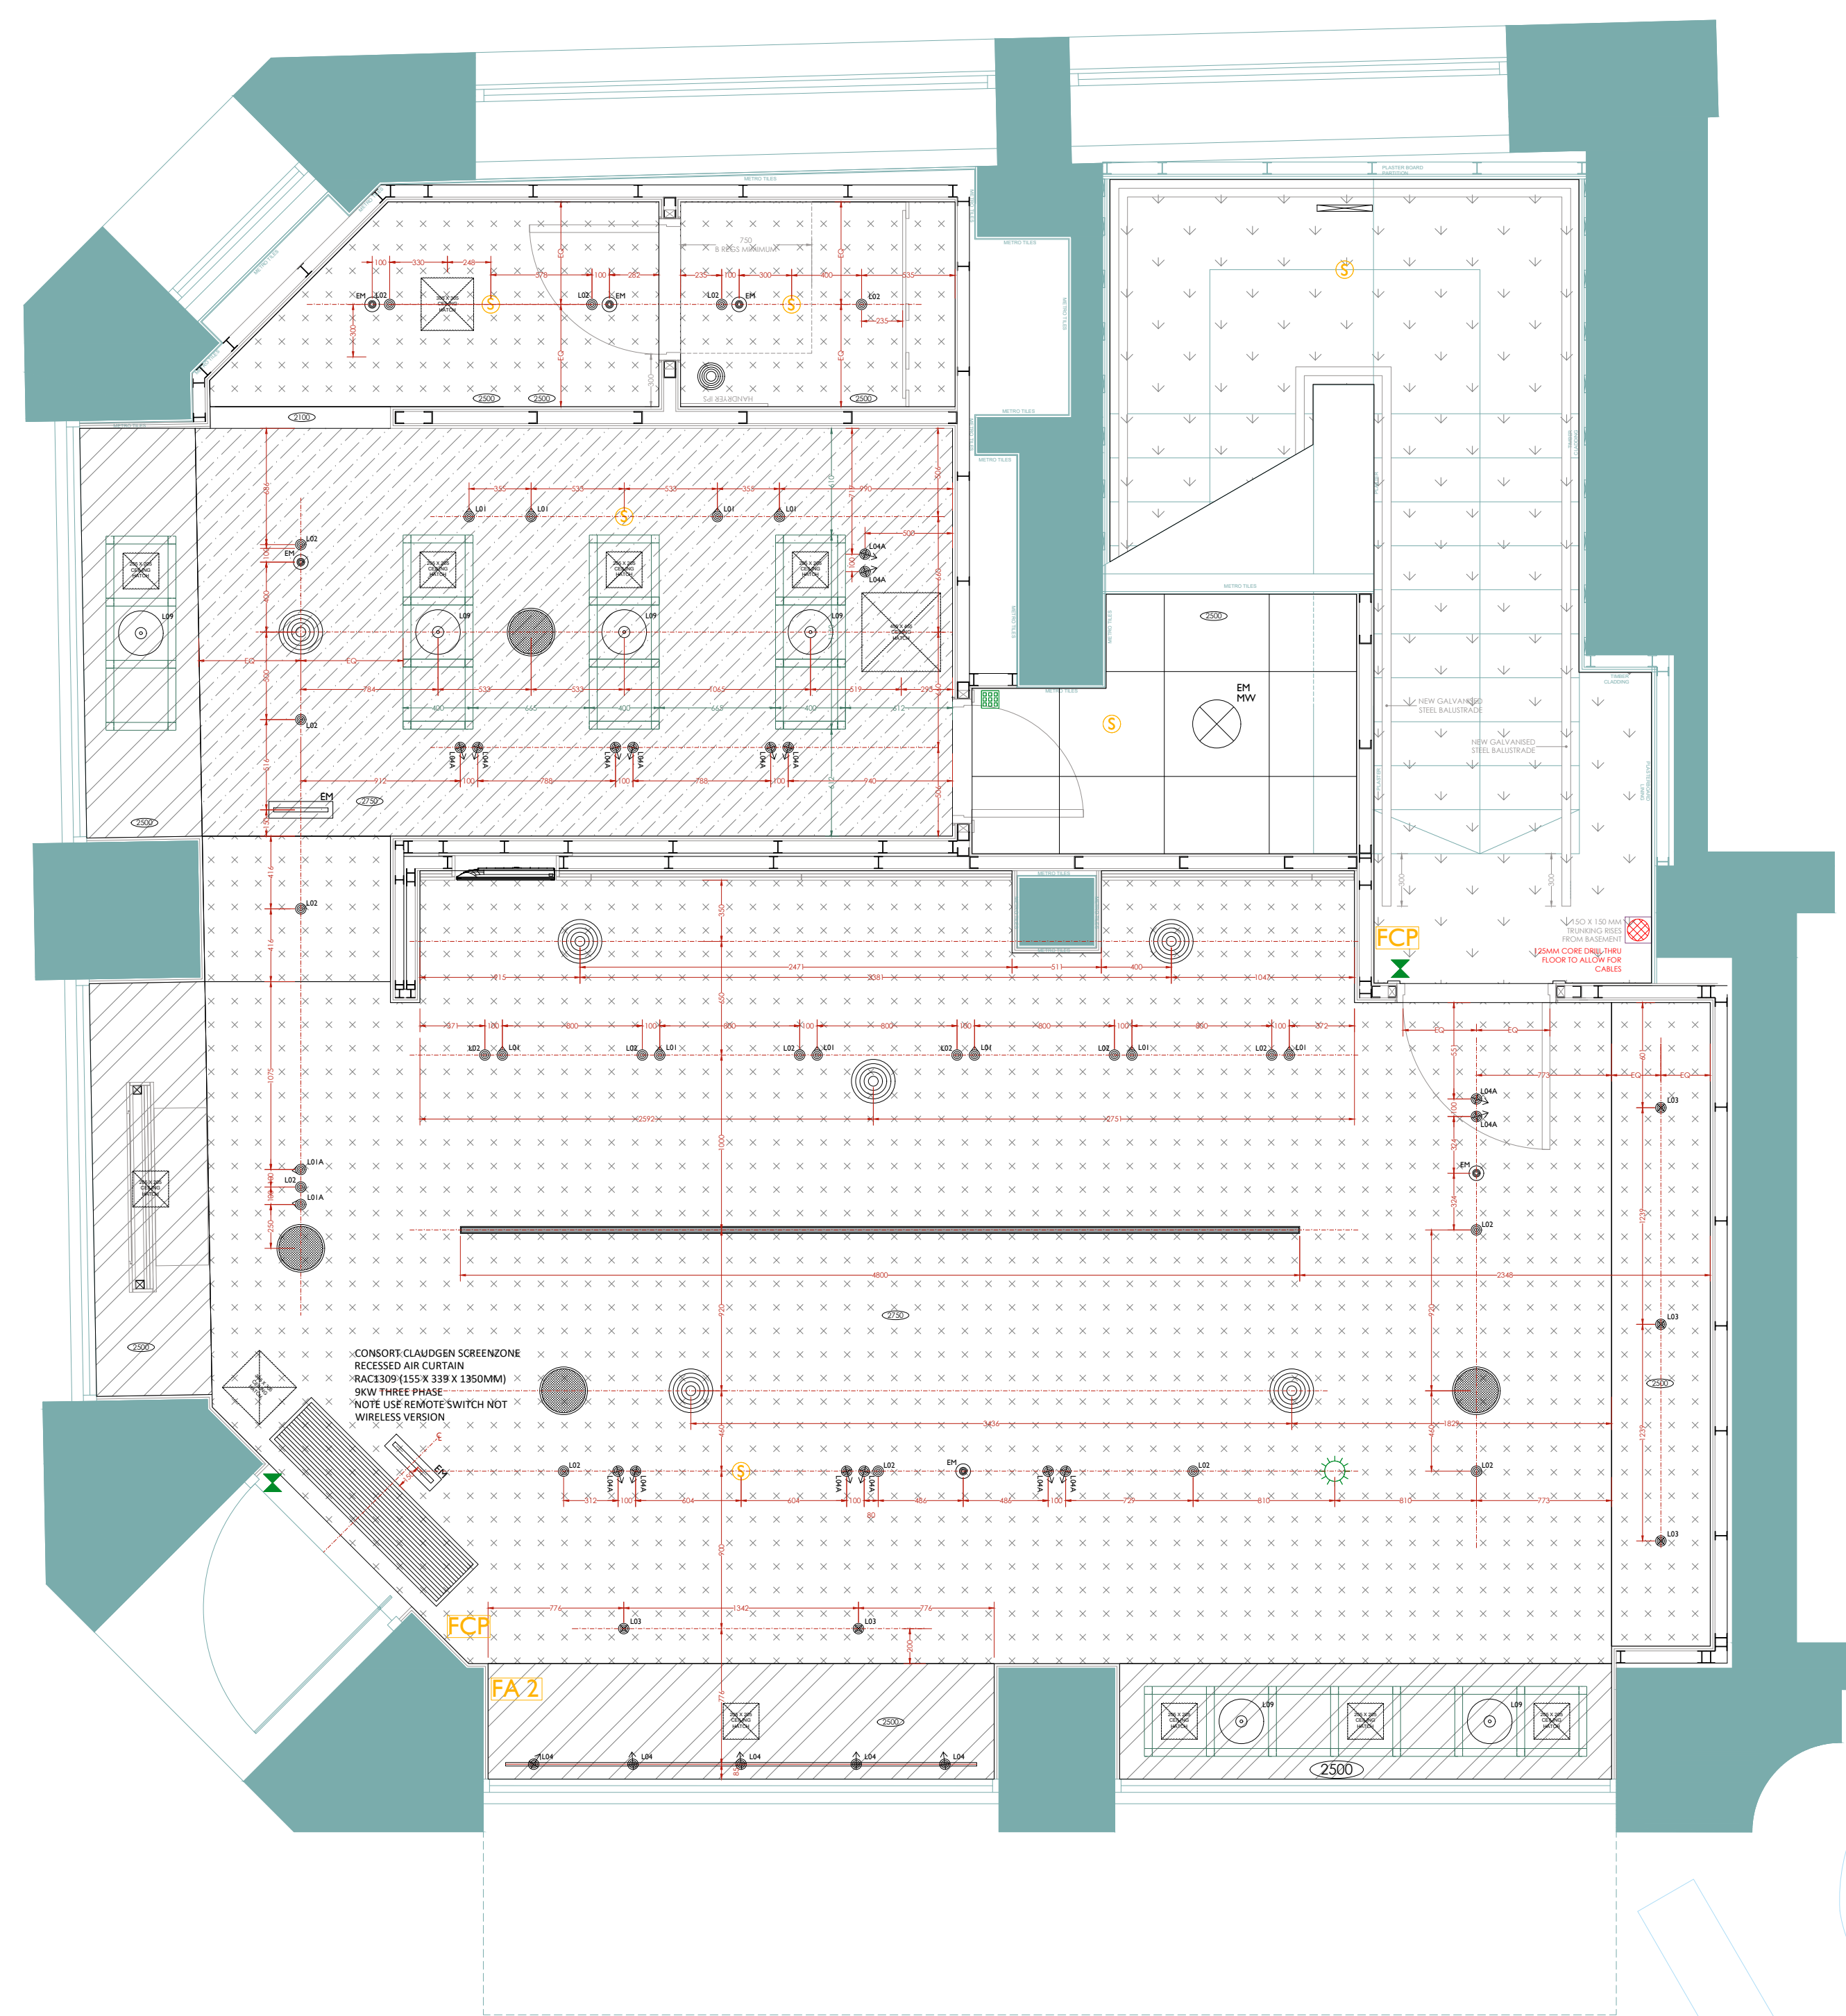

GROUND FLOOR PLAN

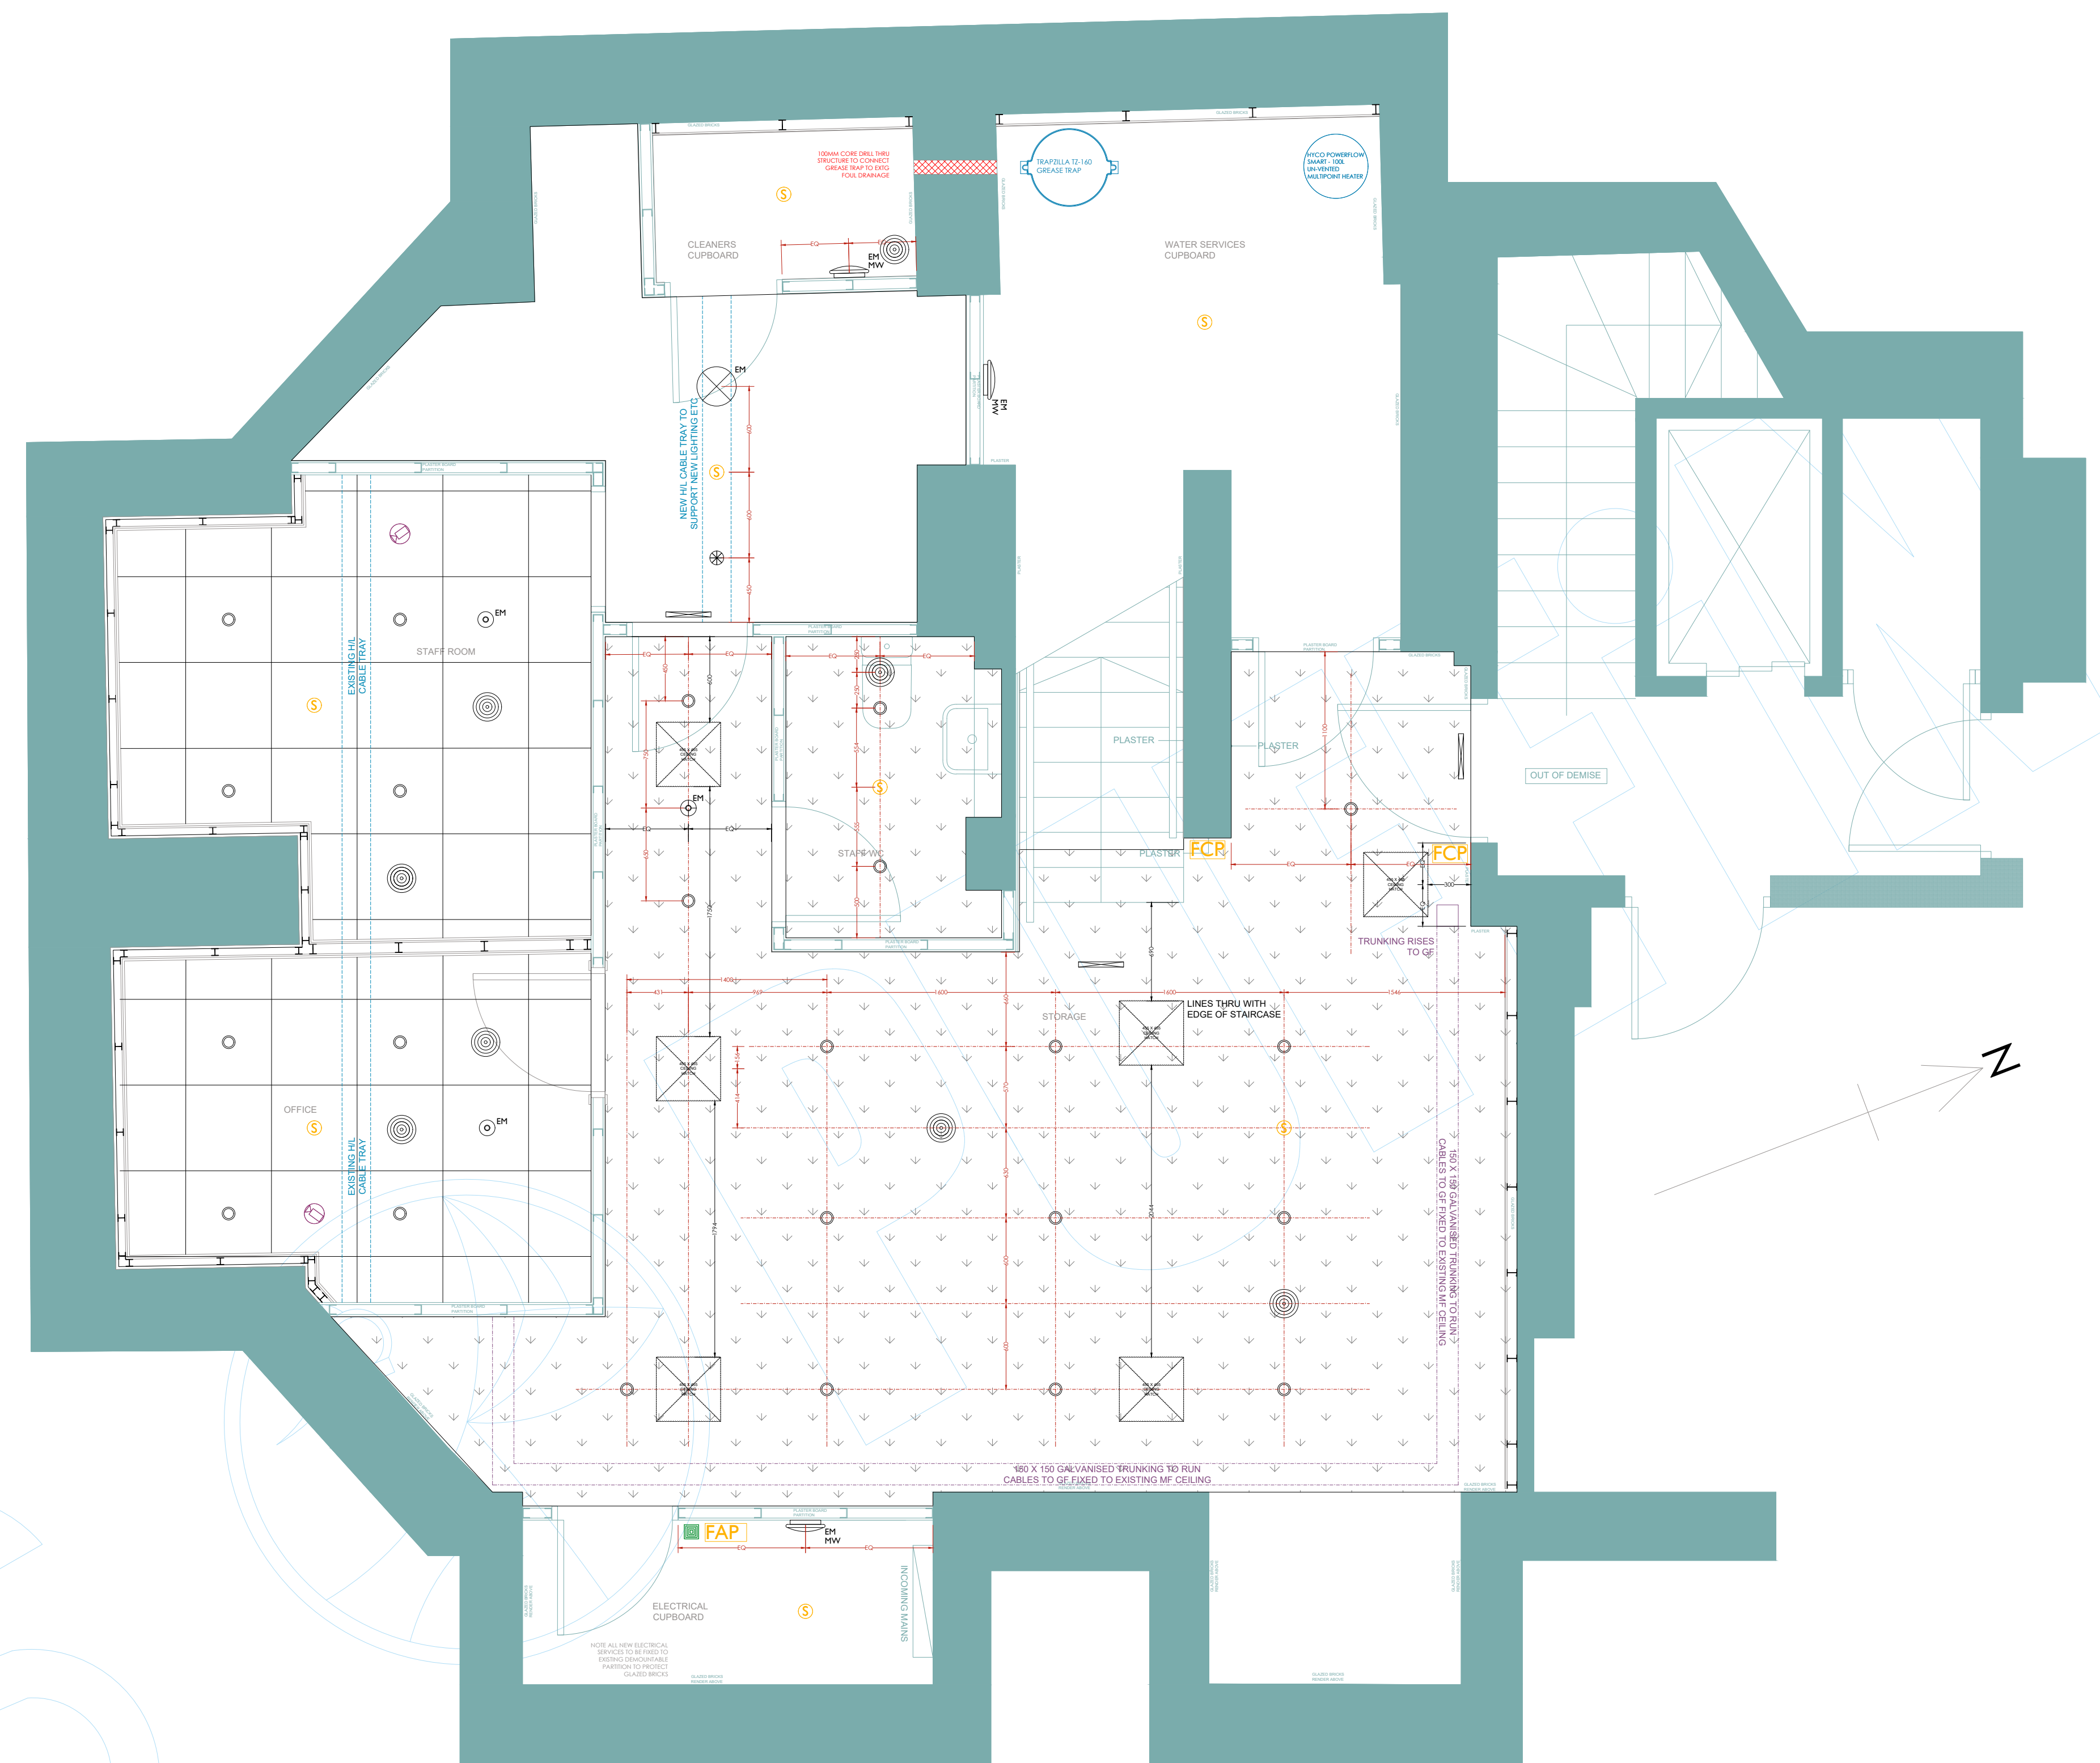

BASEMENT FLOOR PLAN

 DENOTES EXISTING STRUCTURE AND FINISHES

LIVING FRONT OF HOUSE				
REF	DESCRIPTION	RECORDED	DATE NOTIFIED	NOT DEFERRED (YES/NO)
1	XAL SASSO WALL W/ASHNER	RECORDED	YES	10
2	XAL SASSO WALL W/ASHNER (PITAL OFF)	SURFACE	YES	3
3	XAL SASSO ADJUSTABLE DOWNLIGHTER	RECORDED	YES	19
4	XAL SASSO 2ND DOWNLIGHTER	SURFACE	YES	1
5	BO 1 CH 12 TRACK	SURFACE	NO	5
6	MO CROSSOVER	SURFACE	NO	14
7	XAL NINA TURN LEFT LIGHTING	SURFACE	NO	4
8	XAL 40 200W WITH CHARGER	SURFACED	YES	1
9	XAL PICO TO BLACK COUNTER PLAT FINISH	SURFACE	NO	4
10	REPAIRS SMOKE DETECTOR IN HALL	SURFACED	YES	6
11	REPAIRS SMOKE DETECTOR IN HALL	SURFACED	YES	6
12	AMPEL SIGNAL LED PRO EXPERIMENT	RECORDED	N/A	6
13	AMPEL SIGNAL LED PRO EXPERIMENT	RECORDED	N/A	6
14	AMPEL PIAZZO WITH RED WHITE	RECORDED	N/A	6

[illegible]

SWITCHING CIRCUITS			
	DESCRIPTION	GIYMAPPA	NIGHT SETTING
1	WALL HANGERS PERAL WALL	YES	YES
2	WALL HANGERS RETAIL	YES	YES
3	DOWNLIGHTERS	YES	NO
4	DOWNLIGHTERS SURFACE MOUNTING (NOT BNC)	YES	YES
5	DIRECTIONAL SPOOTS FOR MOTORS (NOT BNC)	NO	YES
6	LED STRIPS COUNTER SILLING	NO	YES
7	LED STRIPS UNDER LIGHT	YES	YES
8	REPLACEMENT CABLE PLUGS	YES	YES
9	REPLACEMENT VENTAGE PLUGS	YES	YES
10	EXHOSKS BRONKING DISHASE	YES	YES
11	ILLUMINATED 4 ON COUNTER	NO	YES
12	THROUGH LIGHTS FOR DISHASE	NO	YES
13	BACK COUNTER EXTRACT	NO	NO
14	CABINET TRAP EXTRACT	NO	NO

FIRE

⑤ COMBINED HEAT/SMOKE DETECTOR WITH SOUNDER AND STROBE

FCEP MANUAL BREAK GLASS FIRE CALL POINT

FAP FIRE ALARM PANEL

FA 2 FIRE ALARM REPEATER PANEL

CCTV

 DOME PTZ CCTV CAMERA HARD WIRED TO
HARD DRIVE IN BOH

CEILINGS



NEW MF CEILING (1PM) IS TIE TAPPED AND FILLER HEIGHTS AS SHOWN ON DRAWING



NEW MF CEILING (1PM) OSB AND THEN (1PM) TIE TAPPED AND FILLED. HEIGHTS AS SHOWN ON DRAWING



IN WINDOW REVEALS NEW MF CEILING (1PM) AND THEN (1PM) TIE TAPPED AND FILLED. HEIGHTS AS SHOWN ON DRAWING


Expertly crafted
chocolate drink

and
ks

KNOOPS
Expertly crafted
chocolate drinks

 **CJS**

 CONSTRUCTION. JOINERY. SHOPFITTING.
WEB: www.cjsnw.co.uk/ - EMAIL: info@cjsnw.co.uk



PUFFIN
DESIGN
COMMERCIAL
ARCHITECTURE

© PUFFIN.DESIGN • INFO@PUFFIN.DESIGN

Site Address

68 CROSS STREET
MANCHESTER
M2 4JQ

Drawing Name

**PROPOSED GROUND
AND BASEMENT
CEILING PLANS**

Quote Date	15/11/2022	Drawn By	SUE JONES
------------	------------	----------	-----------

Scale(s)	1:30 @ A0
----------	-----------

Drawing Number 10041 RCP L001

© Copyright Puffin Design Limited/CJS (NW) Ltd.

