


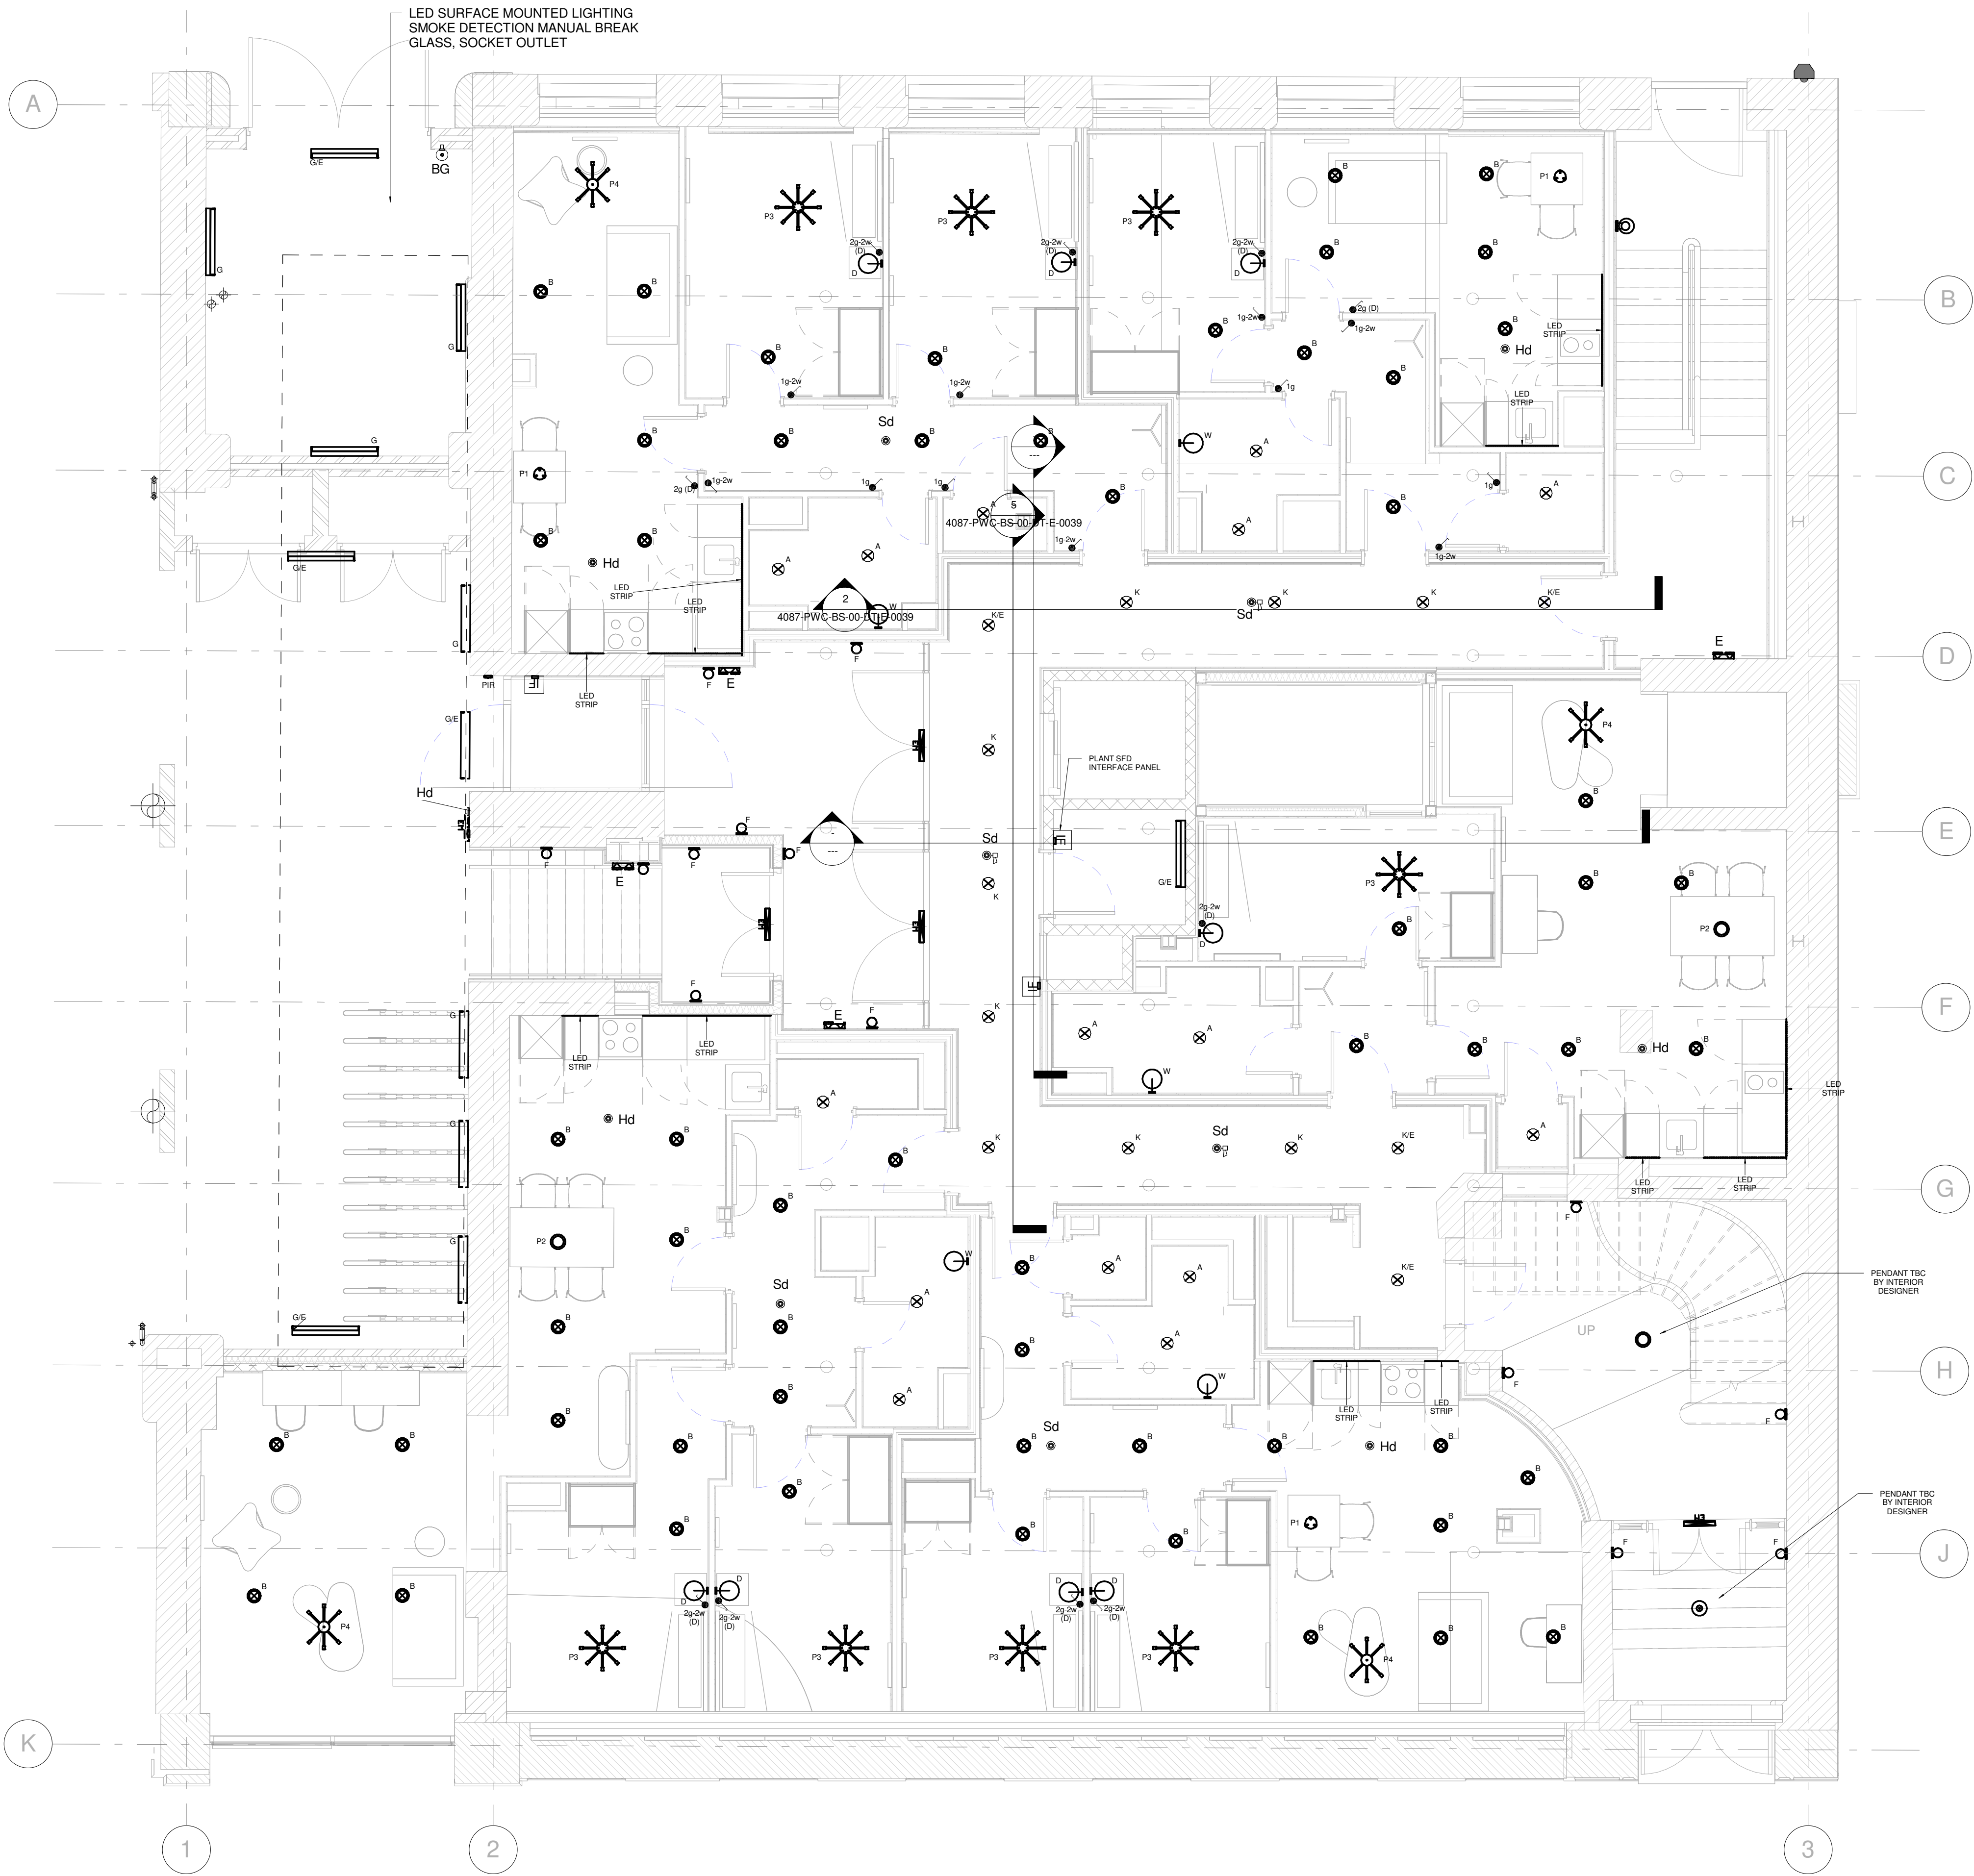

LIGHTING LEGEND :

- Sd SMOKE DETECTOR
- Sd SMOKE DETECTOR (WITH SOUNDER)
- Hd HEAT DETECTOR
- A RECESSED LED DOWNLIGHT (SEE SCHEDULE FOR DETAILS)
- B SURFACE MOUNTED LED DOWNLIGHT (SEE SCHEDULE FOR DETAILS)
- C AS PER "A" TYPE INSTALLED AS UPLIGHTER (SEE SCHEDULE FOR DETAILS)
- K RECESSED LED DOWNLIGHT UPLIGHTER (SEE SCHEDULE FOR DETAILS)
- P1 PENDANT LIGHT (LED LAMPS) (SEE SCHEDULE FOR DETAILS)
- P2 PENDANT LIGHT (LED LAMPS) (SEE SCHEDULE FOR DETAILS)
- P3 PENDANT LIGHT (LED LAMPS) (SEE SCHEDULE FOR DETAILS)
- P4 PENDANT LIGHT (LED LAMPS) (SEE SCHEDULE FOR DETAILS)
- J WALL MOUNTED LIGHT (SEE SCHEDULE FOR DETAILS)
- E WALL MOUNTED EMERGENCY LIGHT (SEE SCHEDULE FOR DETAILS)
- G LED BATTEN LIGHT (SEE SCHEDULE FOR DETAILS)
- W LED WALL LIGHT (BED SIDE) (SEE SCHEDULE FOR DETAILS)
- LED STRIP LED STRIP (KITCHEN) (SEE SCHEDULE FOR DETAILS)
- EM EMERGENCY EXIT SIGNS (SEE SCHEDULE FOR DETAILS)

NOTE :

REFER TO LIGHTING DETAILS AND SECTIONS DRAWING FOR MORE INFORMATION. (4087-PWC-BS-00-DT-E-0039)

/ E E = EMERGENCY FITTING

LIGHT SWITCHES :

- 1g SINGLE GANG LIGHT SWITCH
- 2g TWO GANG LIGHT SWITCH
- 2g (D) TWO GANG LIGHT SWITCH (DIMMER)
- 1g 2w 1 GANG TWO WAY LIGHT SWITCH
- 2g 2w (D) TWO GANG TWO WAY LIGHT SWITCH (DIMMER)

GENERAL NOTES :

1. ALL SERVICE ROUTES DETAILED ARE APPROXIMATE. THE CONTRACTOR SHALL BE RESPONSIBLE FOR DETERMINING THE EXACT ROUTES AND POSITIONS OF ALL INSTALLED SERVICES AND EQUIPMENT.
2. THE EXACT POSITION OF ALL SERVICES AND EQUIPMENT SHALL BE AGREED BY THE CONTRACT ADMINISTRATOR.
3. THE CONTRACTOR SHALL BE RESPONSIBLE FOR FULLY CO-ORDINATING ANY SERVICES INSTALLED WITH THE BUILDING FABRIC AND SERVICES INSTALLED BY OTHERS.
4. THIS DRAWING SHALL BE READ IN CONJUNCTION WITH ALL MECHANICAL, ELECTRICAL, ARCHITECTURAL AND STRUCTURAL DRAWINGS, CONTRACT DOCUMENTATION AND SPECIFICATION FOR THE WORKS.
5. THIS DRAWING FORMS PART OF THE SPECIFICATION FOR THE WORKS.
6. ALL DIMENSIONS SHOWN ARE IN MILLIMETRES.
7. DO NOT SCALE FROM THIS DRAWING
8. THIS DRAWING SHOULD BE READ IN CONJUNCTION WITH THE REVIT MODEL PROVIDED.

Rev	Description	Issue Date
T7	Issued For Tender	06-05-22
T6	Issued For Tender	20-01-22
T5	Issued For Tender	10-09-21
T4	Issued For Tender	14-07-21
T3	Issued For Tender	01-07-21
T2	Issued For Tender	21-05-21
T1	Issued For Tender	16-04-21

Client Name :
BEECH CONSTRUCTION

Project :
BLOOM STREET

Title :
Ground Floor - Lighting Layout



- Burnham House, 373 Bury New Road, Manchester, M25 1AW.
Tel: 0161 773 1177
manchester@parker-wilson.co.uk
- 2nd Floor, 72, Cannon Street, London EC4N 6AE.
Tel: 0207 251 4500
london@parker-wilson.co.uk

www.parker-wilson.co.uk

PWC PROJECT No. 4087	Drawn by : MK	Checked by : AL
Scale 1 : 50	Size A1	Date : Issue Date
Drawing Number 4087-PWC-BS-00-PL-E-0031	Rev T7	

1 00 - Lighting and FA
1 : 50

14/11/2022 17:23:42