
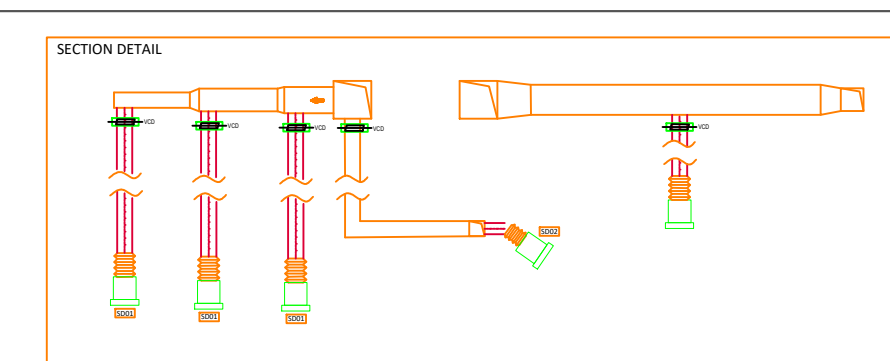


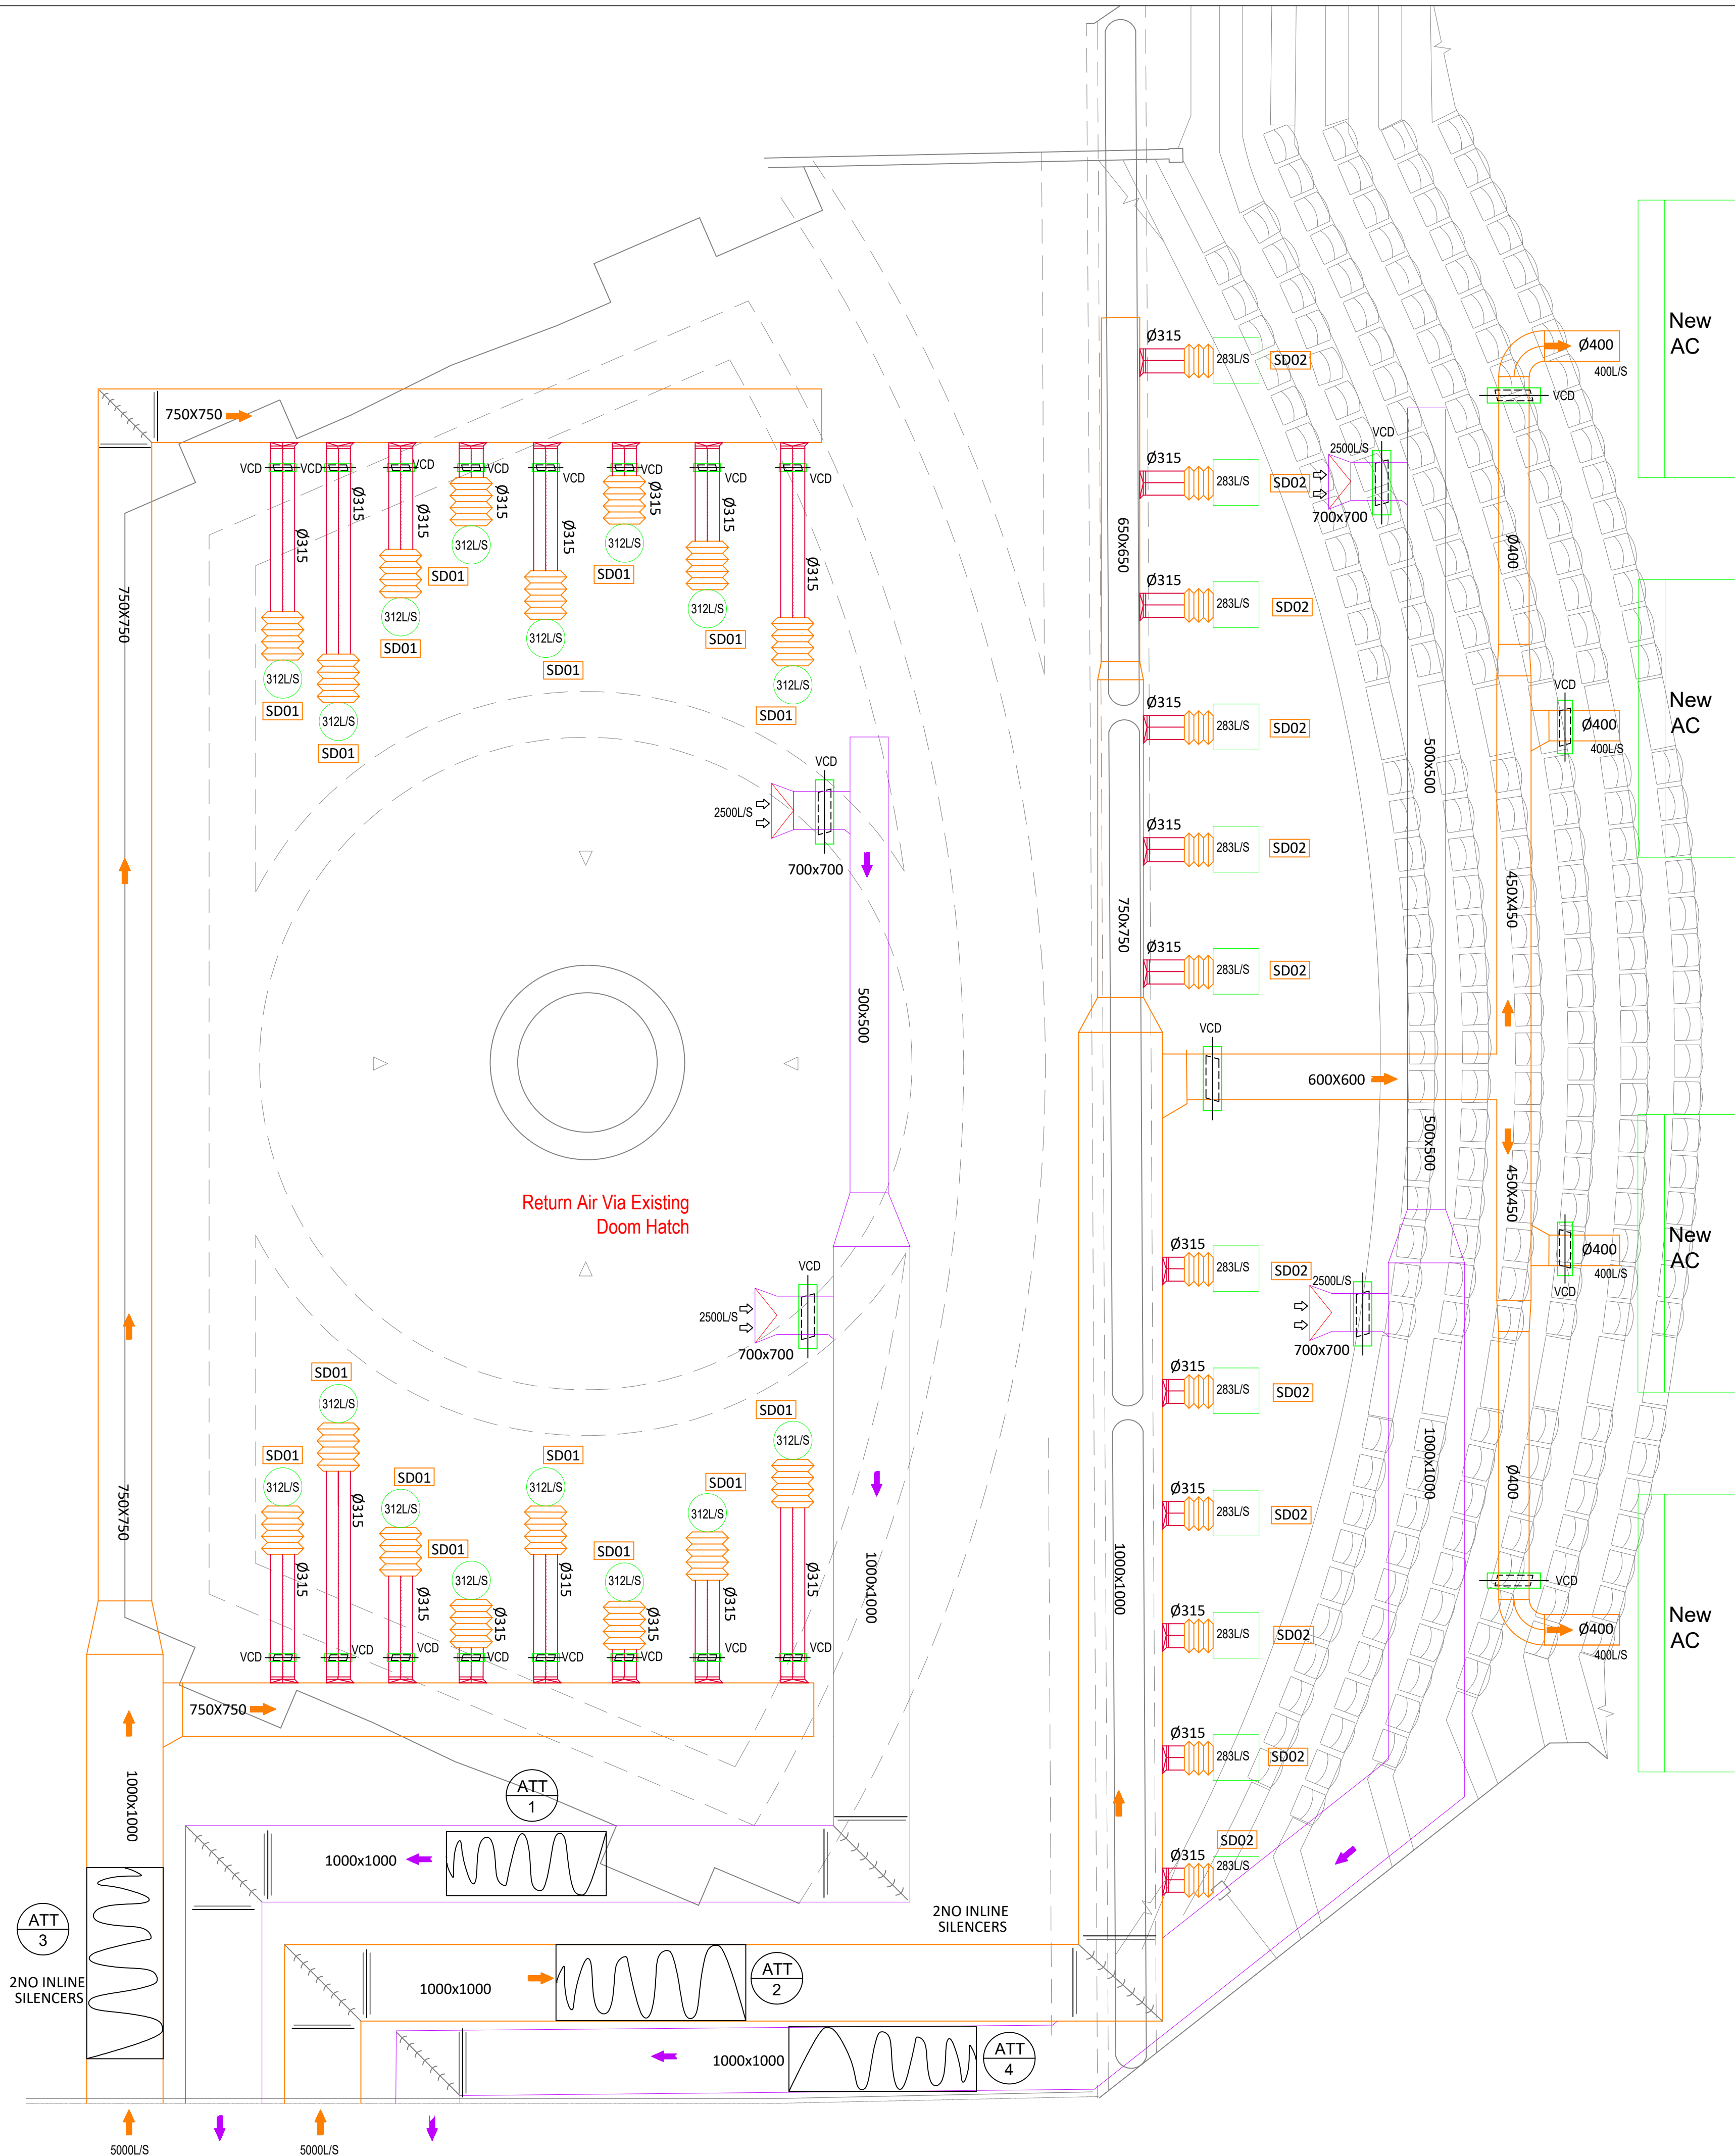

GENERAL NOTES:

LEGEND:

- New Circular Jet Nozzle
- Volume Control Device
- Flexible Ductwork
- Attenuator
- New Extract Ductwork
- New supply Ductwork
- Air Handling Unit
- Existing Supply Grille

D	"FOR APPROVAL"	C.N.	S.H.	08/12/22
C	"FOR APPROVAL"	C.N.	S.H.	08/12/22
B	"FOR APPROVAL"	C.N.	S.H.	05/12/22
A	"FOR APPROVAL"	C.N.	S.H.	28/11/22
REV.	DESCRIPTION	DES.	CHK'D	DATE

SDH Building Services

SDH Building Services Ltd
Unit 29b
Waters Meeting Business Park
Britannia Way
Bolton
BL2 2HH

Telephone: 01204 305 053
e-mail: info@sdhbuildingservices.co.uk

PROJECT
**PALACE THEATRE
MANCHESTER**

TITLE
GRAND TIER HVAC LAYOUT

STAGE
"FOR APPROVAL"

SCALE 1:50	ORIGINAL SIZE A1	DATE NOV / 2022
DRAWN C.N.	DESIGNED C.N.	CHECKED S.H.
DRAWING NUMBER SDH-PTM-M01	REVISION D	