



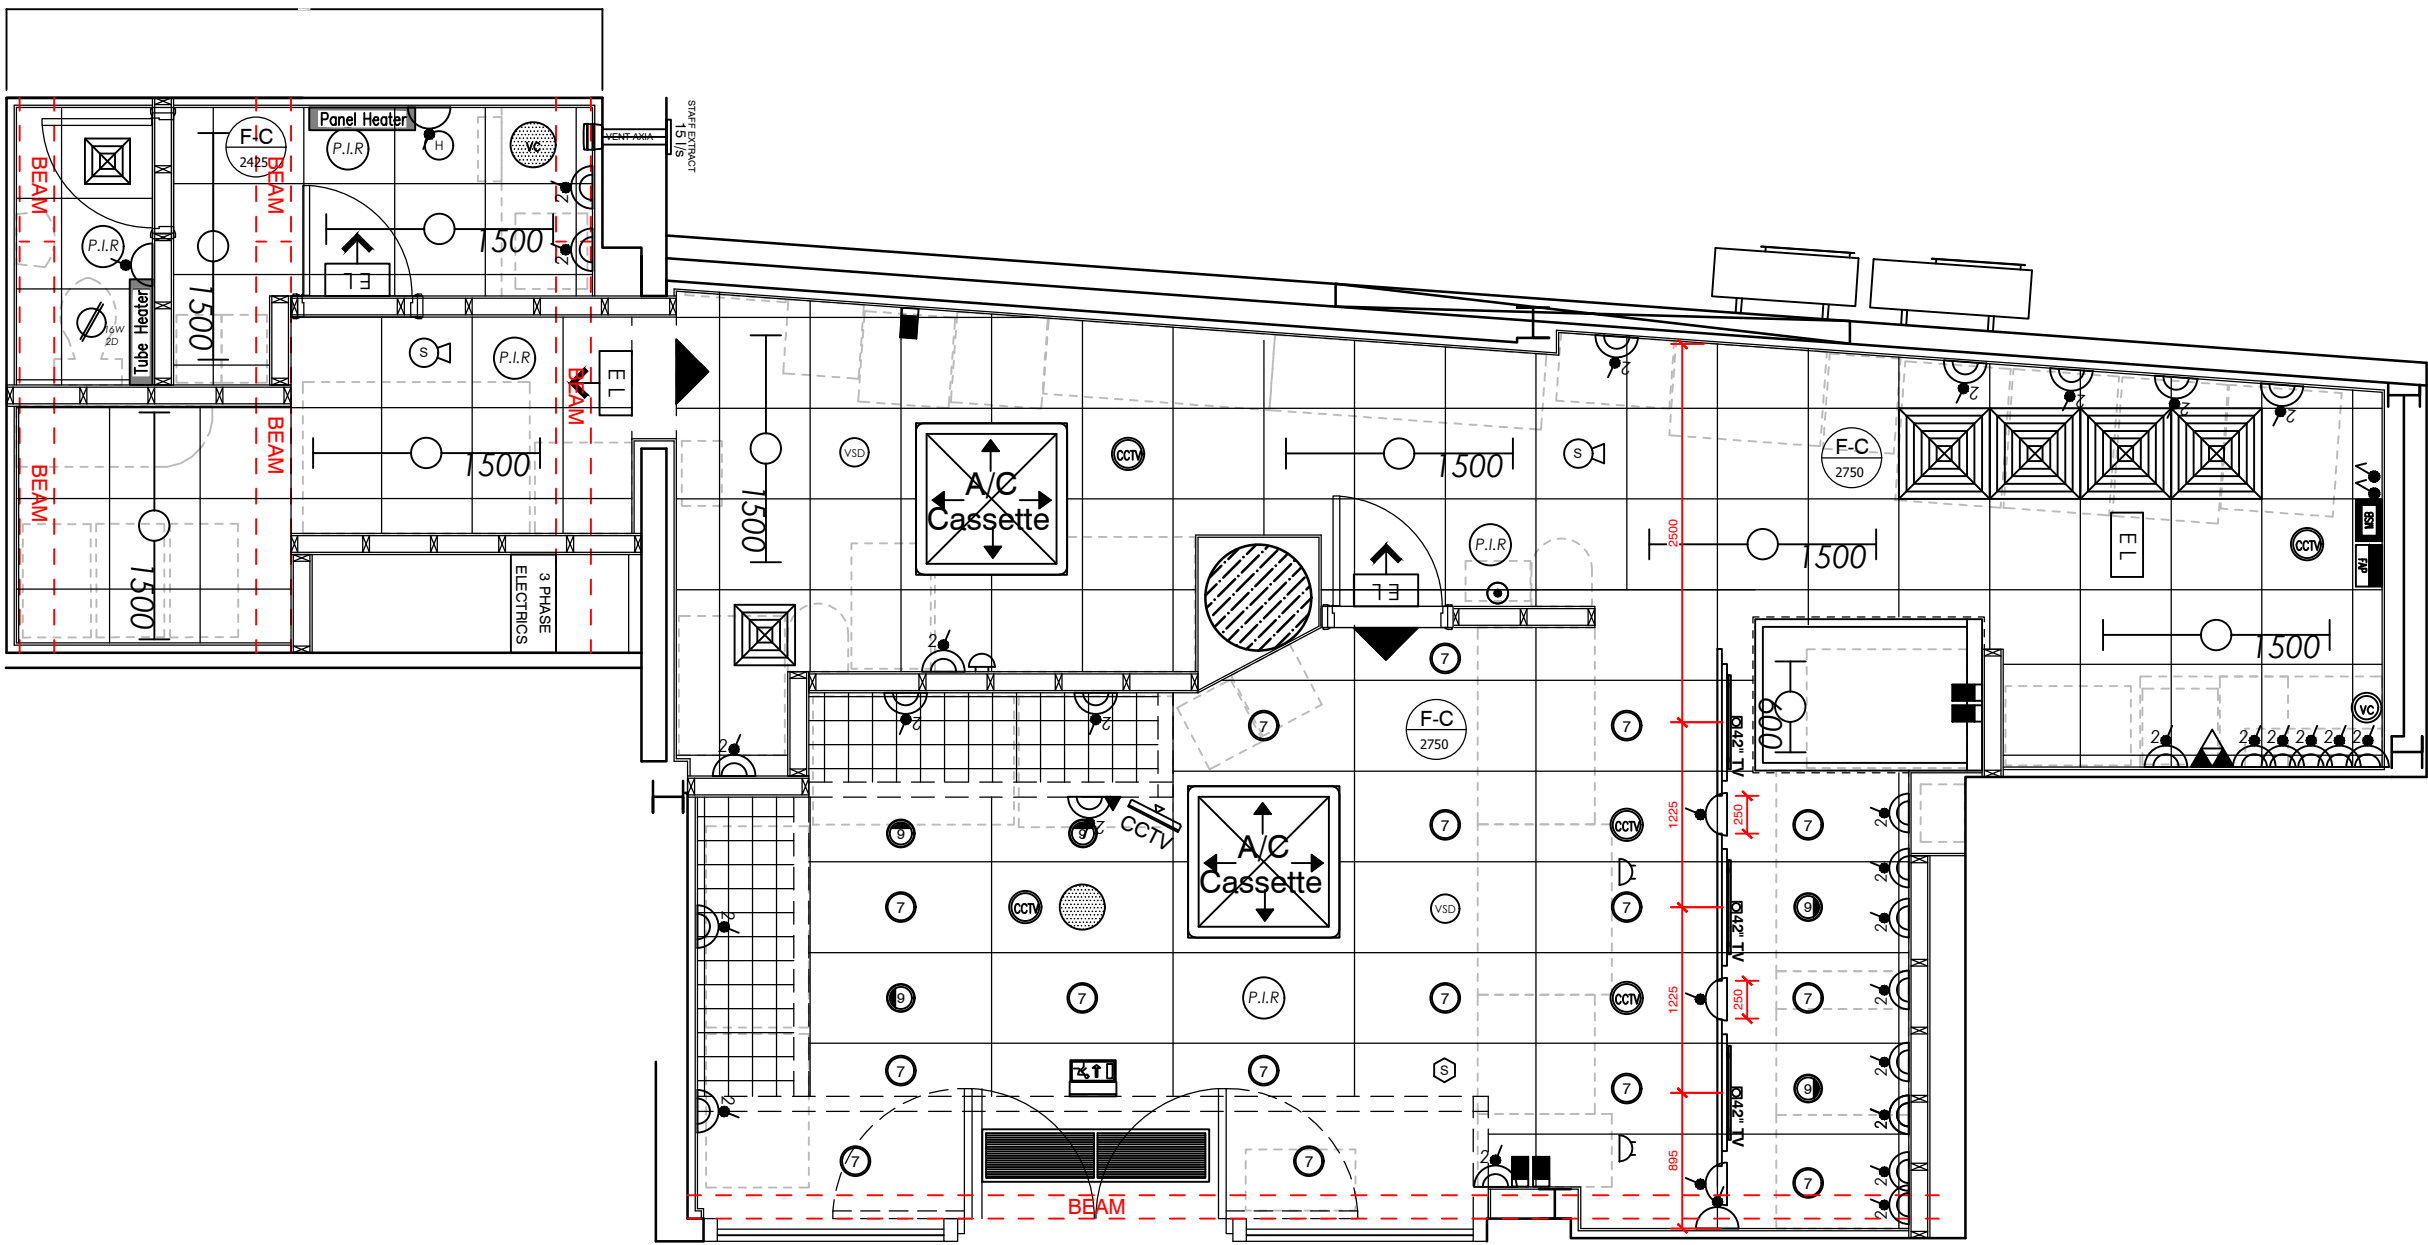

EXISTING RCP AND POWER PLAN (1:50)

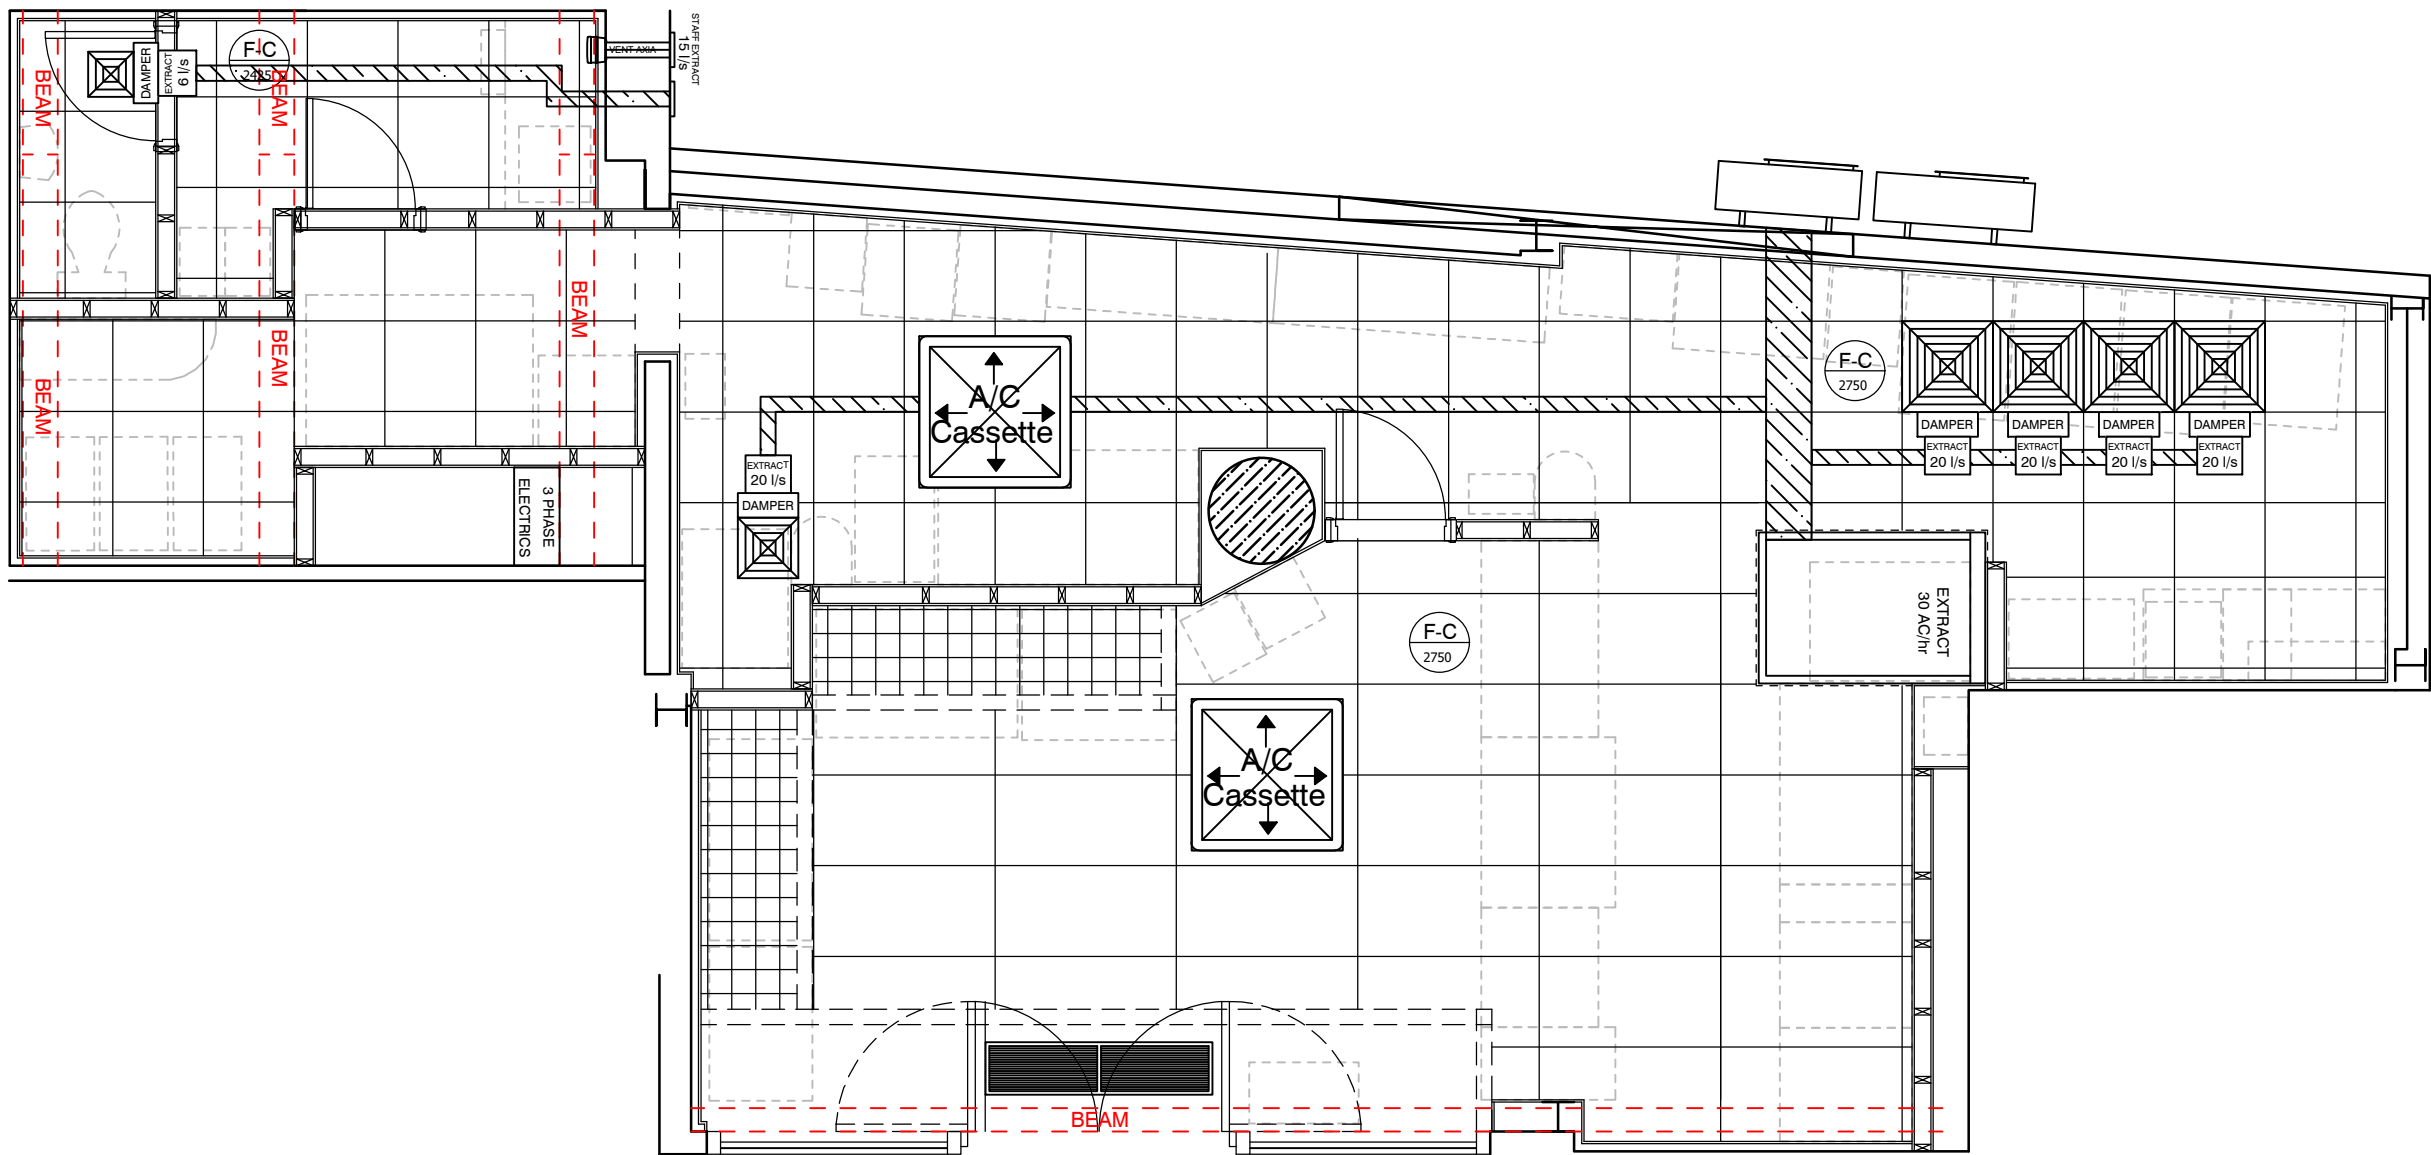

EXISTING HVAC PLAN (1:50)

REV	DESCRIPTION	DATE	NAME
GREGGS			
GREGGS Plc (PENNINES) 31 GREENSIDE STREET OPENSHAW MANCHESTER M11 2HW Tel: (0161) 274 2760			
Shop S Number & Name S3526 MANCHESTER VICTORIA STATION			
Title EXISTING RCP POWER HVAC SURVEY			
Site Address CONCOURSE KIOSK VICTORIA STATION MANCHESTER M3 1WY			
Gross Building Area 73.3 Sq m		Gross Sales Area 18 Sq m	
Drawing No. RPN/S3526/02			Rev.
Date 01.06.15		Scale 1:50	@ A1
Drawn by GREGGS		Scale Bar 0 500 1000 1500 2000 2500mm	
Issued 07.07.22		SCALE 1:50	