



DRAFTED BY	VK
CHECKED BY	AG
DRAWING NUMBER	

SECTION 1: SURVEY

VF MANCHESTER EXPRESS

Disclaimer:
All dimensions given in good faith and believed to be correct.
All measurements to be verified for accuracy after the stripout and prior to creating Construction Phase drawings.
Contractors please always verify measurements prior to starting work. Do not scale off this drawing.
If in doubt please consult the Surveyor or the PM in charge.
No responsibility can be taken for any errors found by measuring off these drawings.



CLIENT NAME
VF Corporation

PROJECT NAME
VF Machester Express

DESCRIPTION
Category B internal fit out to provide No 5 showroom spaces for 5 different Brands teams of the VF Corporation Group (Vans, The North Face, Timberland, Napapijri and Altra) a co-working office space with hot desking facilities and a large meeting room with additional amenities for the staff welfare. To preserve the full visibility of the listed concrete columns, the internal lightweight partitions will be installed by alternating a mix of fully glazed sections with some drywall sections required to provide fixing points for the showrooms shelving units.

SITE ADDRESS
5th Floor, The Express Building, 9 Great Ancoats St, Manchester M4 5AD

PROJECT NUMBER
VFC Manchester 517

REVISIONS

- | | |
|----|------------|
| 1. | 14-12-2022 |
| 2. | 16-12-2022 |
| 3. | 19-12-2022 |

ARCHITECT




OFFICE
8 St James's Square, St. James's, London, SW1Y 4JU

SCALE

DRAFTED BY
VK

CHECKED BY
AGB

DRAWING NUMBER

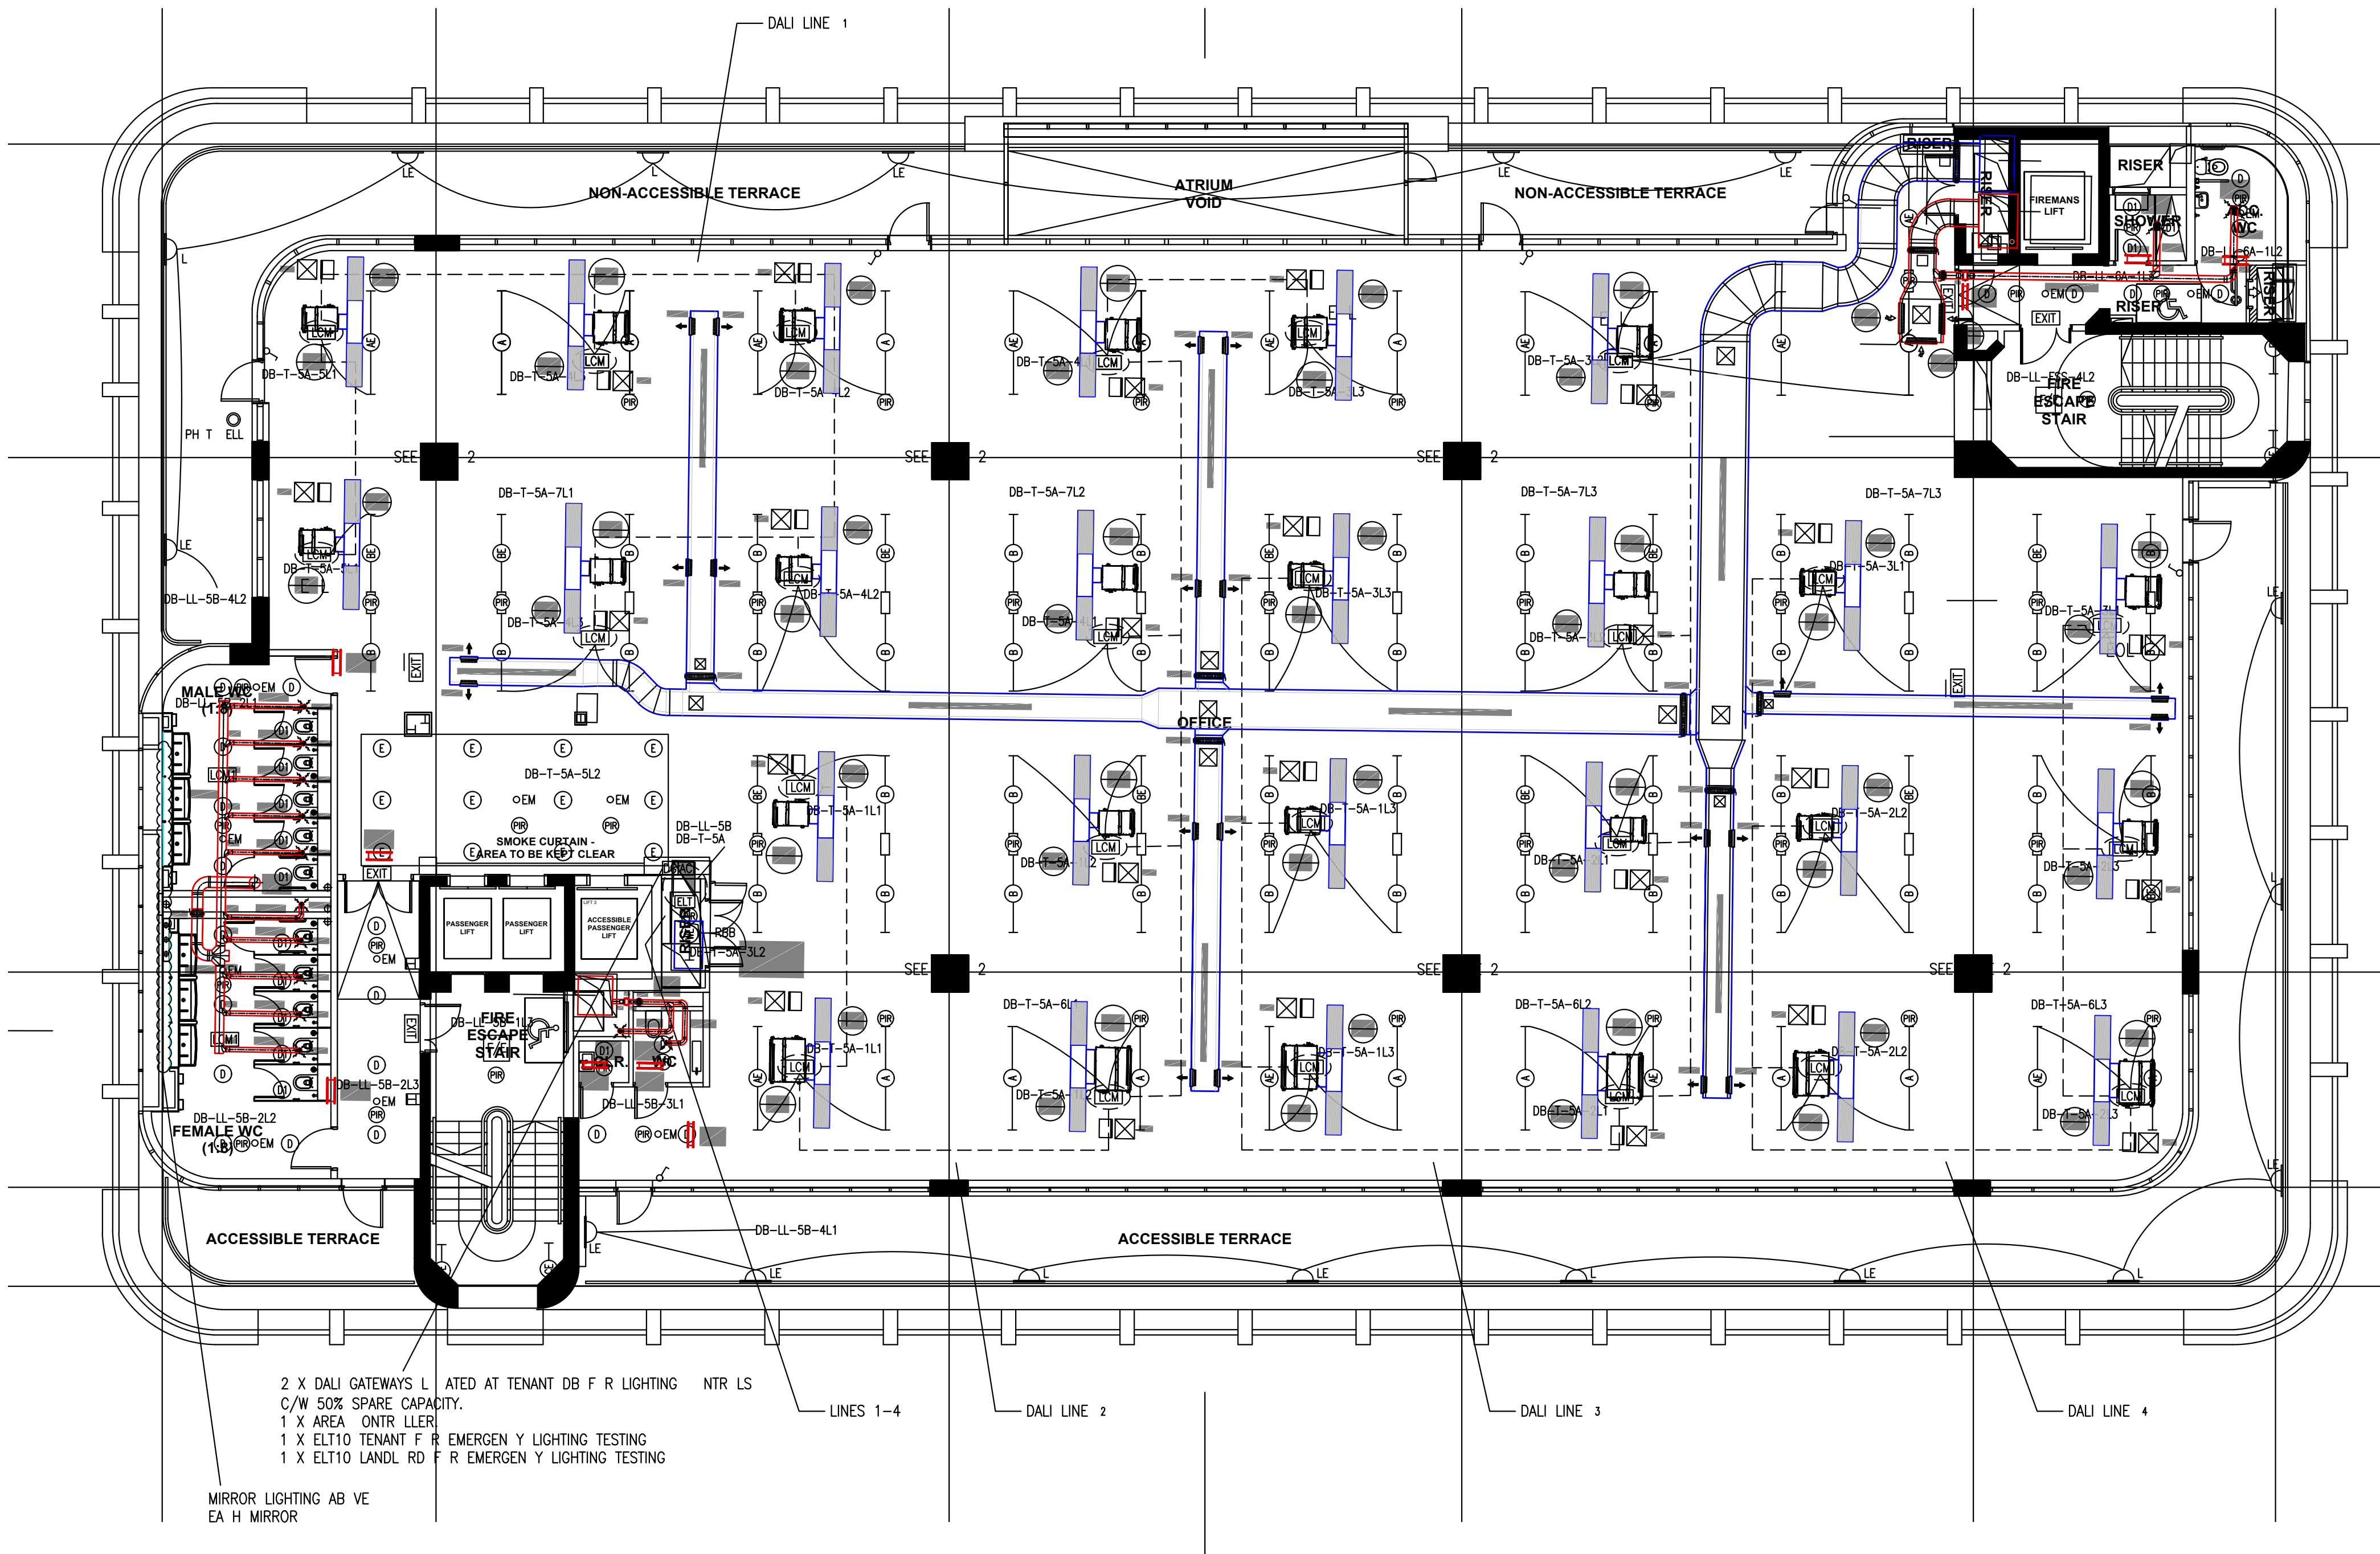

0 1m 2m 3m

2 Existing Reflective Ceiling Plan
S104.0 SCALE 1:100

MECHANICAL SERVICES LEGEND

- DAIKIN FAN COIL UNIT
FIRE DAMPER
VOLUME CONTROL DAMPER
ATTENUATOR
CONSTANT VOLUME BOX
VARIABLE VOLUME BOX
ACCESS PANEL
AC REMOTE CONTROLLER
AC CENTRAL CONTROLLER

TYPE	DESCRIPTION
1	XLN LED 8800LM PLX 2400mm DALI WHITE FINISH 62W.
2	XLN LED 6600LM PLX 1800mm DALI WHITE FINISH 47W.
3	RECESSED XLN LED 8800LM PLX 2400mm DALI WHITE FINISH 62W.
4	RECESSED XLN LED 6600LM PLX 1800mm DALI WHITE FINISH 47W.
5	LUXIONA ARTSHAPE LINE LED, 1200mm WALL MOUNTED.
6	ORSAM LEDVANCE 14WATT RECESSED DOWNLIGHT.
7	ORSAM LEDVANCE 21WATT RECESSED DOWNLIGHT.
8	ROBUS ULTIMUM 7WATT RECESSED DOWNLIGHT.
9	GAMMA TTT 3004 RECESSED LED DOWNLIGHT 840 FINISH, 24.5W.
10	ARTSHAPE SQ LED, 8000MLM 65WATT
11	500 GLOBE PENDANT, LED, 47W.
12	HIGH OUTPUT 4000K LED TAPE CONCEALED AROUND COLUMNS/ CEILING DETAIL (EXACT TYPE TBC).
13	PHILIPS CORELINE LUMINAIRE WT120C LED 225, 840 FINISH.
14	RECESSED 1.5W SELF CONTAINED LED EMERGENCY COMPLETE WITH 3HR BATTERY BACK UP.
15	SURFACE/SUSPENDED/WALL MOUNTED (AS APPROPRIATE) NON-MAINTAINED LED EMERGENCY EXIT SIGN, COMPLETE WITH LEGEND AND 3HR BATTERY BACK UP. AS ANSELL LIGHTING EAGLE.
16	PAP-POLO 900 DIRECT SUSPENDED PENDANT, 60W COMPLETE WITH 3HR BATTERY BACK UP.
17	ANSELL ENDURANCE LED RECESSED PANEL, 600x600 30W.

LIGHTING CONTROL NOTES

- 1 - PIR ACTIVATES LIGHTING ON
PRESENCE, LIGHTING REMAINS ON UNTIL
10MINS AFTER THE LAST PIR FOR LINEAR
LIGHTING SWITCHES OFF
2 - FEATURE LIGHTING AROUND COLUMNS
CONTROLLED AS NOTE 1
3 - LIGHTING AROUND ATRIUM AREA
CONTROLLED AS NOTE 1

Disclaimer:
All dimensions given in good faith and believed to be correct.
All measurements to be verified for accuracy after the stripout and prior to creating Construction Phase drawings.
Contractors please always verify measurements prior to starting work. Do not scale off this drawing.
If in doubt please consult the Surveyor or the PM in charge.
No responsibility can be taken for any errors found by measuring off these drawings.



CLIENT NAME
VF Corporation

PROJECT NAME
VF Machester Express

DESCRIPTION
Category B internal fit out to provide No 5 showroom spaces for 5 different Brands teams of the VF Corporation Group (Vans, The North Face, Timberland, Napapijri and Altra) a co-working office space with hot desking facilities and a large meeting room with additional amenities for the staff welfare. To preserve the full visibility of the listed concrete columns, the internal lightweight partitions will be installed by alternating a mix of fully glazed sections with some drywall sections required to provide fixing points for the showrooms shelving units.

SITE ADDRESS
5th Floor, The Express
Building, 9 Great Ancoats
St, Manchester M4 5AD

PROJECT NUMBER
VFC Manchester 517

REVISIONS

- | | |
|----|------------|
| 1. | 14-12-2022 |
| 2. | 16-12-2022 |
| 3. | 19-12-2022 |

ARCHITECT



OFFICE
8 St James's Square, St. James's,
London, SW1Y 4JU

Existing Reflective Ceiling Plan

SCALE

DRAFTED BY
VK
CHECKED BY
AGB
DRAWING NUMBER

S104.0

SECTION 2:
PROPOSED LAYOUT

VF MANCHESTER EXPRESS

Disclaimer:
All dimensions given in good faith and believed to be correct.
All measurements to be verified for accuracy after the stripout and prior to creating Construction Phase drawings.
Contractors please always verify measurements prior to starting work. Do not scale off this drawing.
If in doubt please consult the Surveyor or the PM in charge.
No responsibility can be taken for any errors found by measuring off these drawings.



CLIENT NAME
VF Corporation

PROJECT NAME
VF Manchester Express

DESCRIPTION
Category B internal fit out to provide No 5 showroom spaces for 5 different Brands teams of the VF Corporation Group (Vans, The North Face, Timberland, Napapijri and Altra) a co-working office space with hot desking facilities and a large meeting room with additional amenities for the staff welfare. To preserve the full visibility of the listed concrete columns, the internal lightweight partitions will be installed by alternating a mix of fully glazed sections with some drywall sections required to provide fixing points for the showrooms shelving units.

SITE ADDRESS
5th Floor, The Express Building, 9 Great Ancoats St, Manchester M4 5AD

PROJECT NUMBER
VFC Manchester 517

REVISIONS

- | | |
|----|------------|
| 1. | 14-12-2022 |
| 2. | 16-12-2022 |
| 3. | 19-12-2022 |

ARCHITECT



OFFICE
8 St James's Square, St. James's, London, SW1Y 4JU

SCALE

DRAFTED BY
VK

CHECKED BY
AGB

DRAWING NUMBER
P200:0

	DAIKIN FAN COIL UNIT
	FIRE DAMPER
	VOLUME CONTROL DAMPER
	ATTENUATOR
	CONSTANT VOLUME BOX
	VARIABLE VOLUME BOX
	ACCESS PANEL
	AC REMOTE CONTROLLER
	AC CENTRAL CONTROLLER

	Data Rack
<i>Wall mounted sockets</i>	
	Power socket
	UTP connection
<i>Floorbox</i>	
	Floorbox with $4 \times \sqrt{} / 2 \times \sqrt{}$
	Floorbox with $8 \times \sqrt{} / 4 \times \sqrt{}$ for scrum area
<i>Desk mounted multi-sockets</i>	
	2 TYPE 2

Wall mounted multi-sockets

TV

4x2' / 2x4' TV ZOOM

HD

DYSON HAND DRYER

Ceiling mounted wi-fi APS (data+power)

AP **CEILING MOUNTED WI-FI APS**

GAMMA TTT 3004 RECESSED LED DOWNLIGHT 840 FINISH, 24.4W.

Wall mounted Sonos speakers (power outlet)

S1 SONOS PLAY 1

Existing Light in proposed position

Existing Light in existing position

2m Track Light

Label	Symbol	pcs.	Art.N.	Lighting Tool	color	cut-off diameter (mm)	Phy. Pays.
						h	
		40	16ST9000-1W-ST	Stucchi Standard 3 Phasen Stromschiene mit Datenbus, weiß (RAL 9010) St-401			
		88	16ST9000-2W-ST	Stucchi Standard 3 Phasen Stromschiene mit Datenbus, weiß (RAL 9010) St-404			
		21	16ST9002-W	Zubehör für Stucchi St 3 Ph Stromschiene mit Datenbus Stromschaltung, 3-Phasen 16A, (RAL 9010) St-401			
		62	16ST9003-W	Zubehör für Stucchi St 3 Ph Stromschiene mit Datenbus Stromschaltung, 3-Phasen 16A, (RAL 9010) St-401			
		31	16ST9004-W	Zubehör für Stucchi St 3 Ph Stromschiene mit Datenbus, weiß (RAL 9010) St-401			
		19	16ST9011-W	Zubehör für Stucchi St 3 Ph Stromschiene mit Datenbus, weiß (RAL 9010) St-401			
		3	16ST9012-W	Zubehör für Stucchi St 3 Ph Stromschiene mit Datenbus Stromschaltung, 3-Phasen 16A, (RAL 9010) St-401			
		4	16ST9015-W	Zubehör für Stucchi St 3 Ph Stromschiene mit Datenbus Stromschaltung, 3-Phasen 16A, (RAL 9010) St-401			
		8	16ST9016W	Zubehör für Stucchi St 3 Ph Stromschiene mit Datenbus Stromschaltung, 3-Phasen 16A, (RAL 9010) St-401			
		235	16ST9000-KIT13	Zubehör für Stucchi St 3 Ph Stromschiene mit Datenbus Auhängungskit, Seil 3 m, Stucchi St			
		159	02IMT18066-401	Iqona IMT			351,00
				02IMT 930PW FL 3202im-401 DALI			5500,00

P	62	02IMT18009-401	Iqona IMT	35.1W
		02IMT 930PW MFL 3241m-401	DALI	2176.2W
P	29	02IMT18008-401	Iqona IMT	35.1W
		02IMT 930PW SP 3280lm-401	DALI	1017.9W
K	28	PDC-02IMT20205-401	Iqona IMT	35.1W
		02IMT 930PW WFL 3241m-401	DALI	982.8W
	278	total count of fixtures		total connected value connected value W/m ² : 16,8 W/m ²

	Fire Alarm Panel
	Fire Alarm Repeater Panel
	Smoke Detector
	Heat Detector
	Multi Sensor Detector
	Manual Call Point
	Sounder Base
	Sounder/Beacon Base
	Sounder
	Sounder/Beacon
	Beacon
	Interface
	Power Supply
	Fixed Magnet

Disclaimer:
All dimensions given in good faith and believed to be correct.
All measurements to be verified for accuracy after the stripout and prior to creating Construction Issue Drawings.
Contractors please always verify measurements prior to starting work. Do not scale off this drawing.
If in doubt please consult the Surveyor or the PM in charge.
No responsibility can be taken for any errors found by measuring off these drawings.



CLIENT NAME
VF Corporation

PROJECT NAME
VF Manchester Express

DESCRIPTION
Category B internal fit out to provide No 5 showroom spaces for 5 different Brands teams of the VF Corporation Group (Vans, The North Face, Timberland, Napapijri and Altra) a co-working office space with hot desking facilities and a large meeting room with additional amenities for the staff welfare. To preserve the full visibility of the listed concrete columns, the internal lightweight partitions will be installed by alternating a mix of fully glazed sections with some drywall sections required to provide fixing points for the showrooms shelving units.

SITE ADDRESS
5th Floor, The Express
Building, 9 Great Ancoats
St, Manchester M4 5AD

PROJECT NUMBER	VFC Manchester 517
----------------	--------------------

1.	14-12-2022
2.	16-12-2022
3.	19-12-2022

ARCHITECT





OFFICE
8 St James's Square, St. James's,
London, SW1Y 4JU

Proposal Coordination
Proposed
Reflective Ceiling Plan

SCALE

DRAFTED BY	VK
CHECKED BY	AG
DRAWING NUMBER	

 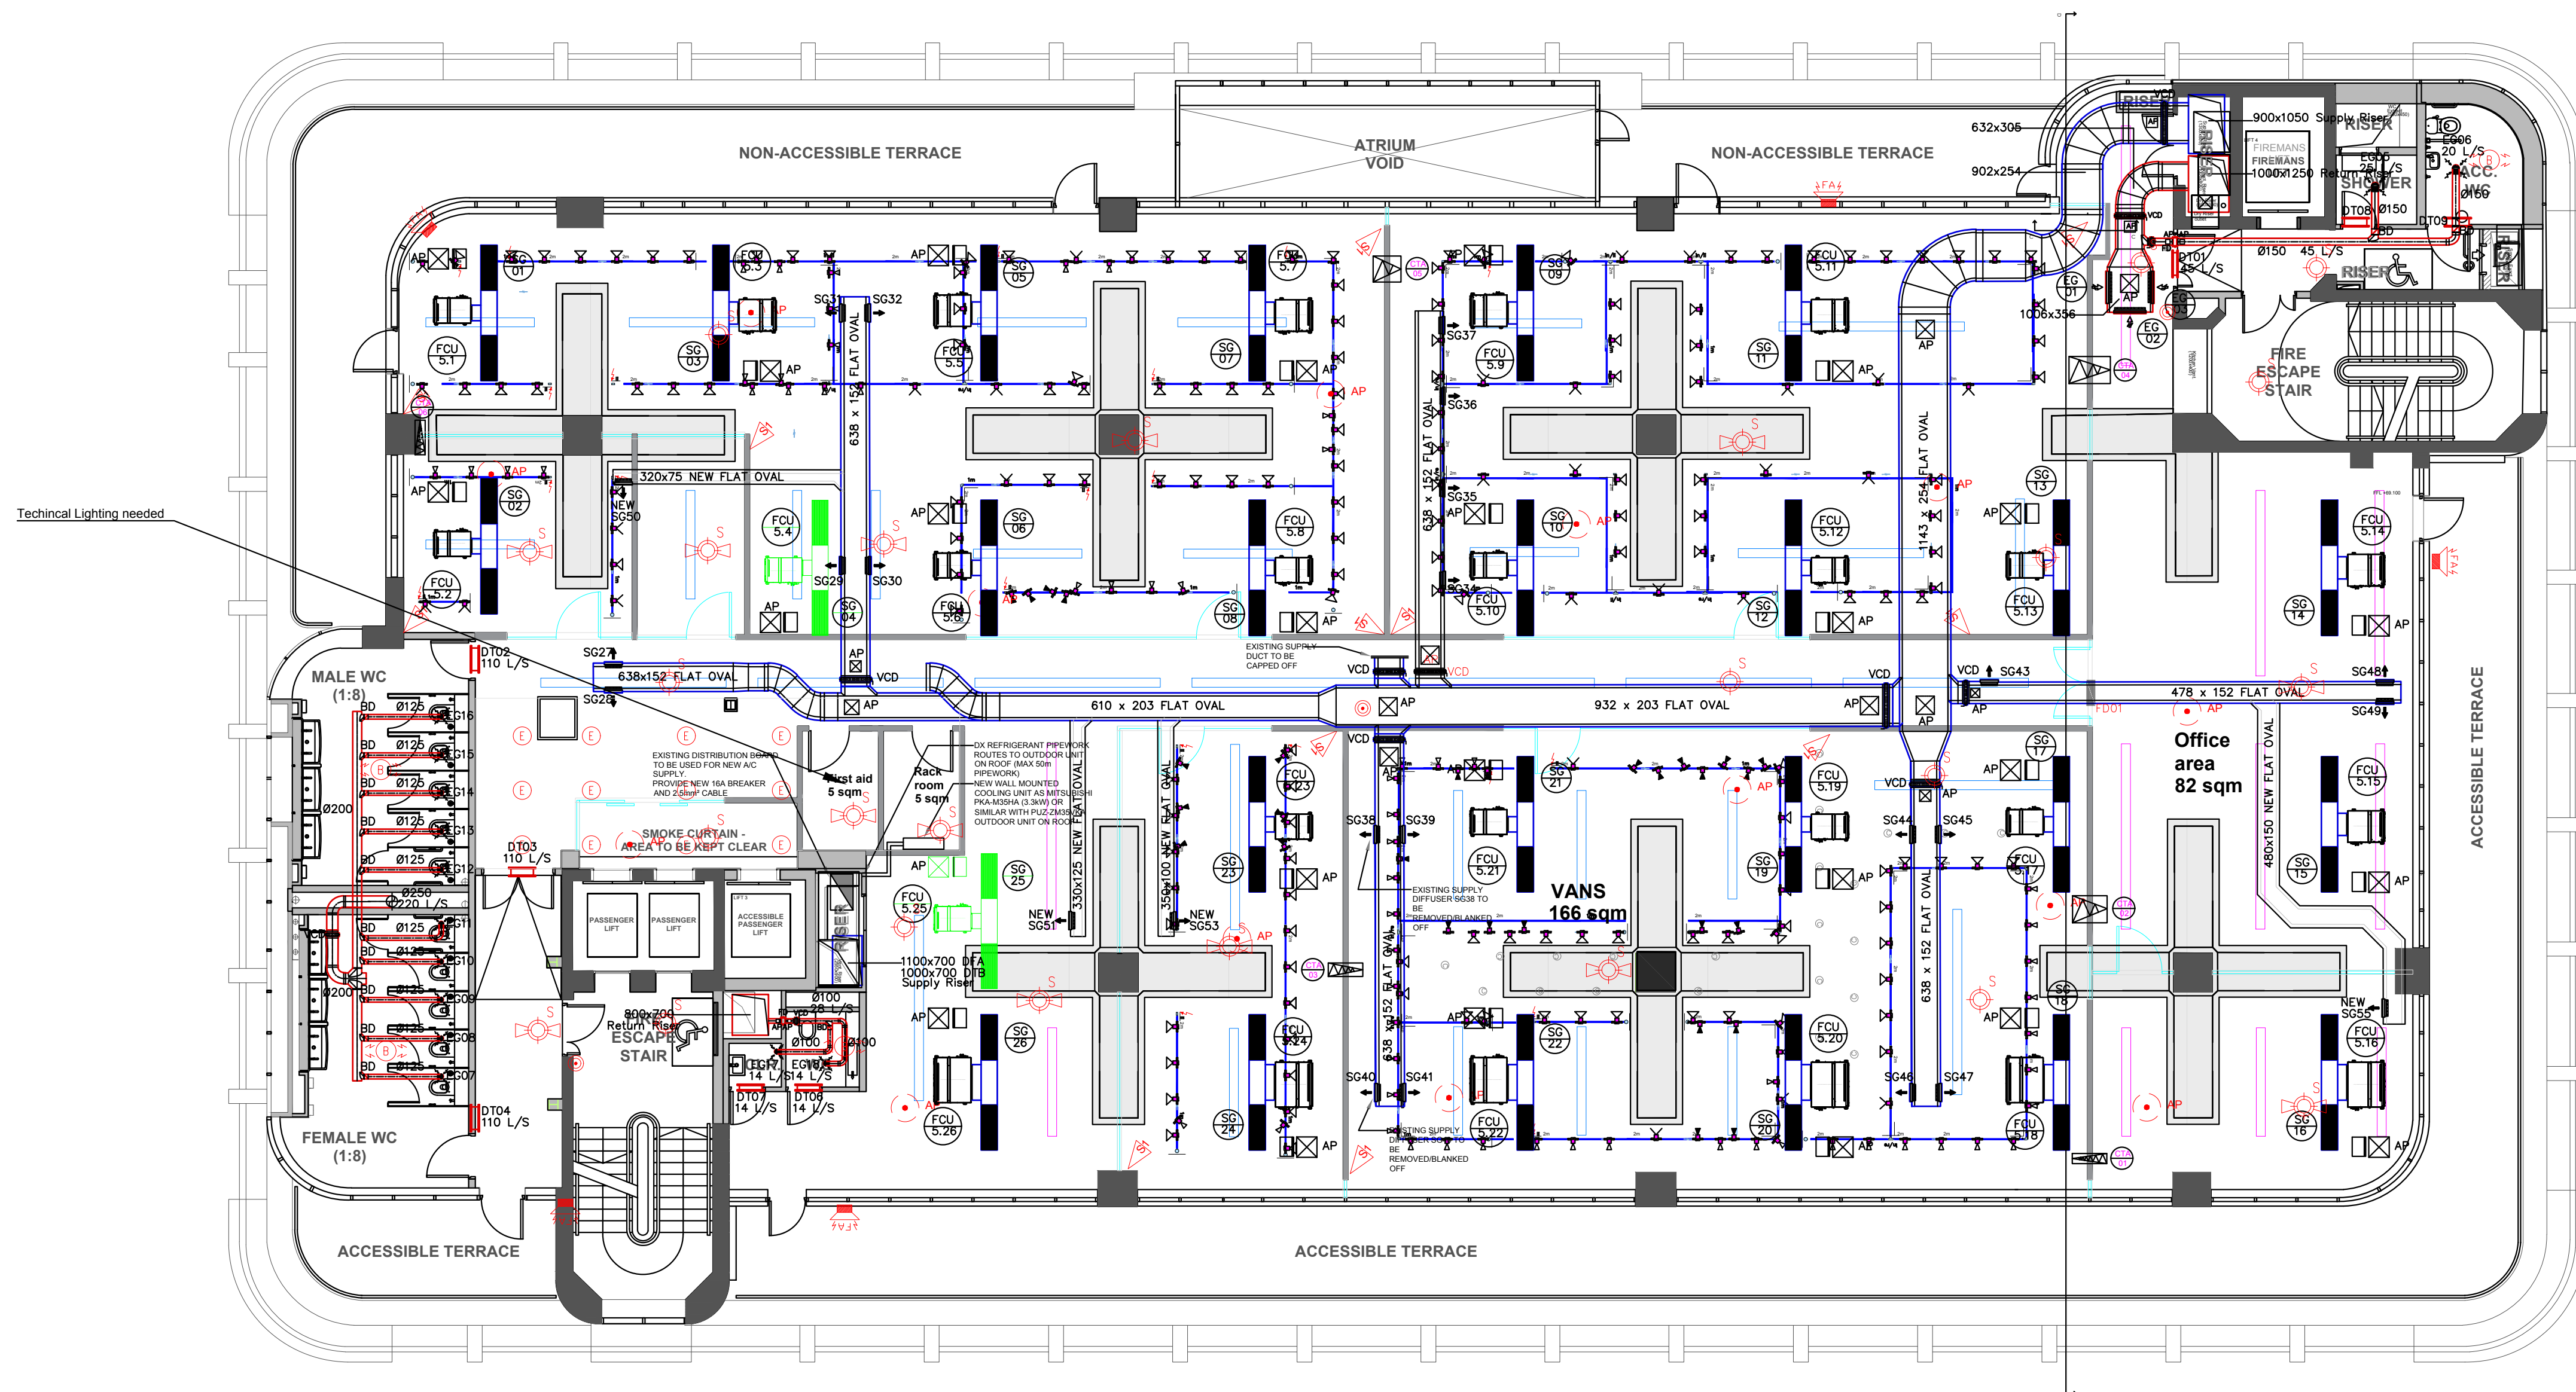

1 Proposal Reflective Ceiling Plan
P200.5 SCALE 1:100