

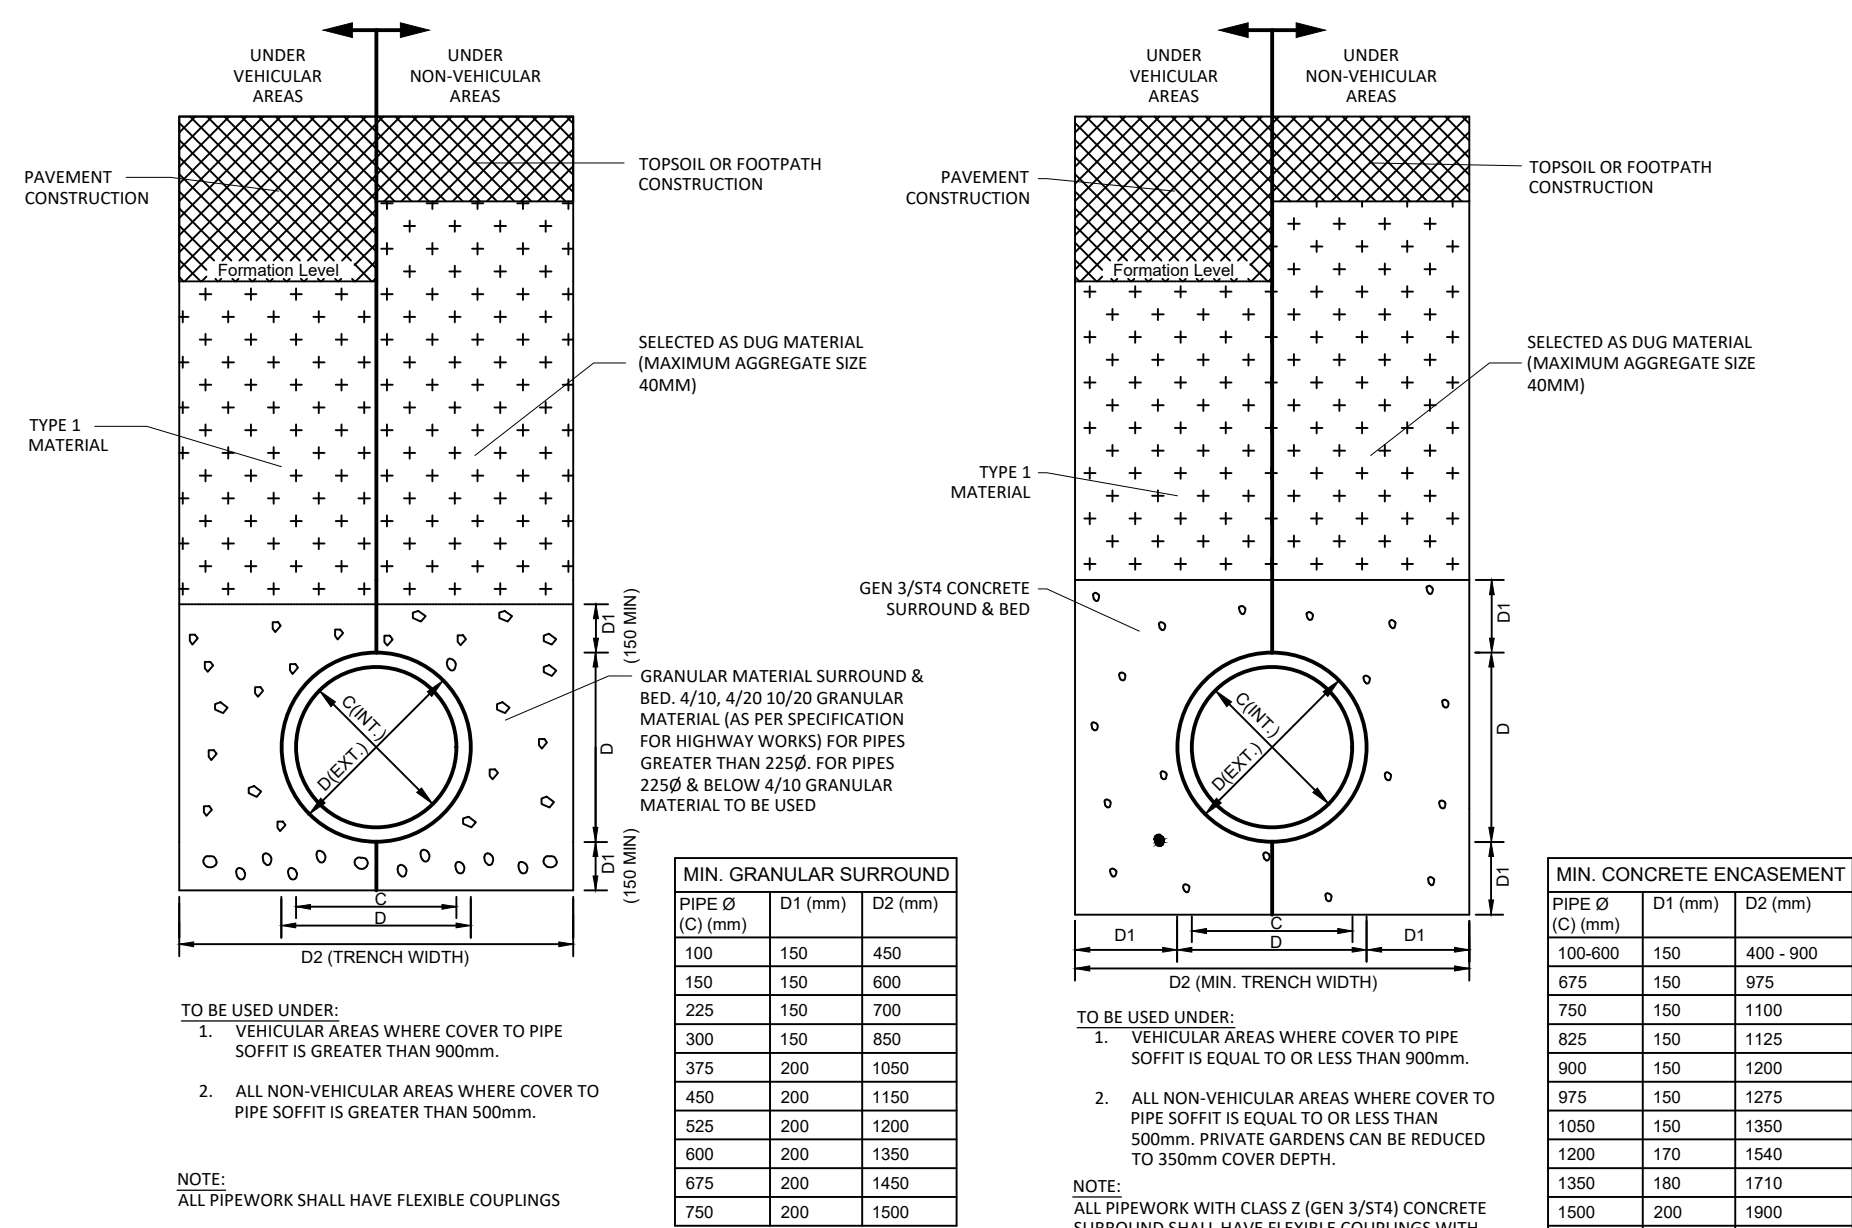
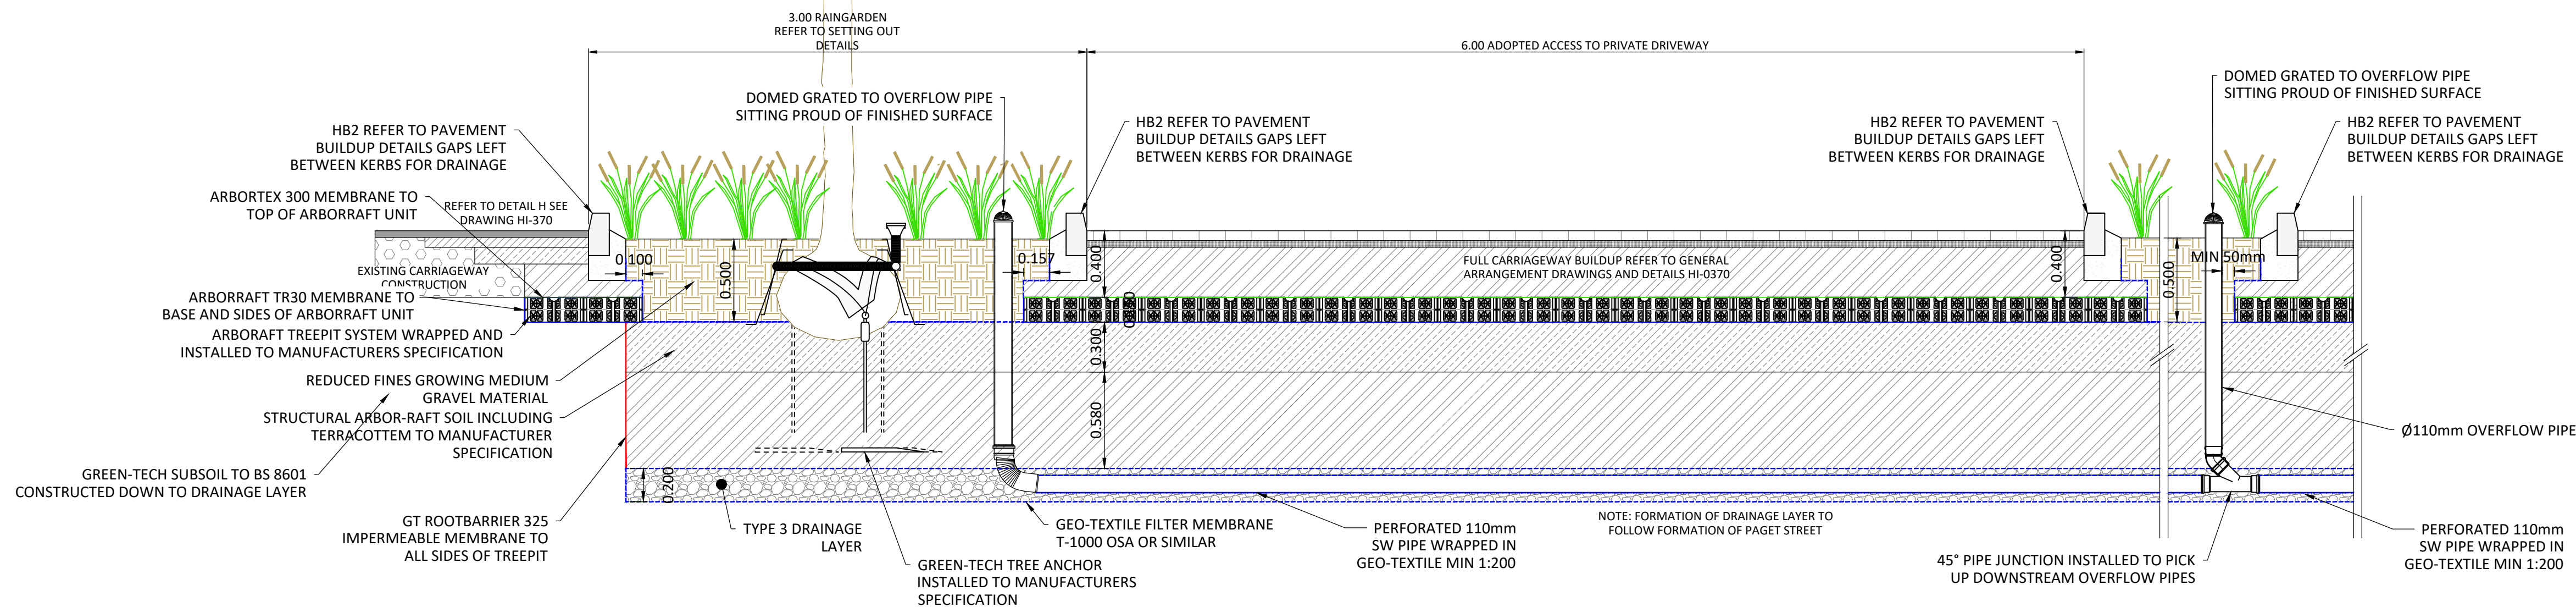
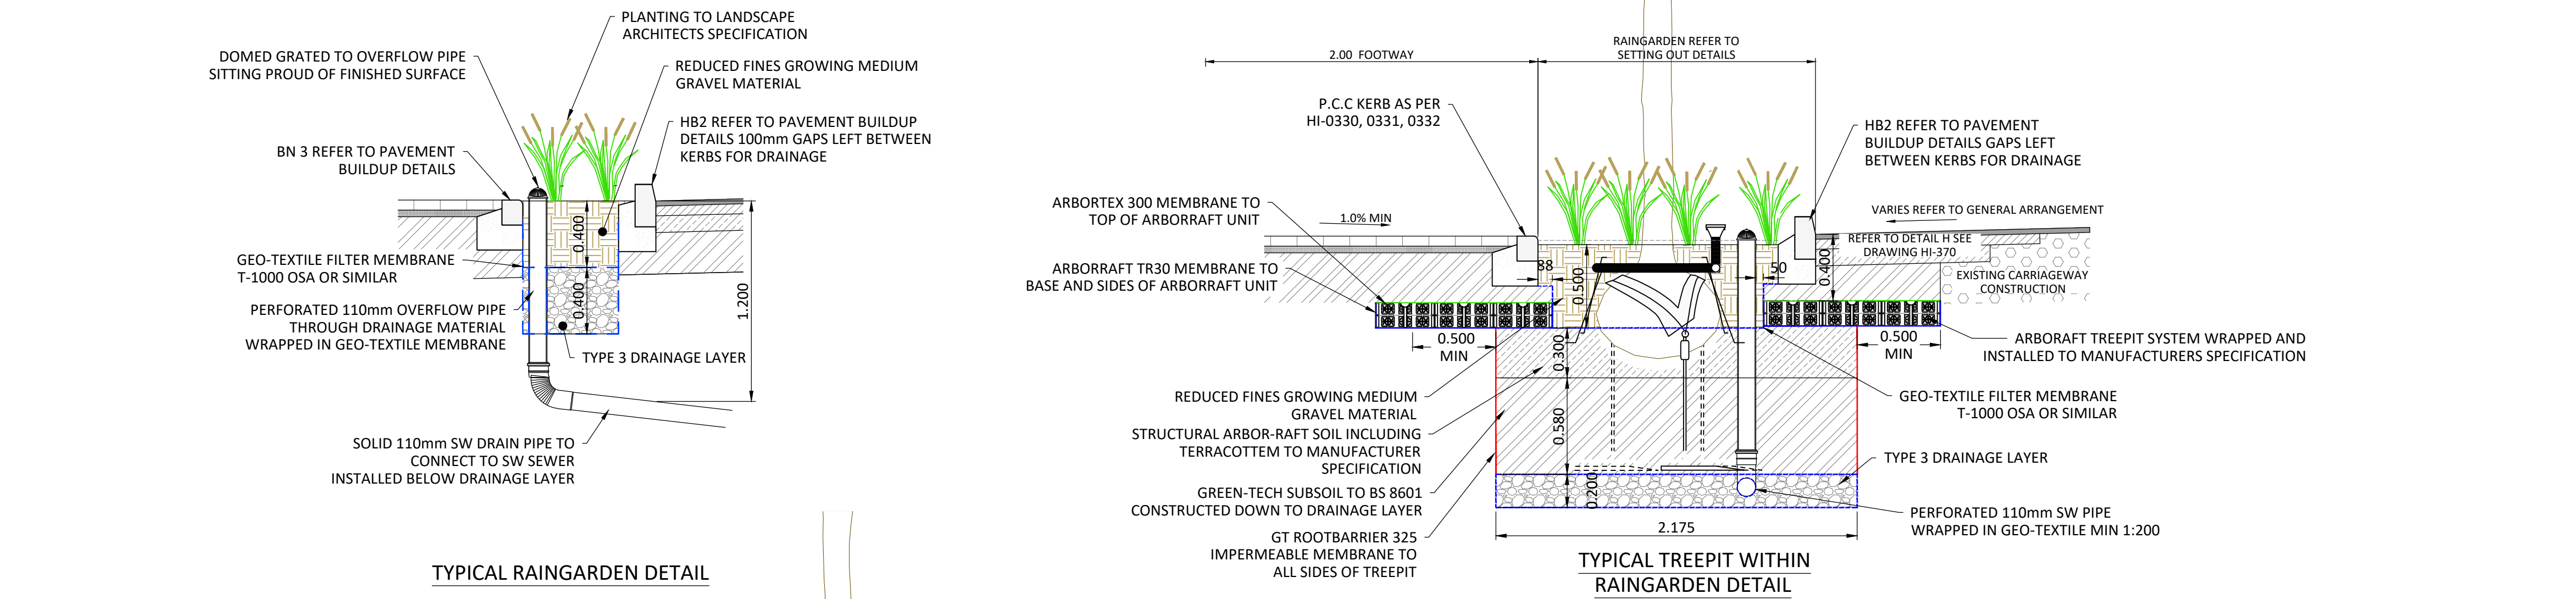


PERFORATED PIPE DETAIL

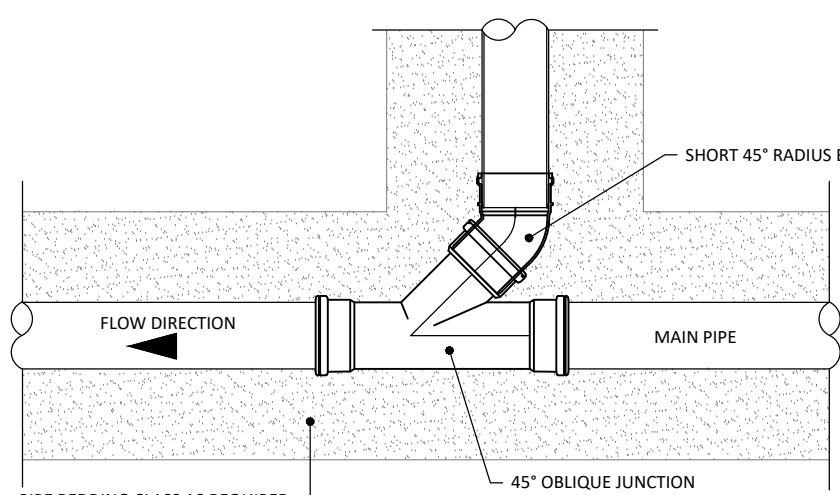

TYPICAL 45° PIPE JUNCTION CONNECTION DETAIL

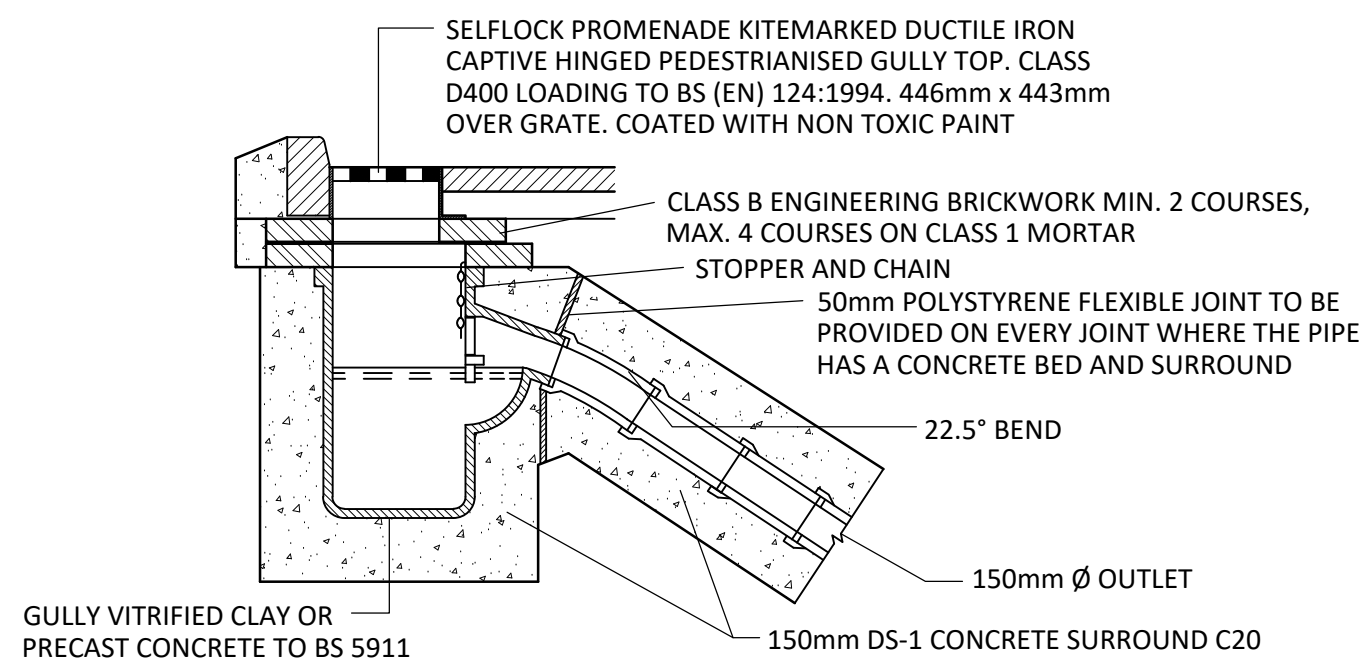

TYPICAL ROAD GULLY DETAIL

Standard Notes

1. This drawing is to be read in conjunction with all relevant Architect's and Engineer's drawings and the specification.
2. This drawing should not be scaled.
3. All dimensions are to be verified by the contractor on site.
4. All discrepancies should be reported to the C.A. prior to the commencement of the works.

© CIVIC ENGINEERS LIMITED

Notes and Keys

1. THIS DRAWING IS TO BE READ IN CONJUNCTION WITH ALL RELEVANT ARCHITECTS, M & E CONSULTANTS AND CIVIC ENGINEERS DRAWINGS. FOR SECTION LOCATION REFER TO CIVIC ENGINEERS HIGHWAY GENERAL ARRANGEMENT DRAWINGS HI-310 - 316.
2. FOR DRAINAGE LAYOUT REFER TO CIVIC ENGINEERS DRAWING HI-0380, 0381, 0382.

22.09.21	P02	ISSUED FOR INFORMATION	RSH	CFK
27.08.21	P01	ISSUED FOR INFORMATION	LGS	RSH
Date	Rev	Description	Drawn	Chkd



MANCHESTER LONDON LEEDS GLASGOW

www.civicengineers.com

Project
COLLYHURST HOUSING MANCHESTER

Title
PROPOSED HIGHWAYS S38 TYPICAL DRAINAGE DETAILS

Status	INFORMATION				
Project Number	Scale @ A1	Date Created	Drawn	Checked	Suitability
1226-01	1:25	AUG '21	LGS	RSH	--
Drawing Number	Revision				
1226-01-CIV-XX-VIL-DR-HI-0387	P02				