




VISUAL SCALE 1:100 @ A3

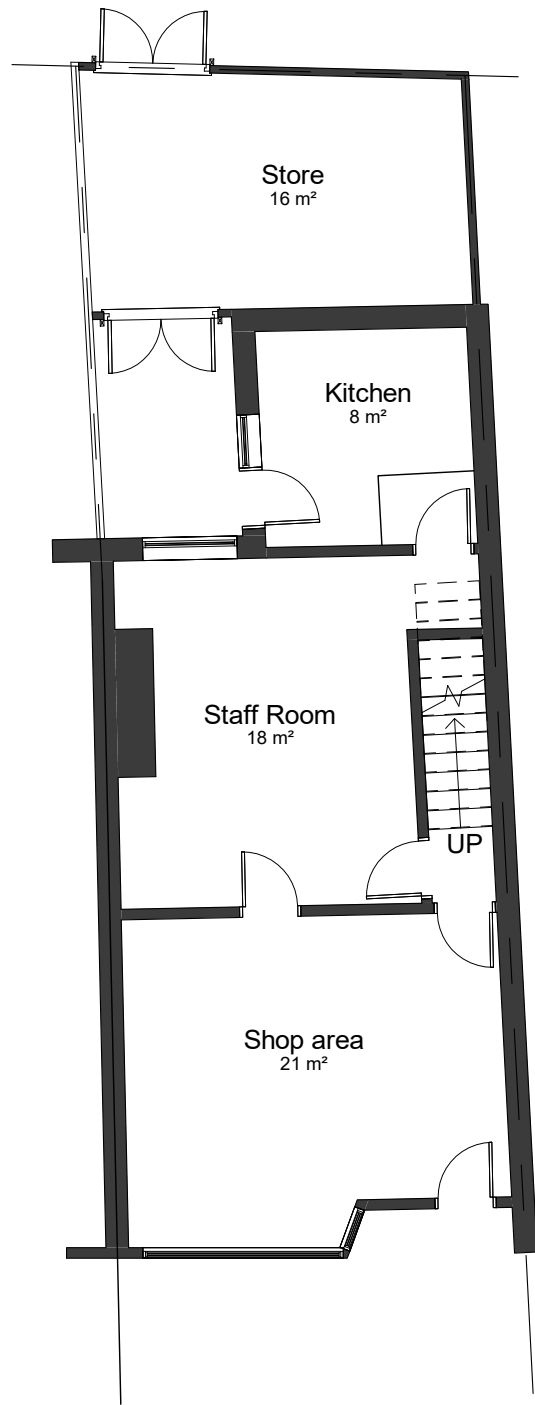

00-E-Ground Floor
1 : 100

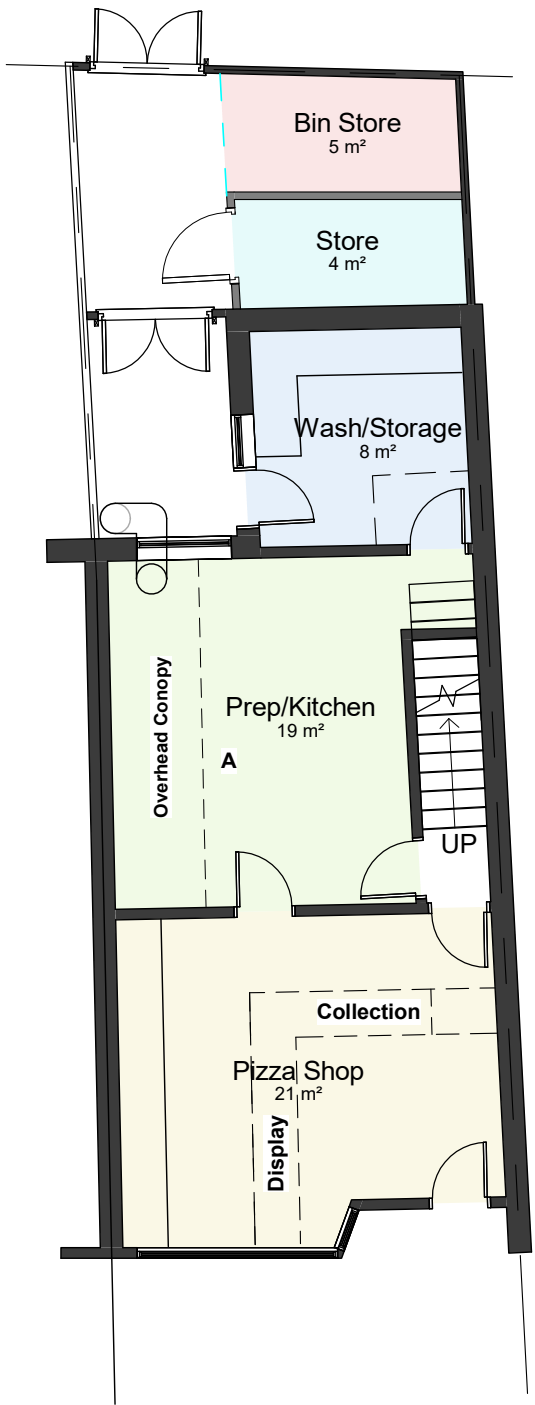

 00-P-Ground Floor
1 : 100



Incoming Air
(1) Wall grille
(2) 400mm Dia Plate Fan
(3) 400x400 square duct
(4) Air distribution using ceiling grilles 400x400

Extraction
(A) Cooking Area
(B) 4500mm Canopy with 8 baffle filters
(C) Transformer to/from ESP
(D) ESP 3000
(E) O.N.100
(F) Square to round transformer
(G) 500mm Dia Silencer 800mm long
(H) 500 Max Fan 2/16/4/5
(I) 500mm Dia Silencer II 800mm long
(J) 450mm Dia spiral round duct
(K) Anti-vibration bracket

COPYRIGHT © ALL RIGHTS RESERVED BY VIKAS ALYAS LTD. DO NOT SCALE FROM DRAWING. DRAWING INDICATES DESIGN INTENT ONLY. REPORT ANY DISCREPANCIES TO CLIENT / VA LTD. NOT TO BE USED FOR CONSTRUCTION UNLESS STATED SO. TO BE READ IN CONJUNCTION WITH OTHER DRAWINGS OR SPECIFICATION WHERE PROVIDED.

ARCHITEK

BUILDING DESIGN CONSULTANCY

0161 511 8479

vikas@architek.uk
916 Stockport Road, Levenshulme, Manchester, M19 3AB

No.	Description	Date
P1	Issue to Planning	05.12.2022

PROJECT		ADDRESS		CLIENT		
Change of Use Former Post Office to Pizza Takeaway (Sui Generis)		814 Hyde Rd, Gorton, Manchester M18 7JD		Hashim Haroon		
		SHEET		Date 24.11.2022	Project number M187	Scale (@ A3) As indicated
Manchester City Council	PURPOSE OF ISSUE Planning	Existing and Proposed Floor Plans		Drawn by VA	DRAWING NUMBER A103	REV P1
				Checked by VA		