


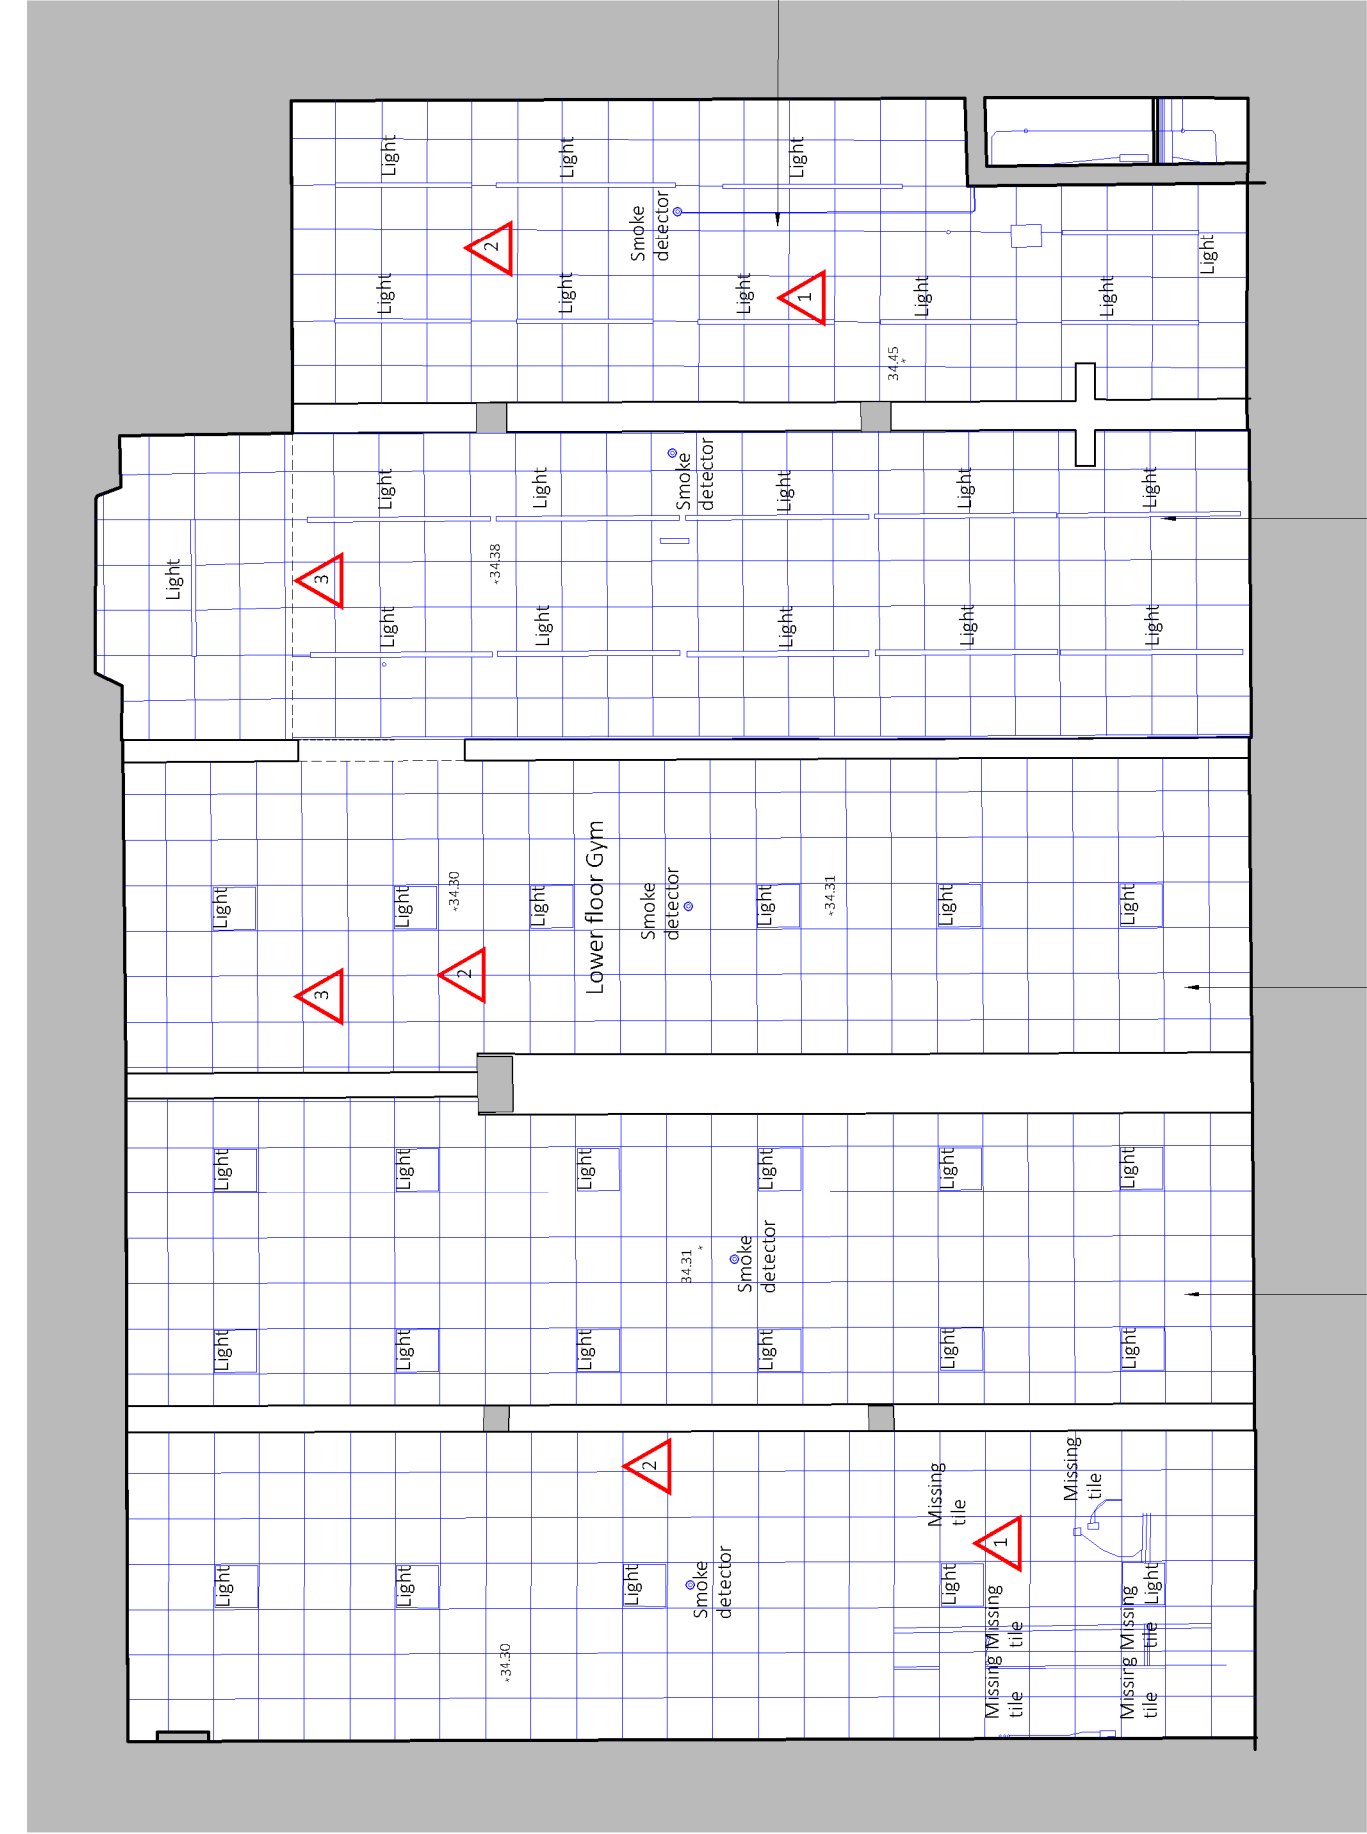

Note:
Do not scale from this drawing.
Dimensions are to be checked on site.
If in doubt please ask.

Before any works begin in the aread the Gym the contractor is to consult the asbestos register and ensure related materials have been removed under controlled conditions by a specialist. Contractor to plan to mitigate risks of contamination.

Key:

Proposed fabric to be installed.

CDM risks:



Risk - Asbestos - Asbestos containing materials have been confirmed across the whole ceiling of the Gym. This MUST be removed by an ACM specialist operative before works begin. Contractor to consult the asbestos register when planning works. Ensure all asbestos is work areas is removed prior to work on site.

Risk - Falling debris and unstable ceiling - risk of falling debris during removal and unstable ceiling fabric during installation. Contractor to ensure temporary work and loose fabric is secured and considering net supports if appropriate. Contractor ensure correct PPE is provided to those removing high level fabric.

Risk - Working at height - Contractor to ensure any tasks that can occur at ground level are arranged. Scaffolds are to be installed by specialist contractor. Principal contractor to ensure these are maintained and safe access is provided at all times.

P1 17/10/22 LU

Revised following client review.

Rev Date/Ints Details

© The moral rights of the author are hereby asserted.
This drawing is the property of Buttress Ltd and must not be reproduced without permission.
Buttress Ltd is registered in England and Wales 5588573

Lower Ground Gym - Reflected Ceiling Plan

Allow to replace the existing heating pipework contained within the gym ceiling void. New pipework to use existing holes. Contractor to limit new openings and ensure all historic fabric is protected during this process.

Install 2 fixed layers of 12.5mm fireline board to manufacturer's specification (British Gypsum or equivalent) with all joints staggered and a plaster skim finish to the ceiling of the gym.

Plasterboard to be fixed to existing floor joists with min 38mm drywall screws. Allow for 50x50 soft wood noggin to support any unsupported plasterboard.

Where the suspended ceiling grid has been removed allow to install new suspended ceiling. Ceiling tiles shall be Dune Max 600 x 600 x 19mm Suspension

System: Armstrong 24mm exposed grid system, all cross tees are to be stitched. Colour to be white. All details to manufacturer's requirements and specification.

Void depth to match existing.

Allow for securely fixing new lighting to new suspended ceiling within gym. No fixtures or fittings to be supported directly onto the back of tiles. Supply and install timber battens or other suitable method to be used to ensure that the load is transferred onto the grid. Overall loads must not exceed the manufacturer's guidelines.

All electrical accessories or fixed items of equipment such as extract fans are to be disconnected from ceilings being replaced. The contractor shall ensure that all existing extract fans and other electrical units are replaced in their existing positions upon completion of the new suspended ceiling installation and are fully working on completion of the works.

Contractor to allow for any cabling to be run within the fabric of the building and above ceiling voids.

The Contractor is to allow for making good any surfaces damaged during the electrical works.

The Contractor is to ensure that all electrical penetrations, voids, holes, cavities formed within the property for service routes as a result of the electrical works, identified within the specification, are sufficiently fire stopped.

Buttress

41 Bengel St
Manchester
M4 6AP

T 0161 236 3303
E contact@buttress.net
W www.buttress.net

Project Title	CSM - Whiteley Hall						
Client	Chetham's School of Music						
Location	Manchester						
Drawing Title	Gym - Reflected Ceiling Plan Proposed						
Date	20/09/22		Scale	1:100			
Checked	LU		Orig Paper Size	A3			
Status PLANNING/LBC							
Project:	Origin:	Zone:	Level:	Type:	Disc:	Number:	Rev:
9357-BA - ZZ - ZZ - DR - A - (04)004 - P1							