


Pld Stamp: Z:\8443 Broomcroft Hall - replacement of conservatory\05 Drawings & Specifications\2 Existing\GA071AA-F000.dwg

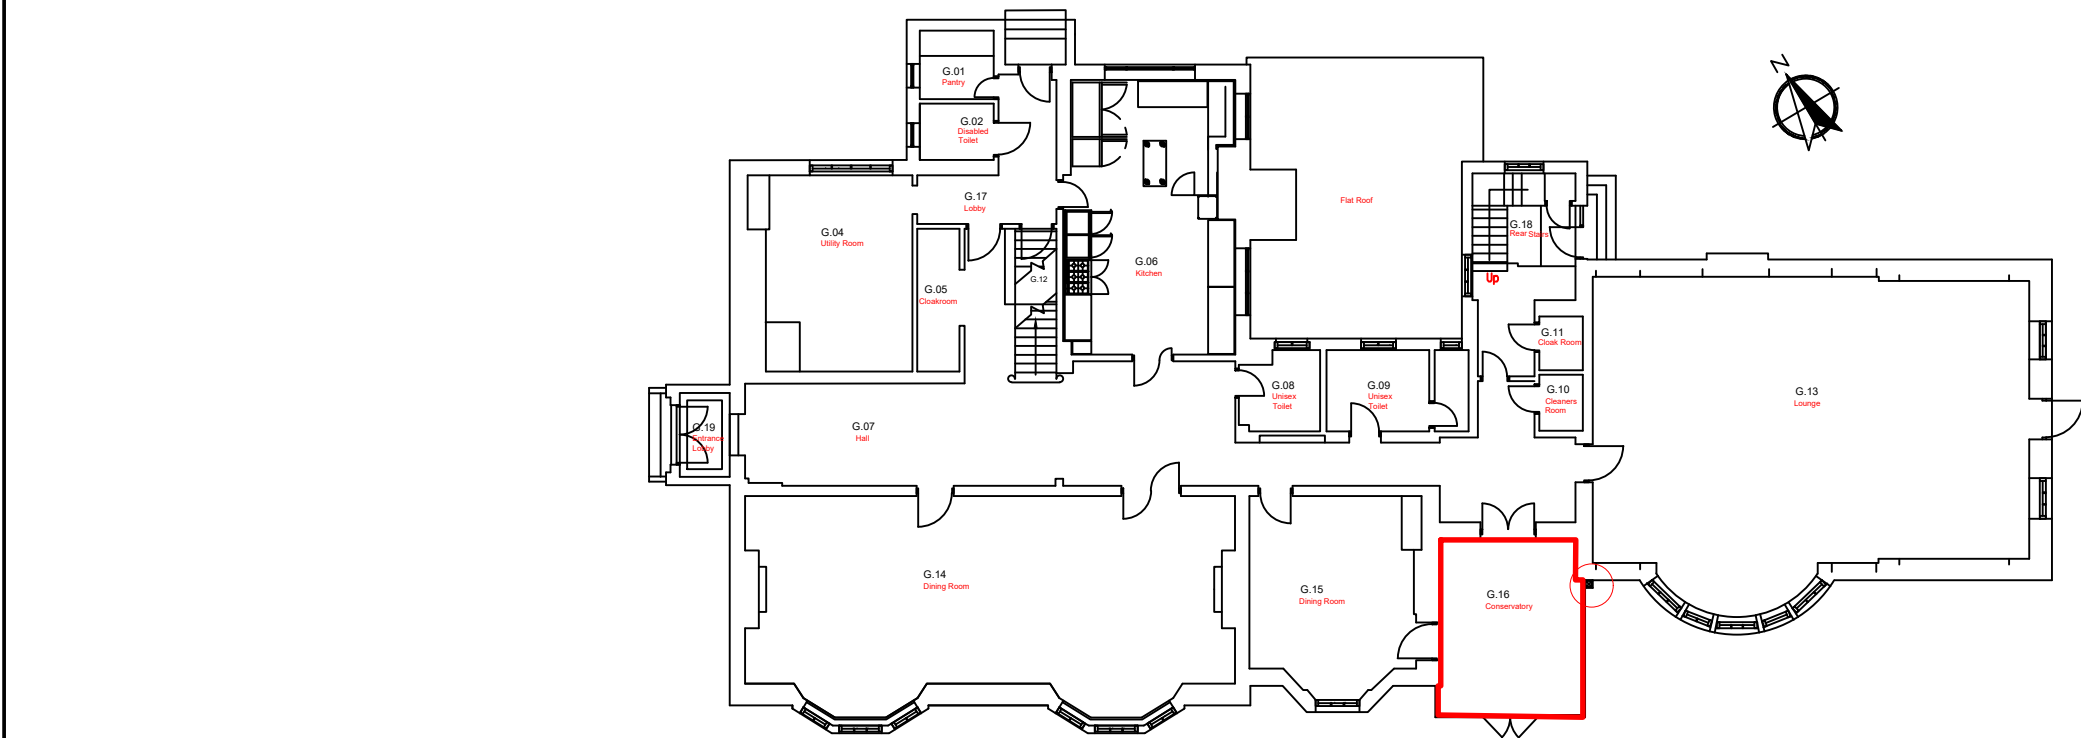

LOCATION OF EXISTING CONSERVATORY DRAINAGE

Showing location of rainwater outlet and downpipe for existing conservatory. New conservatory to use existing downpipe for drainage.

MANCHESTER

1824

The University of Manchester

Directorate of Estates and Facilities
Beyer Building
The University of Manchester
Oxford Road, Manchester
M13 9PL

- NOTES
- DO NOT SCALE FROM THIS DRAWING.
 - ALL MEASUREMENTS ARE IN MILLIMETRES UNLESS STATED OTHERWISE.
 - THIS DRAWING IS TO BE READ IN CONJUNCTION WITH THE SPECIFICATION AND ALL RELEVANT ARCHITECTURAL, ELECTRICAL, MECHANICAL AND STRUCTURAL DRAWINGS.
 - © UNIVERSITY OF MANCHESTER. THIS DRAWING MUST NOT BE REPRODUCED WITHOUT PERMISSION.
 - DIRECTORATE OF ESTATES AND FACILITIES TO BE NOTIFIED OF ANY DISCREPANCIES.

Rev Description				Rev By Chk'd Auth			

Drawing Status				PLANNING			
Project				PN 8443 BROOMCROFT HALL CONSERVATORY REPLACEMENT			
Site Name				DIDSBURY			
Sub Site Name							

Building Name				Building No.			
BROOMCROFT HALL				071AA			
Drawing Title							
BROOMCROFT HALL GROUND FLOOR PLAN SHOWING EXISTING CONSERVATORY DRAINAGE							
PM		Drawn		Checked		Authorised	
JW		JW		-		-	
Scale @ A3		Date		Date		Date	
1:200		16/11/22		-		-	
Drawing No.				Revision			
071AA-8443-A102				-			