



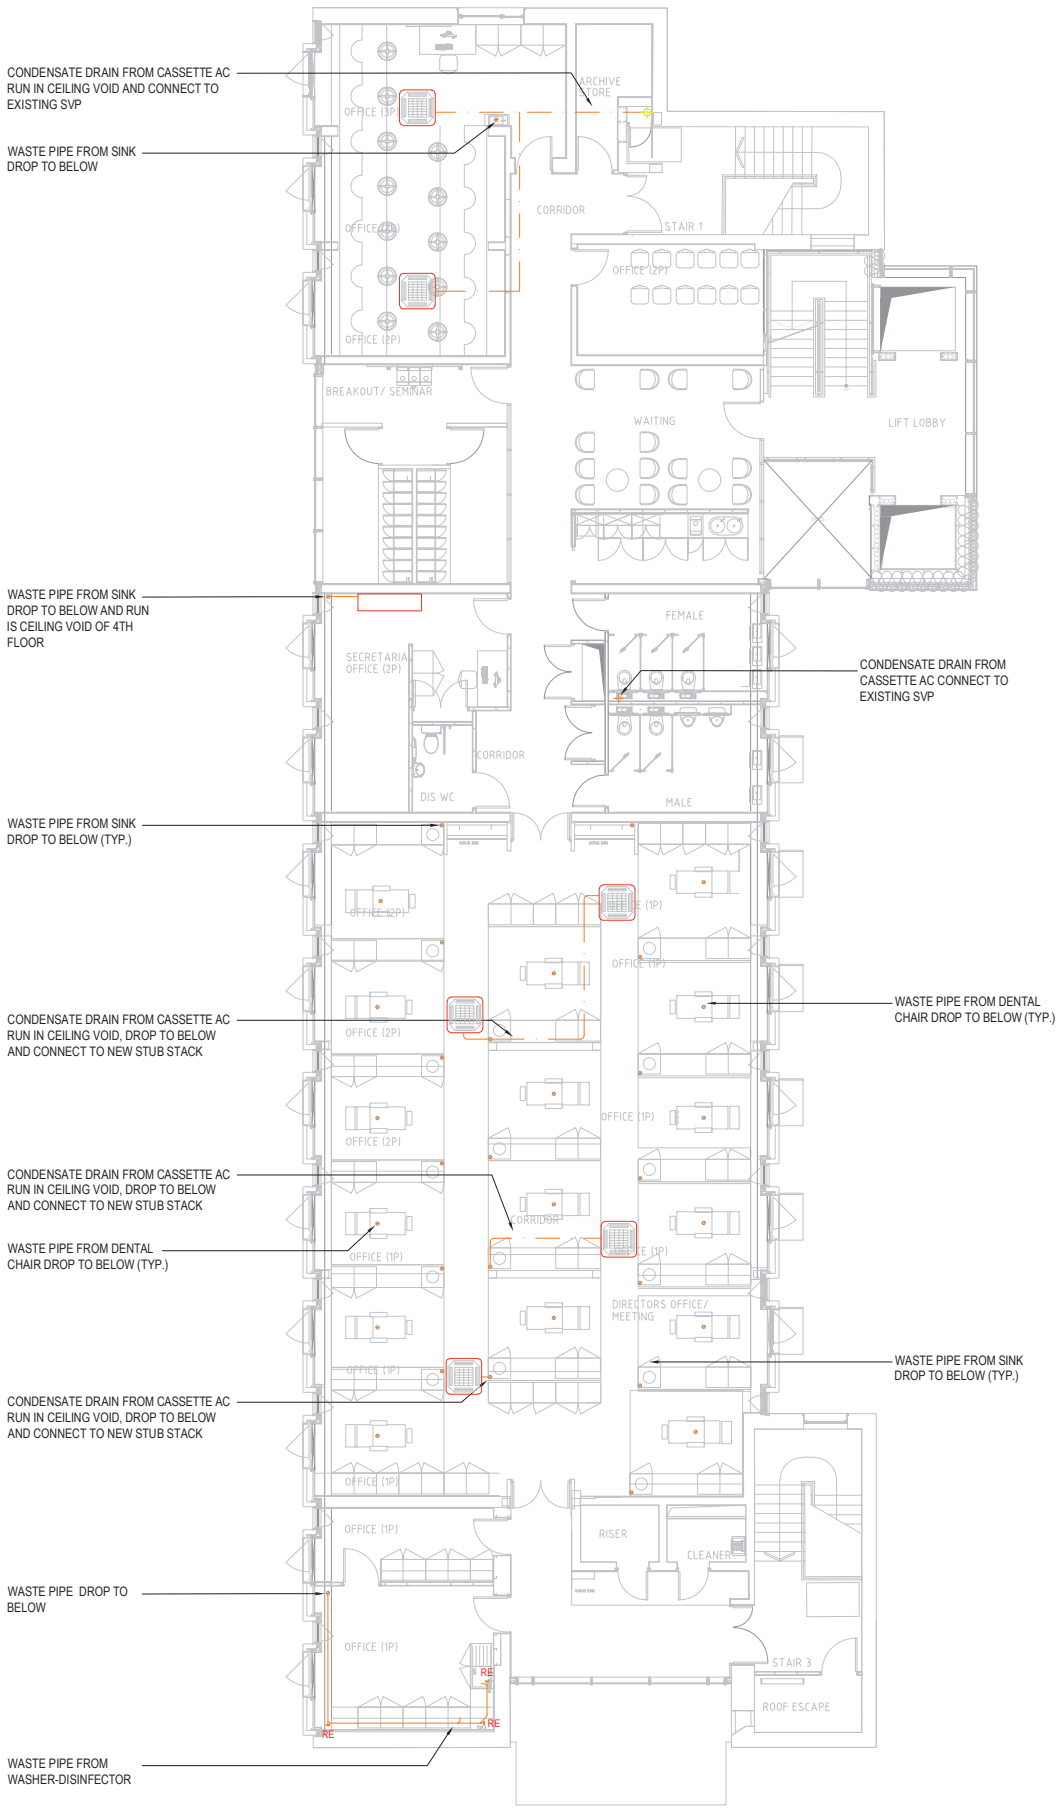

FIFTH FLOOR ABOVE GROUD DRAINAGE LAYOUT

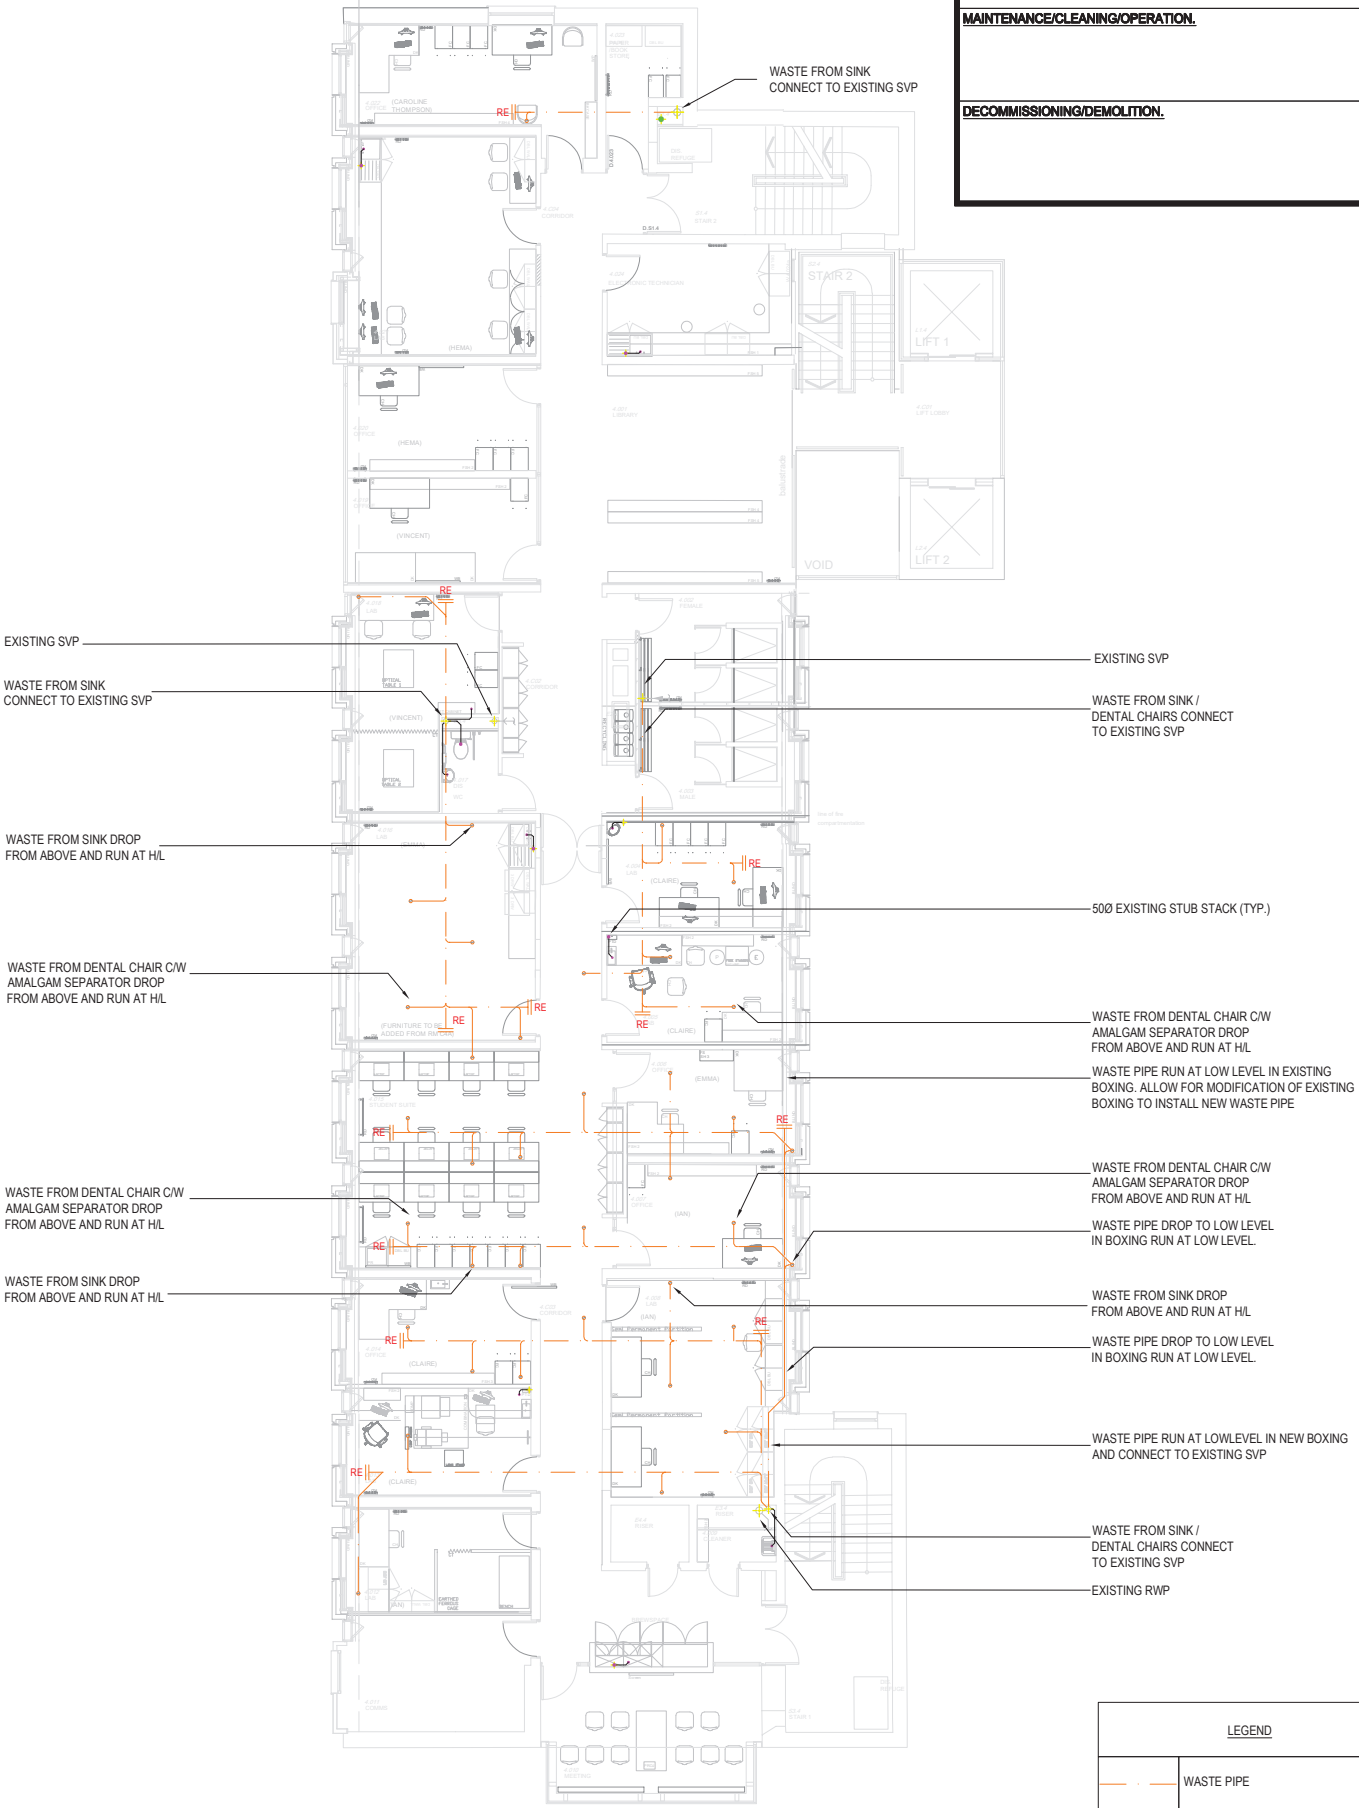

FOURTH FLOOR ABOVE GROUD DRAINAGE LAYOUT

HEALTH AND SAFETY INFORMATION

IN ADDITION TO THE HAZARDS/RISKS NORMALLY ASSOCIATED WITH THE TYPES OF WORK DETAILED ON THIS DRAWING, NOTE THE FOLLOWING

CONSTRUCTION.

MAINTENANCE/CLEANING/OPERATION.

DECOMMISSIONING/DEMOLITION.

- NOTES
1.

PLEASE DO NOT SCALE FROM THIS DRAWING.
2.

THIS DRAWINGS FORMS PART OF THE DETAILED DESIGN AND SHOULD BE READ IN CONJUNCTION WITH THE COMPLETE ARCHITECTURAL AND ENGINEERING TENDER PACKAGE.
3.

PLEASE PRINT/READ THIS DRAWING IN COLOUR.
4.

ALL DIMENSIONS ARE TO BE CONFIRMED ON SITE PRIOR TO ORDERING OR PLACING MATERIALS OR EQUIPMENT.
5.

THIS DRAWING IS NOT INTENDED FOR CONSTRUCTION PURPOSES. IN LINE WITH CONTRACT REQUIREMENTS THE CONTRACTOR SHALL PRODUCE CONSTRUCTION DRAWINGS TO CAPTURE ALL INSTALLATION REQUIREMENTS AND ASSOCIATED CO-ORDINATION.
6.

CLEANING EYE SHALL BE PROVIDED AT ALL CHANGED IN DIRECTION OF SOIL & WASTE PIPEWORK.
7.

INTUMESCENT FIRE COLLARS TO BE FITTED TO 500 MM OR GREATER PIPEWORK PASSING THROUGH A FIRE RATED PARTITION.
8.

ALL PIPES SHALL BE FIXED IN STRAIGHT RUNSAND ALL HORIZONTAL RUNS ARE TO BE LAID ONTO GRADIENTS IN EXCESS OF THE MINIMUM STATED IN BS COPE OF PRACTICE BS EN 12056: 2000 GRADIENT OF SPV 1:80 UNLESS OTHERWISE SPECIFIED.
9.

SANITARY INSTALLATION TO MEET THE REQUIREMENT OF BS EN 12056 PART 2 AND APPROVED DOCUMENT H.

PO1	-	STAGE 3 ISSUE	LK	FC	03.10.2022
Rev	Dcc	Description	Dwn	Chld	Date

STAGE 3

TROUP
BYWATERS
+ ANDERS

Bringing Buildings to Life

3rd Floor, Oxford Place
61 Oxford Street
Manchester M1 6EQ
t: +44 (0)161 974 1710
e: manchester@tbanda.com
w: www.tbanda.com

Project
UNIVERSITY OF MANCHESTER, CARYS
BANNISTER DENTAL SCHOOL

Title
FOURTH AND FIFTH FLOOR
ABOVE GROUND DRAINAGE LAYOUT

Client
UNIVERSITY OF MANCHESTER

Architect
WILSON MASON

Project No. EA0018	Drawn By LK	Date 26/08/2022	Checked FC	Scale 1:100
-----------------------	----------------	--------------------	---------------	----------------

Acad Model EA0018-XM-52-05-001	Revision PO1
Drawing No. EA0018-M-52-05-001	