



SITE LOCATION
(Scale 1:50000)

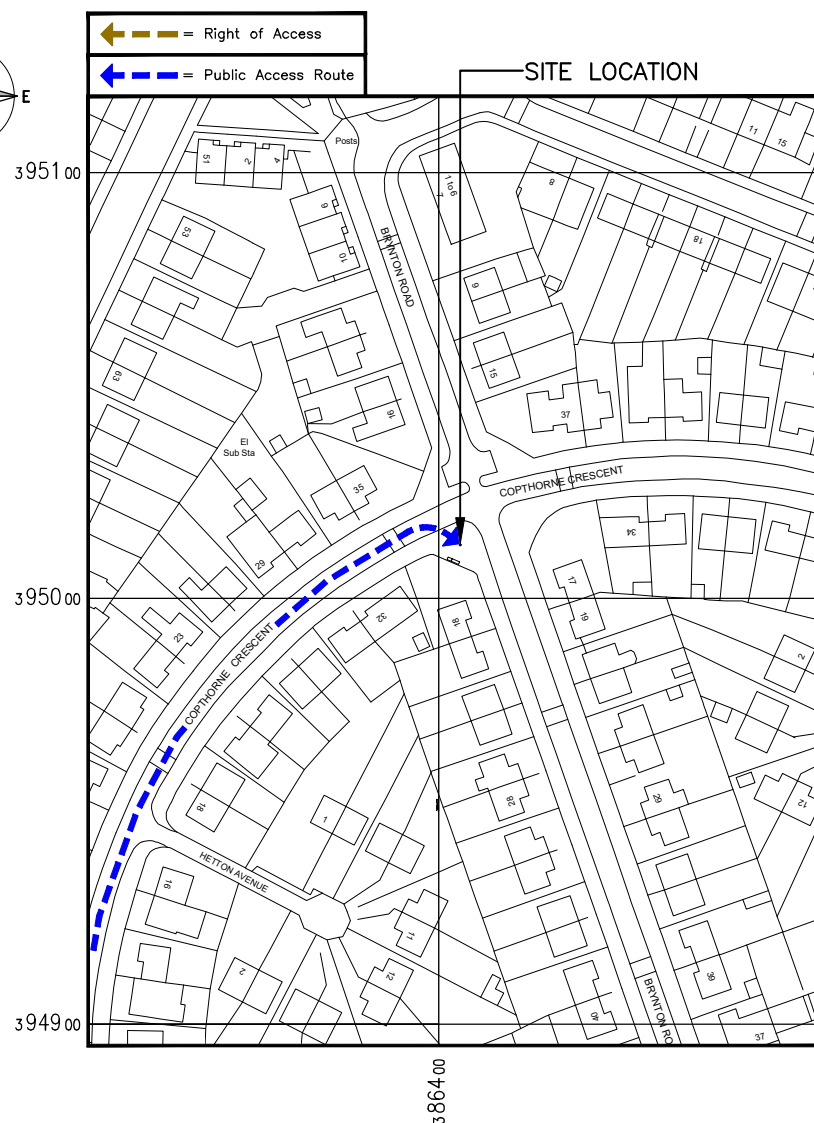

 
SITE PHOTOGRAPH

The drawings comply with TEF Standard ICNIRP guidelines.
Designed in accordance with CORNERSTONE document: SDN0013 v2.0

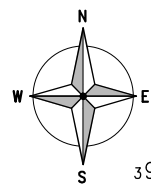


DETAILED SITE LOCATION
(Scale 1:1250)

Based upon Ordnance Survey map extract
with the permission of the Controller of
Her Majesty's Stationery Office.
Crown copyright.
Licence No. 100060010



Drawn: CS	Date: 06.06.22	Checked: DW	Date: 06.06.22	A
--------------	-------------------	----------------	-------------------	---

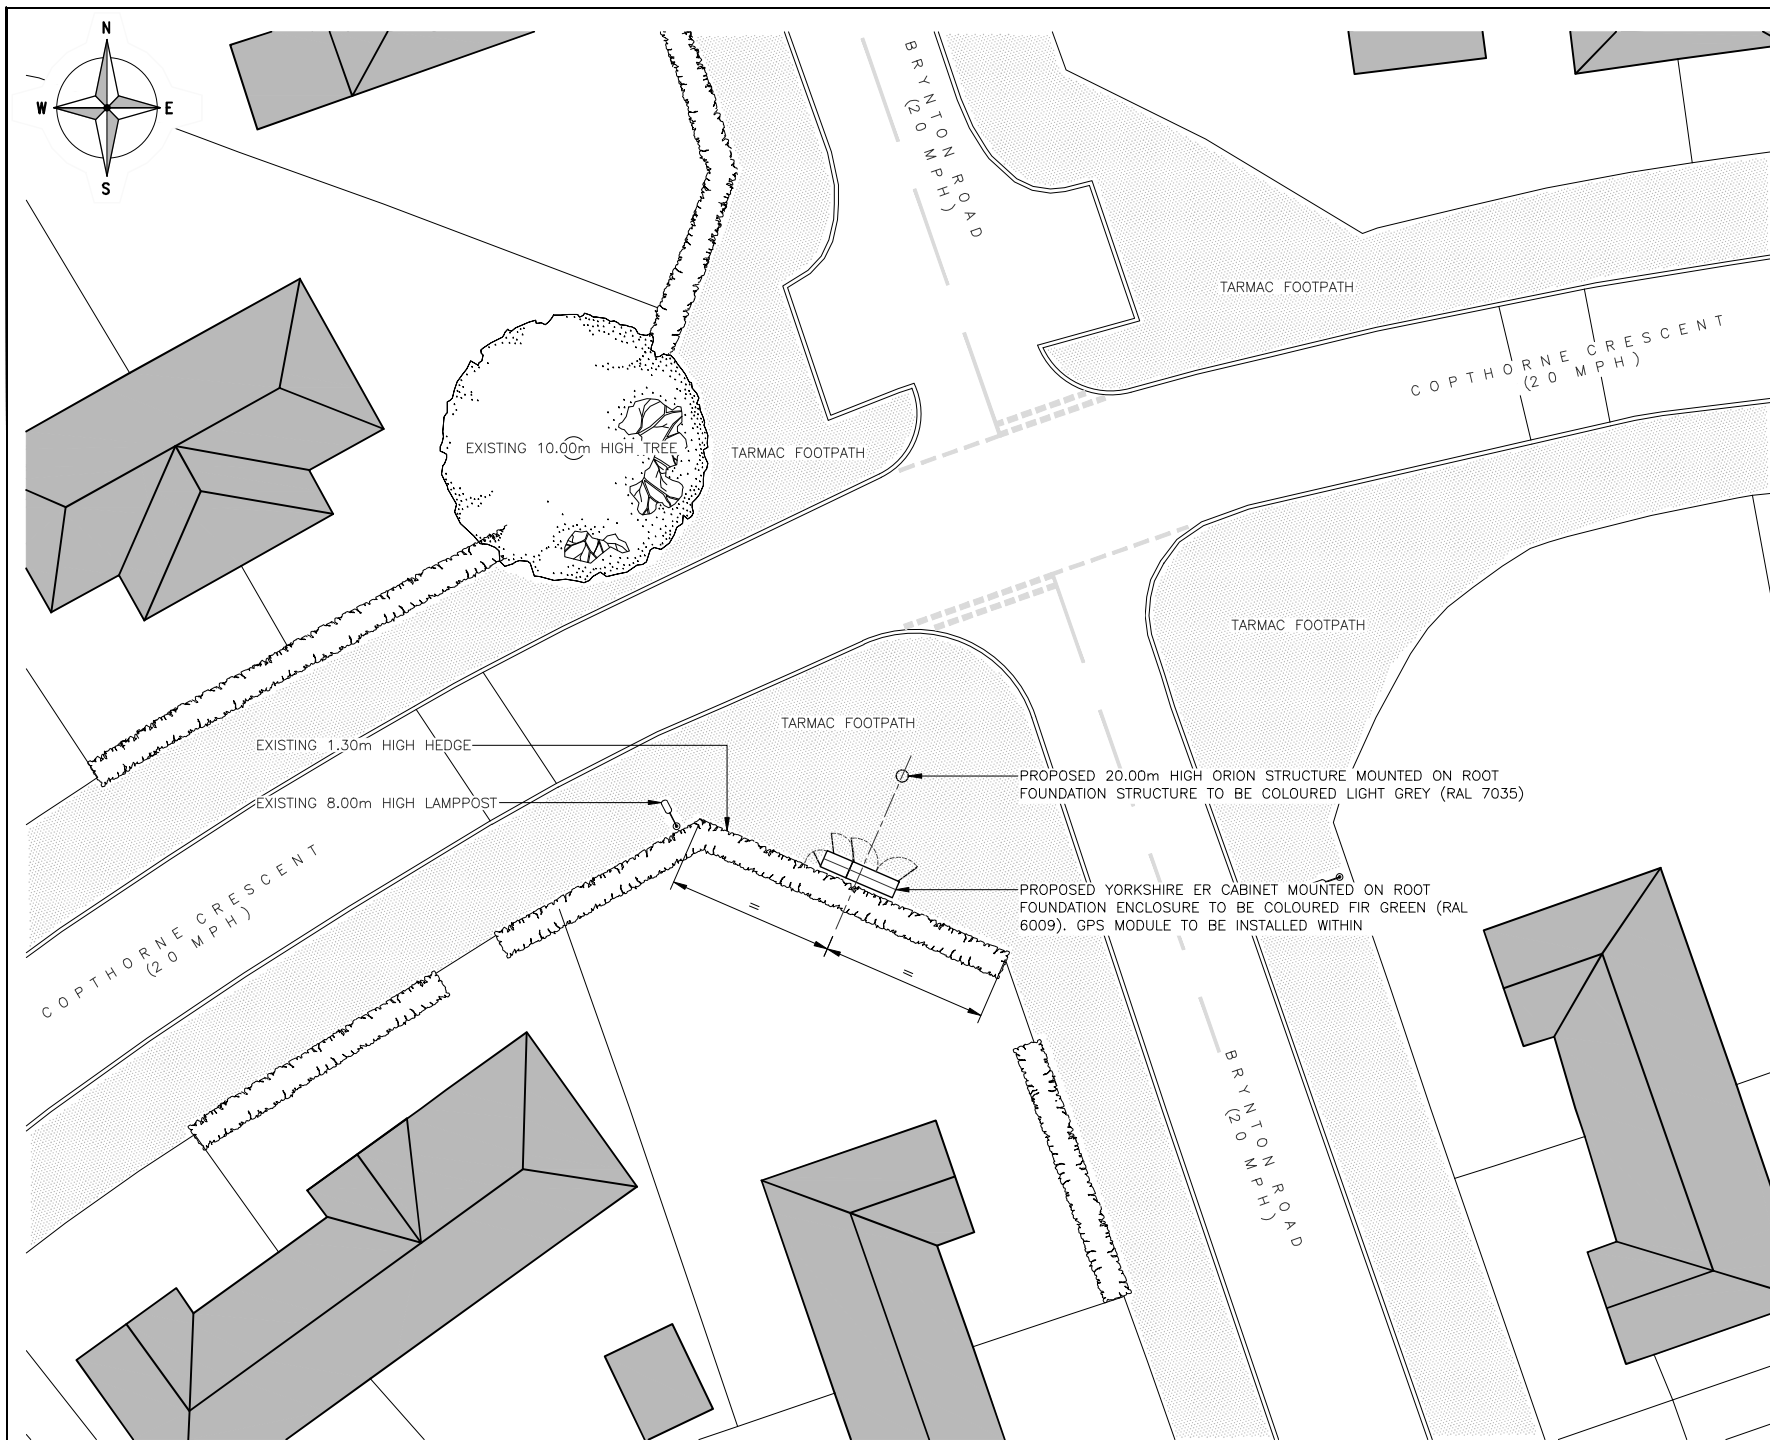

The drawings comply with TEF Standard ICNIRP guidelines.
Designed in accordance with CORNERSTONE document: SDN0013 v2.0

PROPOSED SITE PLAN
(1:200)

ALL DIMENSIONS ARE IN mm UNLESS NOTED OTHERWISE

N.G.R | E: 386404 N: 395019

NOTES:

REV	MODIFICATION	BY	CH	DATE
A	Issued for Approval	CS	DW	06.06.22

CLARKE
telecom
Unit E, Madison Place, Northampton Road,
Manchester, M40 5AG
Tel: 0161 785 4500
Fax: 0161 785 4501
Web: www.clarke-telecom.com

O₂
BEACON 3

Cell Name	Opt.
COPTHORNE CRESCENT SW	B

Cell ID No		
CORNERSTONE	TEF	VF
306156_00	097539	N/A

Site Address / Contact Details
CORNER OF COPTHORNE CRESCENT/BRYNTON RD LEVENSHULME MANCHESTER GREATER MANCHESTER M13 0QY

Drawing Title:	PROPOSED SITE PLAN
----------------	--------------------

Purpose of issue:	PLANNING	Dwg Rev:
-------------------	----------	----------

Drawing Number:	201	A
-----------------	-----	---

Surveyed By:	DW	Original Sheet Size:	A3	Pack Issue:
--------------	----	----------------------	----	-------------

Drawn:	CS	Date:	06.06.22	Checked:	DW	Date:	06.06.22	A
--------	----	-------	----------	----------	----	-------	----------	---

