


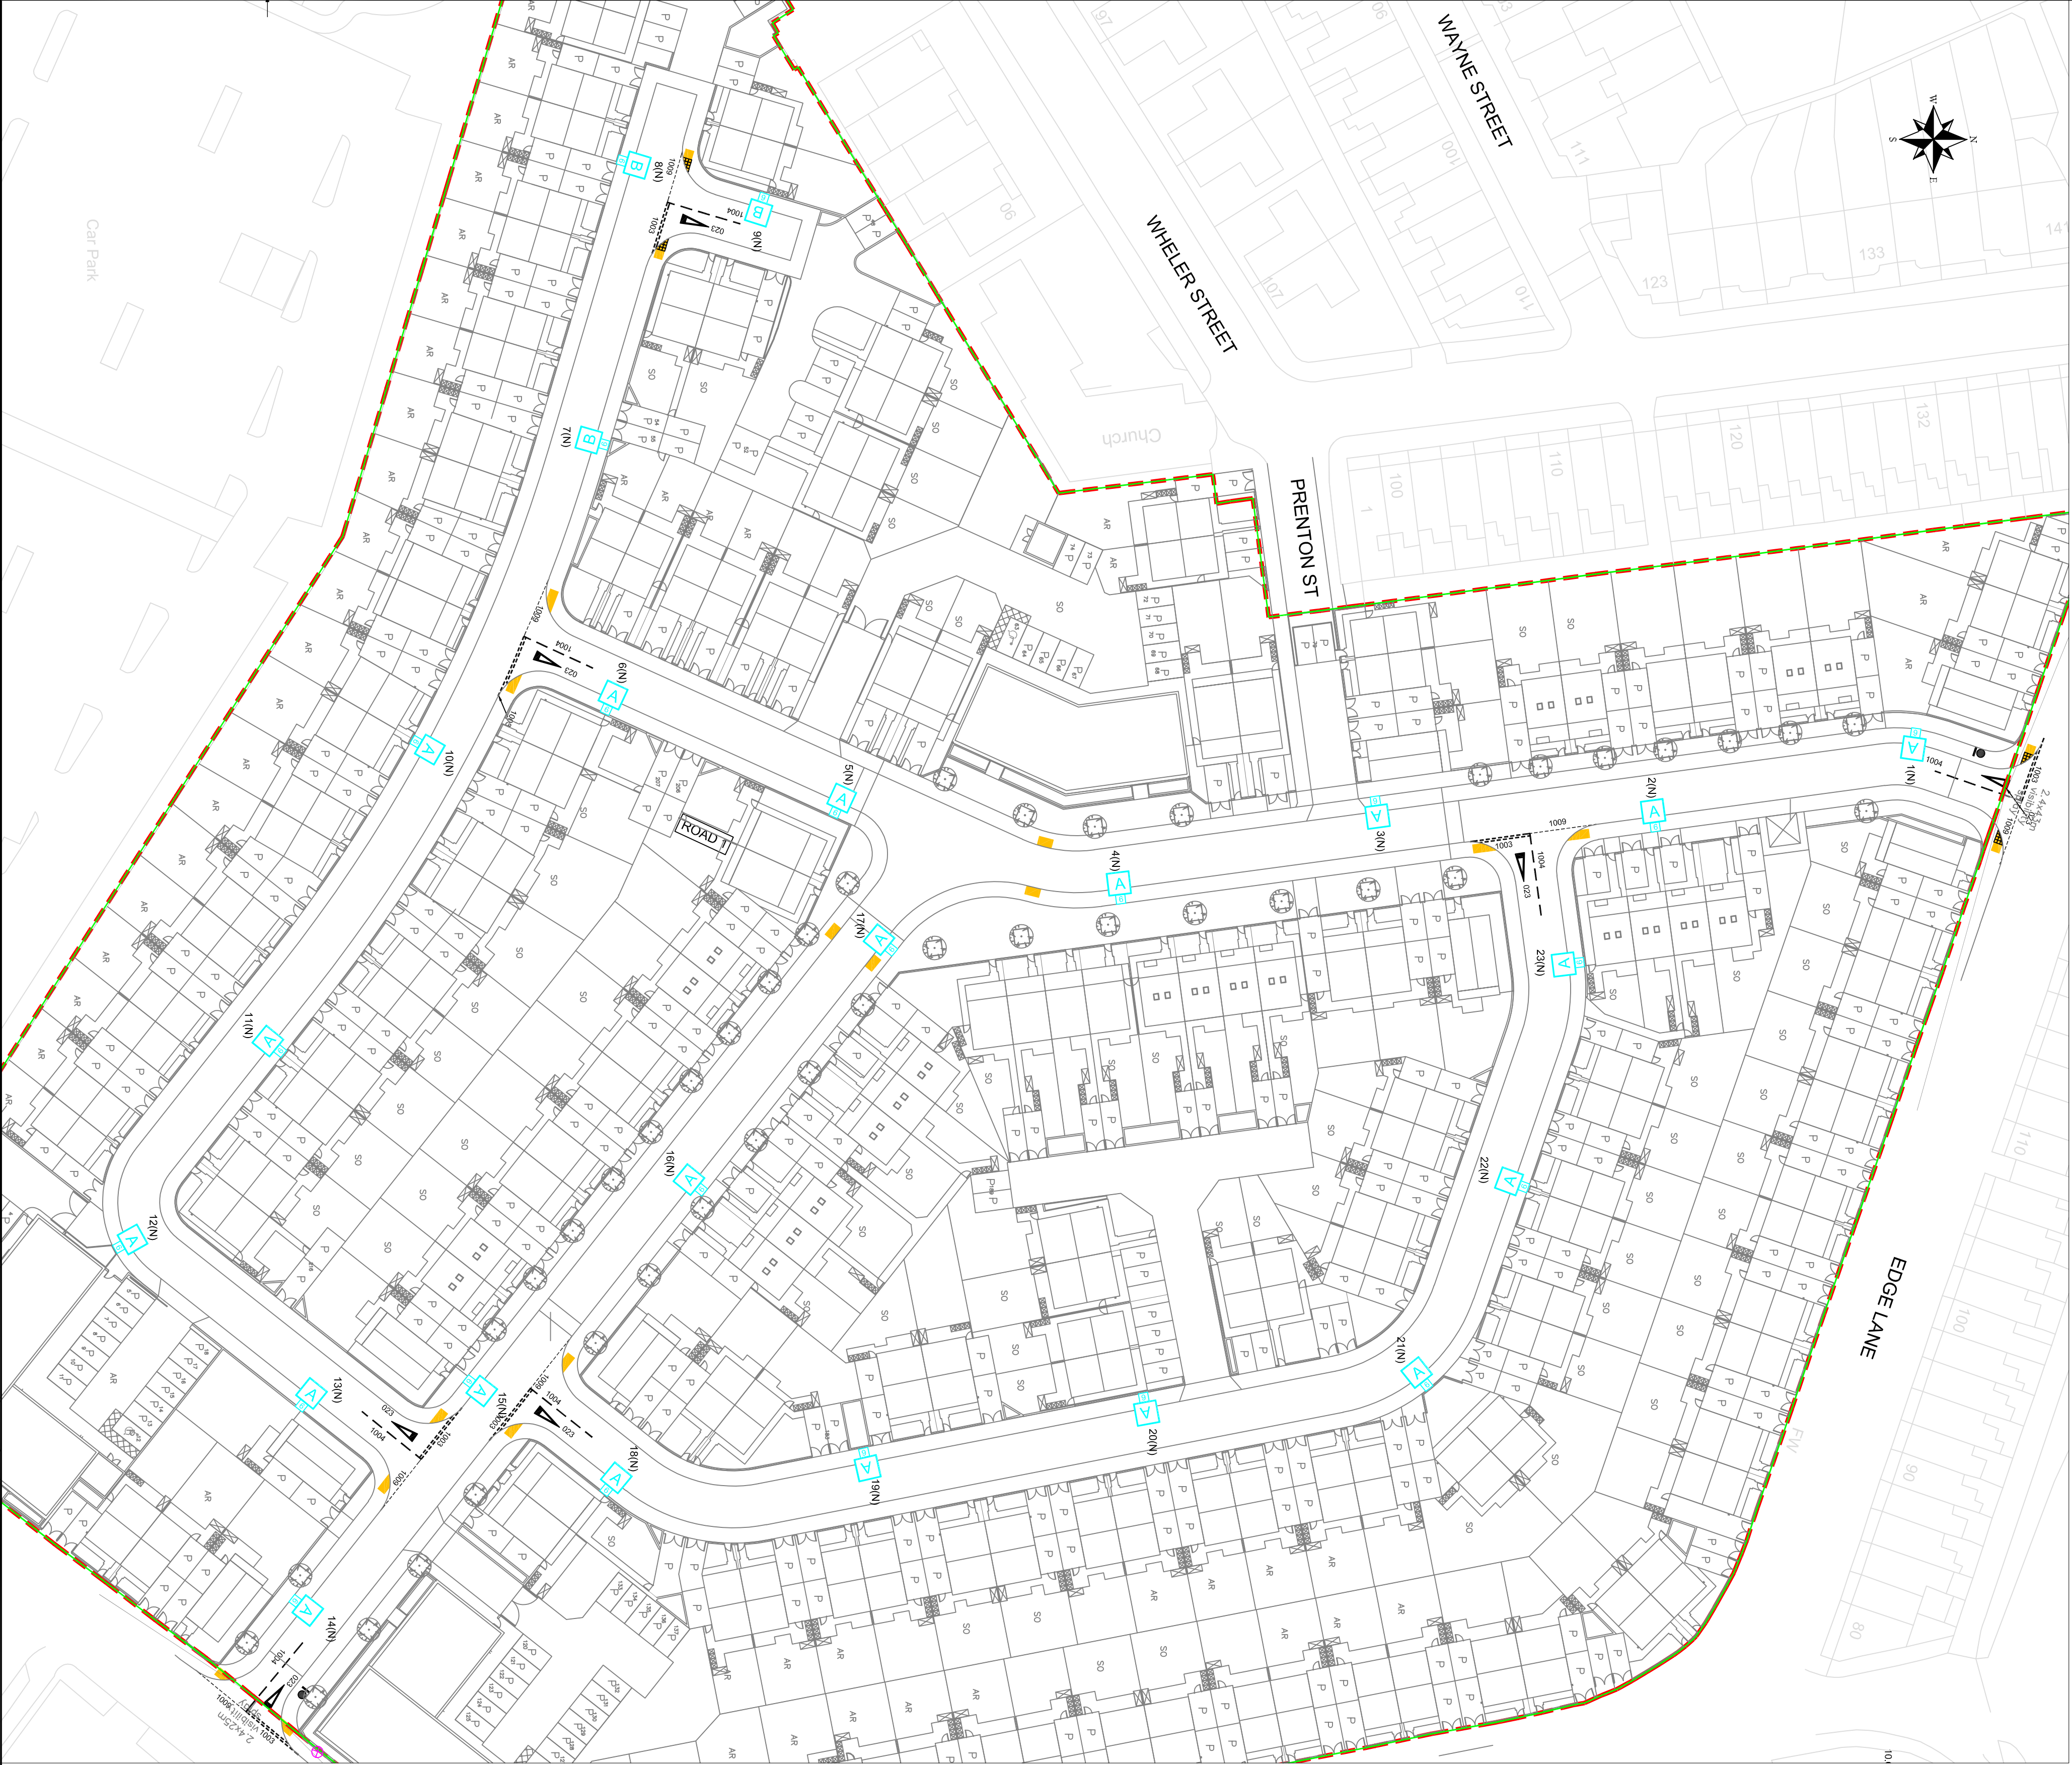

Lanterns Schedule			
Lantern Reference		A	B
Manufacturer		Signify (Philips)	Signify (Philips)
Range/Family		Micro Luma Gen 2 (MCC312.1P)	Micro Luma Gen 2 (MCC308.1P)
LED Output (Total Lamp Flux)		6.2 Klum	3 Klum
CCT		4000	4000
Optic/Distribution Setting		DW50	DW50
Luminous intensity Class		G3	G3
Lantern Spigot Inclination		0°	0°
Control Gear Type		Electronic DALI Driver	Electronic DALI Driver
Control		Philips Citytouch OLC	Philips Citytouch OLC
Quantity		20	3

KEY

- * LANTERN REFERENCE: REFER TO LANTERN SCHEDULE
- HEIGHT OF PROPOSED GALVANISED STEEL POST TOP COLUMN
- Existing column(for reference purposes only)

Example of Numbering details:
Supply details: The following denotes supply type and connection details.
T = DNO Transfer
D = DNO Disconnection
C = Lantern conversion only to existing lighting column
PR = Private service
PD = Private disconnection

NOTES

1. Lantern Dimming Profiles to be applied;
- Column 1: 80%
 - Column 2: 80%
 - Column 3: 80%
 - Column 4: 80%
 - Column 5: 80%
 - Column 6: 80%
 - Column 7: 100%
 - Column 8: 100%
 - Column 9: 100%
 - Column 10: 85%
 - Column 11: 85%
 - Column 12: 85%
 - Column 13: 85%
 - Column 14: 85%
 - Column 15: 85%
 - Column 16: 85%
 - Column 17: 85%
 - Column 18: 80%
 - Column 19: 80%
 - Column 20: 80%
 - Column 21: 80%
 - Column 22: 80%
 - Column 23: 80%

DESIGN HAZARDS

(The following information has been collected from Preconstruction Information and Amey Process CDM Hazard Management Process)

THE FOLLOWING HAZARDS SHOULD BE PRESUMED TO BE SCHEME WIDE

1.14d

1.14d

Client

LOVELL
PARTNERSHIPS

Project Name

EDGE LANE
SECTION 38
MANCHESTER

Drawing Title

Street Lighting
PROPOSED ROAD
LIGHTING LAYOUT

Original Dwg Size : A3 Scale : 1:500

Dimensions : m Title No : -

Drawing Status

SUITABLE FOR CONSTRUCTION A1

Drawing No

AC-MSL-5756-1301 C01

Revision

Copyright © Amey

amey
www.amey.co.uk

Designed: DJW Date: MAY 2021

Drawn: DJW Date: MAY 2021

Checked: CR Date: MAY 2021

Approved: CR Date: MAY 2021