


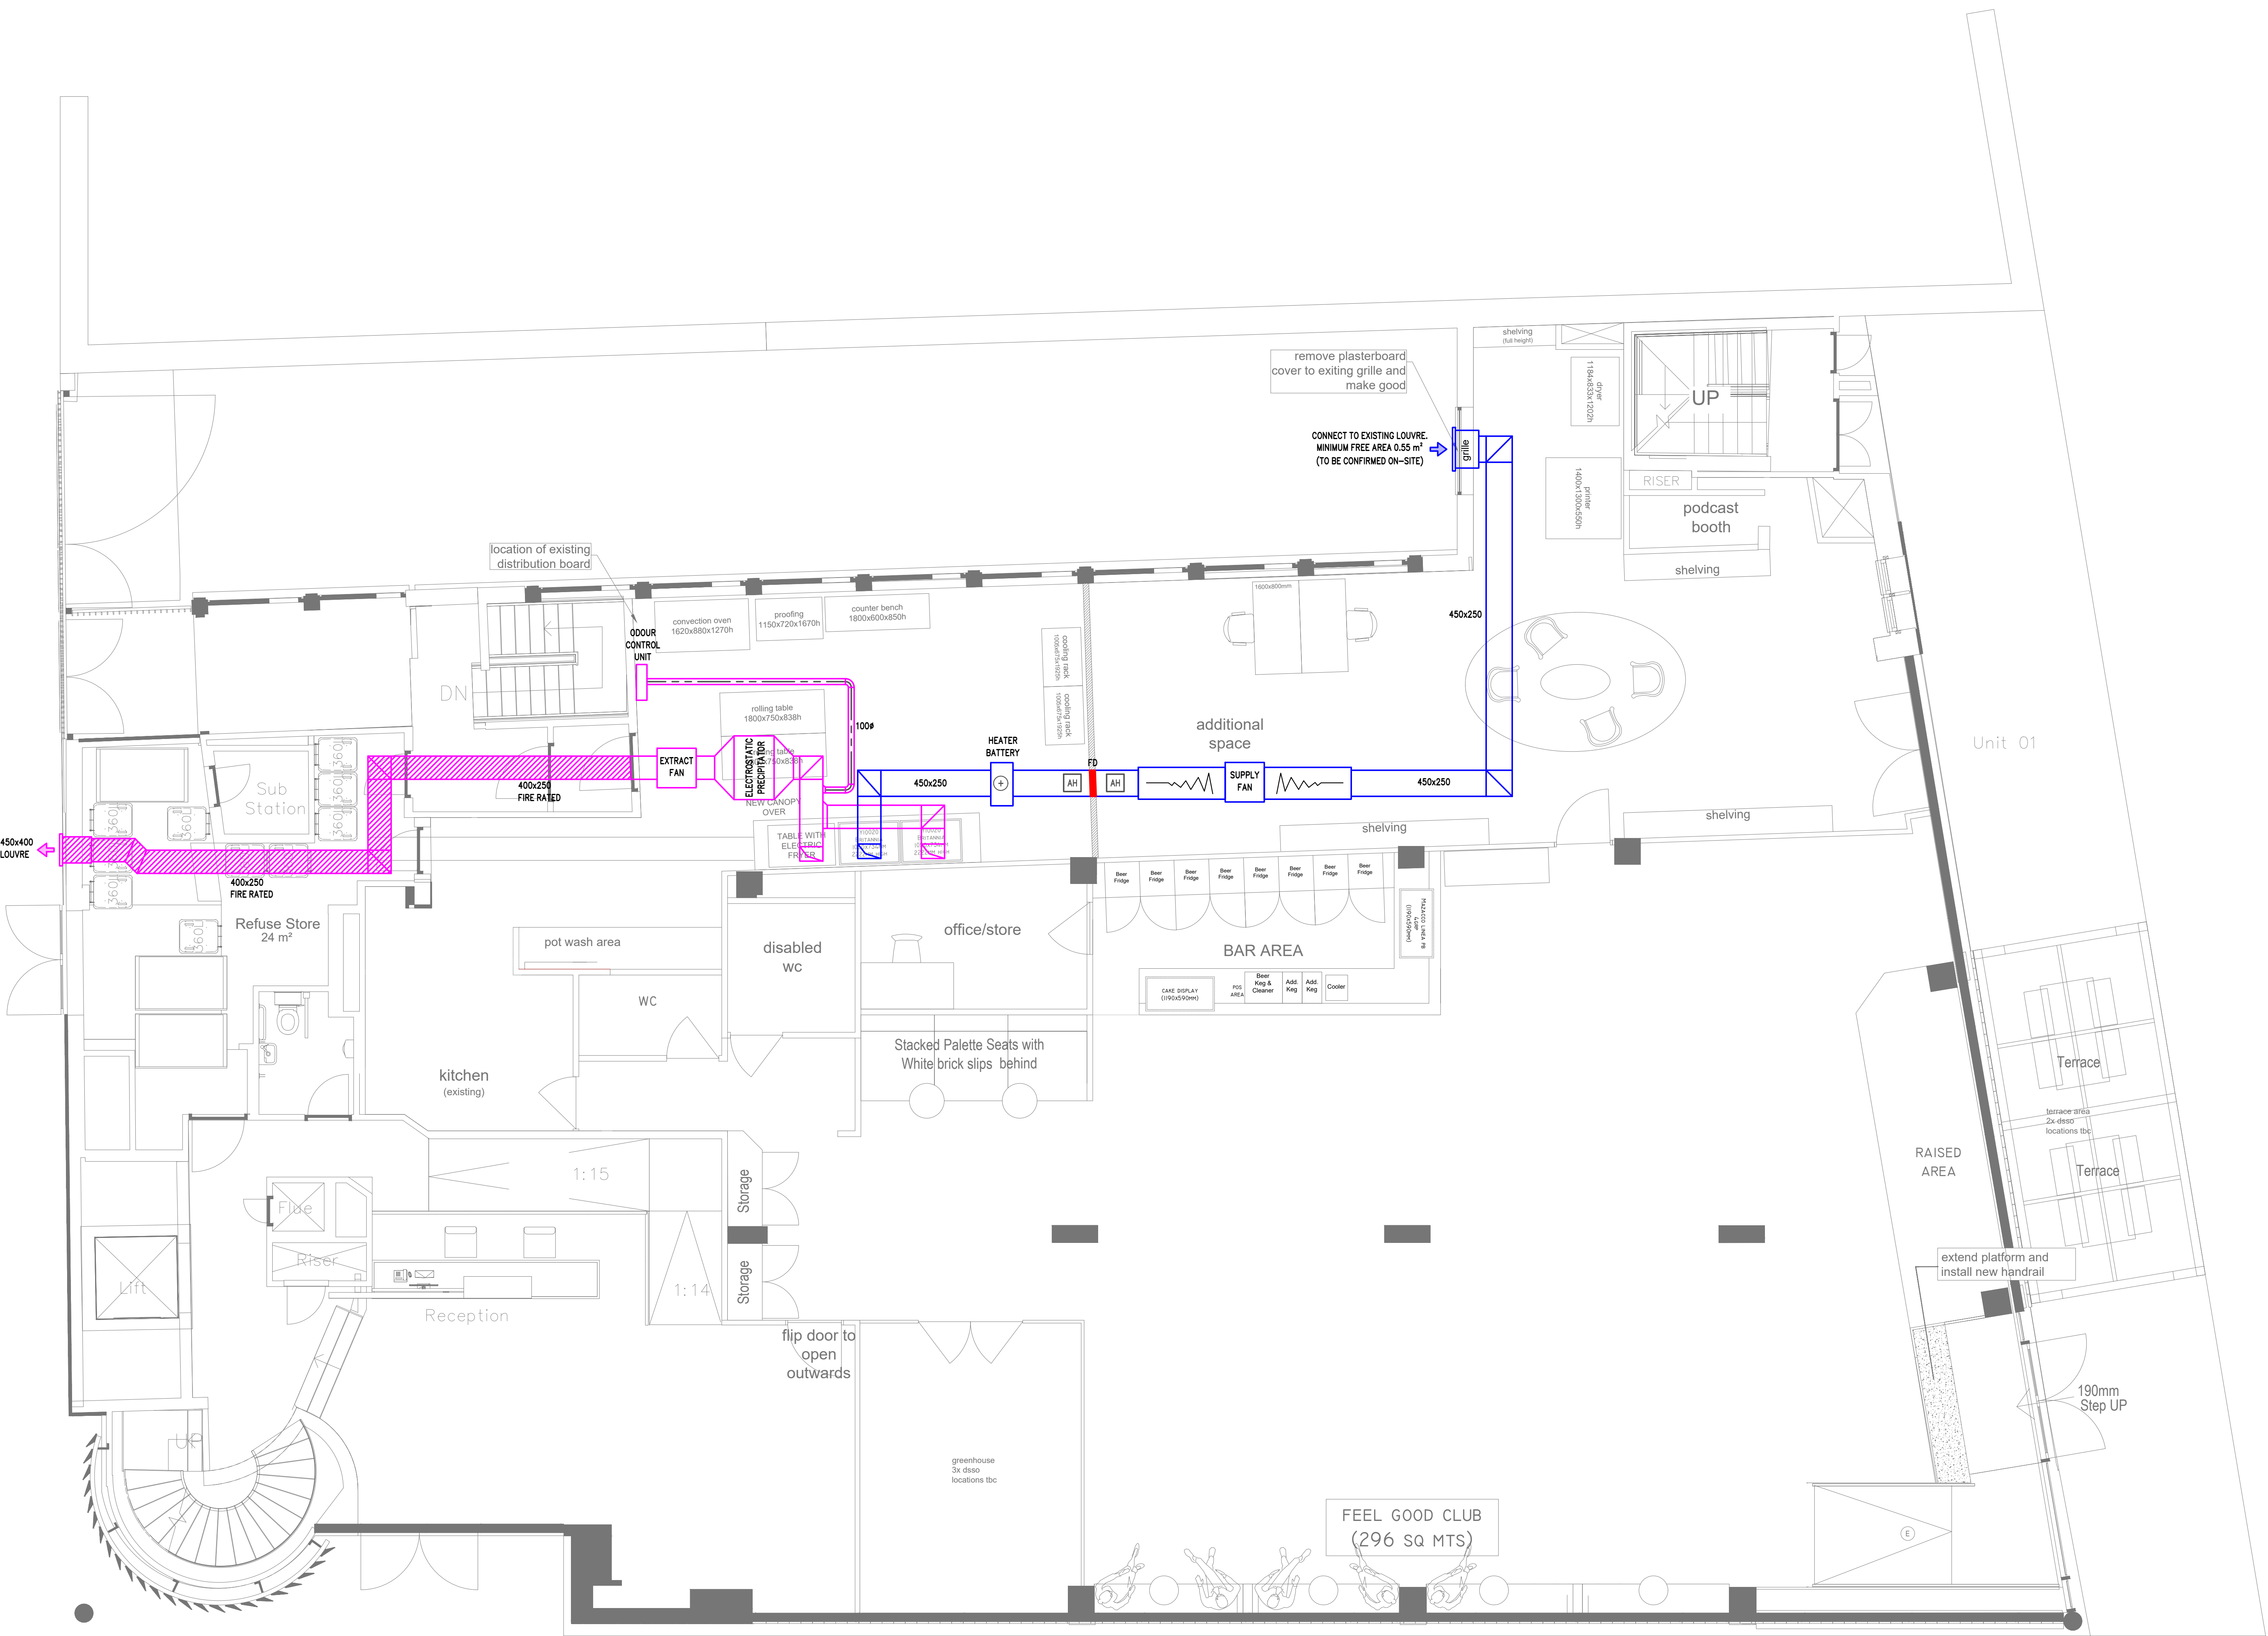

- MECHANICAL VENTILATION LAYOUT LEGEND
- EXISTING SERVICES
 - SUPPLY DUCTWORK
 - EXTRACT DUCTWORK
 - FIRE RATED EXTRACT DUCTWORK
 - DIRTY EXTRACT DUCTWORK
 - SUPPLY GRILLE
 - EXTRACT GRILLE
 - DIRTY EXTRACT GRILLE
 - AIR VALVE
 - ATTENUATOR/CROSS-TALK ATTENUATOR
 - VOLUME CONTROL DAMPER
 - MOTORISED DAMPER
 - LOUVER
 - FIRE DAMPER
 - ACCESS HATCH
 - FLEXIBLE DUCT CONNECTION
 - PASSIVE INFRARED SENSOR
 - HEAT RECOVERY UNIT
 - DUCTED FAN COOL UNIT
 - SUPPLY/EXTRACT FAN
 - PLANT REFERENCE

all power sockets to be galvanised

PRELIMINARY

Revision	P1	PRELIMINARY	08.11.22	
		Revision description		
		Client	Workspace Design & Build	
		Project	Feel Good Club, Manchester	
Title		Ventilation		
		Solution environmental services		
		Pure Office, Brooks Drive, Cheadle Royal Business Park, Cheadle, SK8 3TD Tel: 0161 532 9460 www.solution-es.co.uk		
Drawn by	Checked by	Scale	Sheet Size	
K.H	A.M.	1:50	A0	
Drawing No.	Revision	Date		
SE-AM/M01	P1	08.11.22		