

helter

ED SEWER


ITON OLD ROAD

FINISHED GROUND LEVELS
HAVE BEEN ESTIMATED DUE
TO MISSING SURVEY AND
DESIGN INFORMATION

COVER AND INVERTS OF
EXISTING SEWERS SHOULD
BE CHECKED ON SITE
PRIOR TO CONSTRUCTION

ALL RWP AND SVP'S TO BE
CHECKED AGAINST
ARHICTECTS LAYOUT PLANS

61.4m

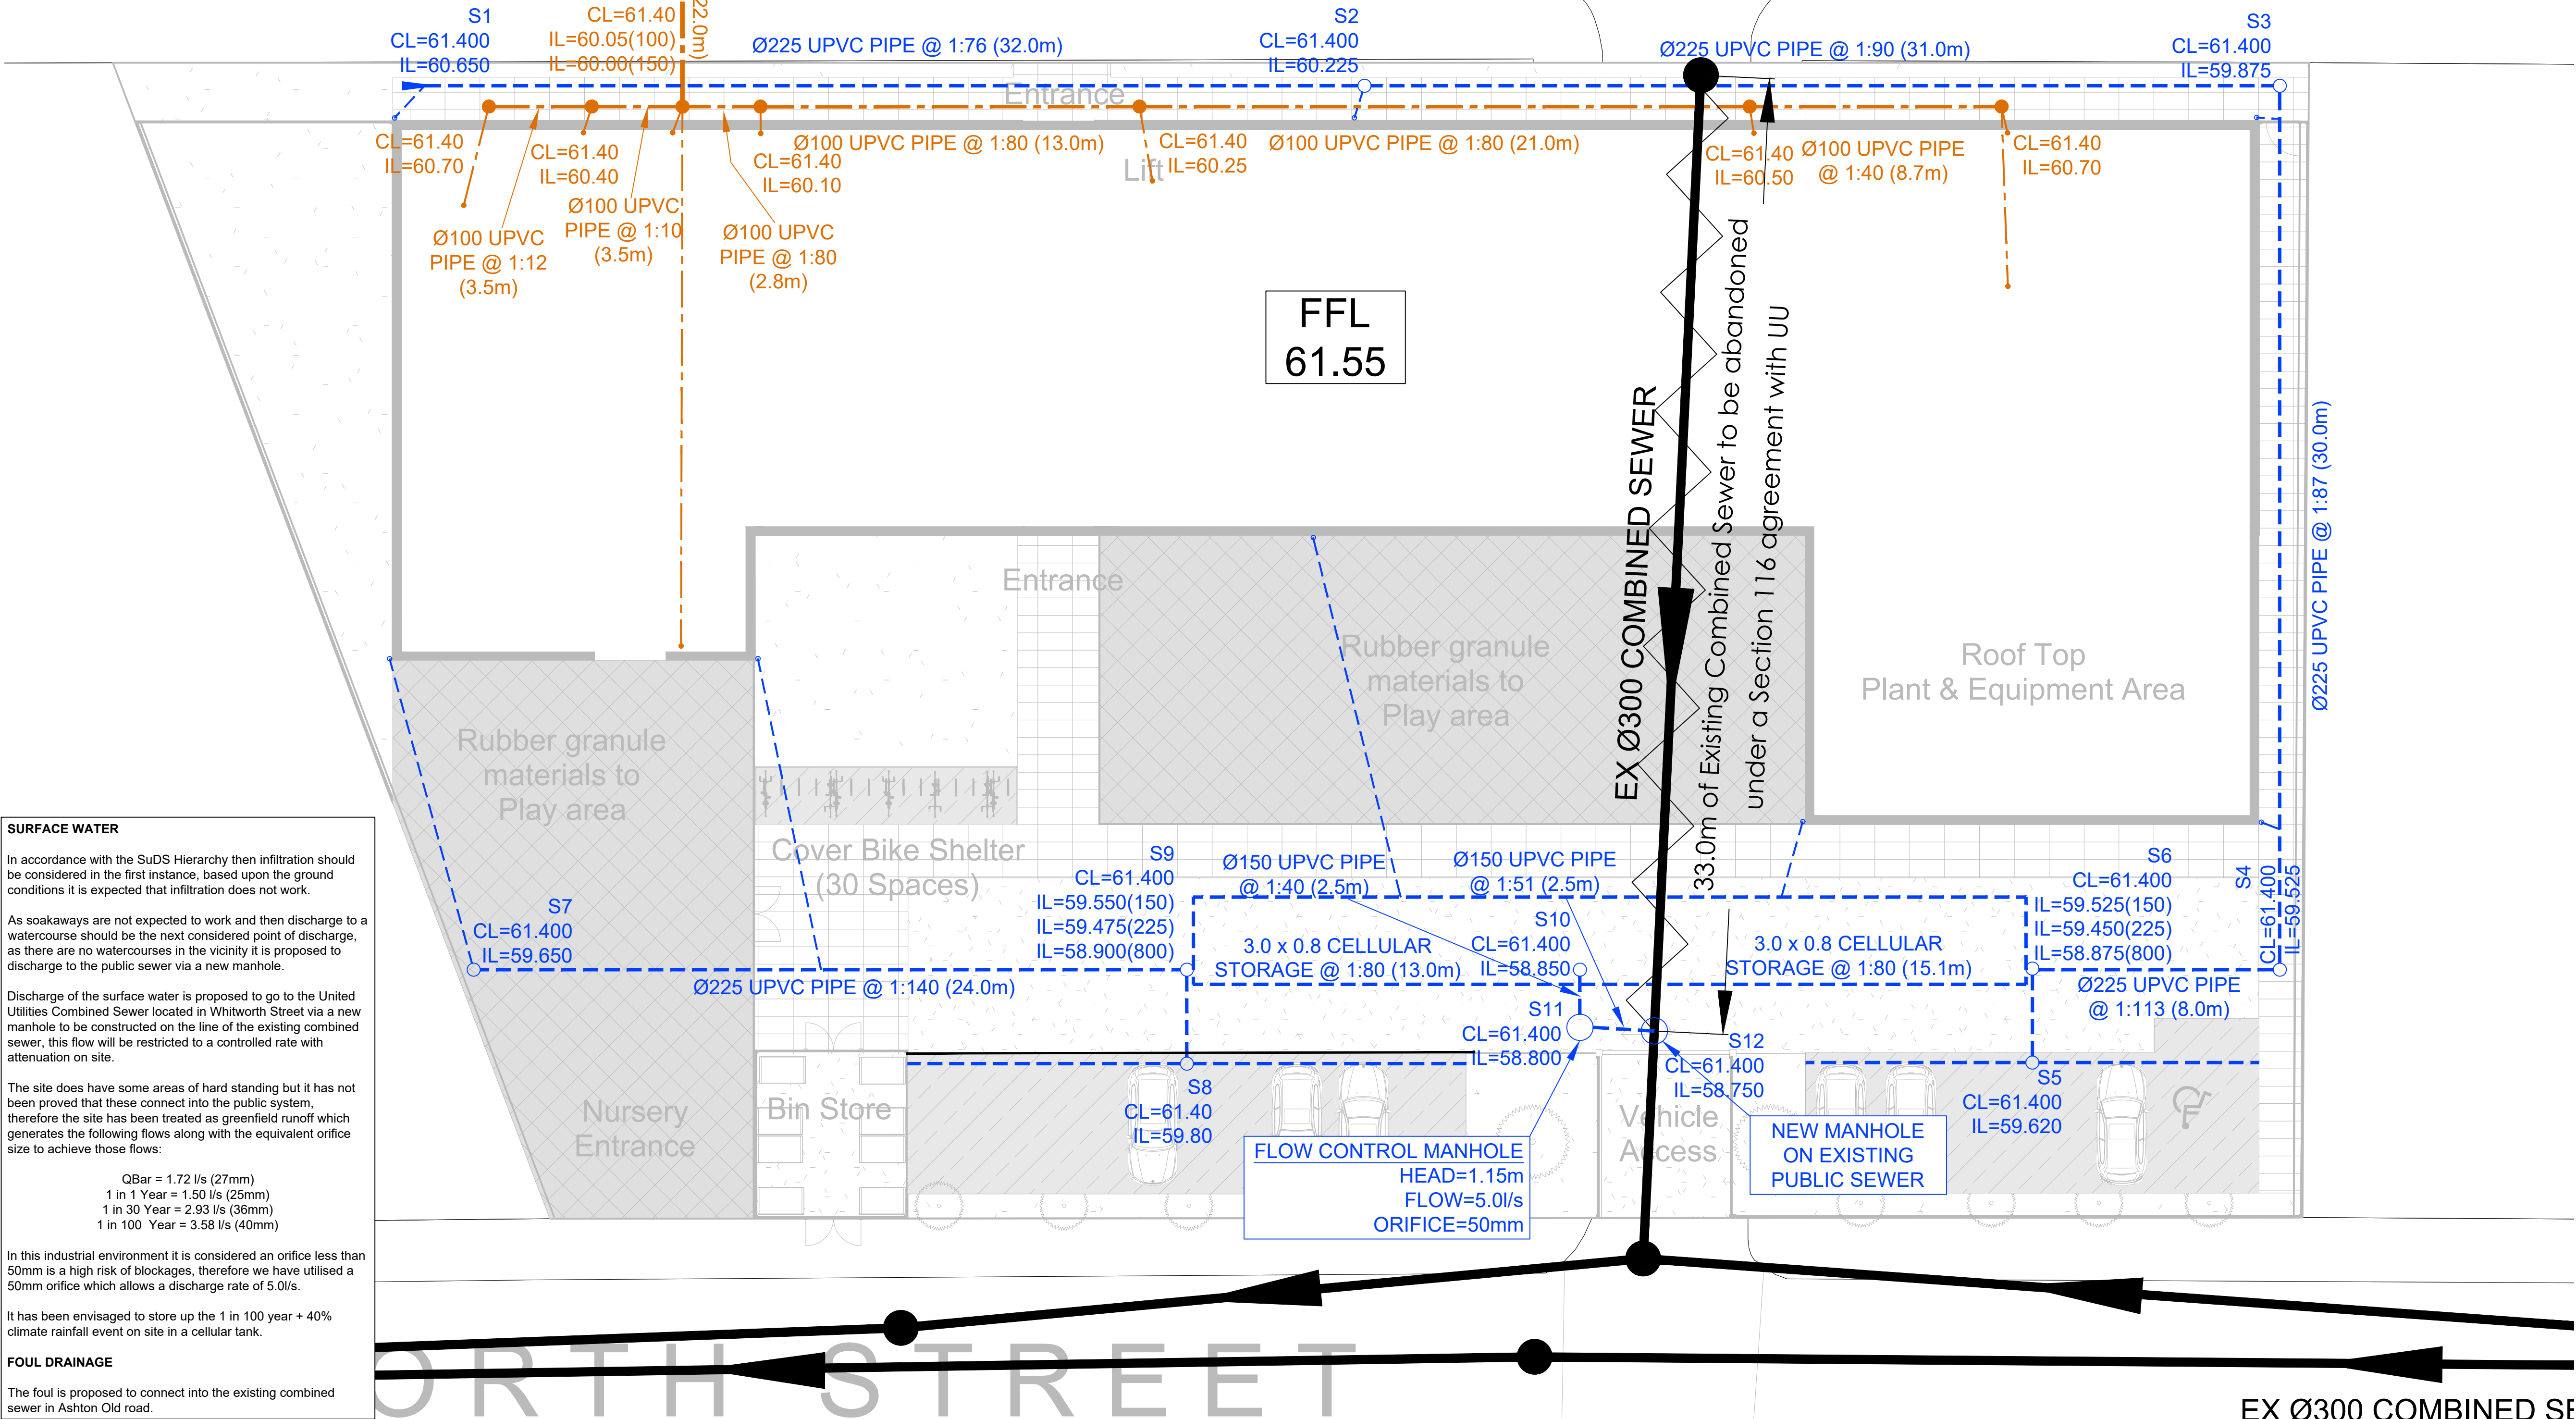

SURFACE WATER

In accordance with the SuDS Hierarchy then infiltration should be considered in the first instance, based upon the ground conditions it is expected that infiltration does not work.

As soakaways are not expected to work and then discharge to a watercourse should be the next considered point of discharge, as there are no watercourses in the vicinity it is proposed to discharge to the public sewer via a new manhole.

Discharge of the surface water is proposed to go to the United Utilities Combined Sewer located in Whitworth Street via a new manhole to be constructed on the line of the existing combined sewer, this flow will be restricted to a controlled rate with attenuation on site.

The site does have some areas of hard standing but it has not been proved that these connect into the public system, therefore the site has been treated as greenfield runoff which generates the following flows along with the equivalent orifice size to achieve those flows:

QBar = 1.72 l/s (27mm)
1 in 1 Year = 1.50 l/s (25mm)
1 in 30 Year = 2.93 l/s (36mm)
1 in 100 Year = 3.58 l/s (40mm)

In this industrial environment it is considered an orifice less than 50mm is a high risk of blockages, therefore we have utilised a 50mm orifice which allows a discharge rate of 5.0l/s.

It has been envisaged to store up the 1 in 100 year + 40% climate rainfall event on site in a cellular tank.

FOUL DRAINAGE

The foul is proposed to connect into the existing combined sewer in Ashton Old road.

- NOTES
1. THIS DRAWING IS PRODUCED FOR USE IN THIS PROJECT ONLY AND MAY NOT BE USED FOR ANY OTHER PURPOSE. THE CONSULTING ENGINEERS ACCEPT NO LIABILITY FOR THE USE OF THIS DRAWING OTHER THAN THE PURPOSE FOR WHICH IT WAS INTENDED IN CONNECTION WITH THIS PROJECT AS RECORDED ON THE TITLE BLOCK FIELDS 'PURPOSE FOR ISSUE' AND 'FILE STATUS CODE'.
 2. THIS DRAWING MAY NOT BE REPRODUCED IN ANY FORM WITHOUT PRIOR WRITTEN AGREEMENT FROM ADVANT ENGINEERS.
 3. DO NOT SCALE FROM THE DRAWING. USE WRITTEN DIMENSIONS ONLY.
 4. ALL DIMENSIONS ARE IN MILLIMETRES UNLESS OTHERWISE SPECIFIED.
 5. DISCREPANCIES MUST BE REPORTED BACK TO THE ENGINEER PRIOR TO CONSTRUCTION.
 6. THIS DRAWING TO BE READ IN CONJUNCTION WITH ALL RELEVANT ADVANT ENGINEERS DRAWINGS AND SPECIFICATIONS.

- KEY
- EXISTING COMBINED SEWER
 - EXISTING SEWER TO BE ABANDONED
 - PROPOSED FOUL SEWER
 - PROPOSED SW SEWER

A	INITIAL ISSUE	MJM	29.07.22
REV	AMENDMENTS	BY	DATE

PRELIMINARY	
STATUS	CHK'D
PRELIMINARY	MJM
FOR COMMENT	
FOR APPROVAL	
FOR CONSTRUCTION	
AS BUILT	



Aspen Close
Gomersal
West Yorkshire
BD19 4NY

(01274) 050280
mail@advantengineers.co.uk
www.advantengineers.co.uk

CLIENT

TRAFFORD LEARNING
VOCATION CENTRE

CONTRACT

REDBY STREET
MANCHESTER
M11 2NP

TITLE

DRAINAGE LAYOUT PLAN

DRAWN	MJM	CHK'D	MJM
SCALE	1:125 @ A1	DATE	29.07.22

JOB No	DRG No	REV
22034	101	A