


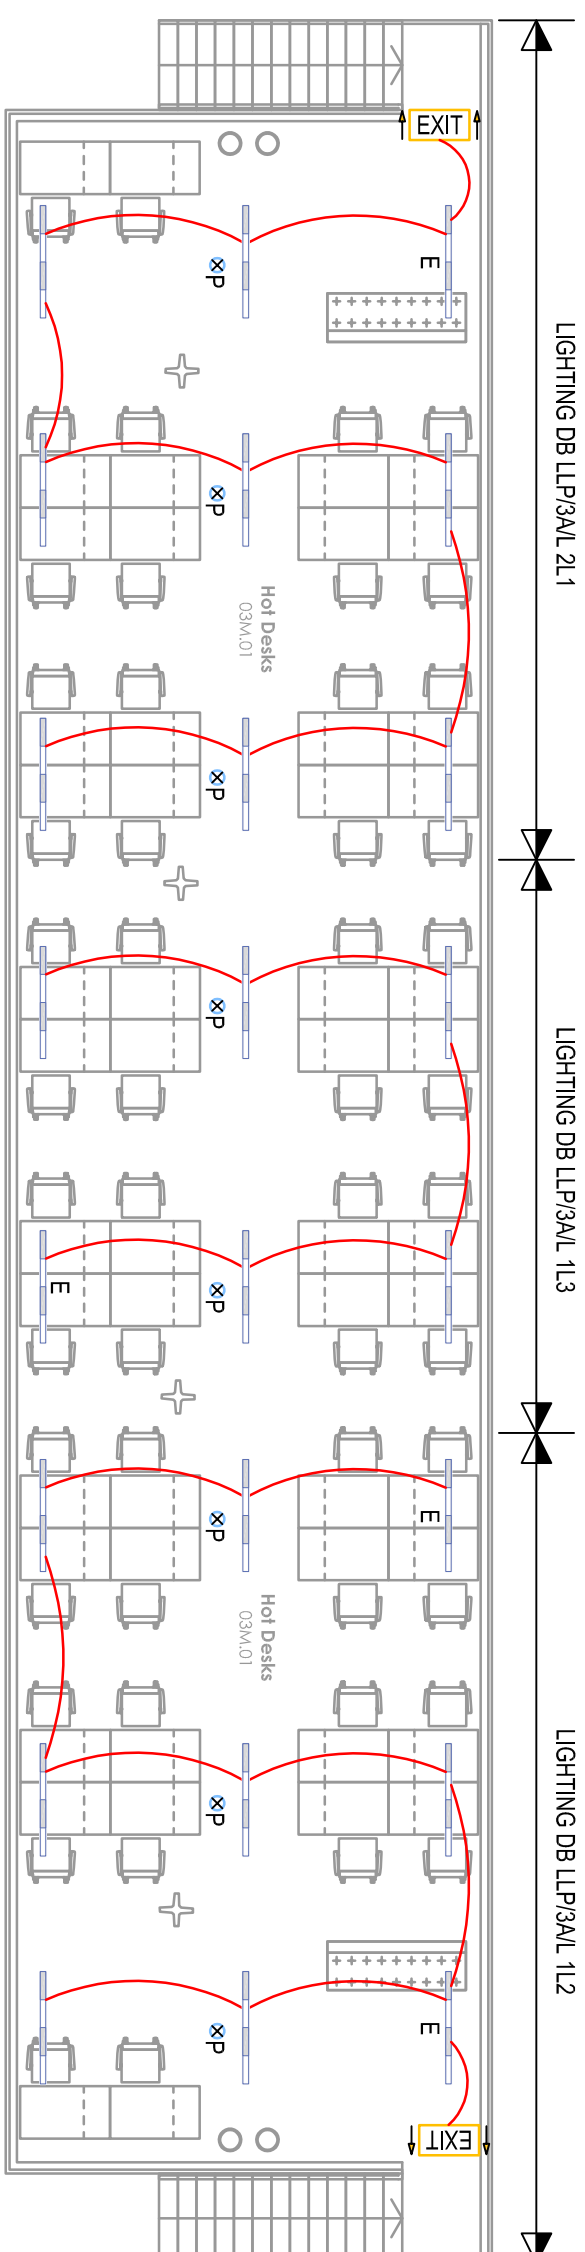

<

AS FITTED DRAWING

Revisions	Description	Ref	Eng	Date
				
	56 QUEEN STREET, FARMWORTH, BOLTON, 01204 579975			
Client	MANCHESTER QUAYS LTD			
Project Title	THE BONDED WAREHOUSE, PHASE 2			
Drawing Title	LEVEL 3 – MEZZANINE LIGHTING/EMERGENCY LIGHTING LAYOUT			
In Association with				
Drawn by	JM	Scales	1:100@A1	
Checked by	JM	(work to figured dimensions)		
Date	JUNE 19			
DWG No.	1799—03—6302		Rev	A/F1