


NOTES:
All dimensions must be checked on site and not scaled from this drawing.

Ref.	Date	Revisions	By
P01	19.11.21	PRELIMINARY ISSUE	B.C.
C01	08.03.22	CONSTRUCTION ISSUE	B.C.
C02	04.07.22	EXTERNAL LIGHTING SCHEME AMENDED TO COMMENTS	C.P.

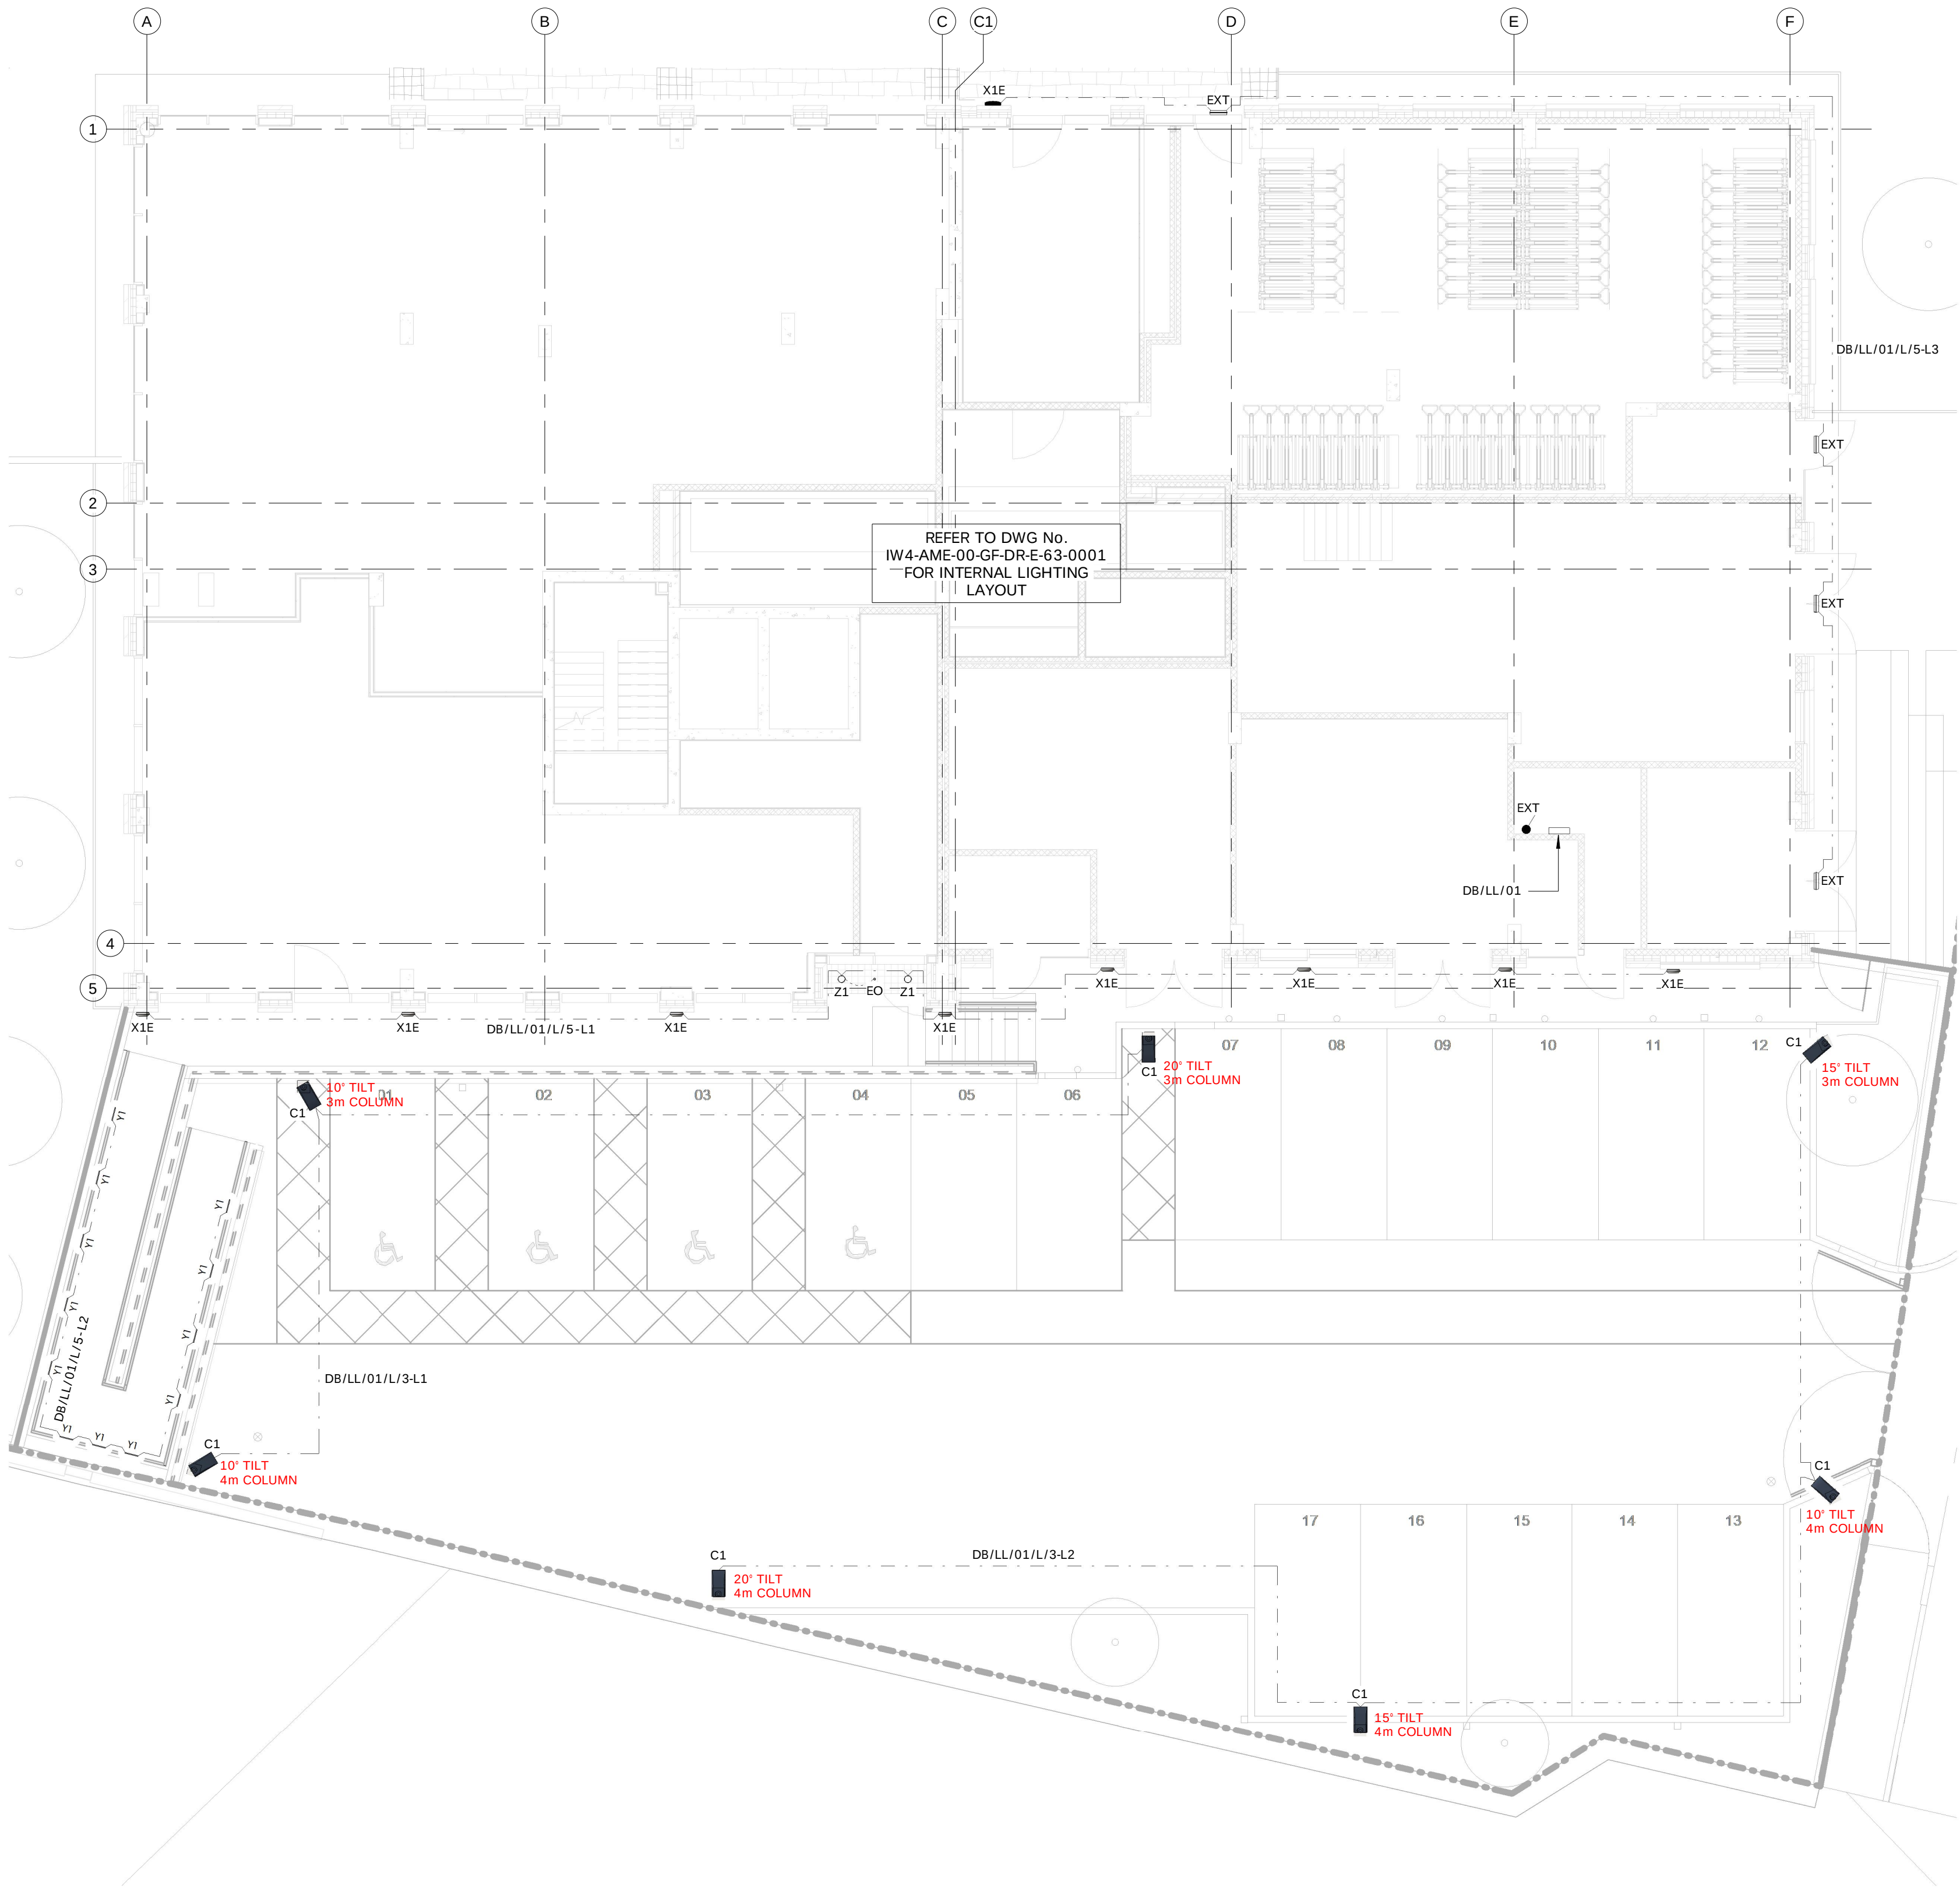


NOTES:

1. ALL DIMENSIONS ARE IN MILLIMETRES UNLESS OTHERWISE INDICATED
2. THIS DRAWING IS TO BE READ IN CONJUNCTION WITH THE EXTERNAL DUCTING LAYOUT DWG No. IW4-AME-00-GF-DR-E-61-0013
3. THIS DRAWING IS TO BE READ IN CONJUNCTION WITH THE EXTERNAL LIGHTING TECHNICAL SUBMITTAL

LEGEND:


- C1 39.9W 3936lm ONIX LED STREET LIGHT
- PC PHOTOCELL
- EXT / ● EXTERNAL LIGHTING OVERRIDE SWITCH
- X1E AMENITY VISION 3 16W 1875lm WALL LIGHT
- Y1 AMENITY 2W 190lm LIBRETTO LED BRICKLIGHT
- EXT EMERGENCY BULKHEAD
- Z1 RECESSED LED DOWNLIGHT
- EO LED3/OA - OPEN AREA EMERGENCY RECESSED SPOT LIGHT

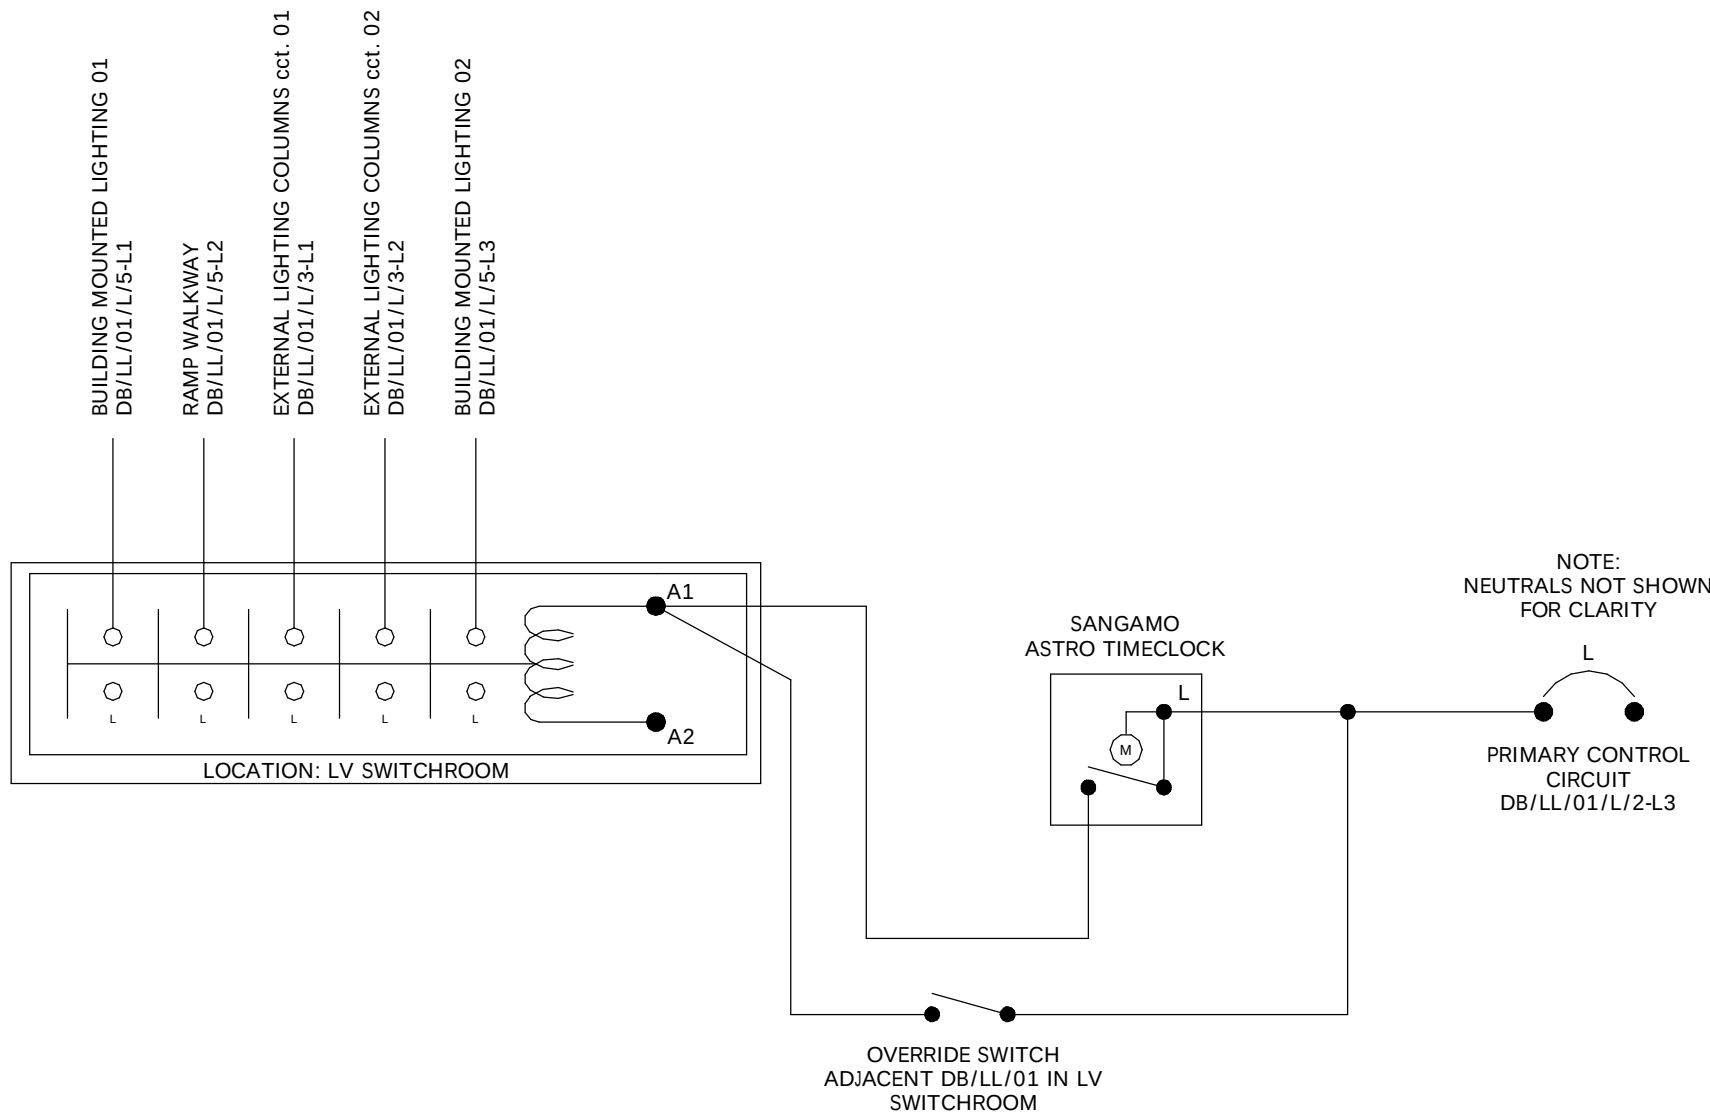

Photocell T/C External Lighting Control Detail

N.T.S.

1 External Lighting Layout
1 : 100

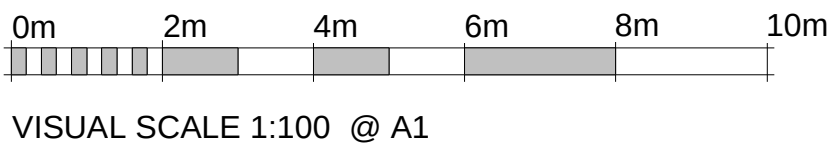

ameon
Building Services Engineering
Unit 9-10 Olympic Court, Boardmans Way,
Whitehills Business Park, Blackpool, FY4 5GU
Tel: 01253 760160
E-mail: info@ameon.co.uk

Client MORGAN SINDALL	Job Title Islington Wharf, Phase 4	Drawing Title External Lighting Layout	Date November 2021	Drawn by B.C.	Check by B.C.
			Scale @ A1 As indicated	Status S4	Revision C02
			Drawing Number IW4-AME-00-GF-DR-E-63-0006		