
 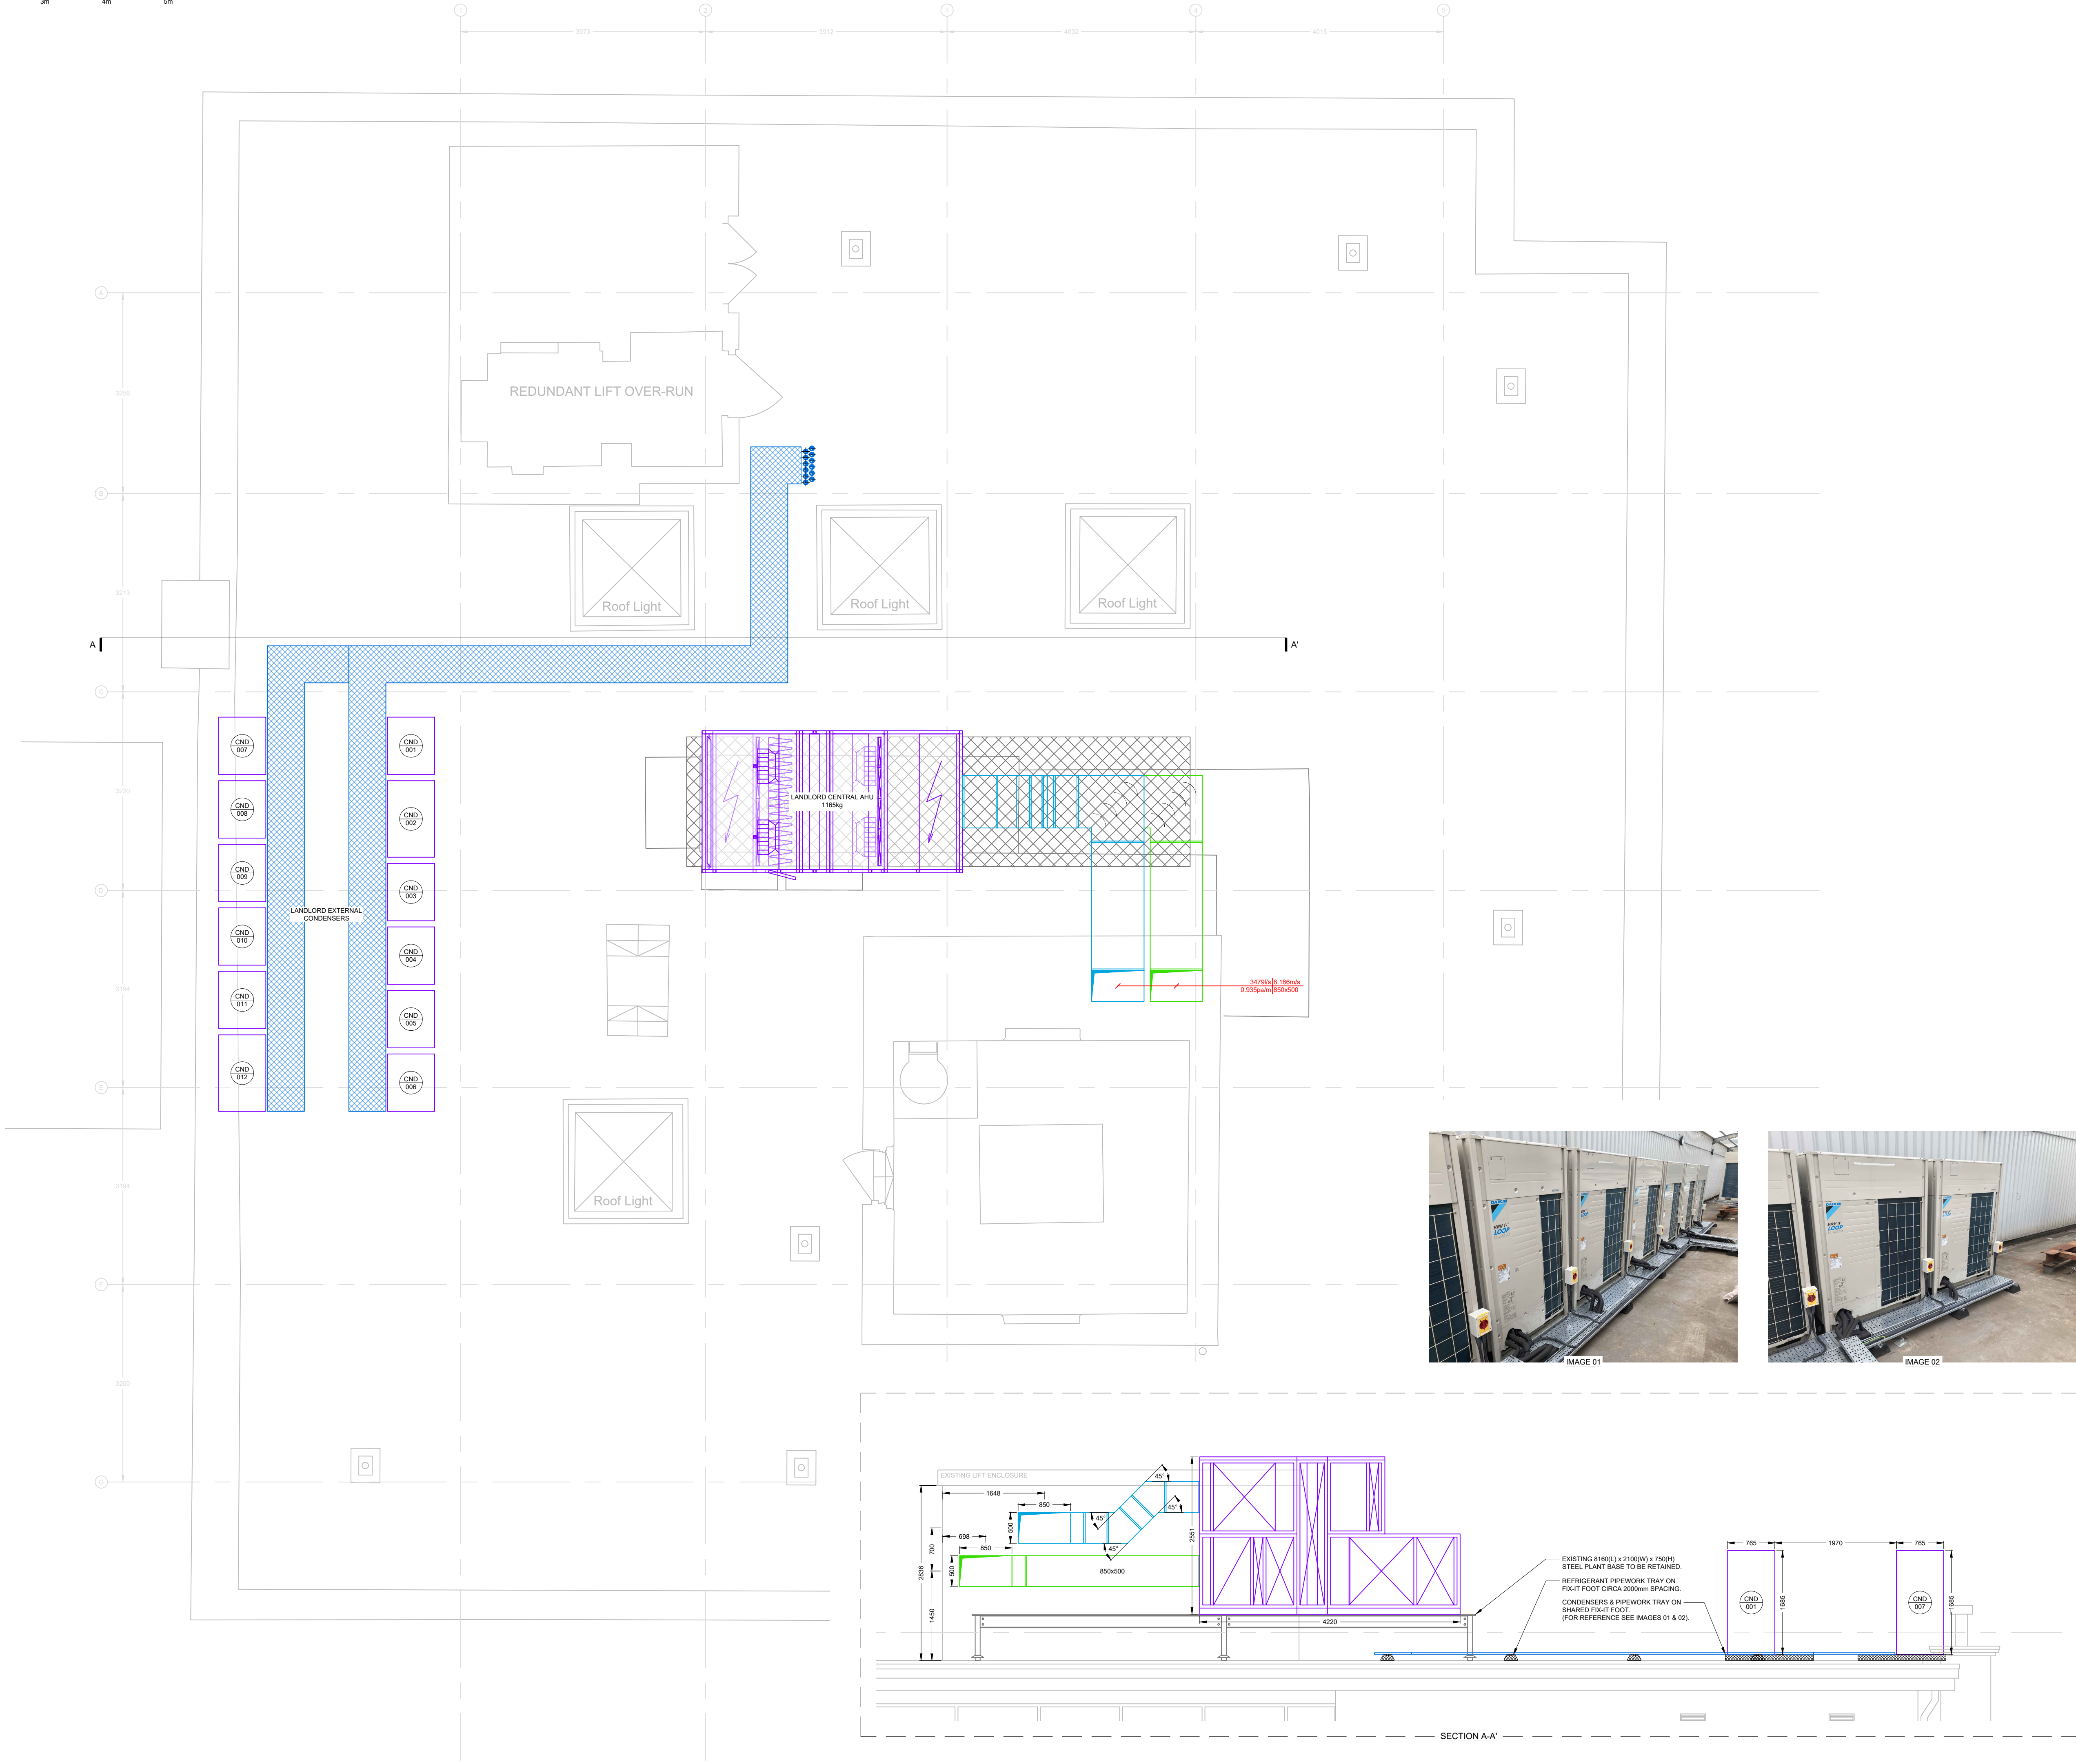




- NOTES:
- THIS DRAWING TO BE READ IN CONJUNCTION WITH THE PROJECT SPECIFIC MAE SPECIFICATIONS & THE PROJECT SPECIFIC DESIGNERS RISK ASSESSMENT.
 - ALL DUCTWORK SHALL CONFORM TO DW 144.
 - ACCESS DOOR SHALL BE PROVIDED IN ACCORDANCE WITH DW 144. POSITION TO BE DETERMINED AND AGREED ON SITE.
 - SMOKE / FIRE DAMPERS AND ACCESS PANELS TO BE INSTALLED WHERE DUCTWORK PASSES THROUGH FIRE WALLS / DOORS. ENSURE ACOUSTIC PERFORMANCE IS NOT AFFECTED.
 - A MAXIMUM OF 500mm OF FLEXIBLE DUCTWORK TO BE USED FOR FINAL CONNECTIONS.

- LEGEND:
- SQUARE DIFFUSER
 - REMOVABLE RETURN GRILLE
 - SWIRL GRILLE
 - CIRCULAR SWIRL GRILLE
 - EGGCRATE GRILLE
 - LECU GRILLE
 - CIRCULAR AIR VALVE
 - LINEAR DIFFUSER
 - BELLMOUTH
 - SUPPLY LOUVRE
 - EXTRACT LOUVRE
 - FIRE DAMPER
 - PRIMARY SUPPLY
 - EXTRACT / RETURN AIR
 - SECONDARY SUPPLY
 - EXISTING
 - REMOVED / RELOCATED
 - DTB / RTA
 - DTLL / RTHL
 - VOLUME CONTROL DAMPER
 - BACKDRAUGHT DAMPER
 - CROSSTALK ATTENUATOR
 - IN LINE FAN
 - HEATER BATTERY
 - DOOR TRANSFER GRILLE
 - DOOR UNDERCUT
 - TWIN FAN
 - AC CONTROLLER
 - CENTRAL CONTROLLER
 - FAN CONTROLLER
 - ACCESS HATCH
 - HEAT RECOVERY UNIT
 - FAN COIL UNIT
 - AC CASSETTE
 - WALL MOUNTED FAN COIL
 - OUTDOOR CONDENSING UNIT
 - BRANCH CONTROLLER
 - PANEL HEATER / RADIATOR

FLOW RATE/VELOCITY
PRESSURE LOSS/DUCT DIAMETER

REV	DESCRIPTION	DATE
P01	PRELIMINARY ISSUE.	01.08.2022
P02	PRELIMINARY ISSUE.	30.08.2022
P03	MINOR AMENDMENTS.	22.09.2022
P04	MINOR AMENDMENTS.	03.10.2022

DRAWING STATUS
PRELIMINARY ISSUE

PULSE
PROJECT SOLUTIONS

Unit 4a
Zebra Court
Greenside Way
Manchester
M24 1UN

0161 655 0290
info@pulseprojectsolutions.com
www.pulseprojectsolutions.com

PROJECT MANAGER	DESIGN
SCALE @A1	1:50
DATE	05.08.2022

PROJECT	FREE TRADE FREE TRADE HALL PETER STREET MANCHESTER M2 5GP
---------	---

DRAWING TITLE	ROOF LEVEL AC & VENTILATION LAYOUT
---------------	---------------------------------------

DRAWING NO.	REV
P2218-PPS-XX-08-5F-DR-M-5701	P04