


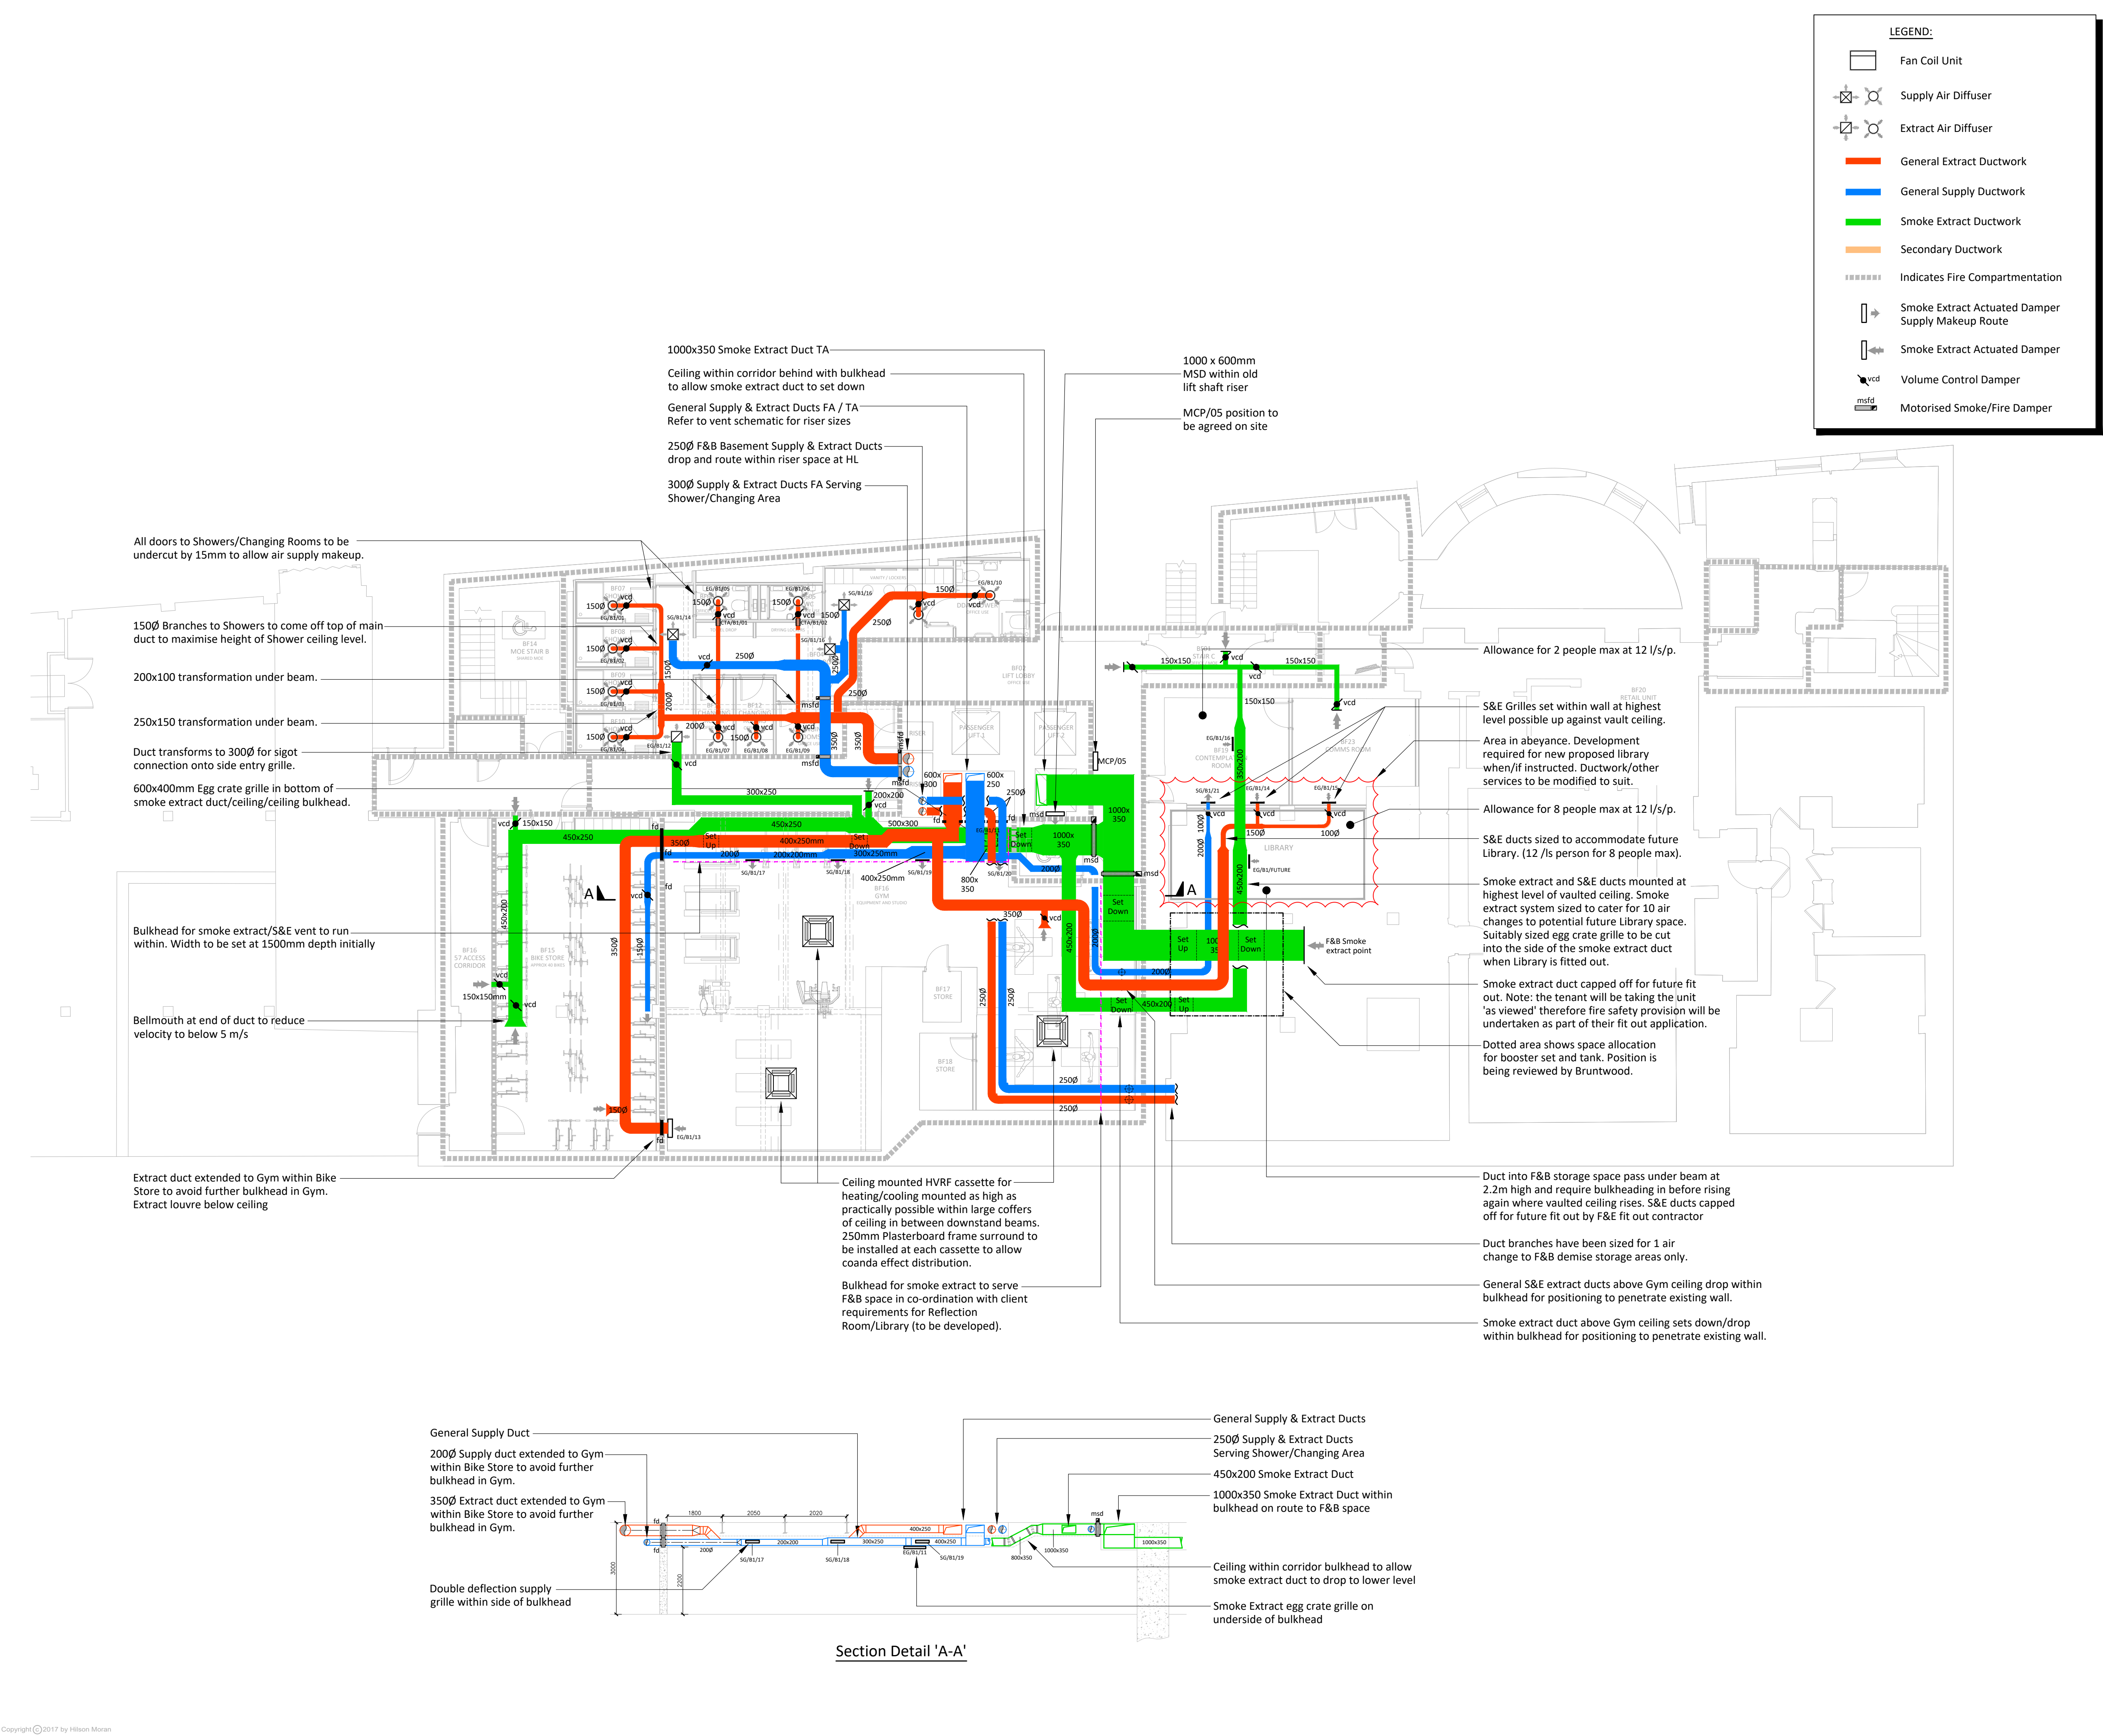

Do not scale from this drawing.
Verify dimensions by site measurement.
Read this drawing in conjunction with the latest architectural and structural drawings.
This drawing is based on the following information:-

- Notes**
- This drawing to be read in conjunction with all mechanical, electrical & public health drawings for this contract.
 - All services work to be carried out in accordance with the relevant Engineering Specification for this contract.
 - All existing Mechanical Services installations shall be isolated, disconnected and stripped out throughout the entire building unless stated otherwise. All stripped out materials to be disposed of in accordance with WEEE regulations.

04	09/09/22	General vent and smoke extract system updates to suit Gym ceiling and introduction of a new contemplation and potential library / introduction of gym space	MR	SH
03	20/05/22	Stage 4 Tender Update.	MR	SH
02	29/04/22	Stage 4 Tender Issue.	MR	SH
01	31/03/22	Stage 3 Issue.	RG	SH

Revision Date Description Drawn Checked

HIM

hilsonmoran.com info@hilsonmoran.com

Client

Bruntwood

Project

38-42 Mosley Street
Grade 2* Listed Building Refurbishment

Drawing Title

Mechanical Services
Basement Level
Ventilation Layout

Scale	Sheet Size	Checked	Approved
1:100	A1	SH	SR
Status	HM Project No.		
For Information	27618		
Drawing No.	Rev		
27618-HM-ZZ-B1-DR-MS-2200	04		