


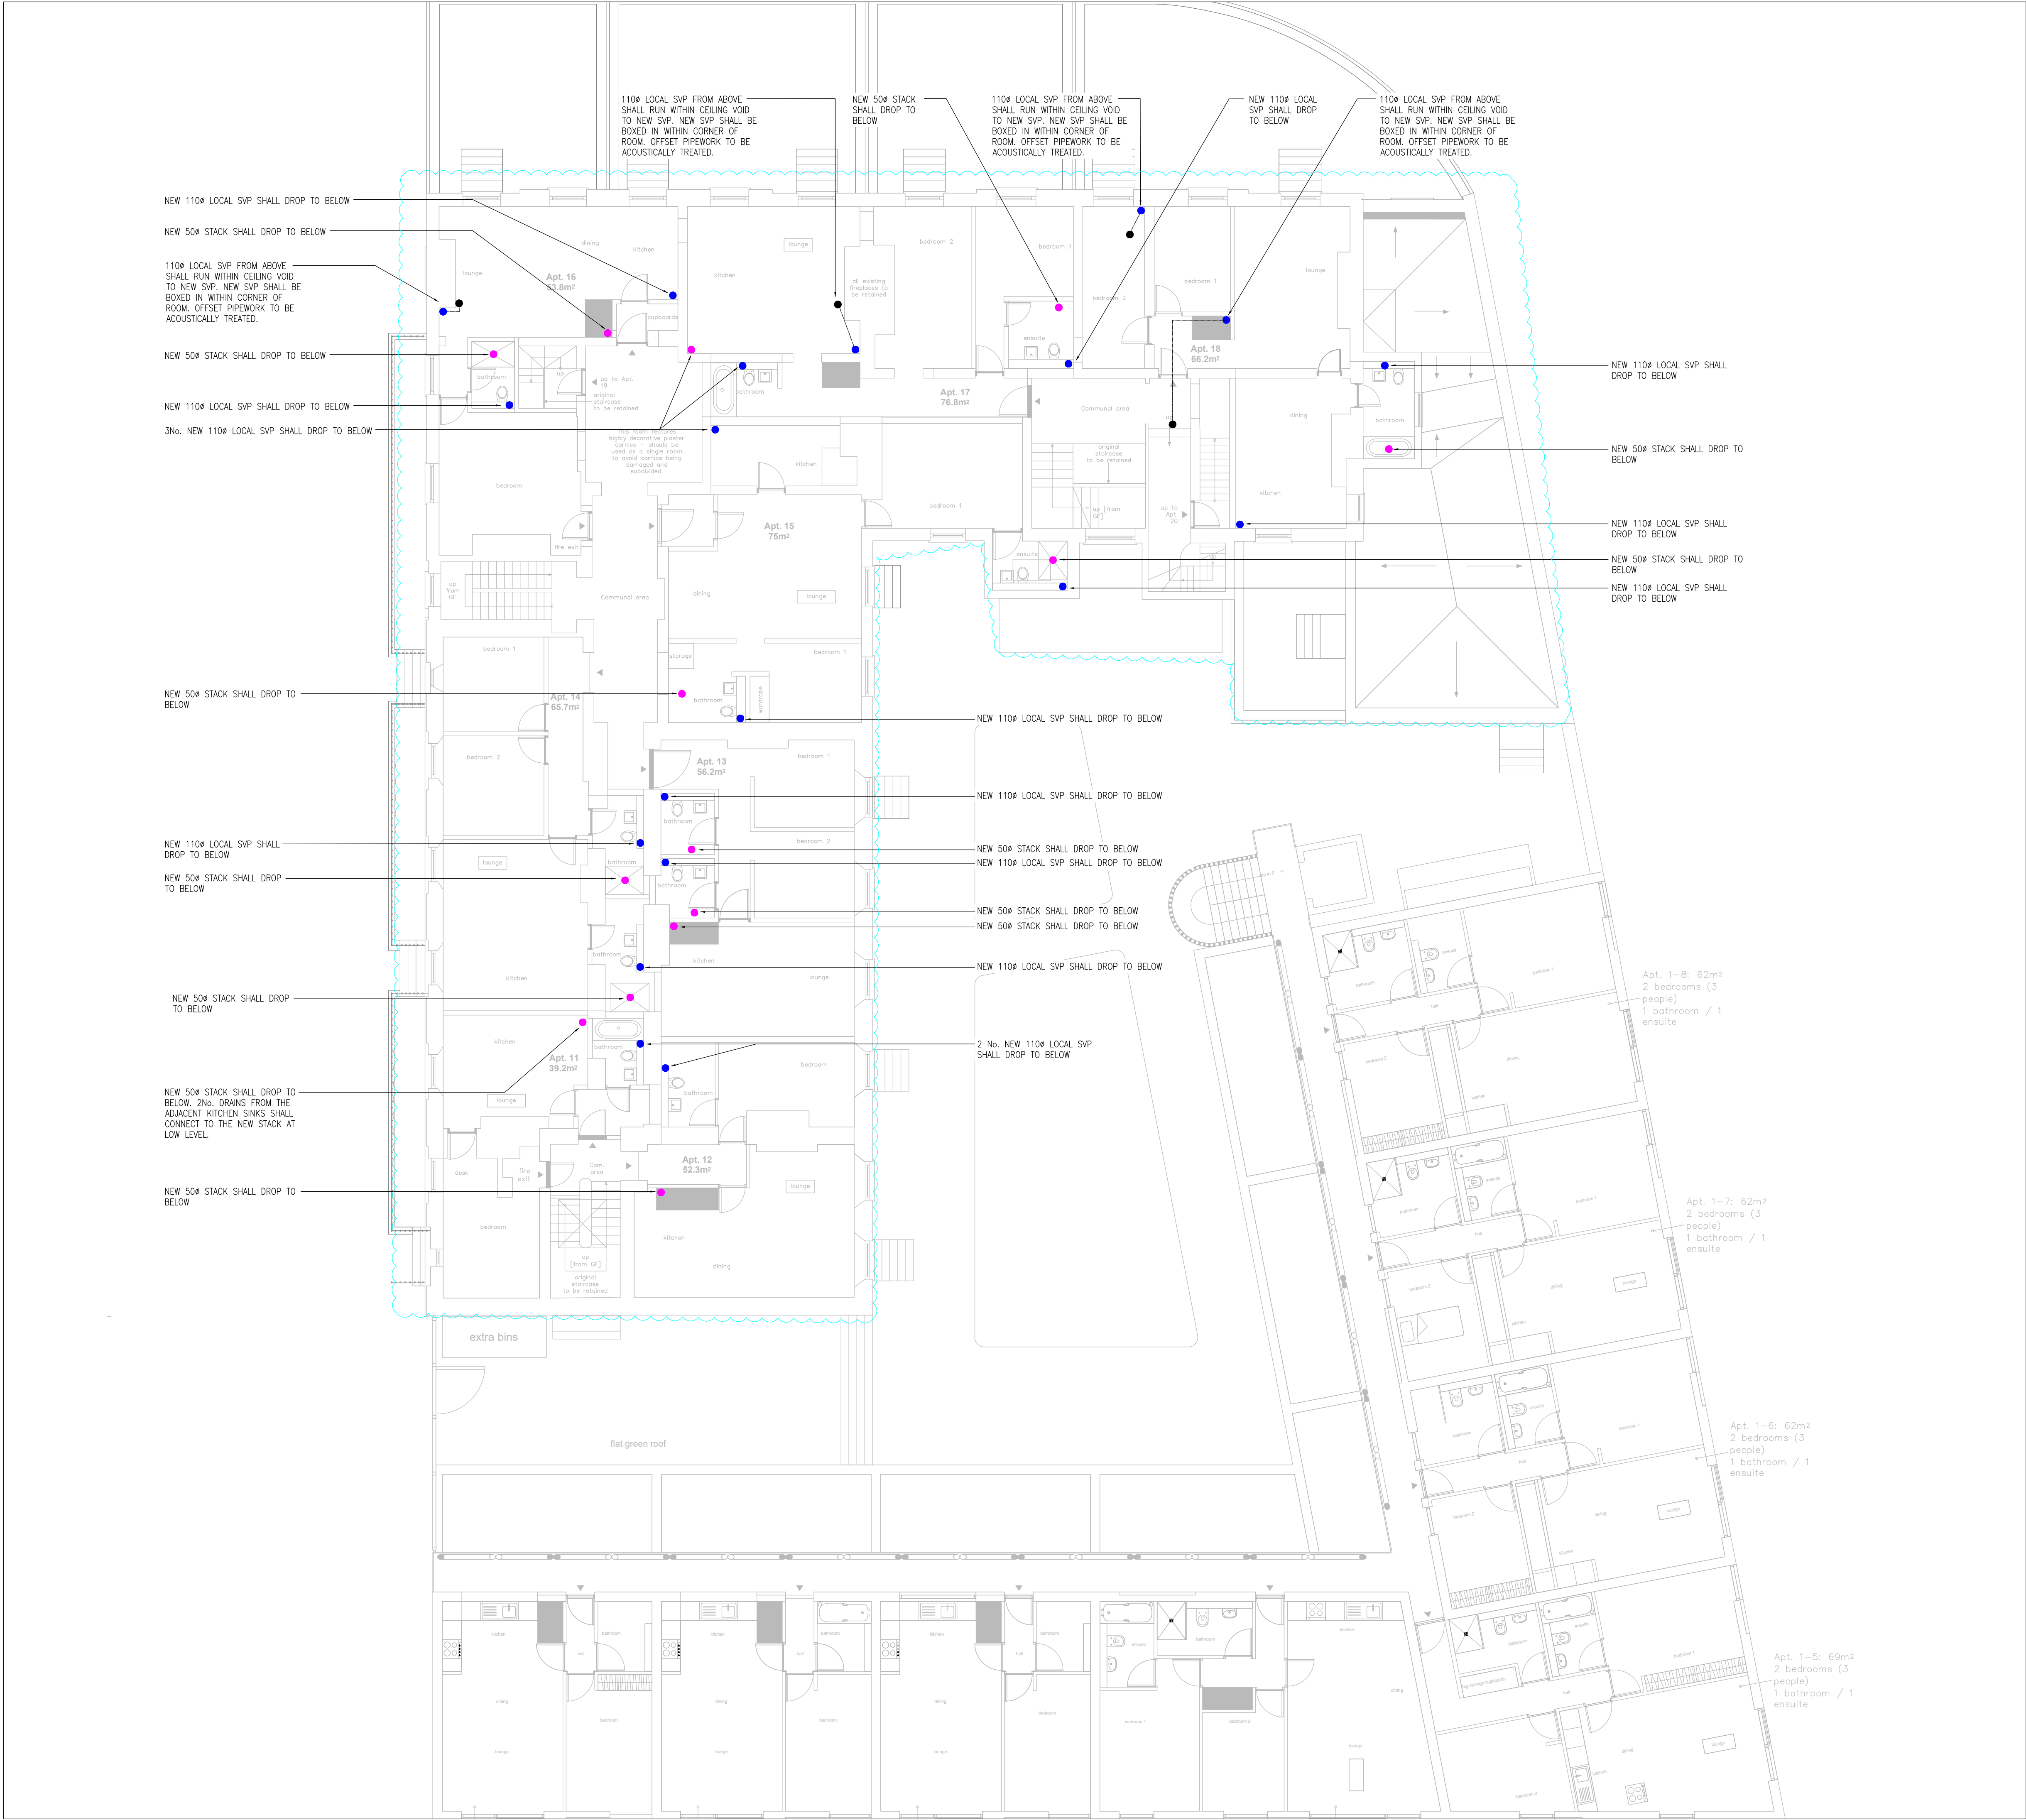

- NOTES:
1. THIS DRAWING SHALL BE READ IN CONJUNCTION WITH THE ARCHITECTURAL HERITAGE REPORT AND ALL RELEVANT PROJECT INFORMATION.
 2. ALL DRAINAGE MUST AVOID DISTURBING HERITAGE DETAILS. FINAL POSITION OF DISTRIBUTING DRAINAGE PIPEWORK TO BE COORDINATED WITH THE HERITAGE DETAILS AND ARCHITECTS LAYOUTS.
 3. ALL ABOVE GROUND DRAINAGE TO COMPLY WITH EN12056, BS8301 AND APPROVED DOCUMENT H IN ALL RESPECTS AND TO THE SATISFACTION OF THE LOCAL DRAINAGE AND ENVIRONMENTAL INSPECTOR AND THE SERVICES ENGINEER.
 4. DRAINAGE DETAILED ON THIS DRAWING IS FOR INTERNAL ABOVE GROUND DRAINAGE INSTALLATION. ALL DRAINAGE BELOW GROUND FLOOR SLAB SHALL BE DESIGNED BY THE STRUCTURAL/CIVIL ENGINEER.
 5. ABOVE GROUND CONNECTIONS SHALL CONNECT TO BELOW GROUND SYSTEM BY CONNECTION PIECE PROVIDED BY THE STRUCTURAL ENGINEER.
 6. ALL TRAPS SHALL BE ANTI-SYPHON WITH MINIMUM 75MM SEAL.
 7. STACK TO BE VENTILATED TO ATMOSPHERE WHERE POSSIBLE, TERMINATING WITH A WEATHERPROOF VENT TERMINAL.
 8. ALL NEW SVP'S AND OFFSETS IN CEILING VOID WITHIN COMMON AREAS AND LIVING QUARTERS TO BE ACOUSTICALLY TREATED

- LEGEND
- PROPOSED 110mm LOCAL SVP DROPPING FROM SECOND FLOOR TO FIRST FLOOR
 - PROPOSED 110mm LOCAL SVP DROPPING FROM LOW LEVEL ON FIRST FLOOR TO GROUND FLOOR
 - PROPOSED 50mm STACK DROPPING TO THE FLOOR BELOW
 - PROPOSED DRAINAGE PIPEWORK RUNNING WITHIN CEILING VOID
 - DENOTES HERITAGE ZONES OF SPECIFIC CONCERN. ALL DRAINAGE WITHIN THIS AREA MUST AVOID DISTURBING HERITAGE DETAILS. FINAL POSITION OF DROPPING DRAINAGE PIPEWORK TO BE COORDINATED WITH THE HERITAGE DETAILS.

Date	Description	Rev	By
Revision Description			



consulting engineers

Manchester Office

2 Commercial Street
Castlefield
Manchester
M15 4RQ

Tel No: 0161 832 2030
E: hk.manchester@hulley.co.uk

...Making Buildings Work

Project:

Bridgewater House

Drawing Title:

**Mechanical Engineering Services
Bridgewater House, First Floor
Indicative Heritage Drainage Layout**

Drawing Number:

50958(52)002

Revision:

Date: 28/06/2022

Scale: 1:100

Drawn By: T.Sugden

CAD Dwg File: 50958(52)002.dwg

Arch. Base Dwg:

Issue Status:

For Information