


NOTES:
All dimensions must be checked on site and not scaled from this drawing.

Ref.	Date	Revisions	By
P01	19.11.21	PRELIMINARY ISSUE	B.C.
C01	08.03.22	CONSTRUCTION ISSUE	B.C.
C02	04.07.22	EXTERNAL LIGHTING SCHEME AMENDED TO COMMENTS	C.P.
C03	16.11.22	EXTERNAL COLUMNS REVISED	B.C.

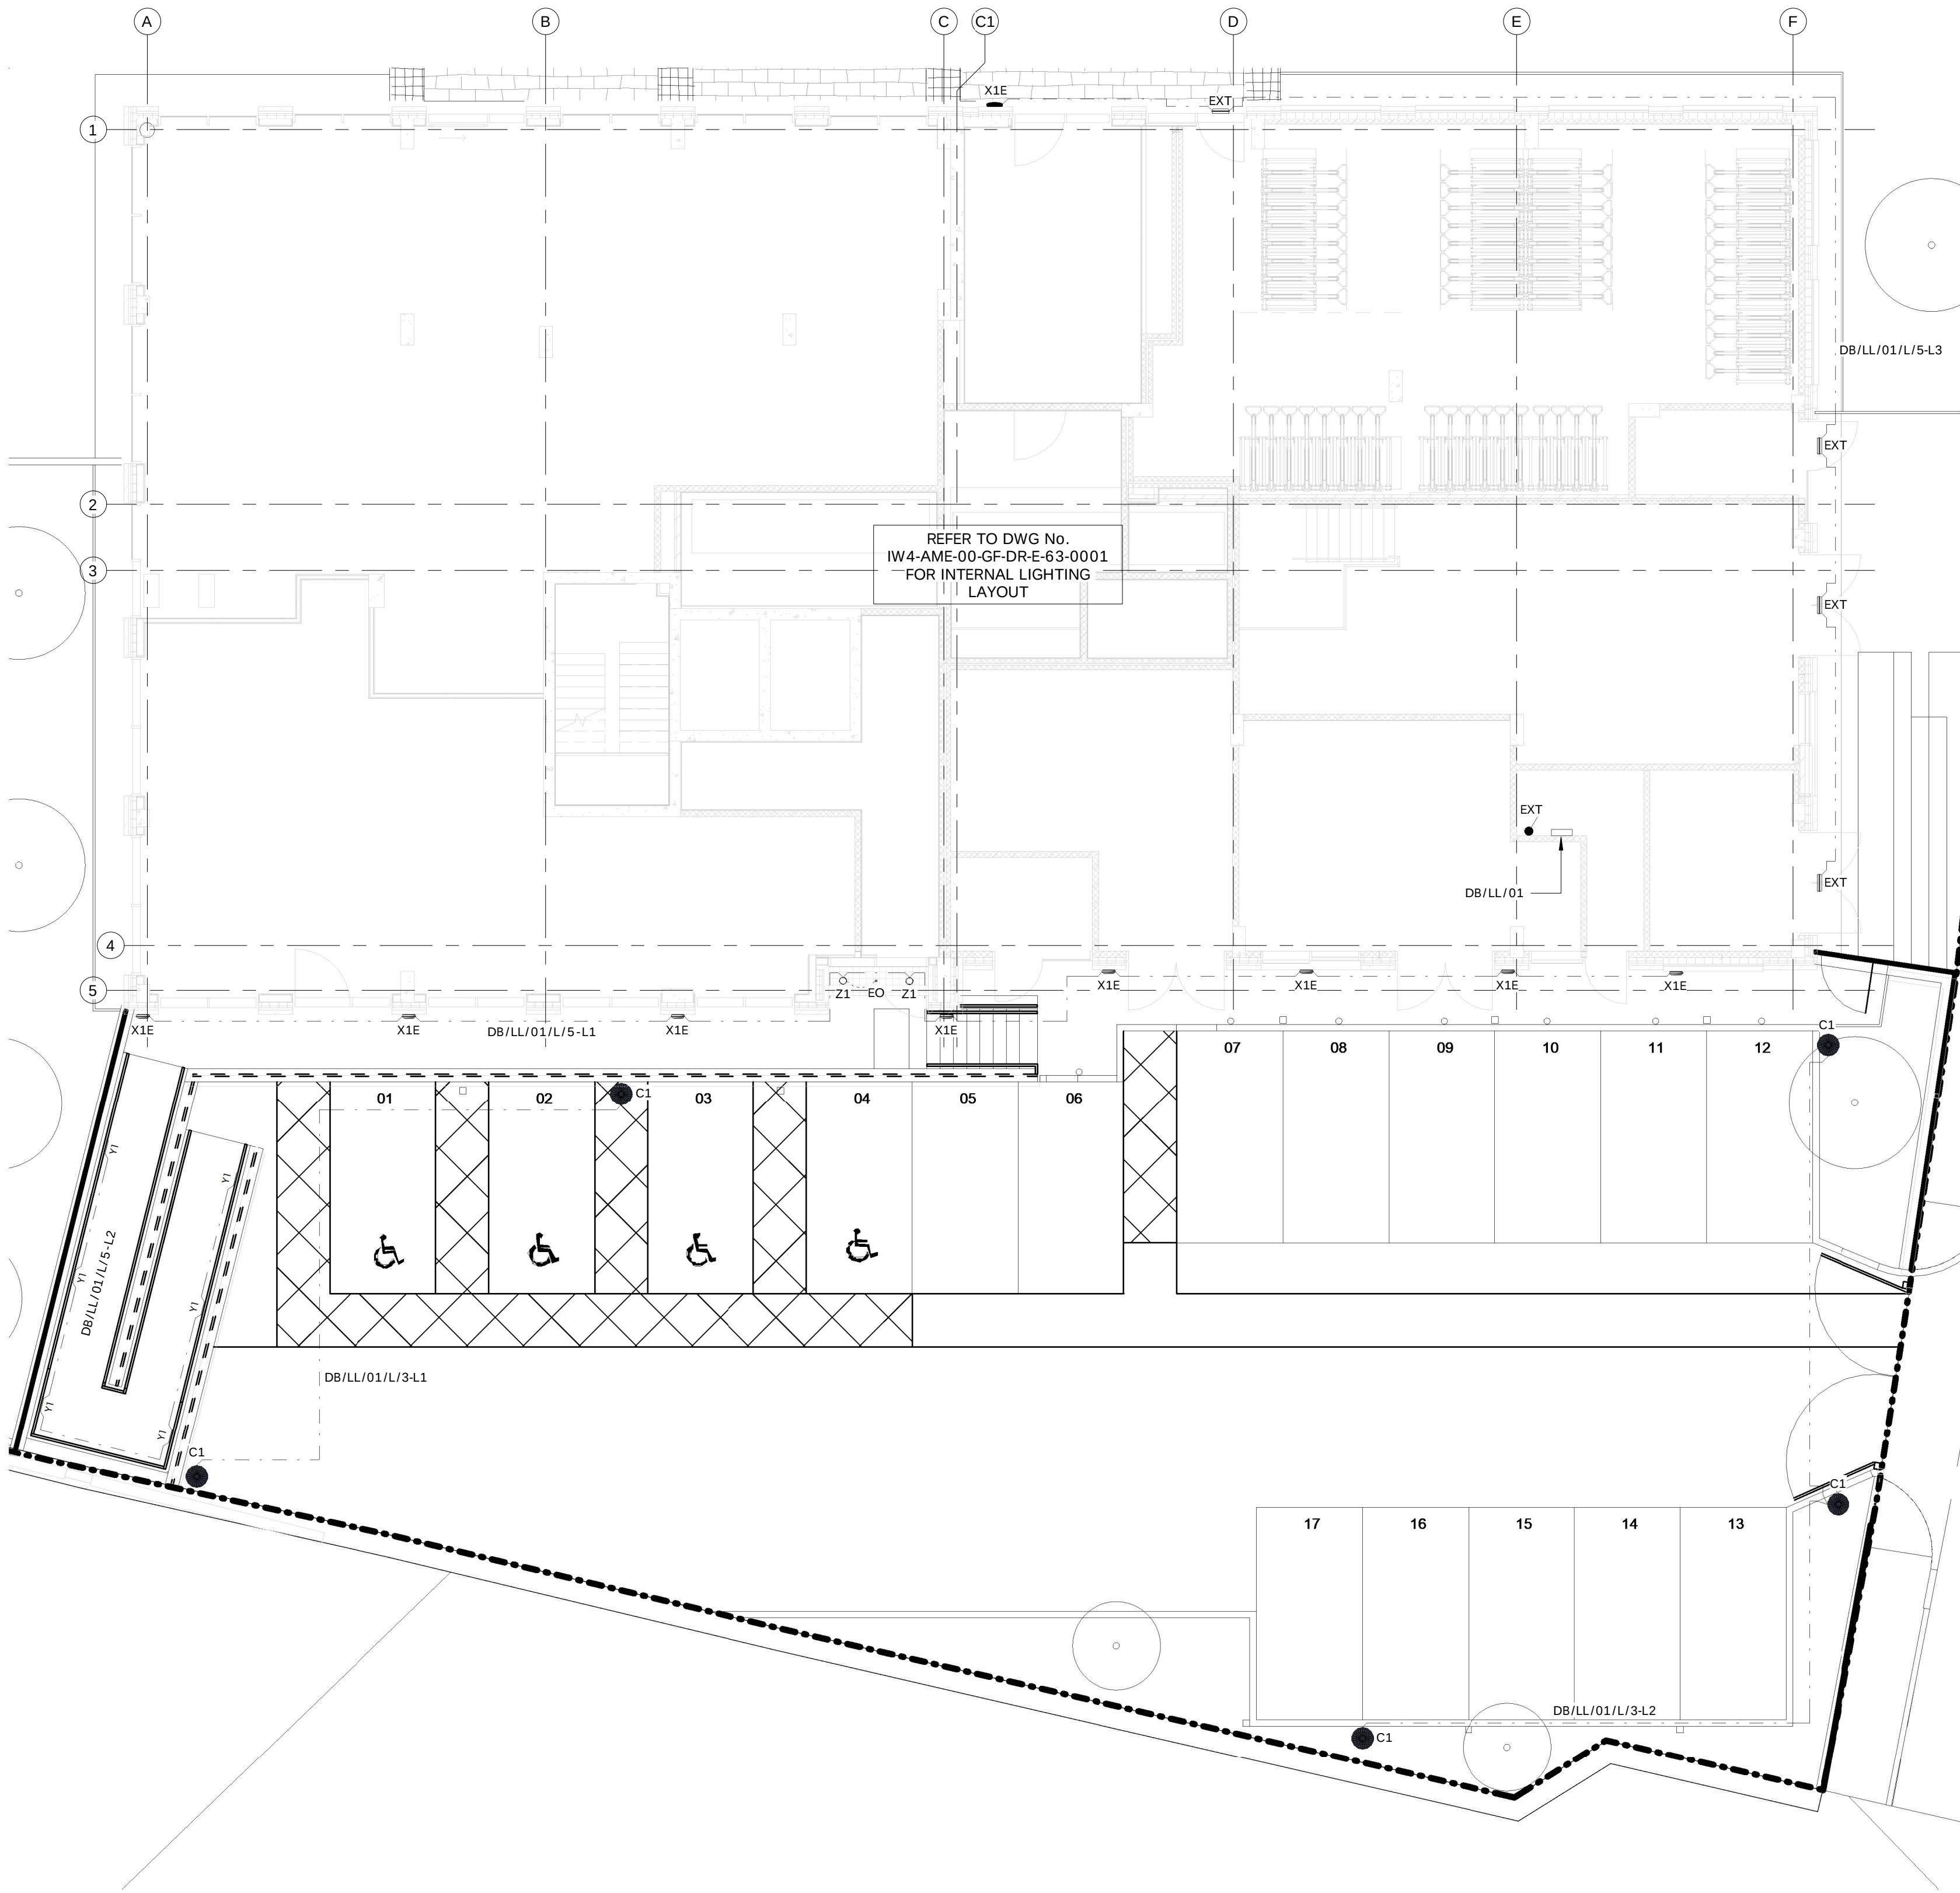


NOTES:

1. ALL DIMENSIONS ARE IN MILLIMETRES UNLESS OTHERWISE INDICATED
2. THIS DRAWING IS TO BE READ IN CONJUNCTION WITH THE EXTERNAL DUCTING LAYOUT DWG No. IW4-AME-00-GF-DR-E-61-0013
3. THIS DRAWING IS TO BE READ IN CONJUNCTION WITH THE EXTERNAL LIGHTING TECHNICAL SUBMITTAL


LEGEND:

- C1 HELIX POST TOP 75W / 8516lm - 3m COLUMN
- PC PHOTOCELL
- EXT / EXTERNAL LIGHTING OVERRIDE SWITCH
- X1E AMENITY LUCCA 27.2W 1947lm WALL LIGHT MOUNTED 2.3m AFFL
- Y1 AMENITY HOLDER OVAL LED BRICKLIGHT 12W / 1082lm
- EXT EMERGENCY BULKHEAD
- Z1 RECESSED LED DOWNLIGHT
- EO LED3/OA - OPEN AREA EMERGENCY RECESSED SPOT LIGHT

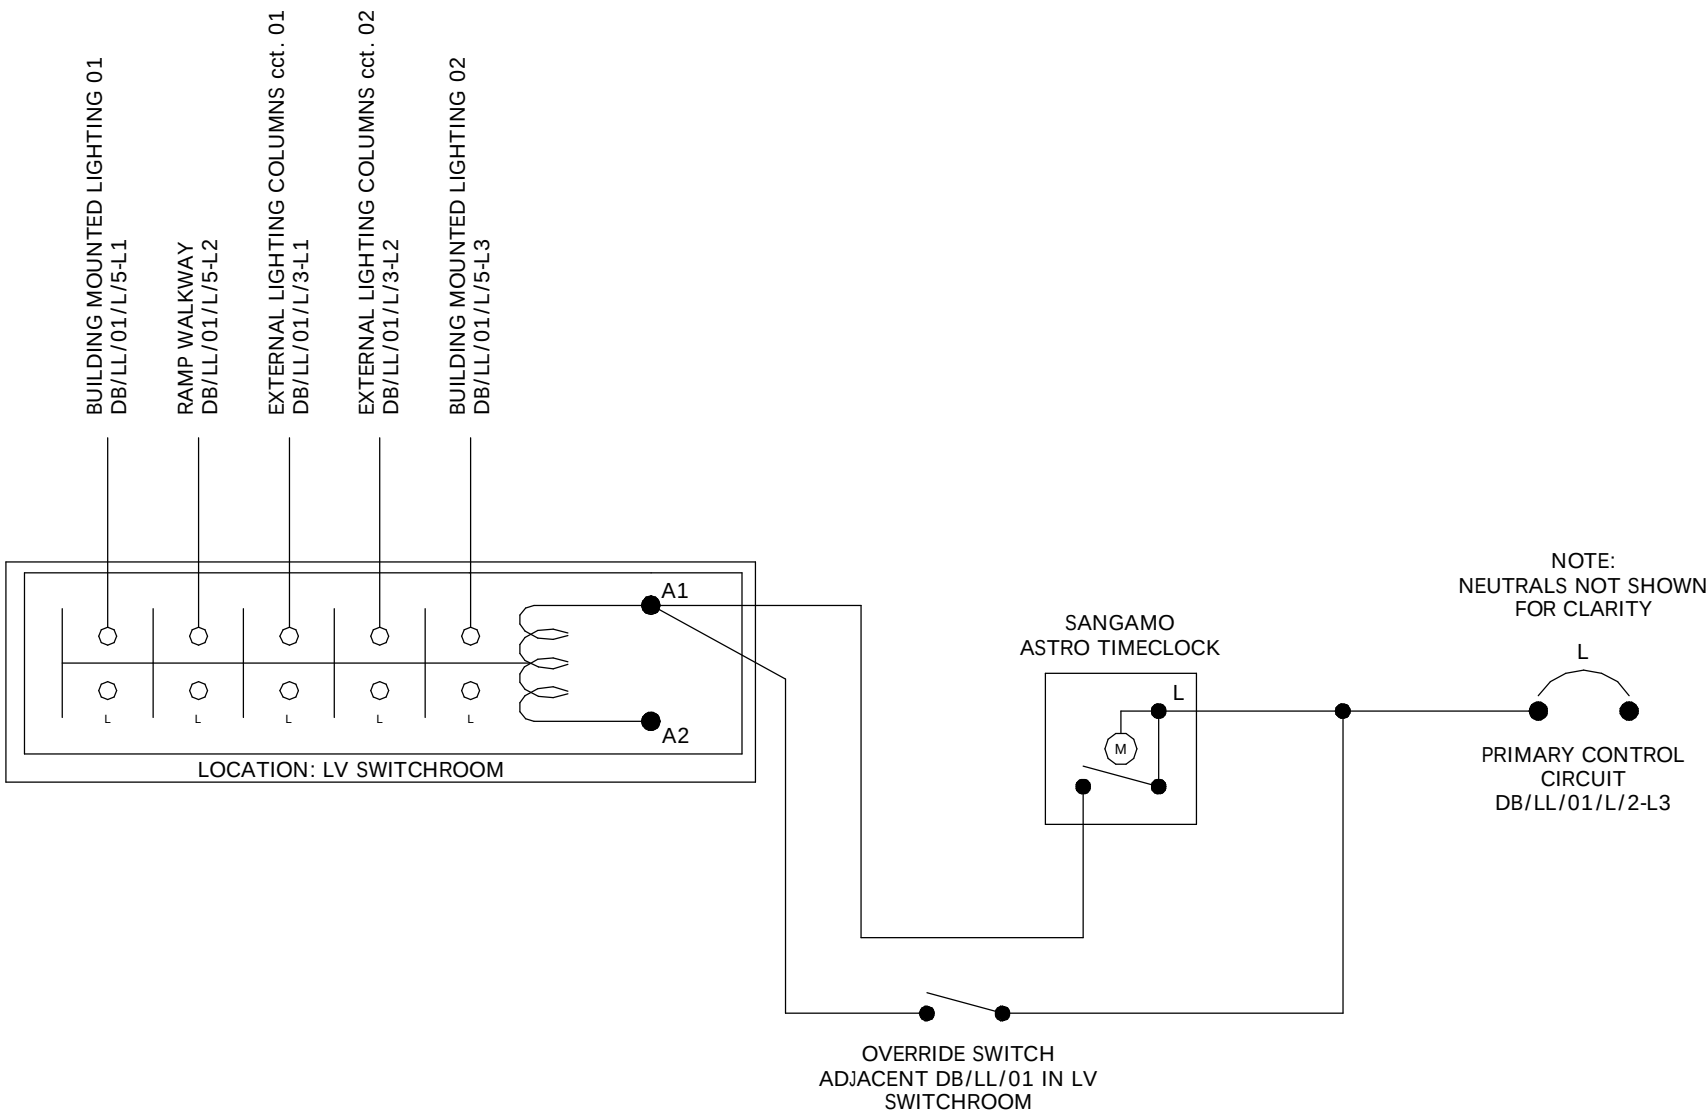

Photocell T/C External Lighting Control Detail
N.T.S.

1 External Lighting Layout
1 : 100

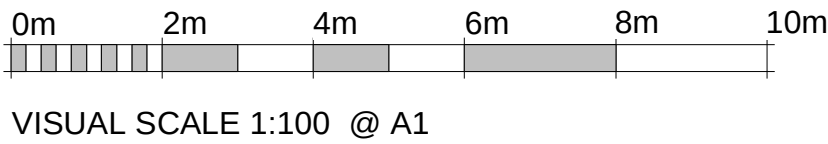

Client	Job Title	Drawing Title	Date	Drawn by	Check by
	Islington Wharf, Phase 4	External Lighting Layout	November 2021	B.C.	B.C.
			Scale @ A1 As indicated	Status S4	Revision C03
			Drawing Number IW4-AME-00-GF-DR-E-63-0006		

ameon
Building Services Engineering

Unit 9-10 Olympic Court, Boardmans Way,
Whitehills Business Park, Blackpool, FY4 5GU
Tel: 01253 760160
E-mail: info@ameon.co.uk