


# SHIP CANAL HOUSE, 9TH FLOOR

## CEILING AND FEATURE LIGHTING LAYOUT

NOTE: ALL DRAWING INFORMATION SUBJECT  
TO SITE SURVEY AND DRAWING UPDATES  
POST STRIP-OUT

This drawing is the property of bluesky Design  
and must not be copied or otherwise  
reproduced. All dimensions must be checked  
on site before commencing work.  
This drawing was produced using AutoCAD 2019.

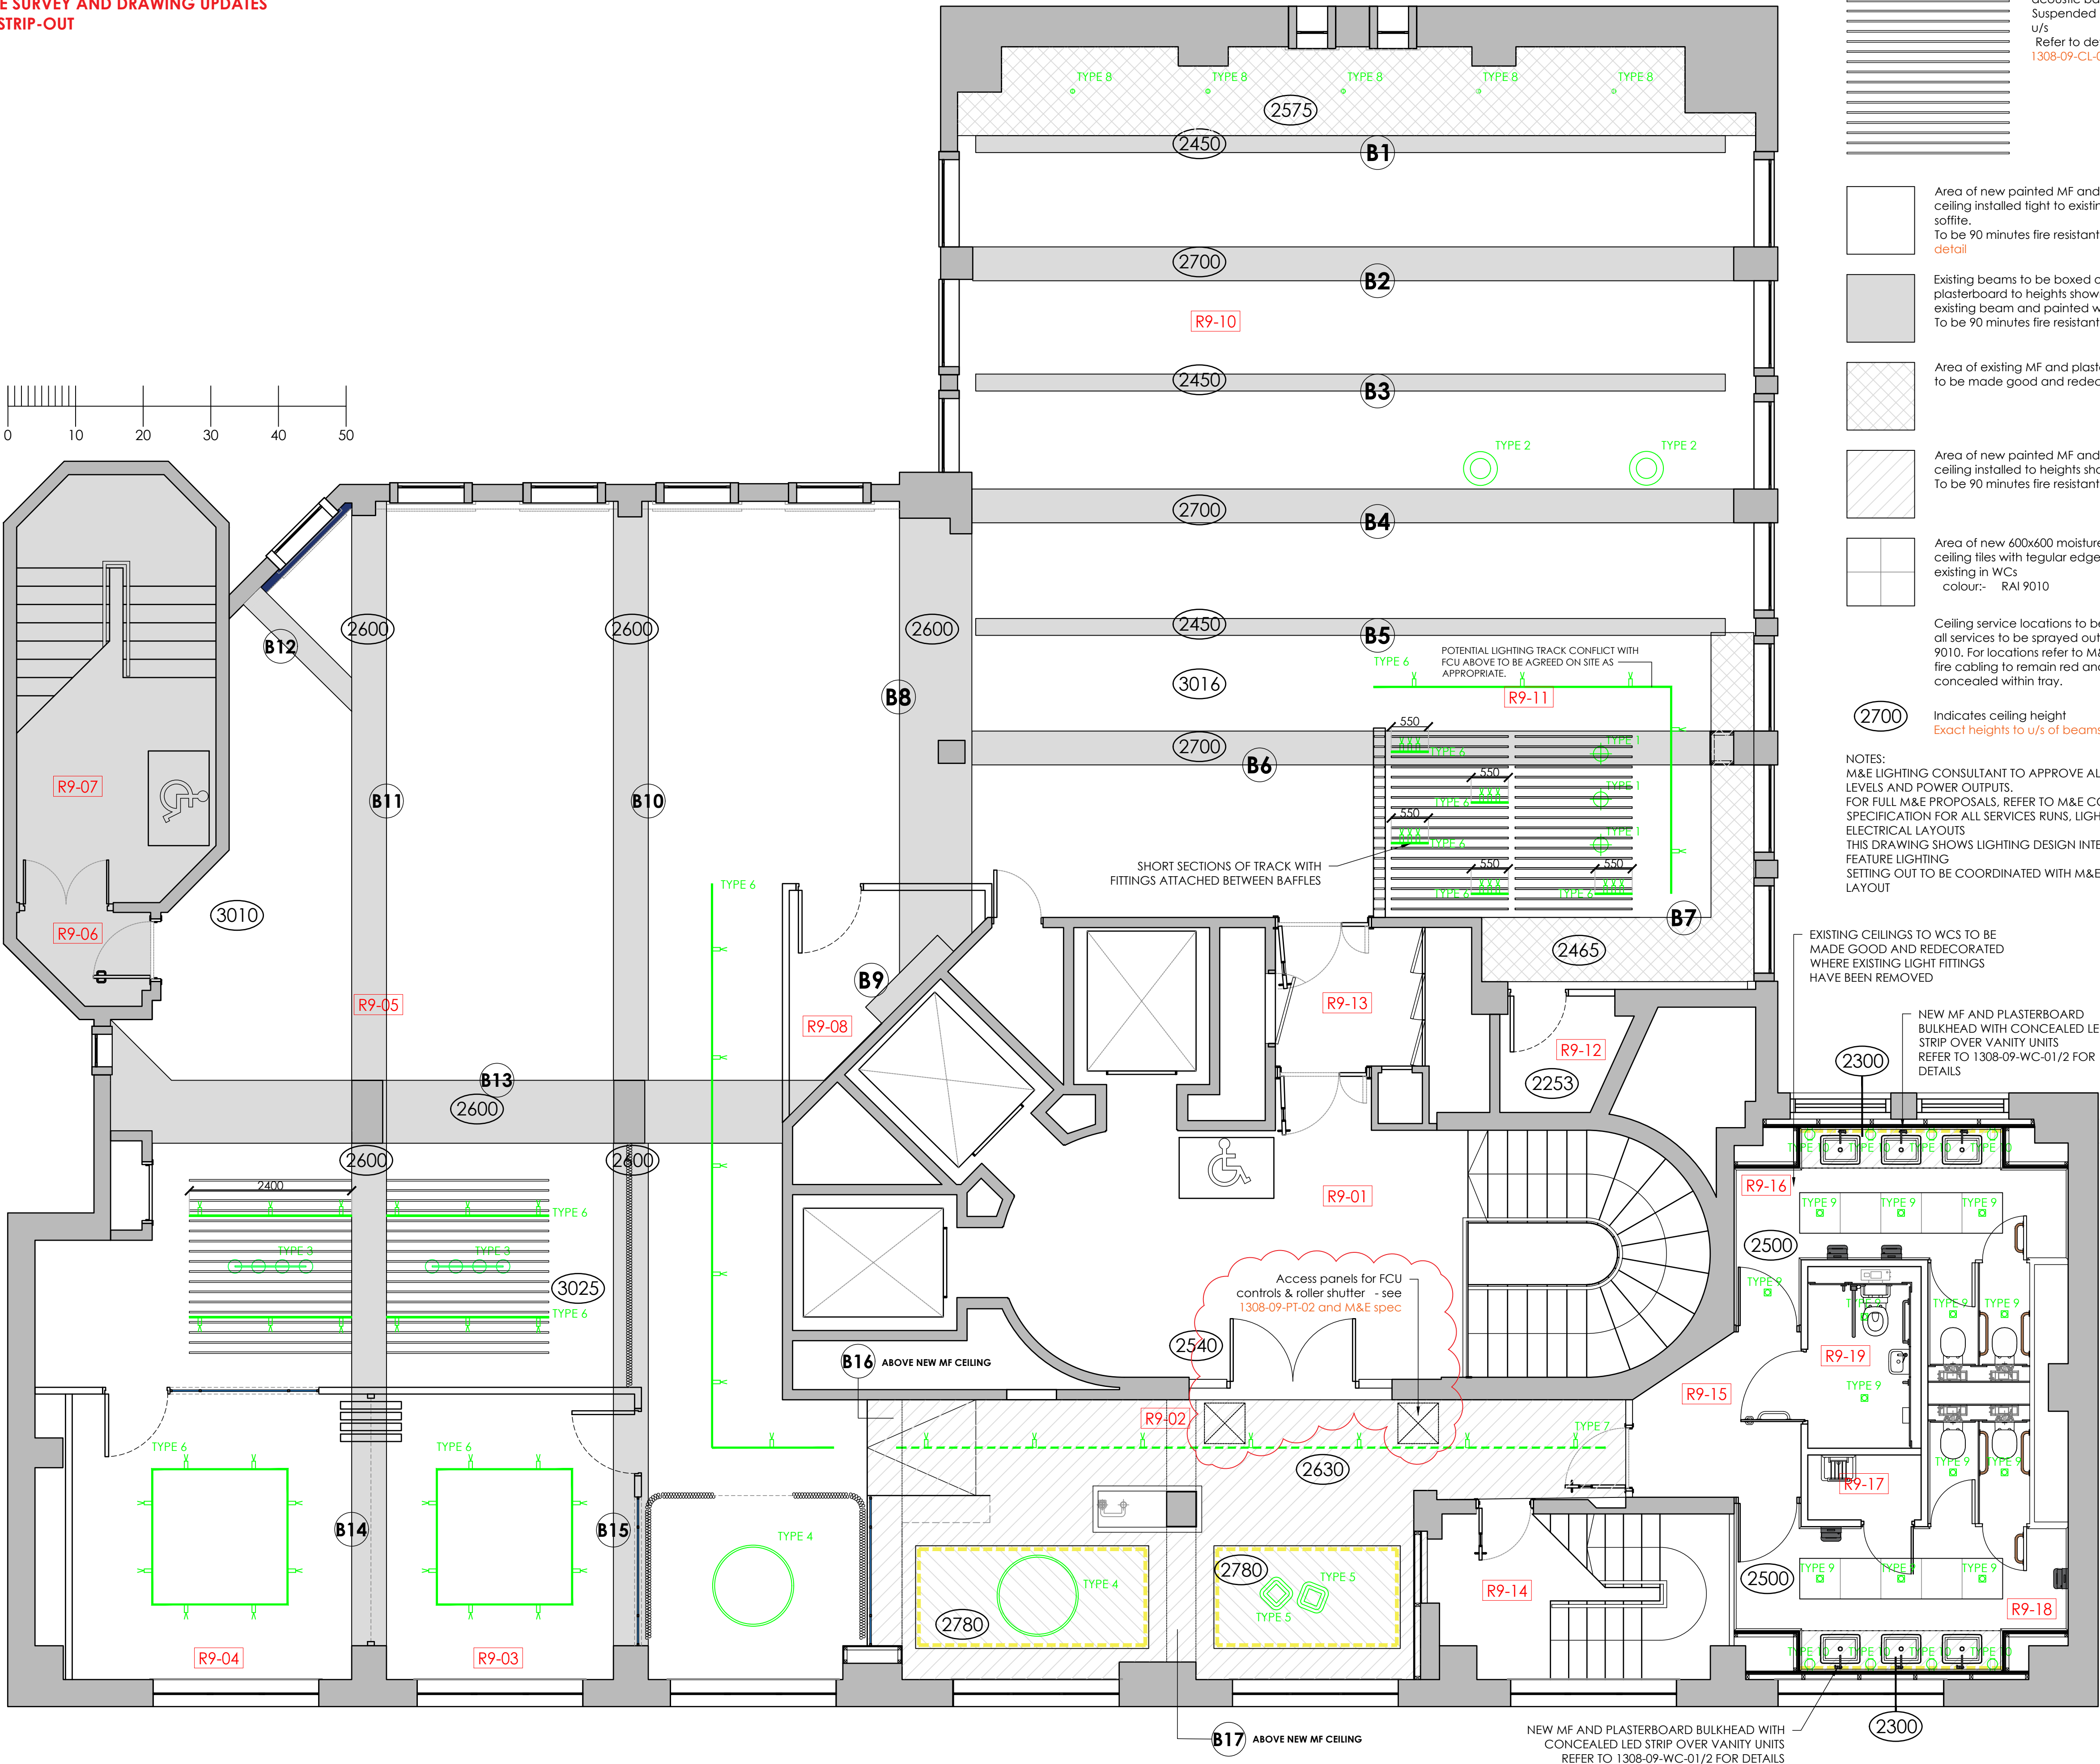

### CEILING FINISHES KEY

- Area of suspended acoustic baffles. Suspended at 2350mm to u/s. Refer to detail drawing 1308-09-CL-02
- Area of new painted MF and plasterboard ceiling installed tight to existing concrete soffit. To be 90 minutes fire resistant. Refer to detail
- Existing beams to be boxed out in plasterboard to heights shown, tight to existing beam and painted white. To be 90 minutes fire resistant. Refer to detail
- Area of existing MF and plasterboard soffit to be made good and redecorated
- Area of new painted MF and plasterboard ceiling installed to heights shown. To be 90 minutes fire resistant. Refer to detail
- Area of new 600x600 moisture resistant ceiling tiles with regular edge to replace existing in WCs colour:- RAI 9010
- Ceiling service locations to be confirmed - all services to be sprayed out white RAI 9010. For locations refer to M&E layouts. Red fire cabling to remain red and be concealed within tray.
- 2700 Indicates ceiling height. Exact heights to u/s of beams to be confirmed

NOTES:  
M&E LIGHTING CONSULTANT TO APPROVE ALL LIGHTING LEVELS AND POWER OUTPUTS.  
FOR FULL M&E PROPOSALS, REFER TO M&E CONSULTANTS SPECIFICATION FOR ALL SERVICES RUNS, LIGHTING & ELECTRICAL LAYOUTS  
THIS DRAWING SHOWS LIGHTING DESIGN INTENT ONLY FOR FEATURE LIGHTING  
SETTING OUT TO BE COORDINATED WITH M&E CONSULTANT'S LAYOUT

EXISTING CEILINGS TO WCS TO BE MADE GOOD AND REDECORATED WHERE EXISTING LIGHT FITTINGS HAVE BEEN REMOVED

NEW MF AND PLASTERBOARD BULKHEAD WITH CONCEALED LED STRIP OVER VANITY UNITS. REFER TO 1308-09-WC-01/2 FOR DETAILS

NEW MF AND PLASTERBOARD BULKHEAD WITH CONCEALED LED STRIP OVER VANITY UNITS. REFER TO 1308-09-WC-01/2 FOR DETAILS

### FEATURE LIGHTING KEY

- TYPE 1 &Tradition JU1 Utzon Pendant Light Brass finish Ø220 x H230mm Suspended at 1800mm to u/s
- TYPE 2 Moooi Random Light II Medium White Ø800mm Suspended at 1800mm to u/s
- TYPE 3 Menu TR Bulb Suspension Frame (4no. shades) Black frame W1250 x D200 x H450mm Suspended at 1800mm to u/s
- TYPE 4 Delta Light Superloop HC Flemish Gold finish Ø1191 x D19 x H50mm Suspended at 1800mm to u/s
- TYPE 5 Delta Light SOIRE SC 4055 E27 Flemish Gold Ø400 x H550mm Suspended at alternate heights 1800/1700mm to u/s
- TYPE 6 Deltalight Suspended 3F Spy 52 Spy Fittings to locations shown Black Track suspended at 2500mm Inline with top of suspended baffles
- TYPE 7 Deltalight Ceiling fixed 3F Spy 52 Clip Spy Fittings to locations shown Black
- TYPE 8 Deltalight SPY 52 CLIP WALLWASH 927 Black
- TYPE 09 Deltalight Entero SQ M fixed downlight Black W100 x D100
- TYPE 10 Deltalight Oano W S - Wall mounted IP54 Black Ø150 x D186mm See 1308-09-WC-01/2 for setting out
- Halo lighting to coffered ceilings Refer to detail 1308-09-CL-02

| Rev | Date     | Description                 | Initials |
|-----|----------|-----------------------------|----------|
| C   | 13.11.22 | Heritage Issue              | FLC      |
| B   | 08.11.22 | Access panel added to R9-02 | FLC      |
| A   | 03.11.22 | Issued for Tender           | FLC      |

|                 |                                          |
|-----------------|------------------------------------------|
| Client:         | GROSVENOR                                |
| Project:        | SHIP CANAL HOUSE                         |
| Address:        | 9TH FLOOR, SHIP CANAL HOUSE, KING STREET |
| Drawing Title:  | CEILING + LIGHTING LAYOUT                |
| Date:           | 21.10.2022                               |
| Project Number: | 1308                                     |
| Scale:          | 1:50@A1                                  |
| Drawn by:       | CB                                       |
| Drawing Number: | 1308-09-CL-01C                           |

bluesky Design  
INTERIORS LIMITED  
Studio 1, 149 High Street, Boston Spa, Leeds LS23 6BH  
Tel: 01937 845 399 www.blueskydesigninteriors.co.uk