

NOTES:
All dimensions must be checked
on site and not scaled from this
drawing.

Ref.	Date	Revisions	By
P01	28.07.21	PRELIMINARY ISSUE	B.W.
P02	05.10.21	CIRCUITING ADDED, CONTROLS UPDATED	R.J.L
C01	08.11.21	CONSTRUCTION ISSUE	MC
C02	01.12.21	LUMINAIRE UPDATE	MC
C03	12.01.22	APARTMENT REFERENCES UPDATED	MC

NOTES


- TYPE F1 AND F2 WALL MOUNTED LUMINAIRE CONTROLLED VIA MANUAL SWITCH LOCATED IN THE ASSOCIATED APARTMENT.
- EXTERNAL LIGHTING CONTROLLED BY TIMECLOCK / PHOTOCELL WITH MANUAL OVERRIDE. REFER TO EXTERNAL LIGHTING CONTROLS WIRING SCHEMATIC AS01-AME-61-XX-DR-E-0012 FOR DETAILS OF TIMECLOCK, PHOTOCELL AND PRESENCE DETECTION REQUIREMENTS.
- POSITIONS OF ACCESSORIES SHOWN ARE APPROXIMATE UNLESS SPECIFIC DIMENSIONS ARE INDICATED AND / OR ARCHITECTAL SETTING OUT INFORMATION HAS BEEN MADE AVAILABLE.

LIGHTING LEGEND

- ZMP - CIRCULAR BULKHEAD
- WZP - IP65 SURFACE LINEAR - WPZ/4/3580/4
- WZP - IP65 SURFACE LINEAR - WPZ/4/6220/4
- ASTORIA LED - RECESSED SPOT
- LDB - IP65 CIRCULAR BULKHEAD
- TR2 SURFACE -
- TARA S -
- TRAXON - IP65 LONG RANGE EXIT SIGN
- AX - EMERGENCY BULKHEAD
- LUNA - EMERGENCY FLOOD LIGHT
- EXIT - WALL MOUTED EXIT SIGN
- LDS1 - EXIT SIGN
- HYDRO EXIT - IP65 EXIT SIGN
- LDL 1037 - IP54 SQUARE UP/DOWN WALL LIGHT (BLACK)
- LDL 1037 - IP54 SQUARE UP/DOWN WALL LIGHT
- ATLANTA S - IP67 IN GROUND UP LIGHT
- TBC - IP67 ELV 'SPIKE' UP LIGHT
- TUBE UP-DOWN - IP65 UP/DOWN WALL LIGHT
- BOL/LED/2 - IP65 BOLLARD
- LED TAPE - IP67 LED TAPE IN EXTRUSION
- GRACE - TRACK MOUNTED SPOTLIGHTS
- DENOTES EMERGENCY FITTING


LIGHTING CONTROLS LEGEND

- LONG RANGE WALL MOUNTED MICROWAVE PRESENCE DETECTOR
- SURFACE MOUNTED PIR
- 1 GANG 1 WAY LIGHT SWITCH
- 1 GANG 2 WAY LIGHT SWITCH
- EMERGENCY LIGHTING KEY SWITCH
- SURFACE MOUNTED IP67 ADAPTABLE BOX (100X100X50mm)

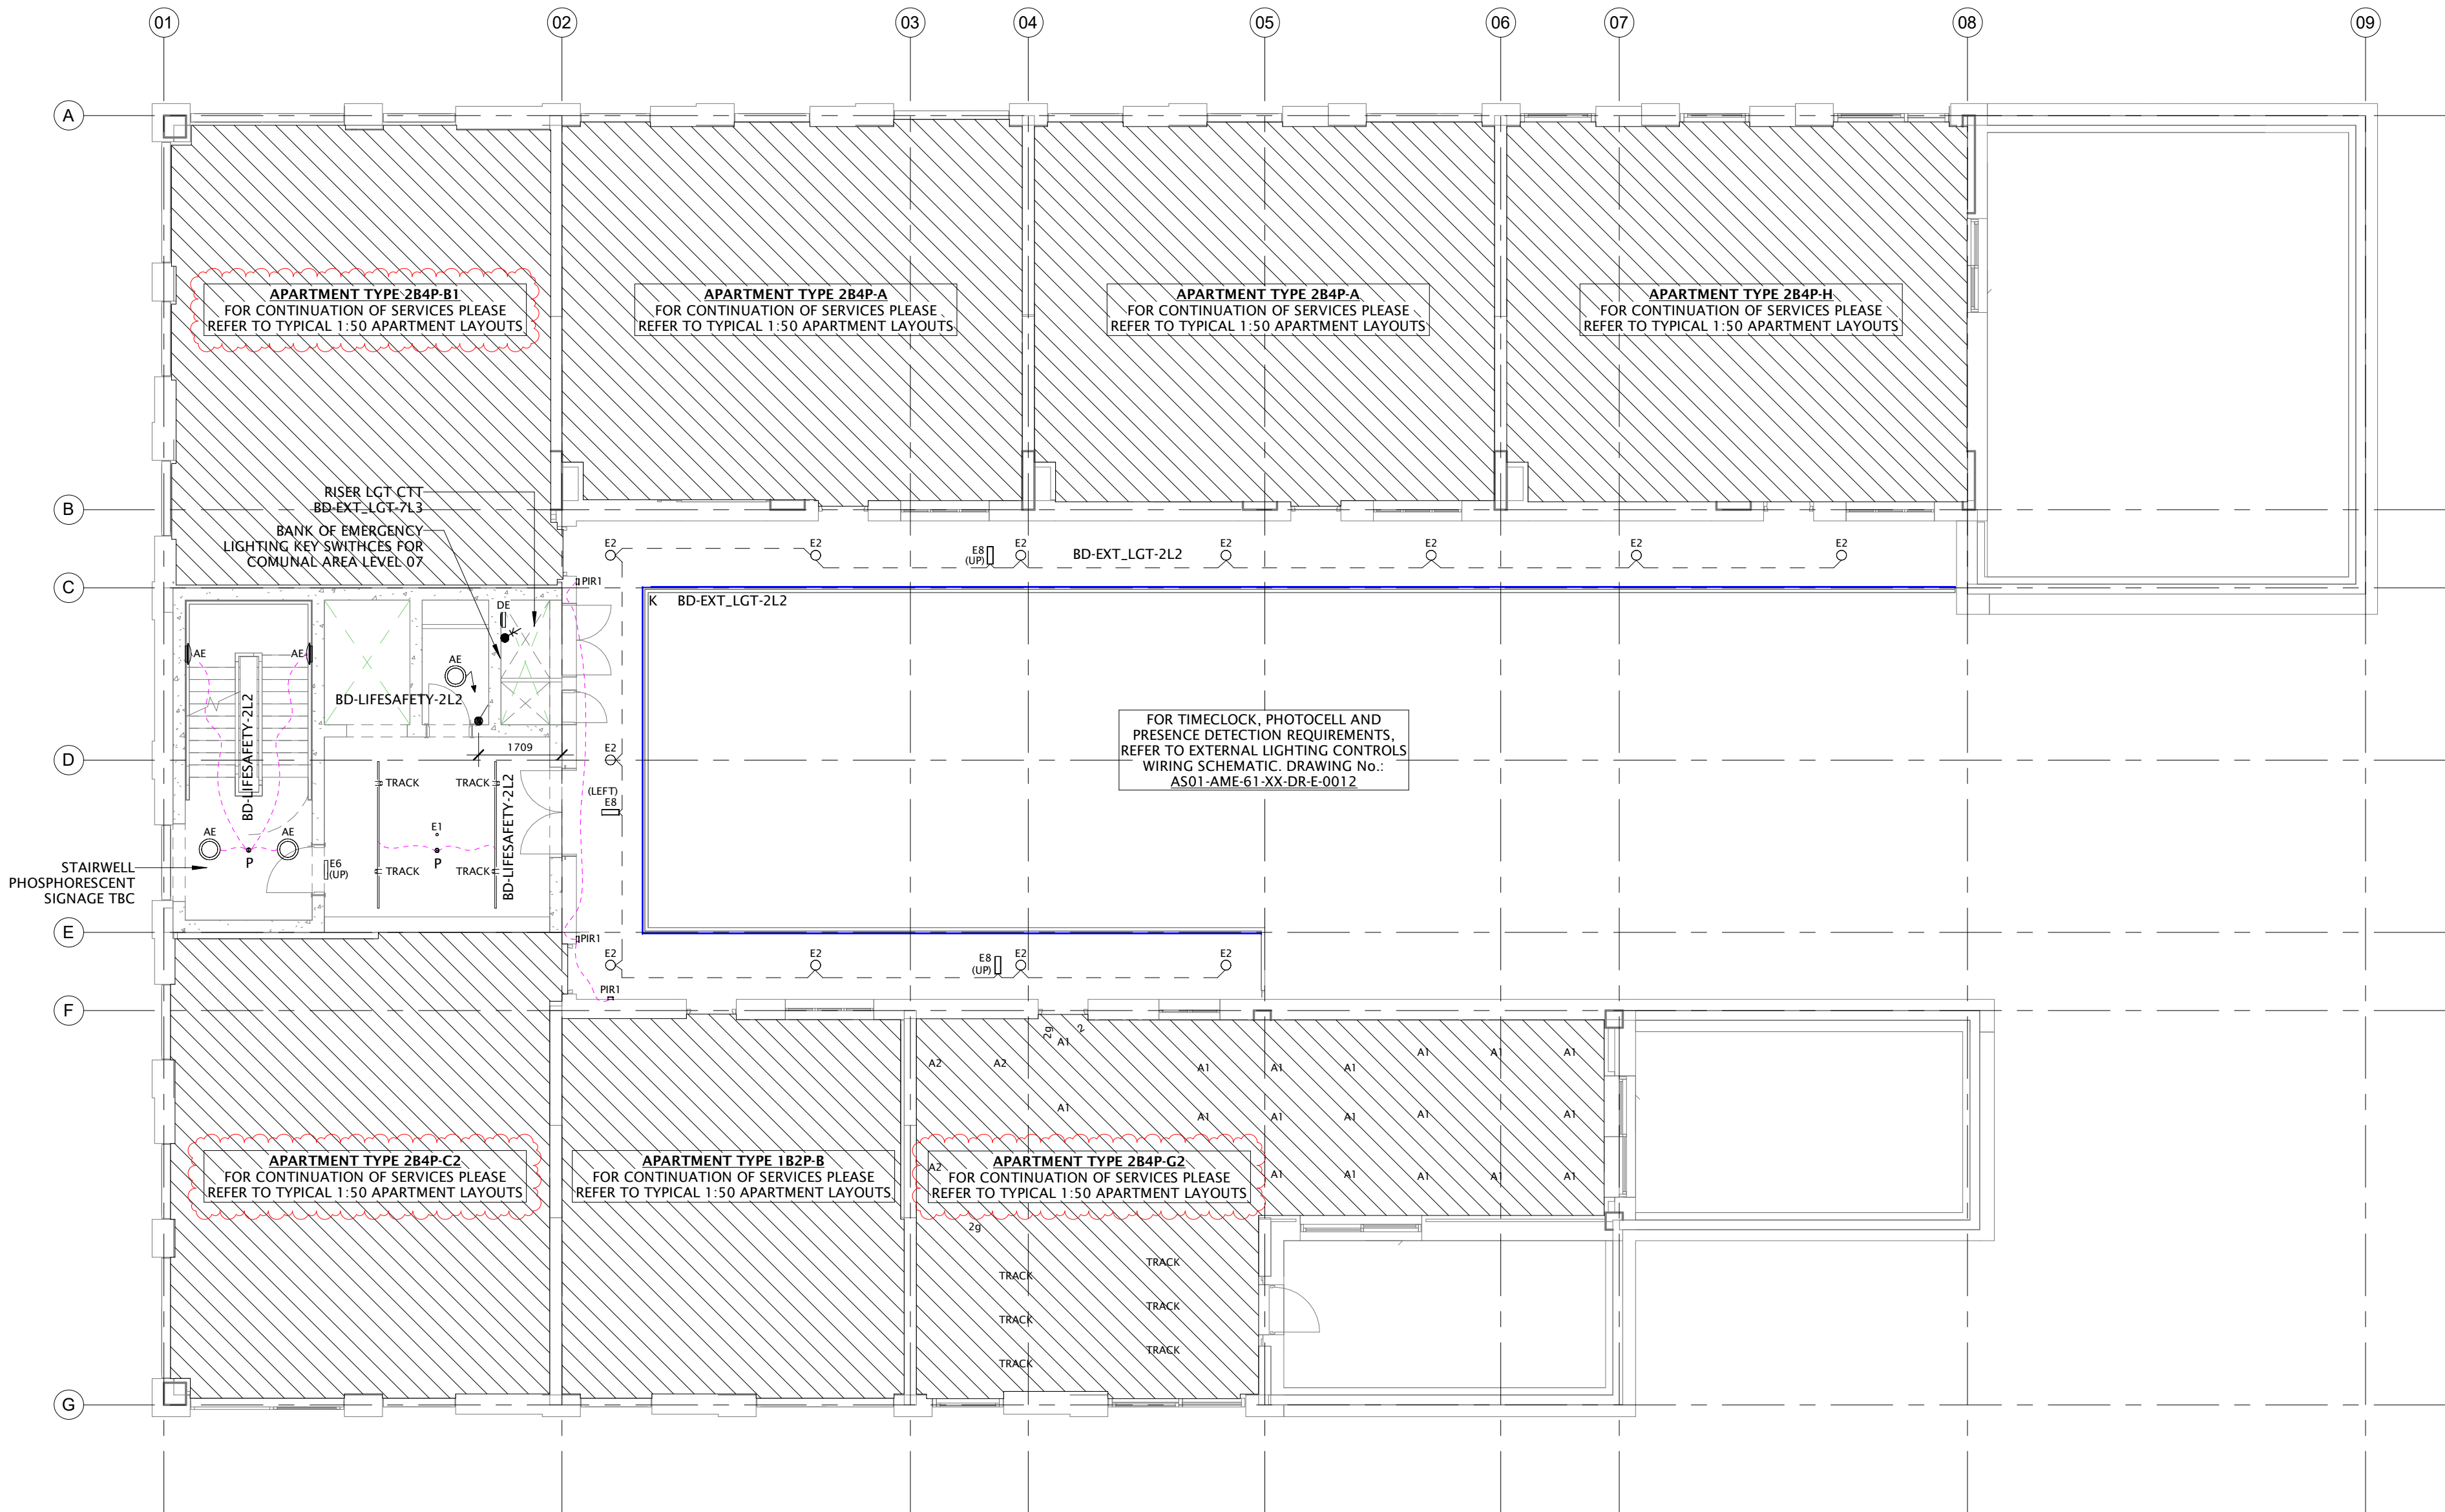

Level 07 - Lighting Layout

 1 : 100



VISUAL SCALE 1:100 @ A1

CONSTRUCTION



Building Services Engineering

Unit 9-10 Olympic Court, Boardmans Way,
Whitehills Business Park, Blackpool, FY4 5GU
Tel: 01253 760160
E-mail: info@ameon.co.uk

Client	Job Title	Drawing Title	Date	Scale @ A1	Drawn by	Check by
DEX Construction	Addington Street	Seventh Floor - Lighting, Emergency Lighting & Controls Layout	JUNE 2021	1 : 100	BW	RL
			Drawing Number	Revision		
			AS01-AME-63-07-DR-E-0001	C03		