


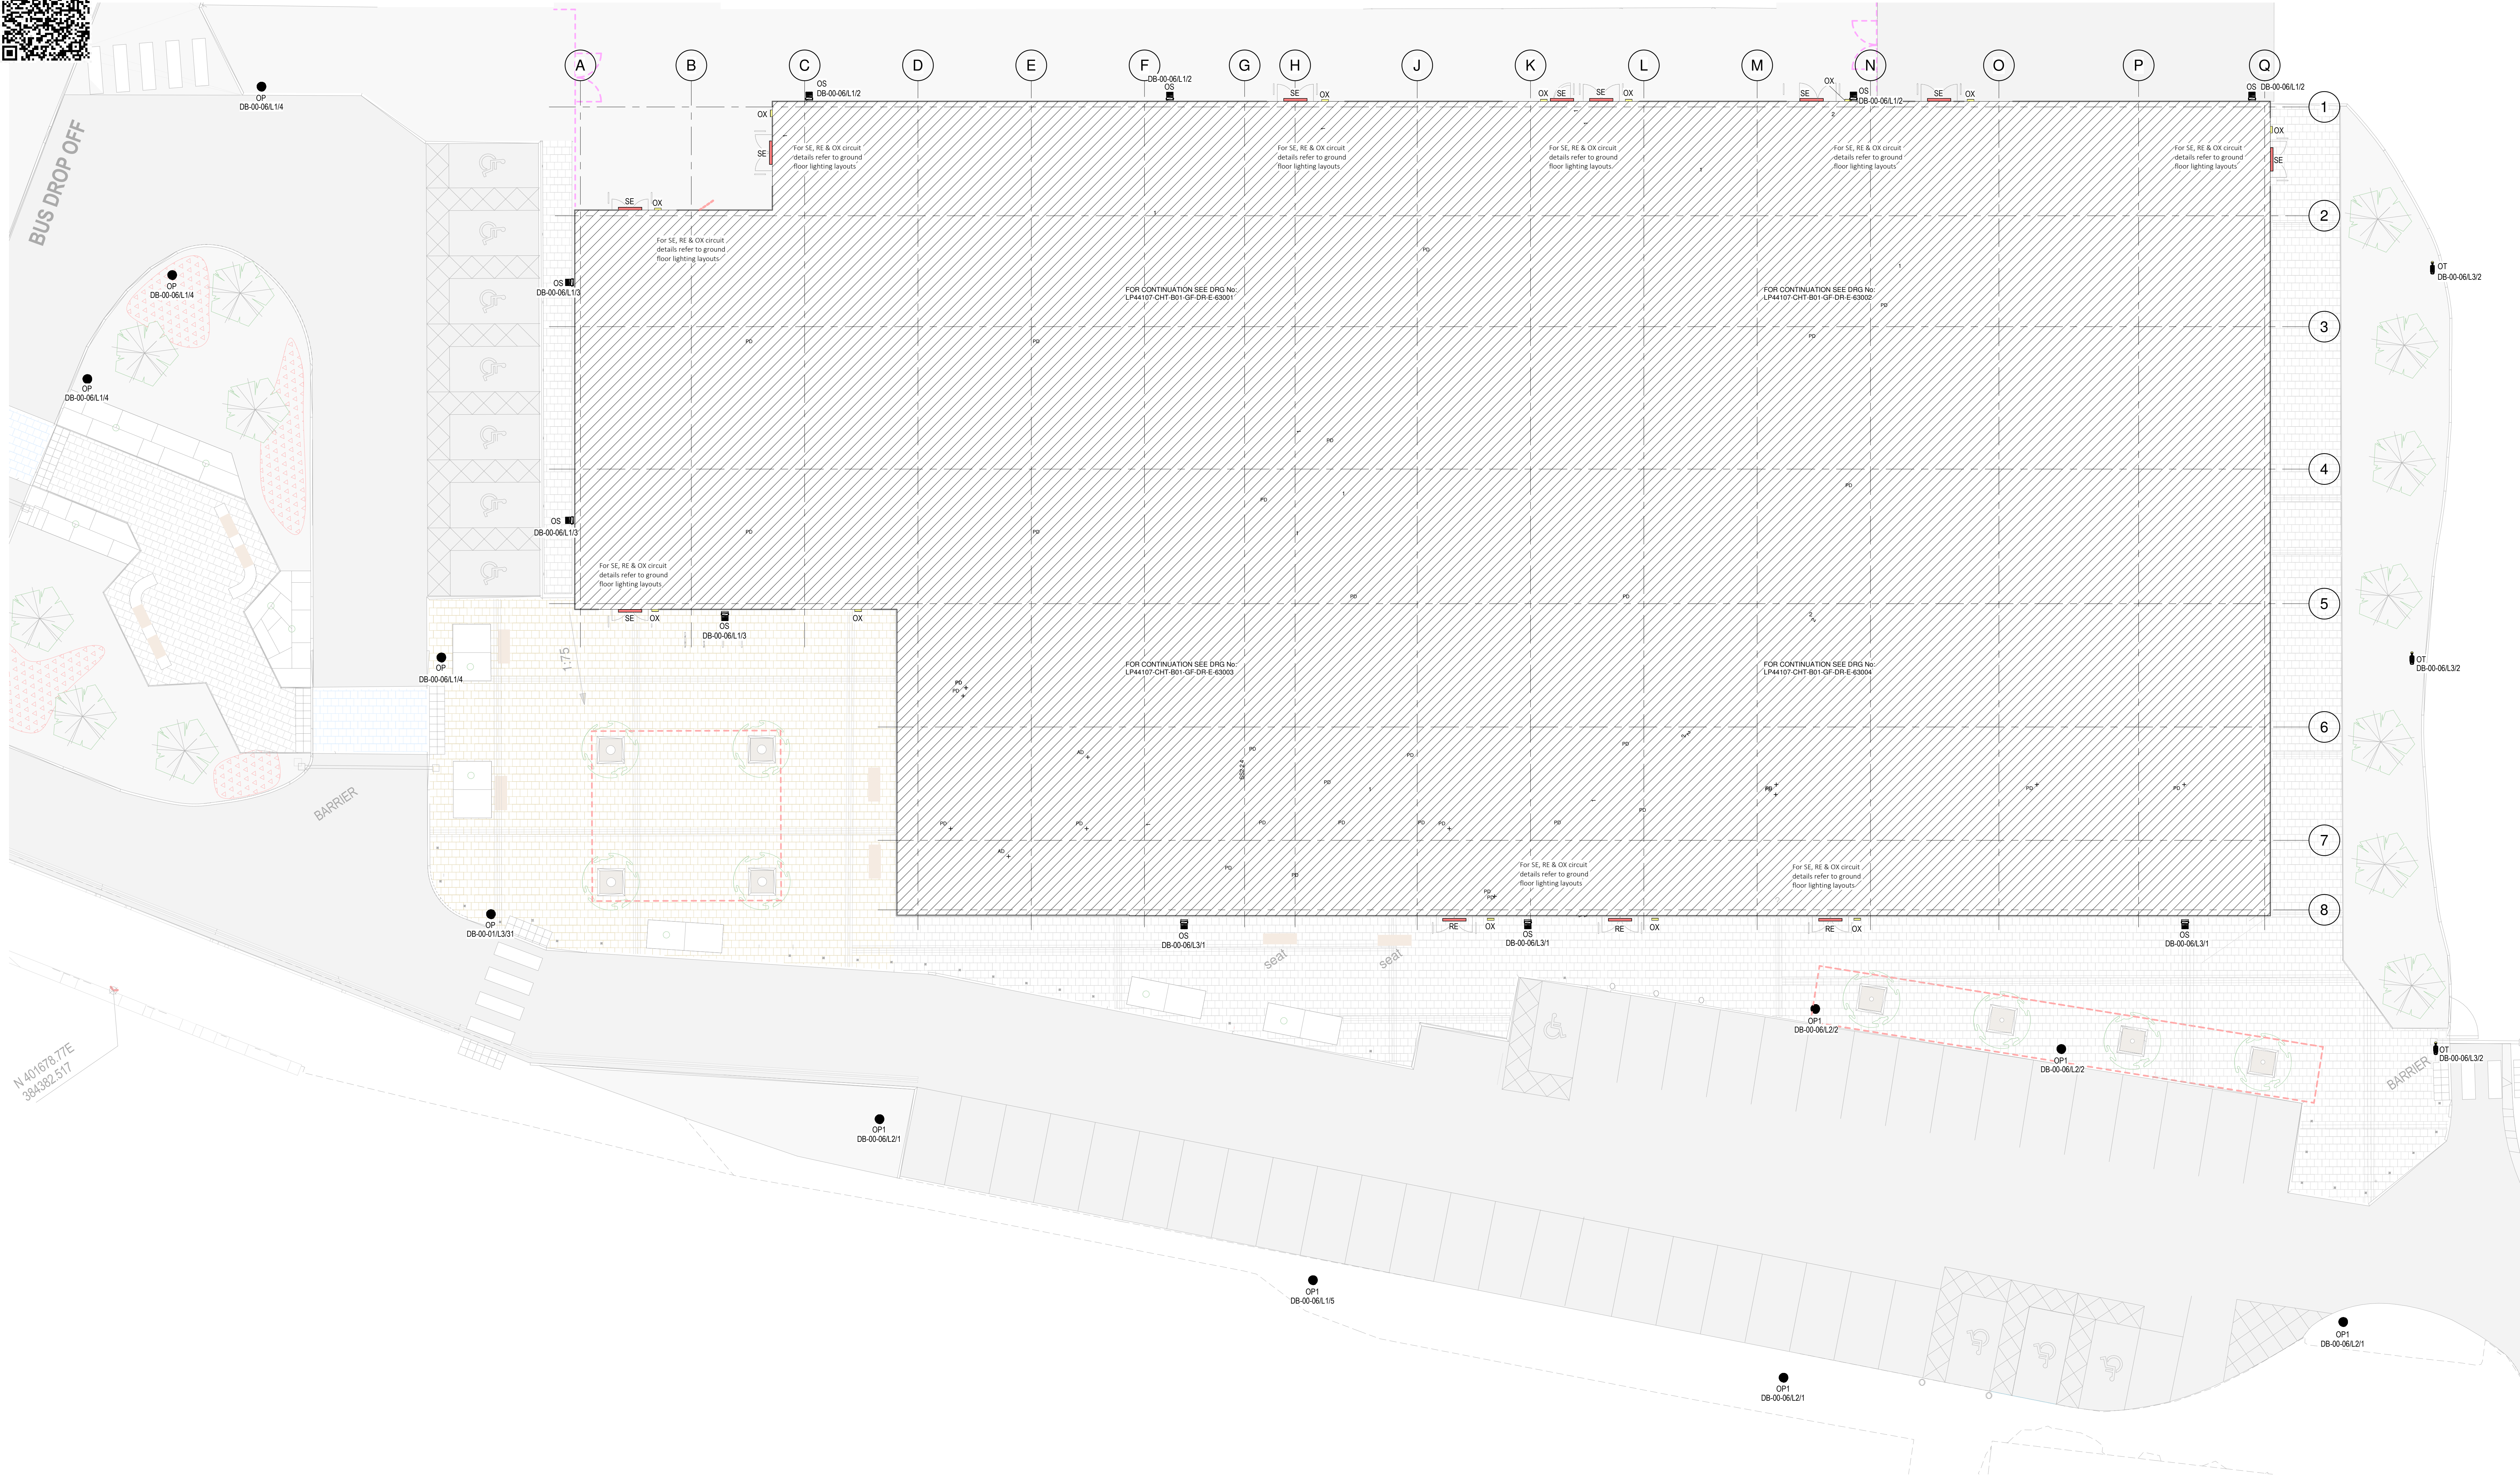

1 CFL - Ground Floor - Lighting External
1 : 125

This drawing is the copyright of Crown House Technologies Ltd. and must not be copied or reproduced in part or in whole without their permission.
COMPUTER AIDED DRAWING - AVOID MANUAL MODIFICATION
This drawing must not be issued. All dimensions to be checked on site.

DYNAMIC RISK ASSESSMENT
PPE
Is it Fit for purpose, appropriate for task, in good condition
HOUSEKEEPING
Before you start your area? Clean and tidy, free from trip hazards, with all waste in appropriate bins, has a safe route for 110V trailing leads.
Before you finish ensure your area has no hazards for the next shift

TOOLS & EQUIPMENT
Are they? In good working order, PAT tested, correct for task

WORK
Do you? Understand your scope of works, have the required skills to carry out tasks, have a Method Statement and Risk Assessment to cover tasks, need to work at height? If so - you will require a Permit to Work, have any abnormal lifts or movements - If so - is there a Lifting Plan.
If you are unsure of anything, or you are not happy that the work you are proposing is to be done, then please stop, and consult your Supervisor or Team Leader, and do not carry out the work.

Site Plan

LEGEND

NOTES:

1. THE INFORMATION SHOWN ON THIS DRAWING IS BASED UPON THE MODEL AND DRAWINGS ISSUED BY THE ARCHITECT ON THE DATES AS INDICATED BELOW.
2. THIS DRAWING SHALL BE READ IN CONJUNCTION WITH ALL RELEVANT ENGINEERS' AND ARCHITECT'S DRAWINGS, REPORTS, LUMINAIRE SCHEDULE AND SPECIFICATIONS.
3. ALL DIMENSIONS ARE IN MILLIMETRES UNLESS OTHERWISE STATED.
4. THIS IS NOT A COORDINATED WORKING OR INSTALLATION DRAWING.
5. THE PURPOSE OF THIS DRAWING IS TO PROVIDE A LEVEL OF DETAIL SUITABLE FOR BSRIA PRO-FORMA 4A - TECHNICAL DESIGN.
6. FINAL SETTING OUT INFORMATION WILL BE PROVIDED BY THE MEP SUBCONTRACTOR IN LIAISON WITH THE ARCHITECT.
7. LUMINAIRES WITH PREFIX OR SUFFIX 'E' ARE EMERGENCY LUMINAIRES.
8. CONTRACTOR TO COORDINATE LIGHTING ARRANGEMENT WITH FINAL PLANT & SERVER ROOM LAYOUT.
9. ONGOING COORDINATION OF EMERGENCY LIGHTING DESIGN WITH FIRE STATIST ESCAPE ROUTES, MUSTER POINTS, CRASH BARRIERS, CALL POINTS, FIREFIGHTING EQUIPMENT, FIRST AID POINTS, HAZARDOUS AREAS, NON-ILLUMINATED SIGNAGE E.T.C. (WILL BE THE RESPONSIBILITY OF THE CONTRACTOR OR THEIR NOMINATED REPRESENTATIVE).
10. ALL LIFT LIGHTING TO BE PROVIDED BY LIFT MANUFACTURER.
11. DIMMABLE LUMINAIRES ARE IDENTIFIED WITH A '+' SYMBOL.
12. 'E' LUMINAIRES WHICH ARE USED IN THE CORRIDOR AREAS ARE TO HAVE SECONDARY FIXING / DROP RODS TO SUPPORT THE LUMINAIRE IN THE EVENT OF CEILING COLLAPSING.

For luminaire schedule refer to document
LP44107-BDP-XXX-XX-SH-E-96009

P01	18/02/21	S3 - For Review and Comment	CFL	GL
Rev	Date	Revision	Drm	Chk

Status:

S3 - For Review and Comment

Project:

Abraham Moss Leisure Centre

Drawing Title:

External Lighting Layout

MANCHESTER CITY COUNCIL

Manchester City Council
Town Hall Extension
Albert Square
Manchester
M60 2LA

Architect:

Ellis Williams Architects
Wellfield Chester Road
Preston Brook
WAT 3BA

Consulting Engineer:

BDP
11 Ducie Street
PO Box 65
Piccadilly Basin
Manchester
M60 3JA

Manchester Office

City Gate
Cross Street, Sale,
Manchester,
M15 5QU, United Kingdom
Tel: +44 (0)161 227 6000
Fax: +44 (0)161 227 6199
www.crownhouse.com

Crown House

CAD File Name:

Department: CFL
Project: LP44107
Scale: As Indicated
Original Drawing Size: A0

Coordinated: CFL
Detailed: CFL
Checked: SH
Approved: JT
Date: 22/12/21

Drawing Number:

LP44107-CHT-B01-XX-DR-E-63050

Rev:

P01