


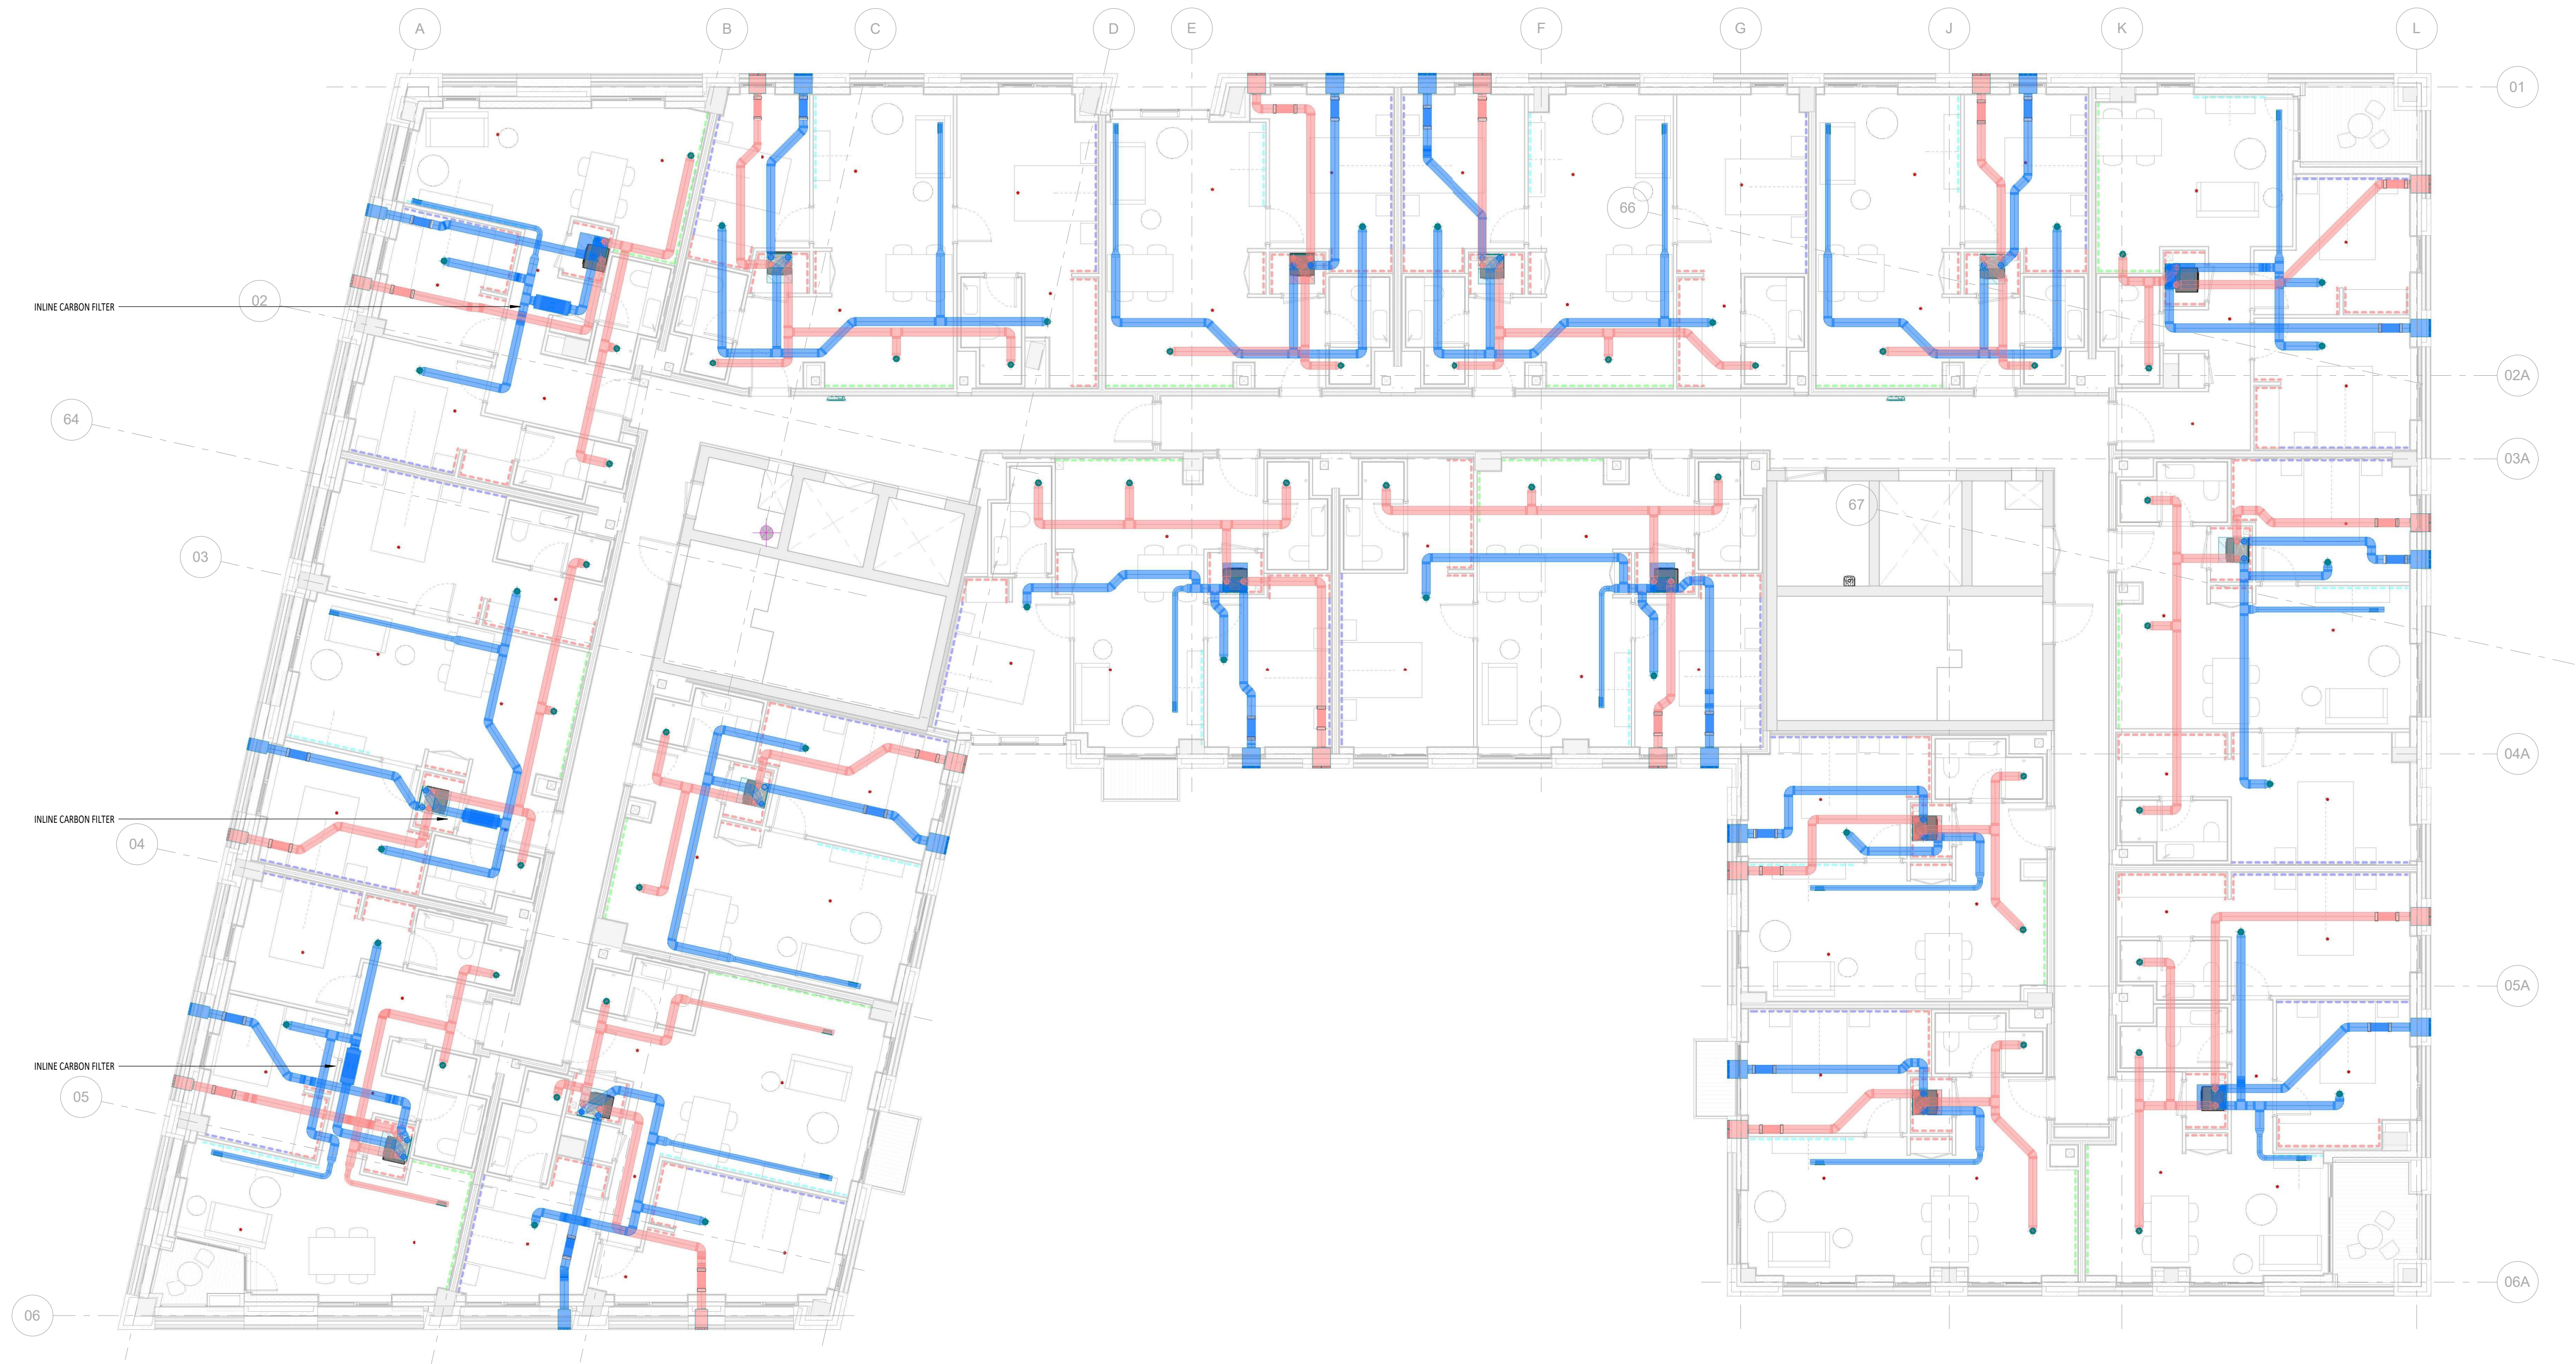

1 01-06 - Ventilation
1:100

GENERAL NOTES:

1. THIS DRAWING IS COPYRIGHT AND SHALL NOT BE REPRODUCED WITHOUT PERMISSION
2. THIS DRAWING IS TO BE READ IN CONJUNCTION WITH ALL OTHER DISCIPLINES, DRAWINGS, SCHEDULES AND SPECIFICATIONS, LEGENDS AND STANDARD DETAILS
3. DIMENSIONS GOVERN ON ALL DRAWINGS AND DETAILS. SHOULD ANY DISCREPANCIES BE FOUND ON THIS DRAWING AND ANY ASSOCIATED DRAWINGS OR SPECIFICATIONS, THIS SHOULD BE BROUGHT TO THE ATTENTION OF BRENTWOOD DESIGN IMMEDIATELY
4. CONTRACTORS MUST CHECK AND VERIFY ALL INFORMATION / DIMENSIONS / LEVELS IN CONJUNCTION WITH ALL RELEVANT DRAWINGS AND ACTUAL SITE CONDITIONS BEFORE COMPLETING ANY MANUFACTURING / INSTALLATION DRAWINGS OR COMMENCING SITE INSTALLATION WORK
5. DO NOT SCALE FROM THIS DRAWING

VENTILATION LEGEND

- SUPPLY AIR GRILLE - SG
- EXTRACT AIR GRILLE - EG
- ATTENUATOR SILENCER - SIL-00-00
- INLINE CARBON FILTER - FIL-00-00
- MECHANICAL VENTILATION HEAT RECOVERY UNIT - MVHR-00-00

VENTILATION LEGEND

- SUPPLY DUCT
- FIRE RATED SUPPLY DUCT
- EXTRACT DUCT
- (S) SUPPLY DUCT
- (E) EXTRACT DUCT
- VCD VOLUME CONTROL DAMPER
- FD FIRE DAMPER
- FCU FAN COIL UNIT
- HRU HEAT RECOVERY UNIT
- EF EXTRACT FAN
- SF SUPPLY FAN
- SD SUPPLY DIFFUSER
- EG EXTRACT GRILLE
- ATT ATTENUATOR

P01	08/09/22	PRELIMINARY ISSUE	SP	RD
Rev	Date	Description	Dwn	Chk

BRENTWOOD
CONSULTING ENGINEERS

First Floor, 21 Hornbeam Square South, Harncliffe, HG2 8NH
T: 01432 975803 W: www.brentwoodgroup.co.uk
&
Jacton House, 24 Hood Street, Manchester, M4 6WS
T: 0161 569 4620

CLIENT

Walker
Integrated Building Services Ltd

PROJECT
ANCOATS GARDENS

DRAWING TITLE
VENTILATION LAYOUT
LEVELS 01-06

DRAWING STATUS
PRELIMINARY

DRAWN BY SP	CHEK BY RD	DATE 08/09/22	SCALE As indicated@A1
DRAWING NO. EC2016-BGL-ZZ-DR-M-003	REVISION P01		