



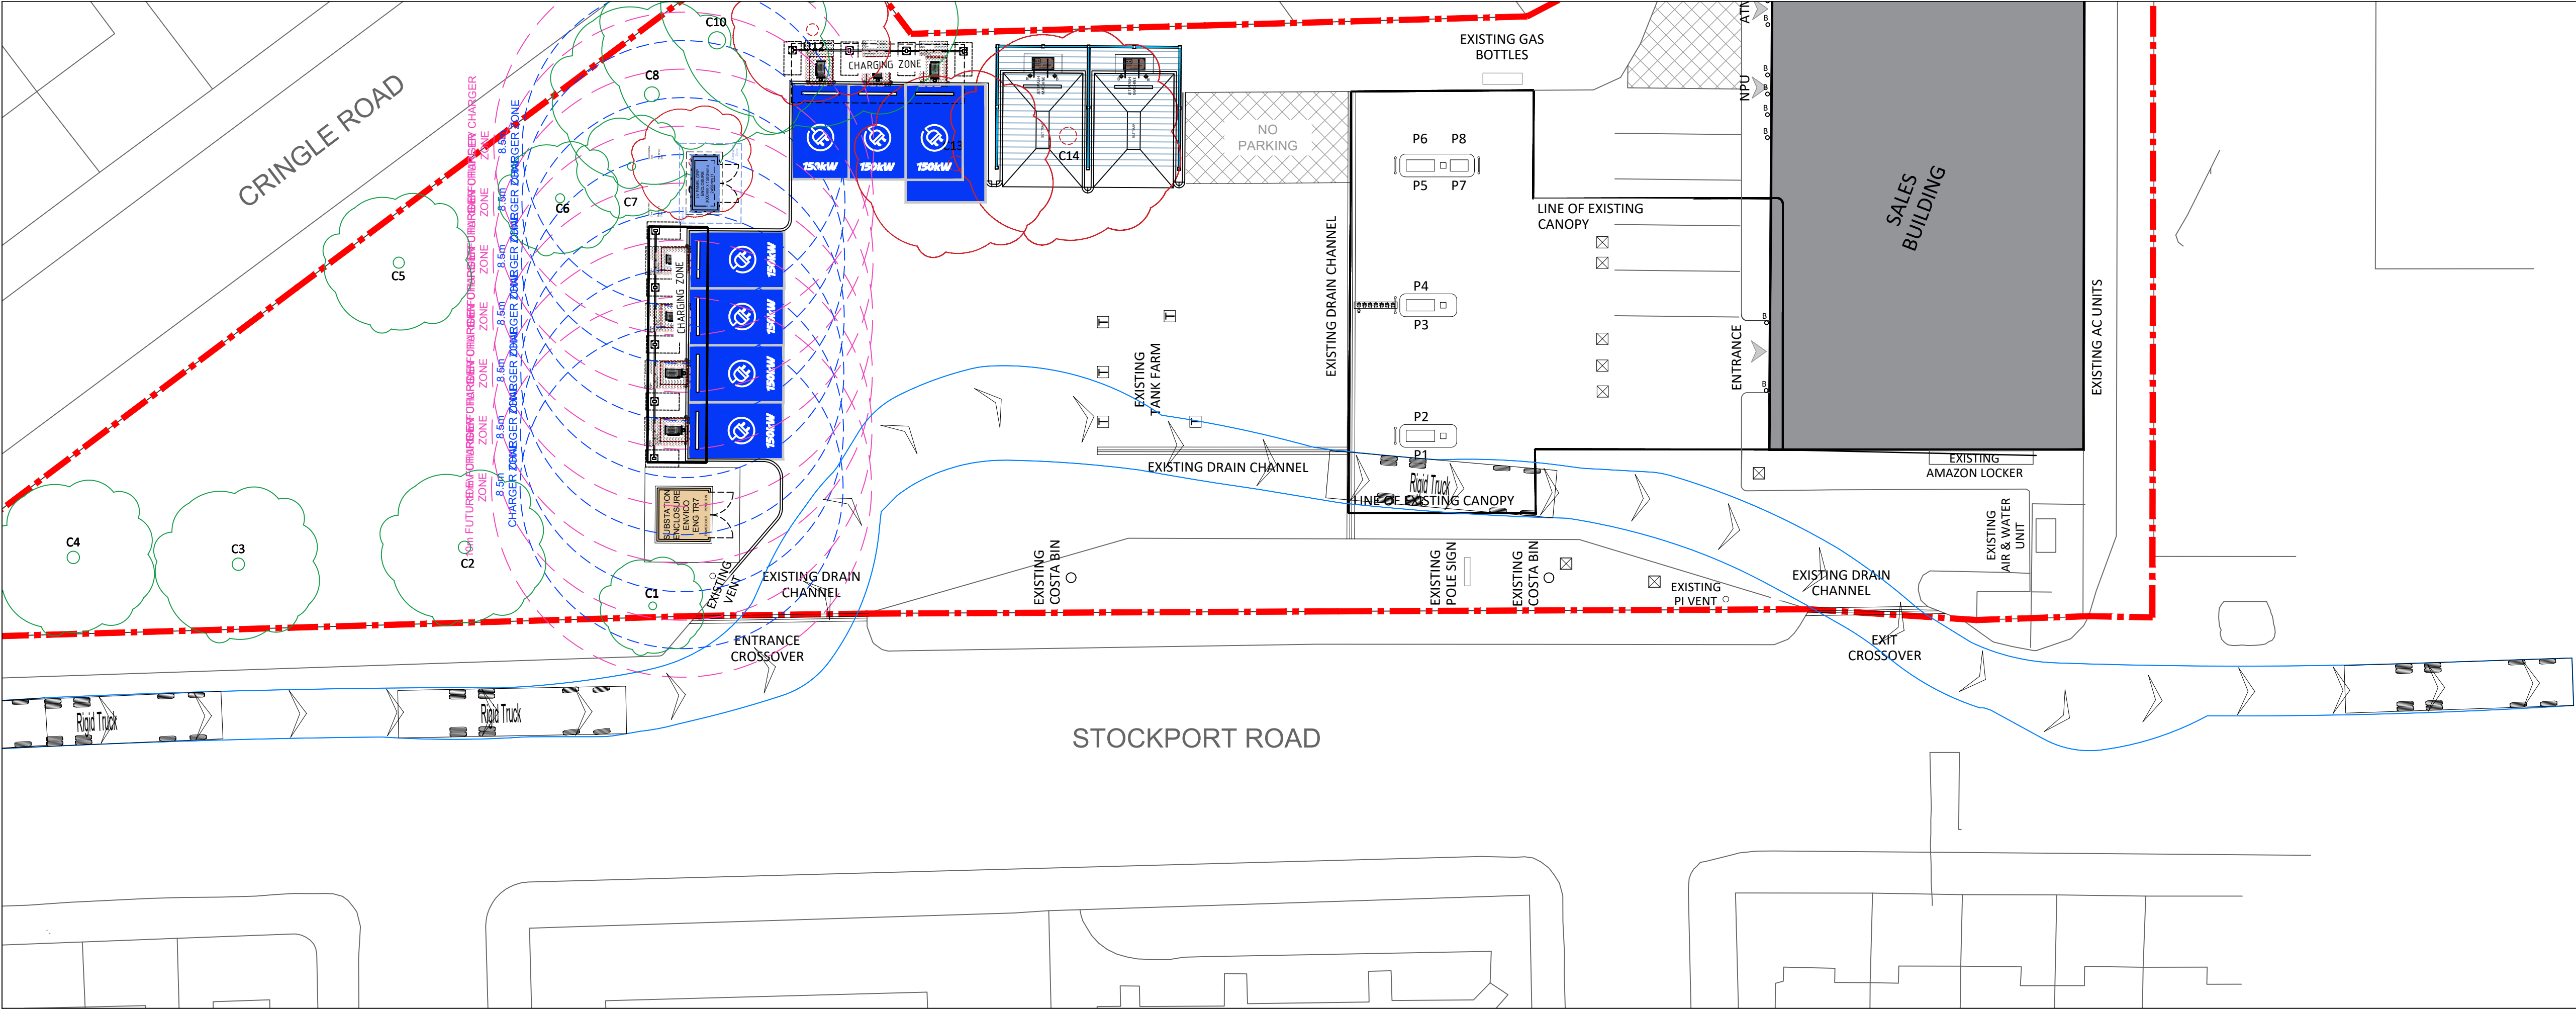


VEHICLE TRACKING - RIGID TRUCK
SCALE - 1:100

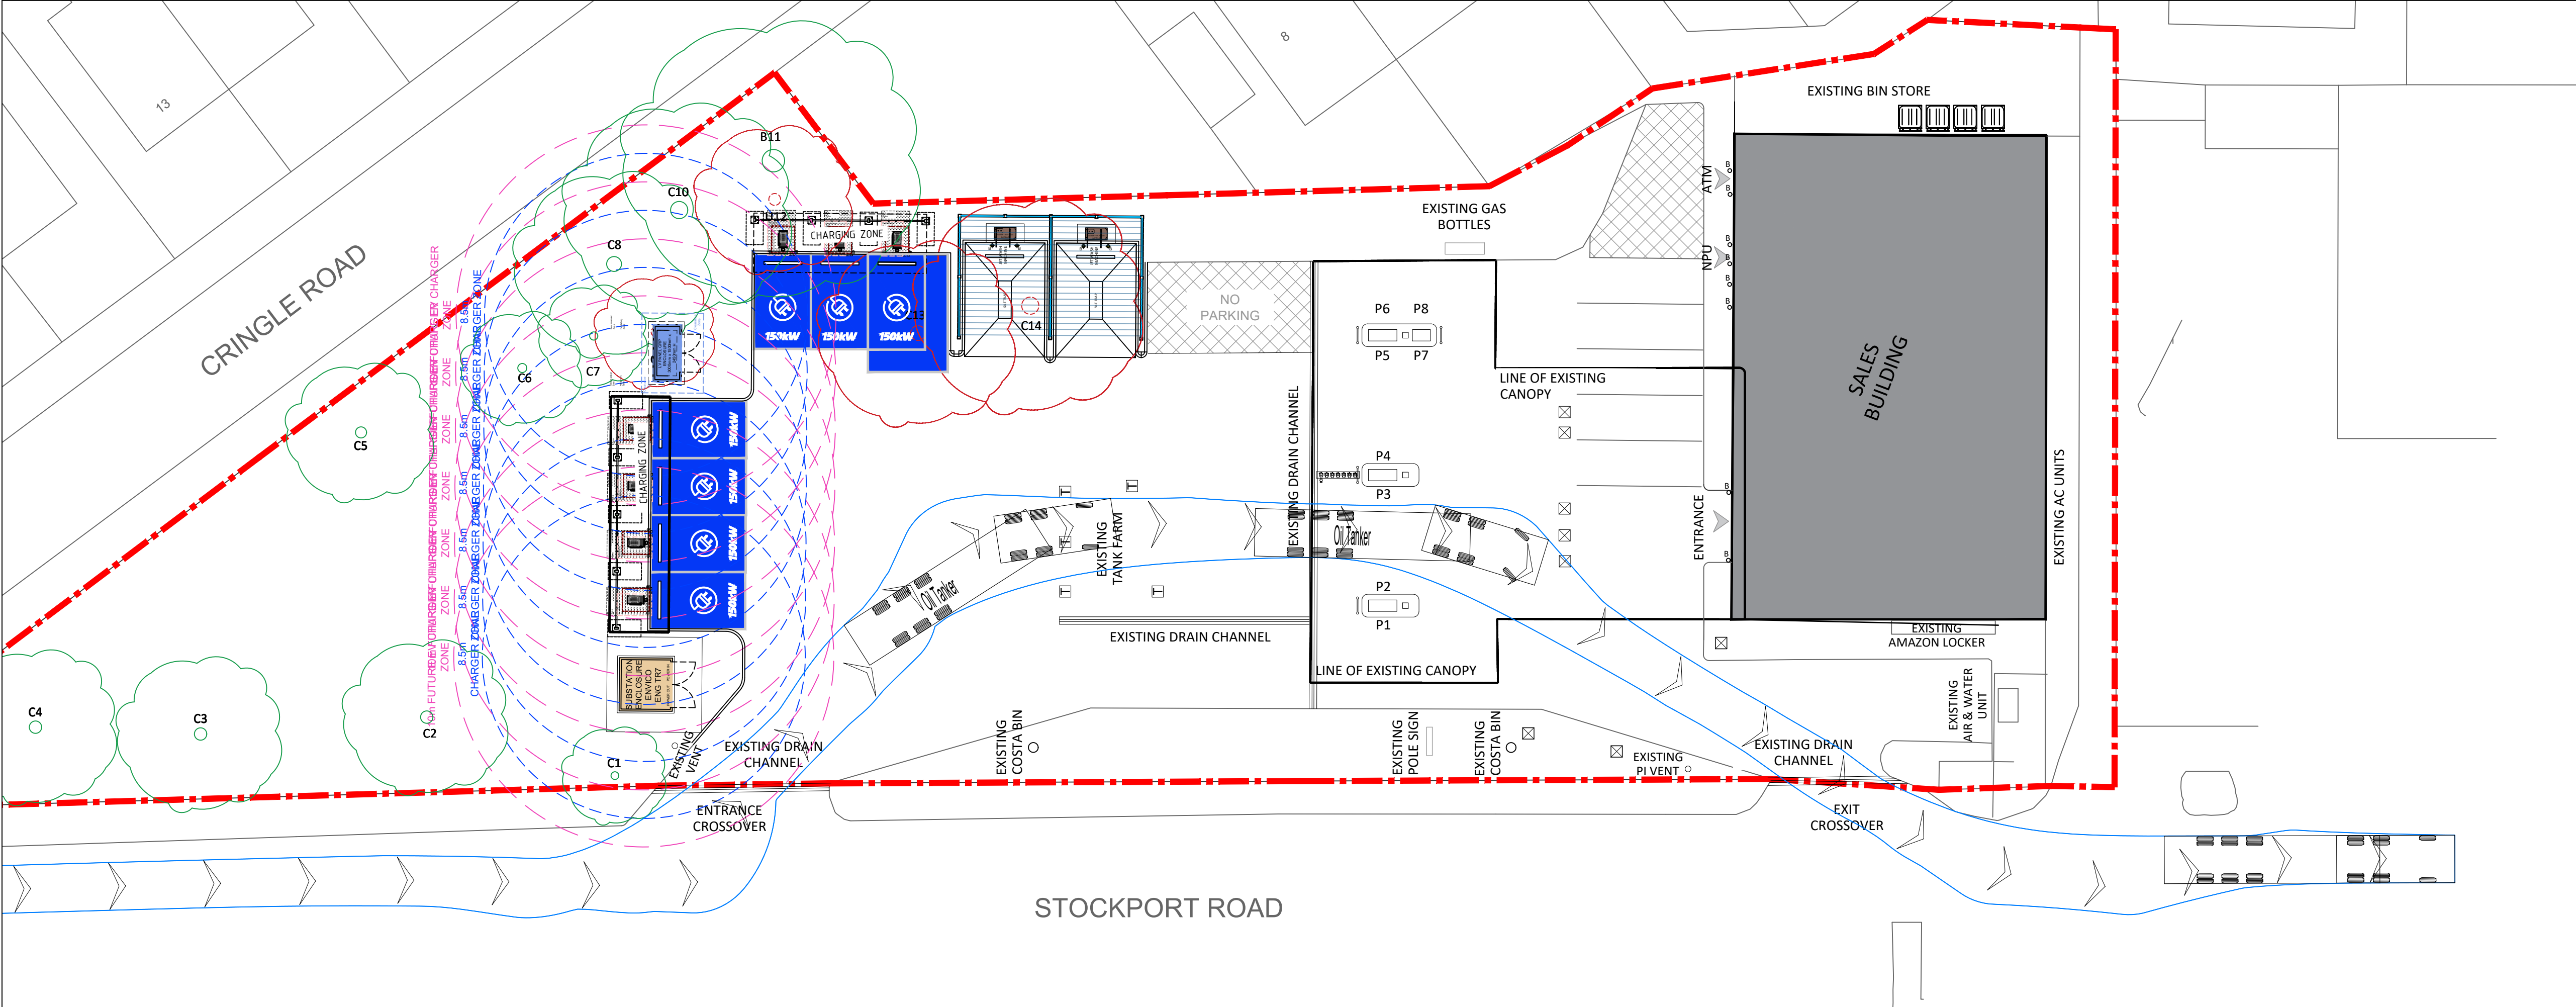

VEHICLE TRACKING - OIL TANKER
SCALE - 1:100

DRAWING NOTES
COPYRIGHT ©
This drawing and the details herein are the copyright of MBH Design Studio Ltd. and must not be reproduced, altered or passed to any third party without prior written consent.
This drawing has been produced for the project listed below, is submitted in support of this application application to the Local Planning Authority and is not intended for use by any other person or for any other purpose.
Every effort has been made to ensure the accuracy of these drawings, however MBH Design Studio Ltd. accept no responsibility for any discrepancies arising from the reuse of survey information and preliminary drawings commissioned by the Applicant from others.

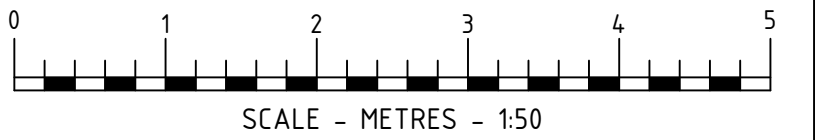

REV	DATE	DESCRIPTION	DRAWN/CHECKED
1			

PLANNING



PROJECT
FS304 LEVENSHULME SERVICE STATION
STOCKPORT ROAD, CRINGLE ROAD
MANCHESTER
M19 2RE

DRAWING TITLE
SITE PLAN
VEHICLE TRACKING PLAN

DRAWN BY JR	DATE 16.05.2022	SCALE 1:50	PAPER SIZE A1
CHECKED BY RRB	DRAWING NUMBER 13664-P11-304	REV. -	