

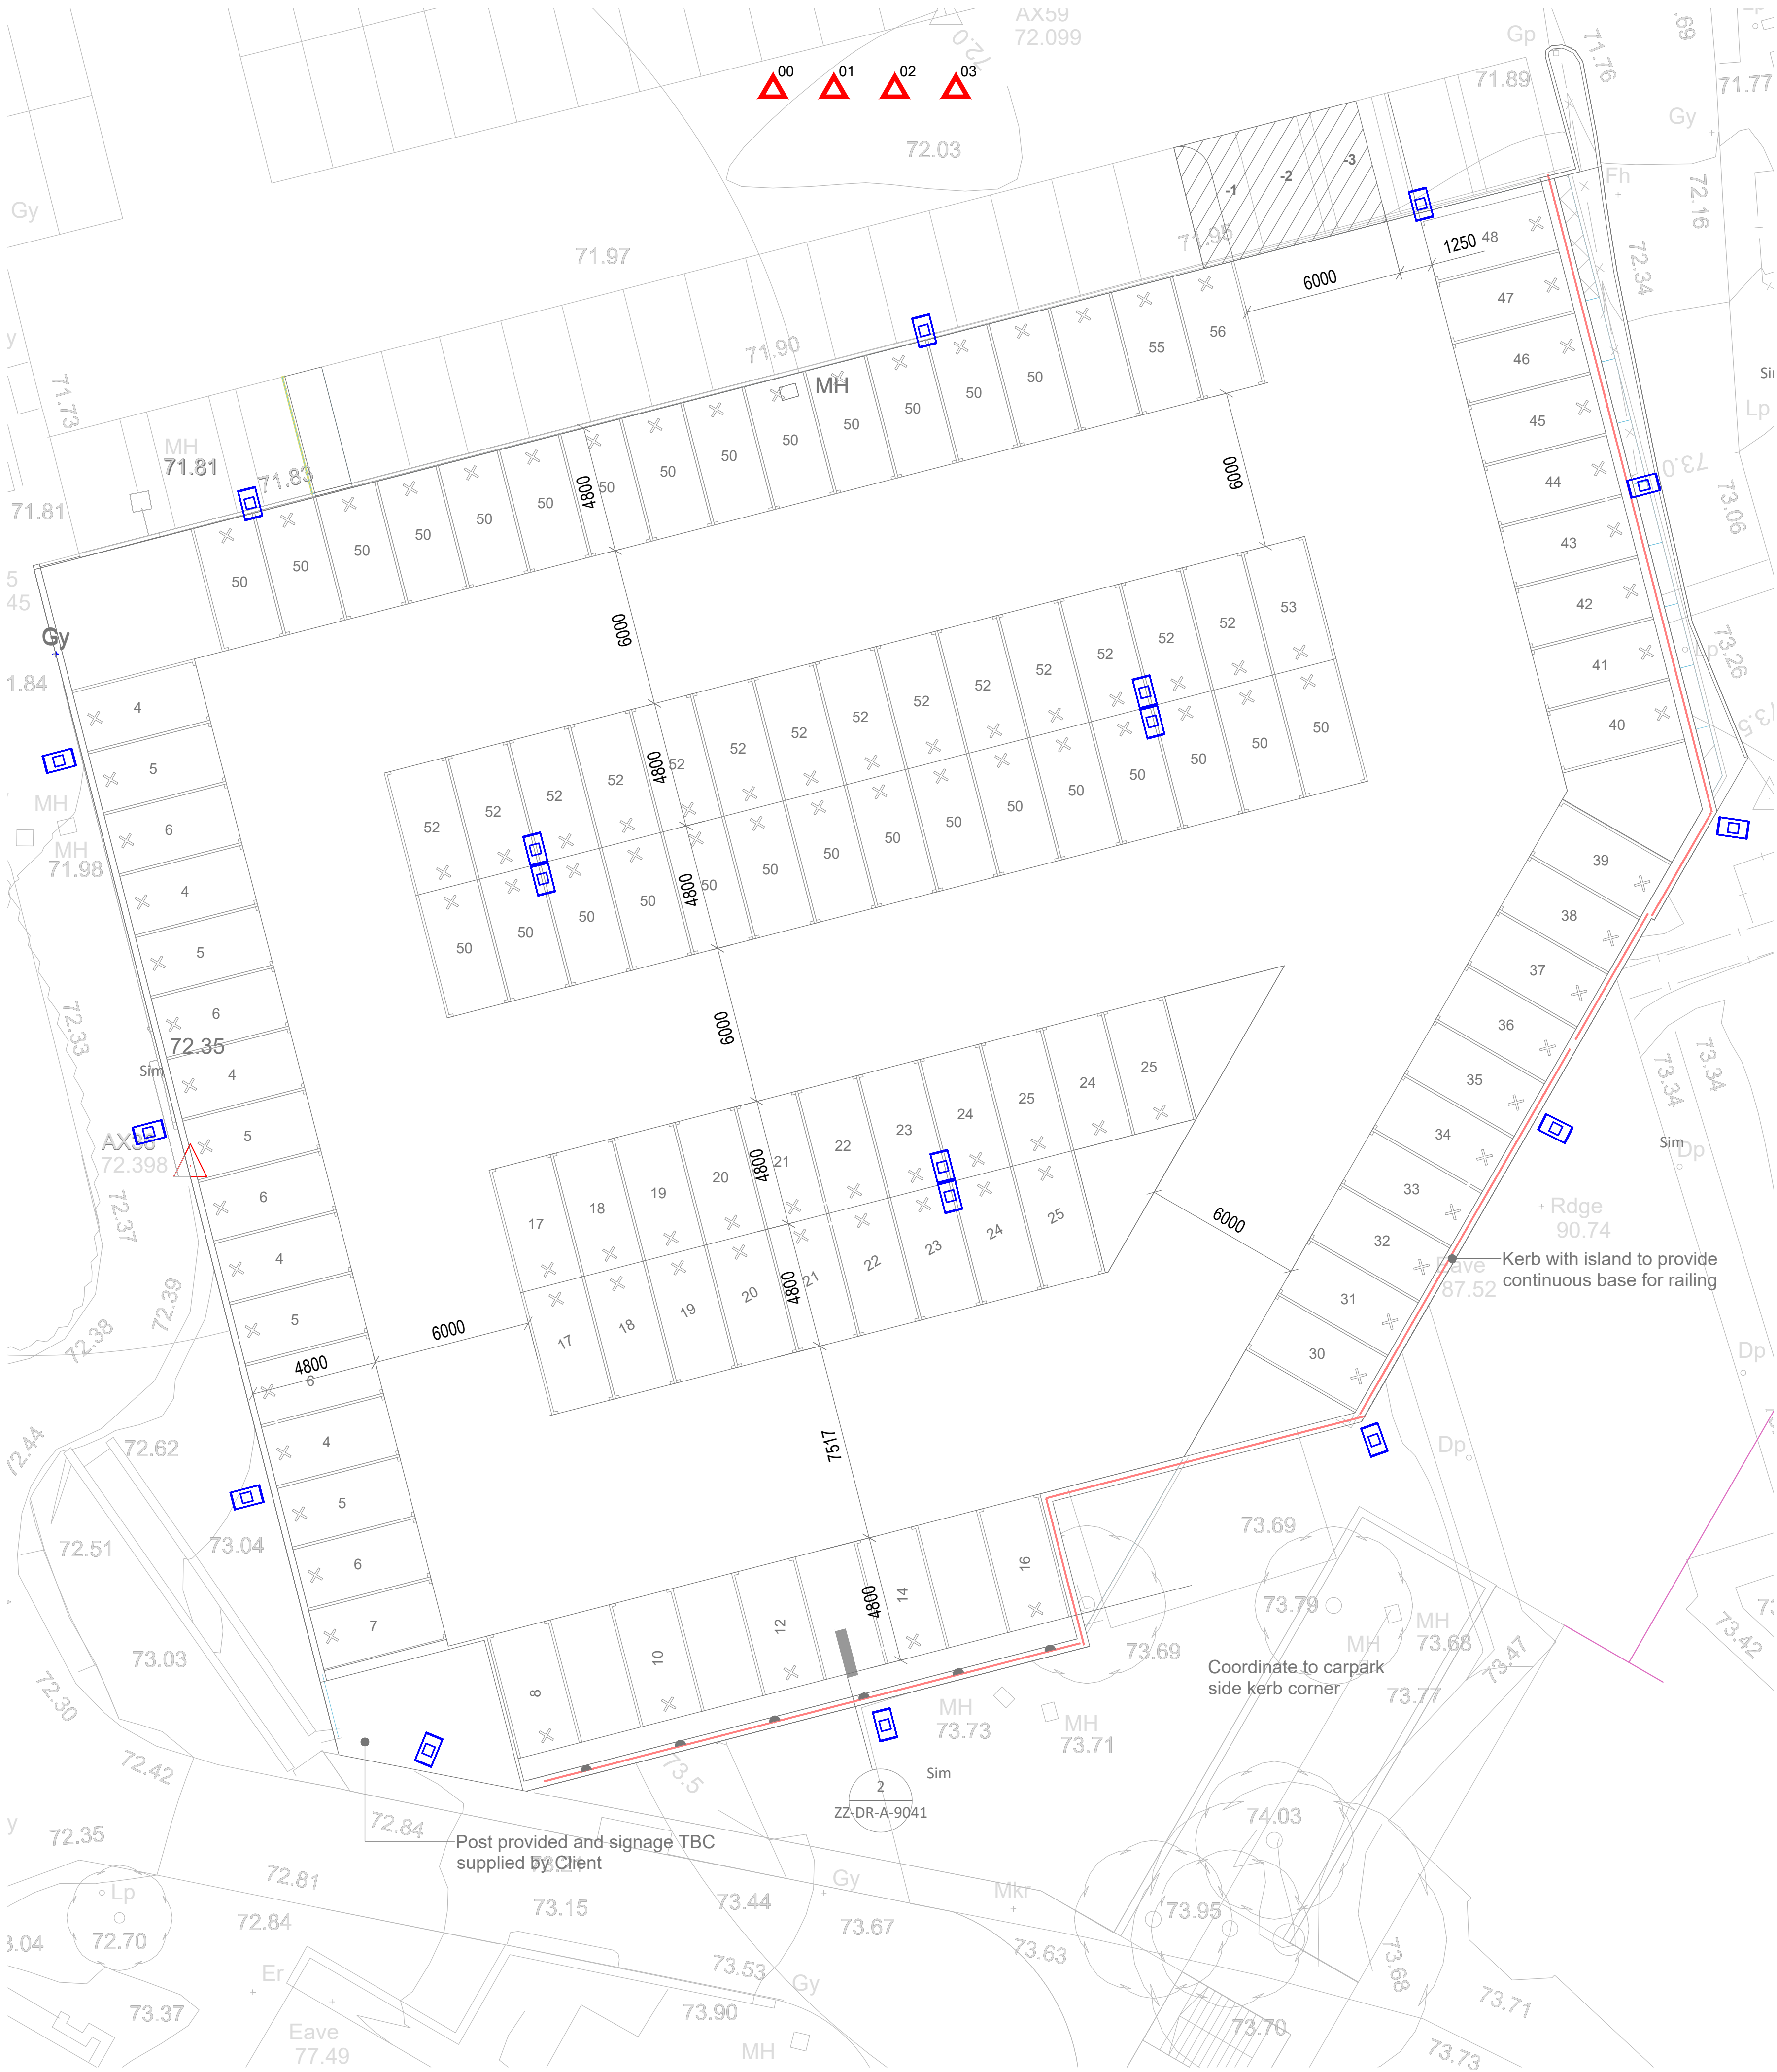


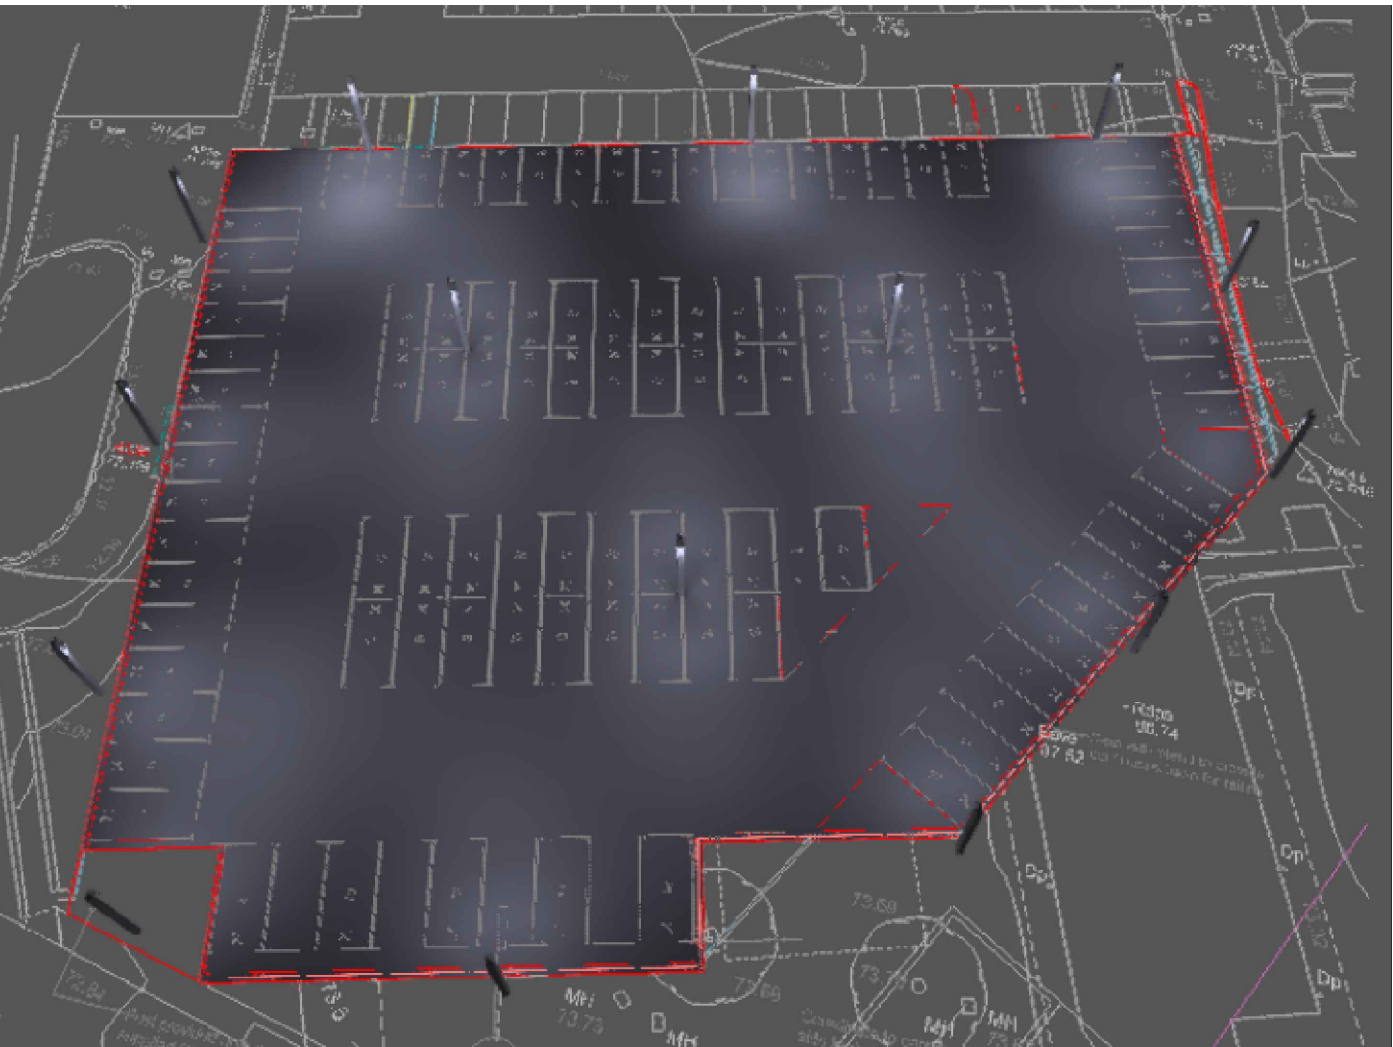

00 01 02 03

Proposed Fittings					6m MEDIUM DUTY COLUMN WITH LIGHT FITTING POST TOP MOUNTED CB09A1000-462
Ref.	Description	Manufacturer	Fitting Ref.	Type	
	IP66 LED FLOOD LIGHT	WHITECROFT	EUROFLOOD MID LED - 52W - 6030 LUMENS - EFLH4KG		

NEW CARPARK LIGHTING COLUMNS TO BE INSTALLED AS SHOWN.
NEW CABLES TO RUN ALONG THE EDGE OF THE NEW CARPARK, BETWEEN EACH COLUMN VIA 10mm² SWA CABLES BURIED IN THE GROUND.
NEW LIGHTING SUPPLIED FROM ID OFFICES (BUILDING 47) DISTRIBUTION BOARDS, CONTROLLED VIA A TIMECLOCK AND PHOTOCELL MOUNTED ON BUILDING 47.

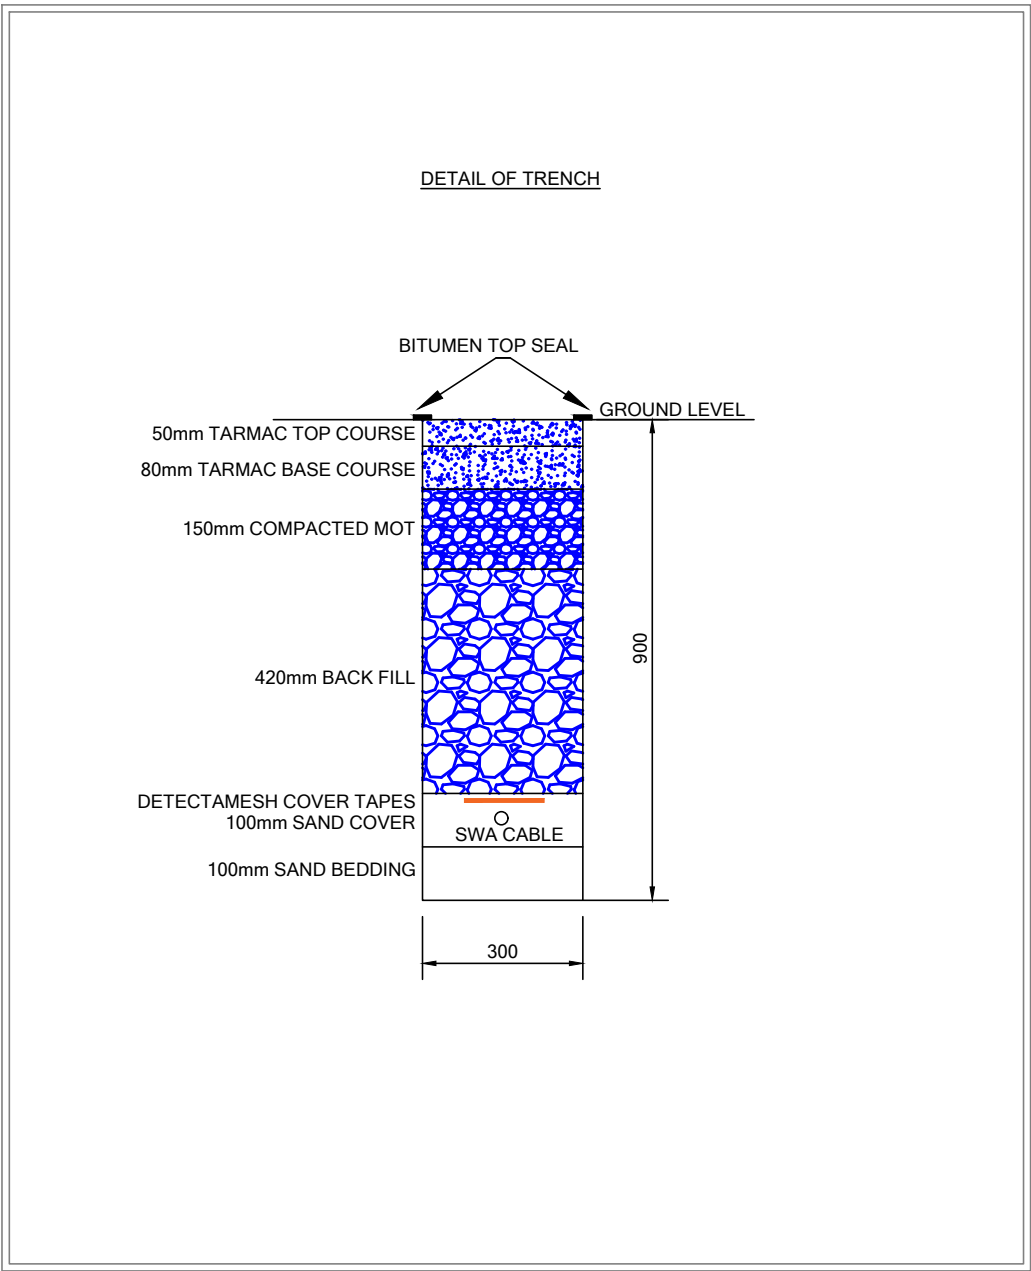

THIS DRAWING IS THE PROPERTY OF S.I. SEALY AND ASSOCIATES LTD. NO INFORMATION CONTAINED HEREON SHALL BE COPIED IN WHOLE OR IN PART, OR PASSED TO ANY OTHER PARTY WITHOUT WRITTEN CONSENT.
COPYRIGHT IS RESERVED. ©
THIS DRAWING SHALL NOT BE SCALED.

RESIDUAL RISKS THAT CANNOT BE OMITTED BY DESIGN ARE HIGHLIGHTED ON THE DRAWING WITH THE SYMBOL 00

A DESCRIPTION OF THE RISK AND THE REQUIRED ACTIONS ARE SCHEDULED BELOW.

RISK SCHEDULE	
No.	DESCRIPTION
00	PERMITS TO WORK REQUIRED THROUGHOUT
01	ASBESTOS MAY BE PRESENT, REQUEST REGISTER FROM ESTATES BEFORE WORK COMMENCES
02	BEWARE OF EXISTING UNDERGROUND SERVICES. CHECK CPN SURVEY DRAWINGS.
03	EXISTING LIVE SERVICES

P02	SECOND ISSUE - UPDATED LUMINAIRE LOCATIONS AND TYPE	24/10/2022	JR	DS	
P01	FIRST ISSUE	24/10/22	JR	DS	
REV	DESCRIPTION	DATE	DRW	CHK	

NHS
Manchester University
NHS Foundation Trust

S.I. SEALY
Specialist Colour ■ Street Road ■ Secondary ■ Secondary ■ Secondary ■ Secondary ■ Secondary ■ Secondary
Tel: 0161 430 2004 | www.sisealy.co.uk

PROJECT
NORTH MANCHESTER GENERAL HOSPITAL
TOP 05 REDESIGN

TITLE
PROPOSED LIGHTING LAYOUT - PHASE 2

STATUS
P01
PURPOSE OF ISSUE
Preliminary

DRAWN BY
AF
CHECKED BY
DP
DATE
20/10/2022

SCALE (@A0L)
1:100
PROJECT NUMBER
20200

FILE DRAWING NUMBER
20200-SIS-INZ-XX-DR-E-6910
REV.
P02