


REVISION	DATE	DESCRIPTION
P01	26/08/2022	INITIAL ISSUE

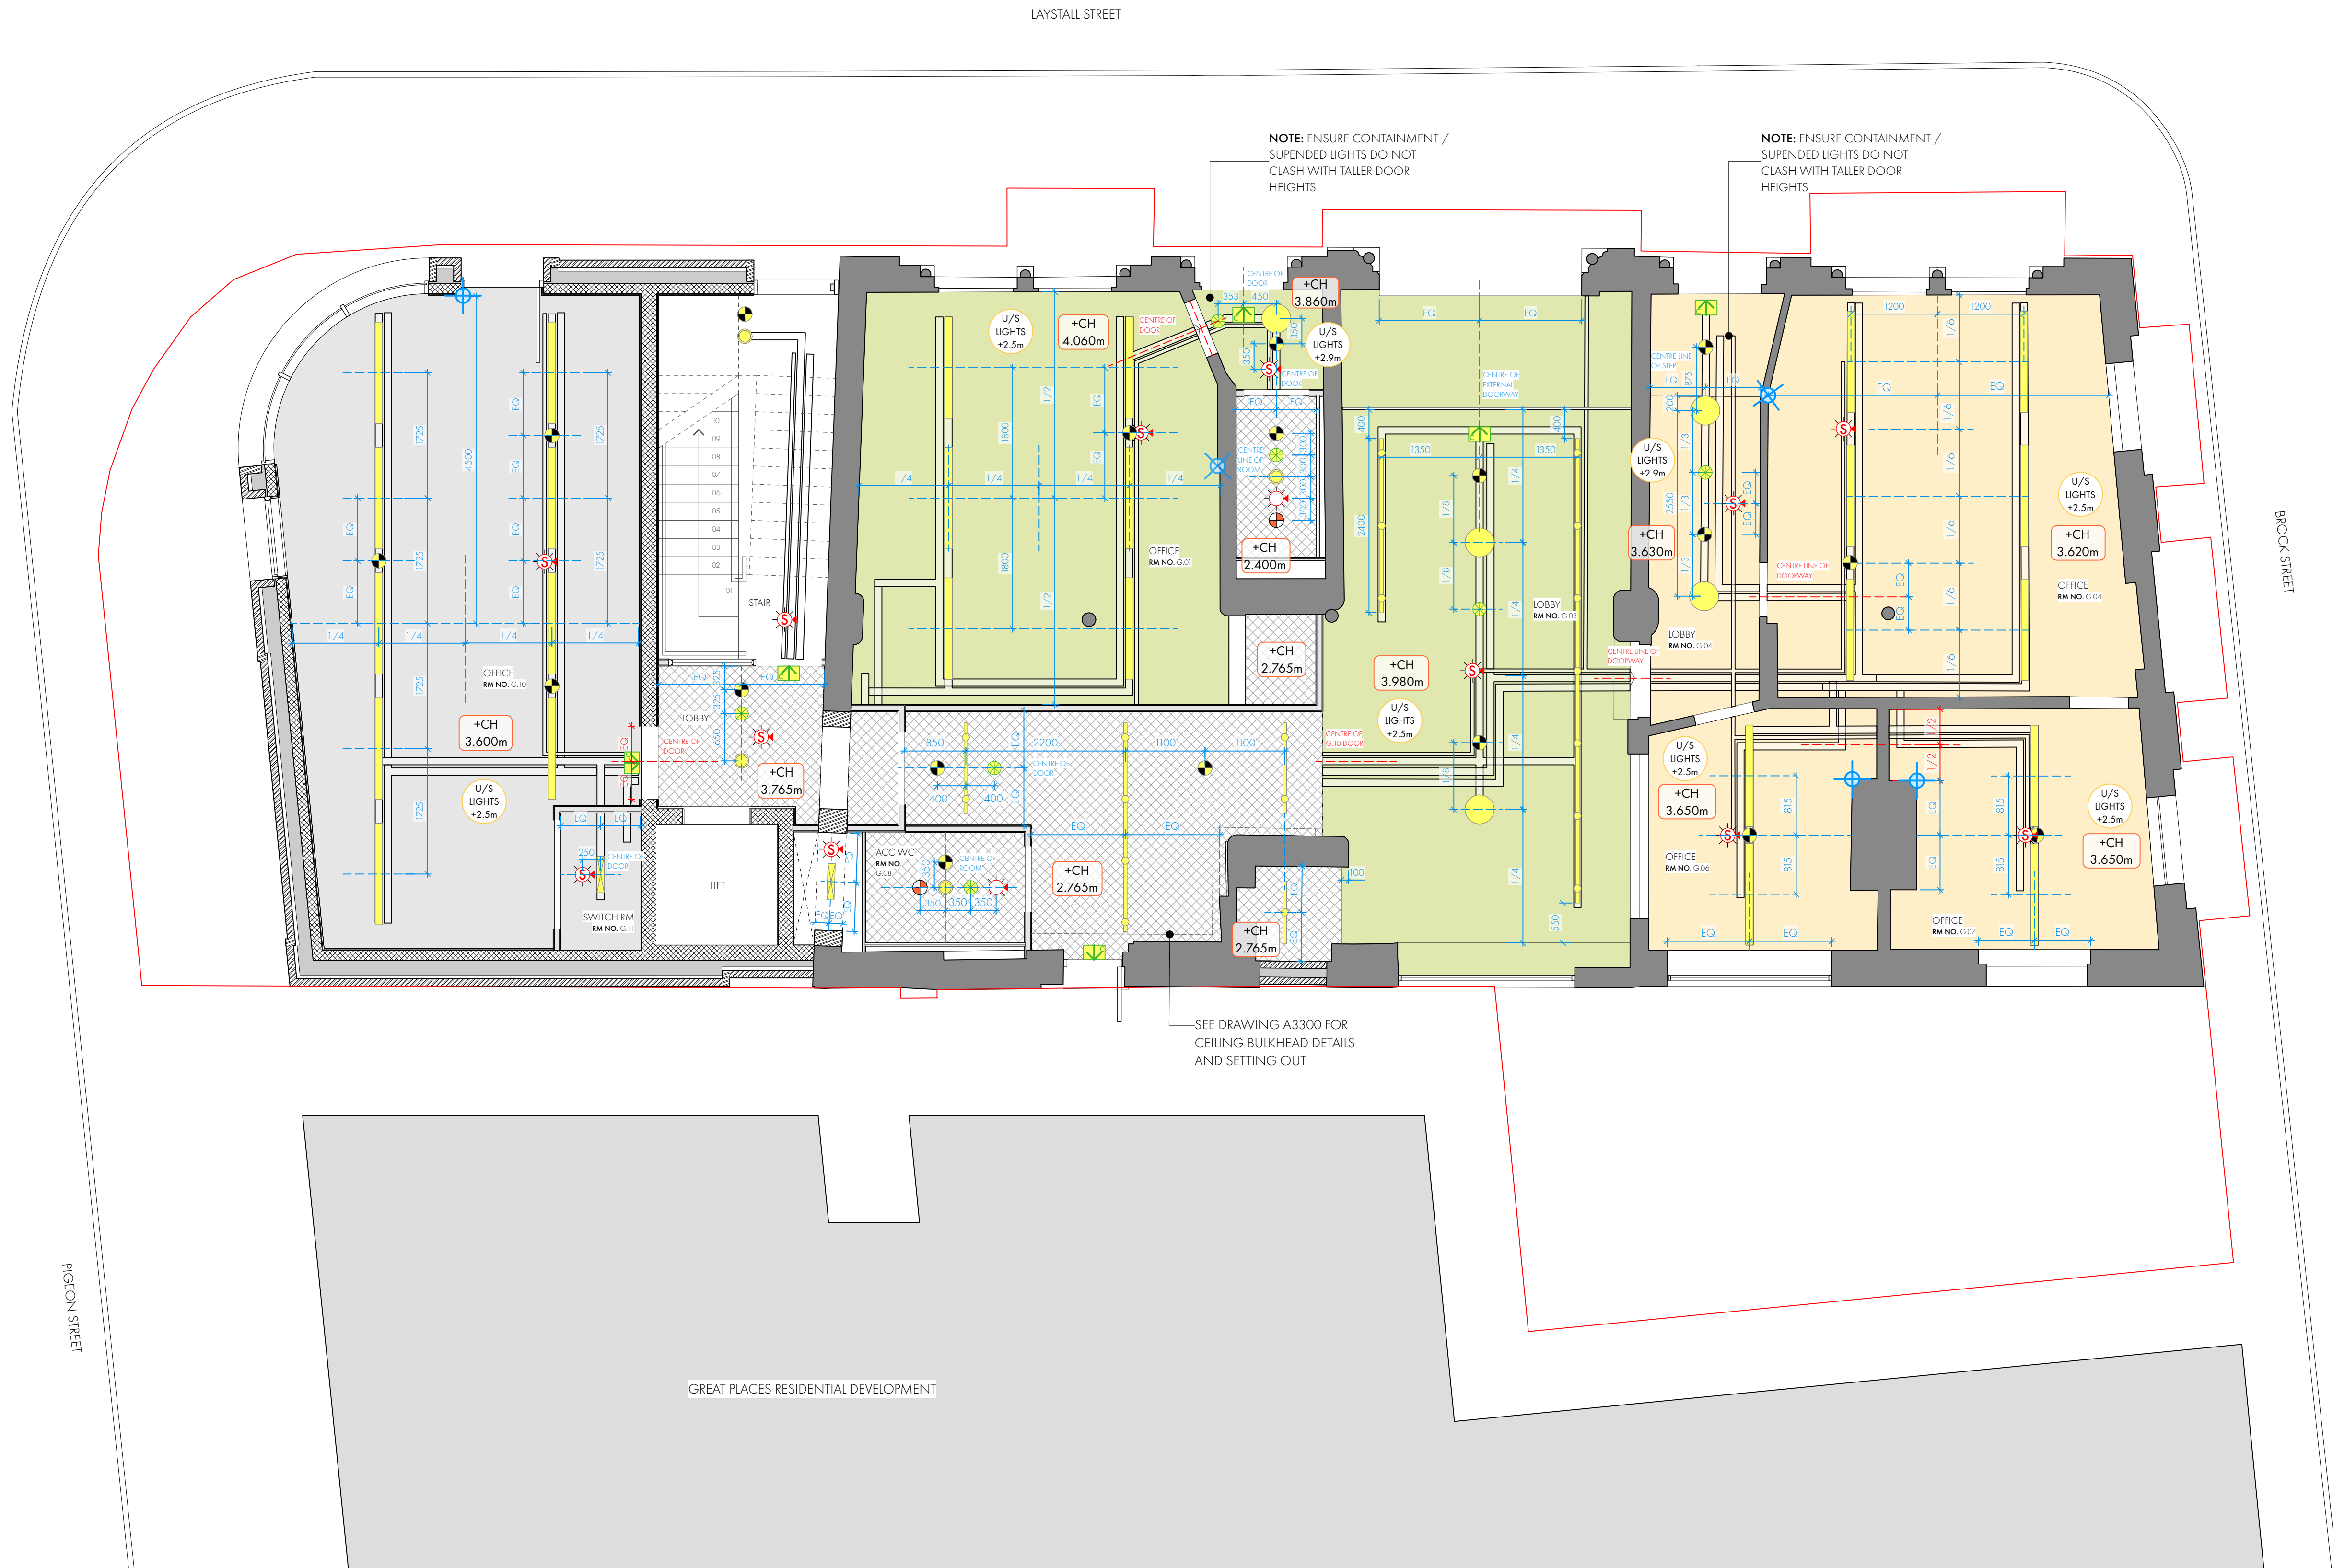

REFLECTED CEILING PLAN LEGEND	
	EXISTING LATHE AND PLASTER – BASKETS VISIBLE
	EXISTING PAINTED TIMBER BOARD – BASKETS VISIBLE
	EXISTING VAULTED BRICK
	PROPOSED PLASTERBOARD SUSPENDED CEILING – BASKETS VISIBLE
	PROPOSED PLASTERBOARD SUSPENDED CEILING – NO BASKETS VISIBLE
	PROPOSED PLASTERBOARD TO UNDERSIDE OF JOISTS – BASKETS VISIBLE
	FINISHED CEILING HEIGHT, MEASURED FROM FFL
	UNDERSIDE OF LIGHT FITTINGS, MEASURED FROM FFL
	SETTING OUT POINT FOR FITTINGS
	PENDANT LIGHT
	RECESSED LIGHT
	SUSPENDED LINEAR LUMINAIRE – MIN. 2.5m TO UNDERSIDE FROM FFL
	SUSPENDED TRACK LIGHTING WITH SPOTLIGHTS
	SURFACE LINEAR LUMINAIRE
	PIR
	SURFACE MOUNTED EMERGENCY LIGHTING
	ILLUMINATED CEILING MOUNTED EMERGENCY EXIT SIGN
	SMOKE DETECTOR W/ BEACON & SOUNDER
	BEACON W/ SOUNDER
	SMOKE DETECTOR
	CEILING MOUNTED EXTRACT FAN
	EXPOSED BASKET ROUTES FOR CABLES
	FACE-FIXED CONDUIT ROUTES
	RED DIMENSIONS RELATE TO BASKET SETTING OUT
	BLUE DIMENSIONS RELATE TO LIGHT FITTINGS SETTING OUT



OMIArchitects

31 Blackfriars Road, Salford, Manchester, M3 7AQ.
+44(0)161 832 3242 / info@omiarchitects.com / www.omiarchitects.com

PROJECT	LAYSTALL STREET – LISTED BUILDING			
DRAWING	REFLECTED CEILING PLAN – GROUND FLOOR			
DATE	AUG 22	DRAWN BY	LG	SCALE 1:50 @A1
JOB NO.	1383	DWG. NO.	1383-OMI-00-00-DR-A-L1020-P01	