
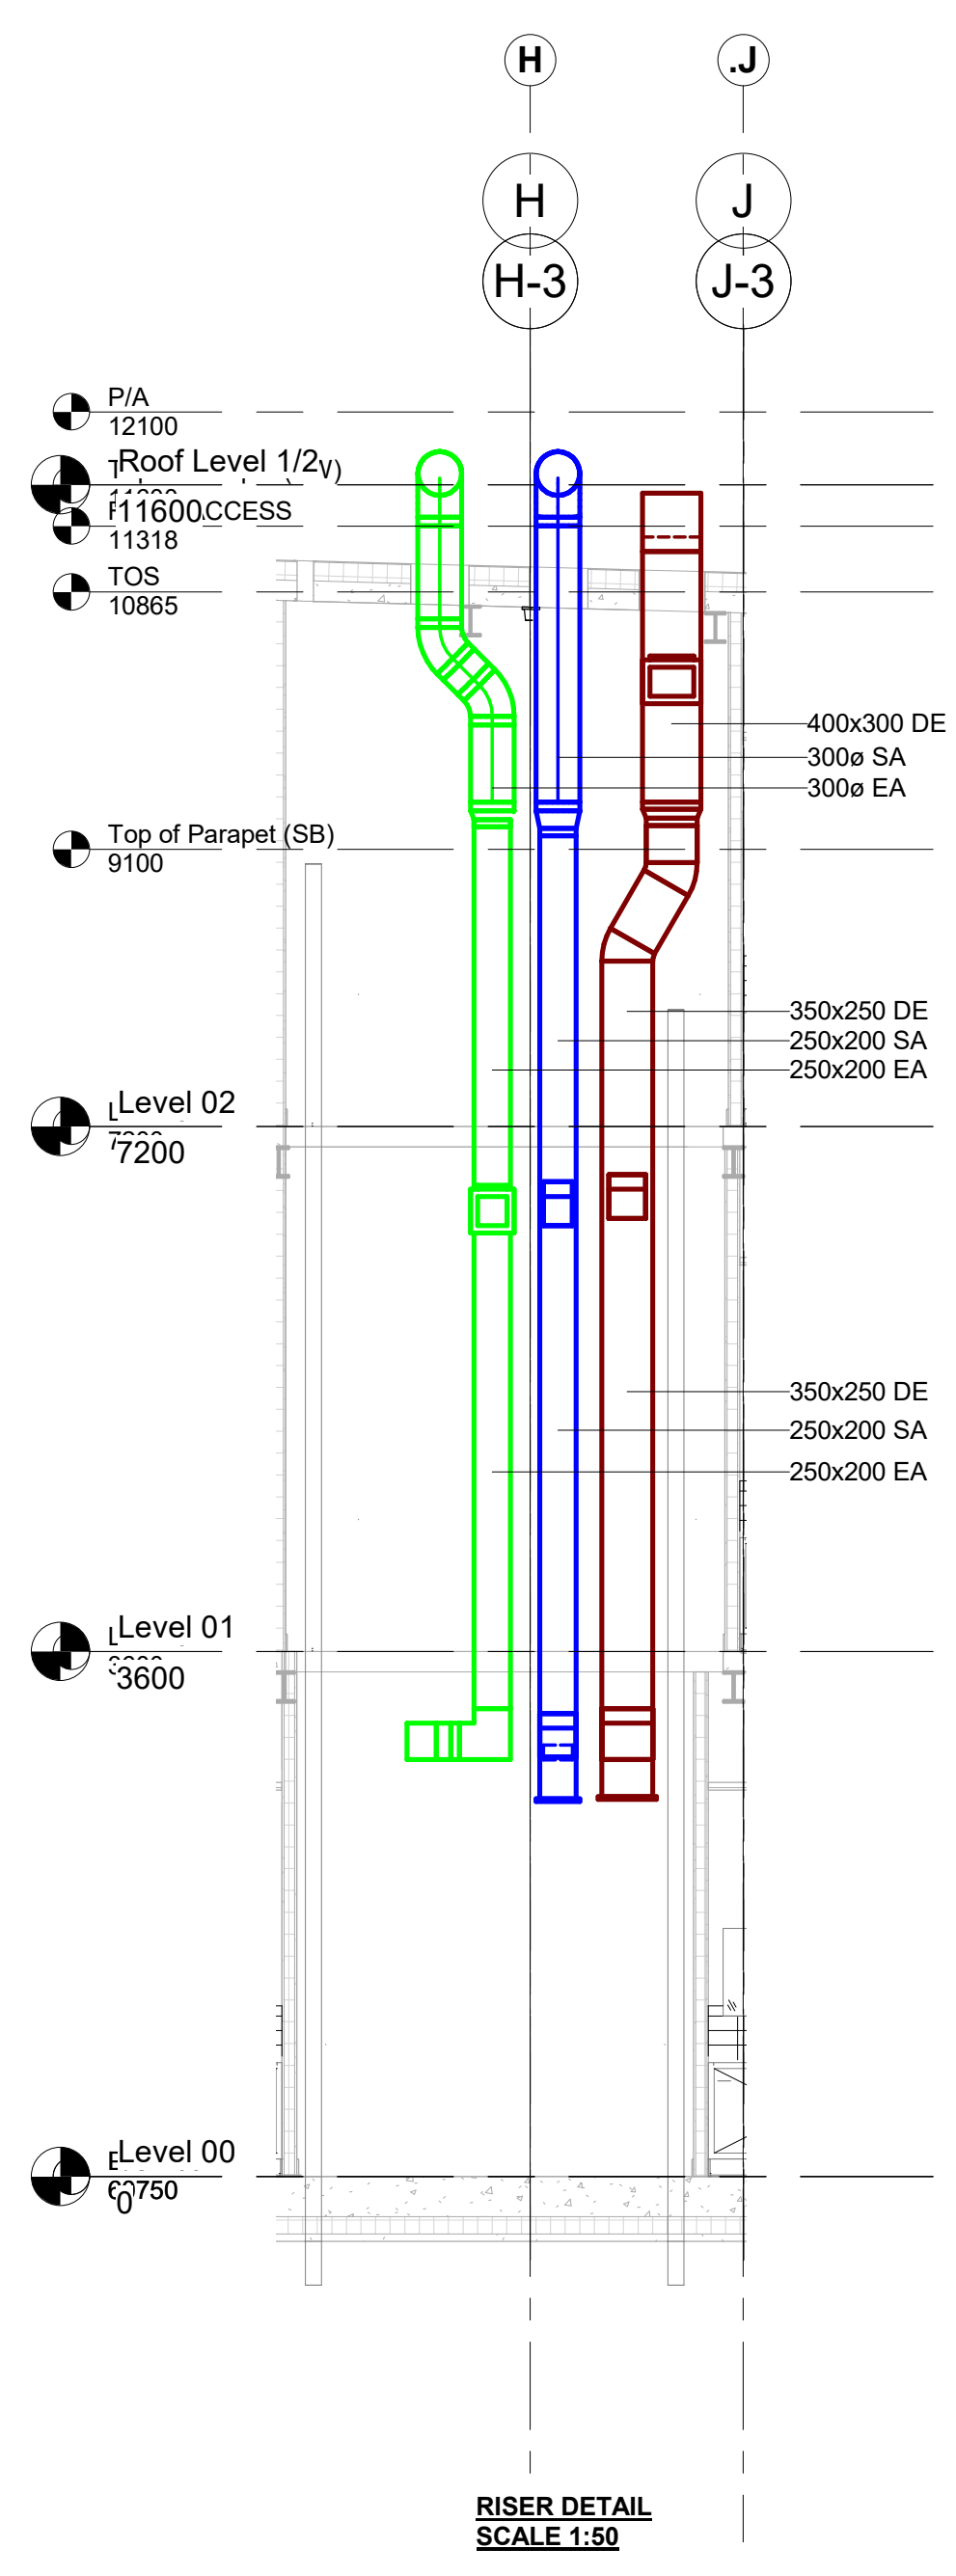


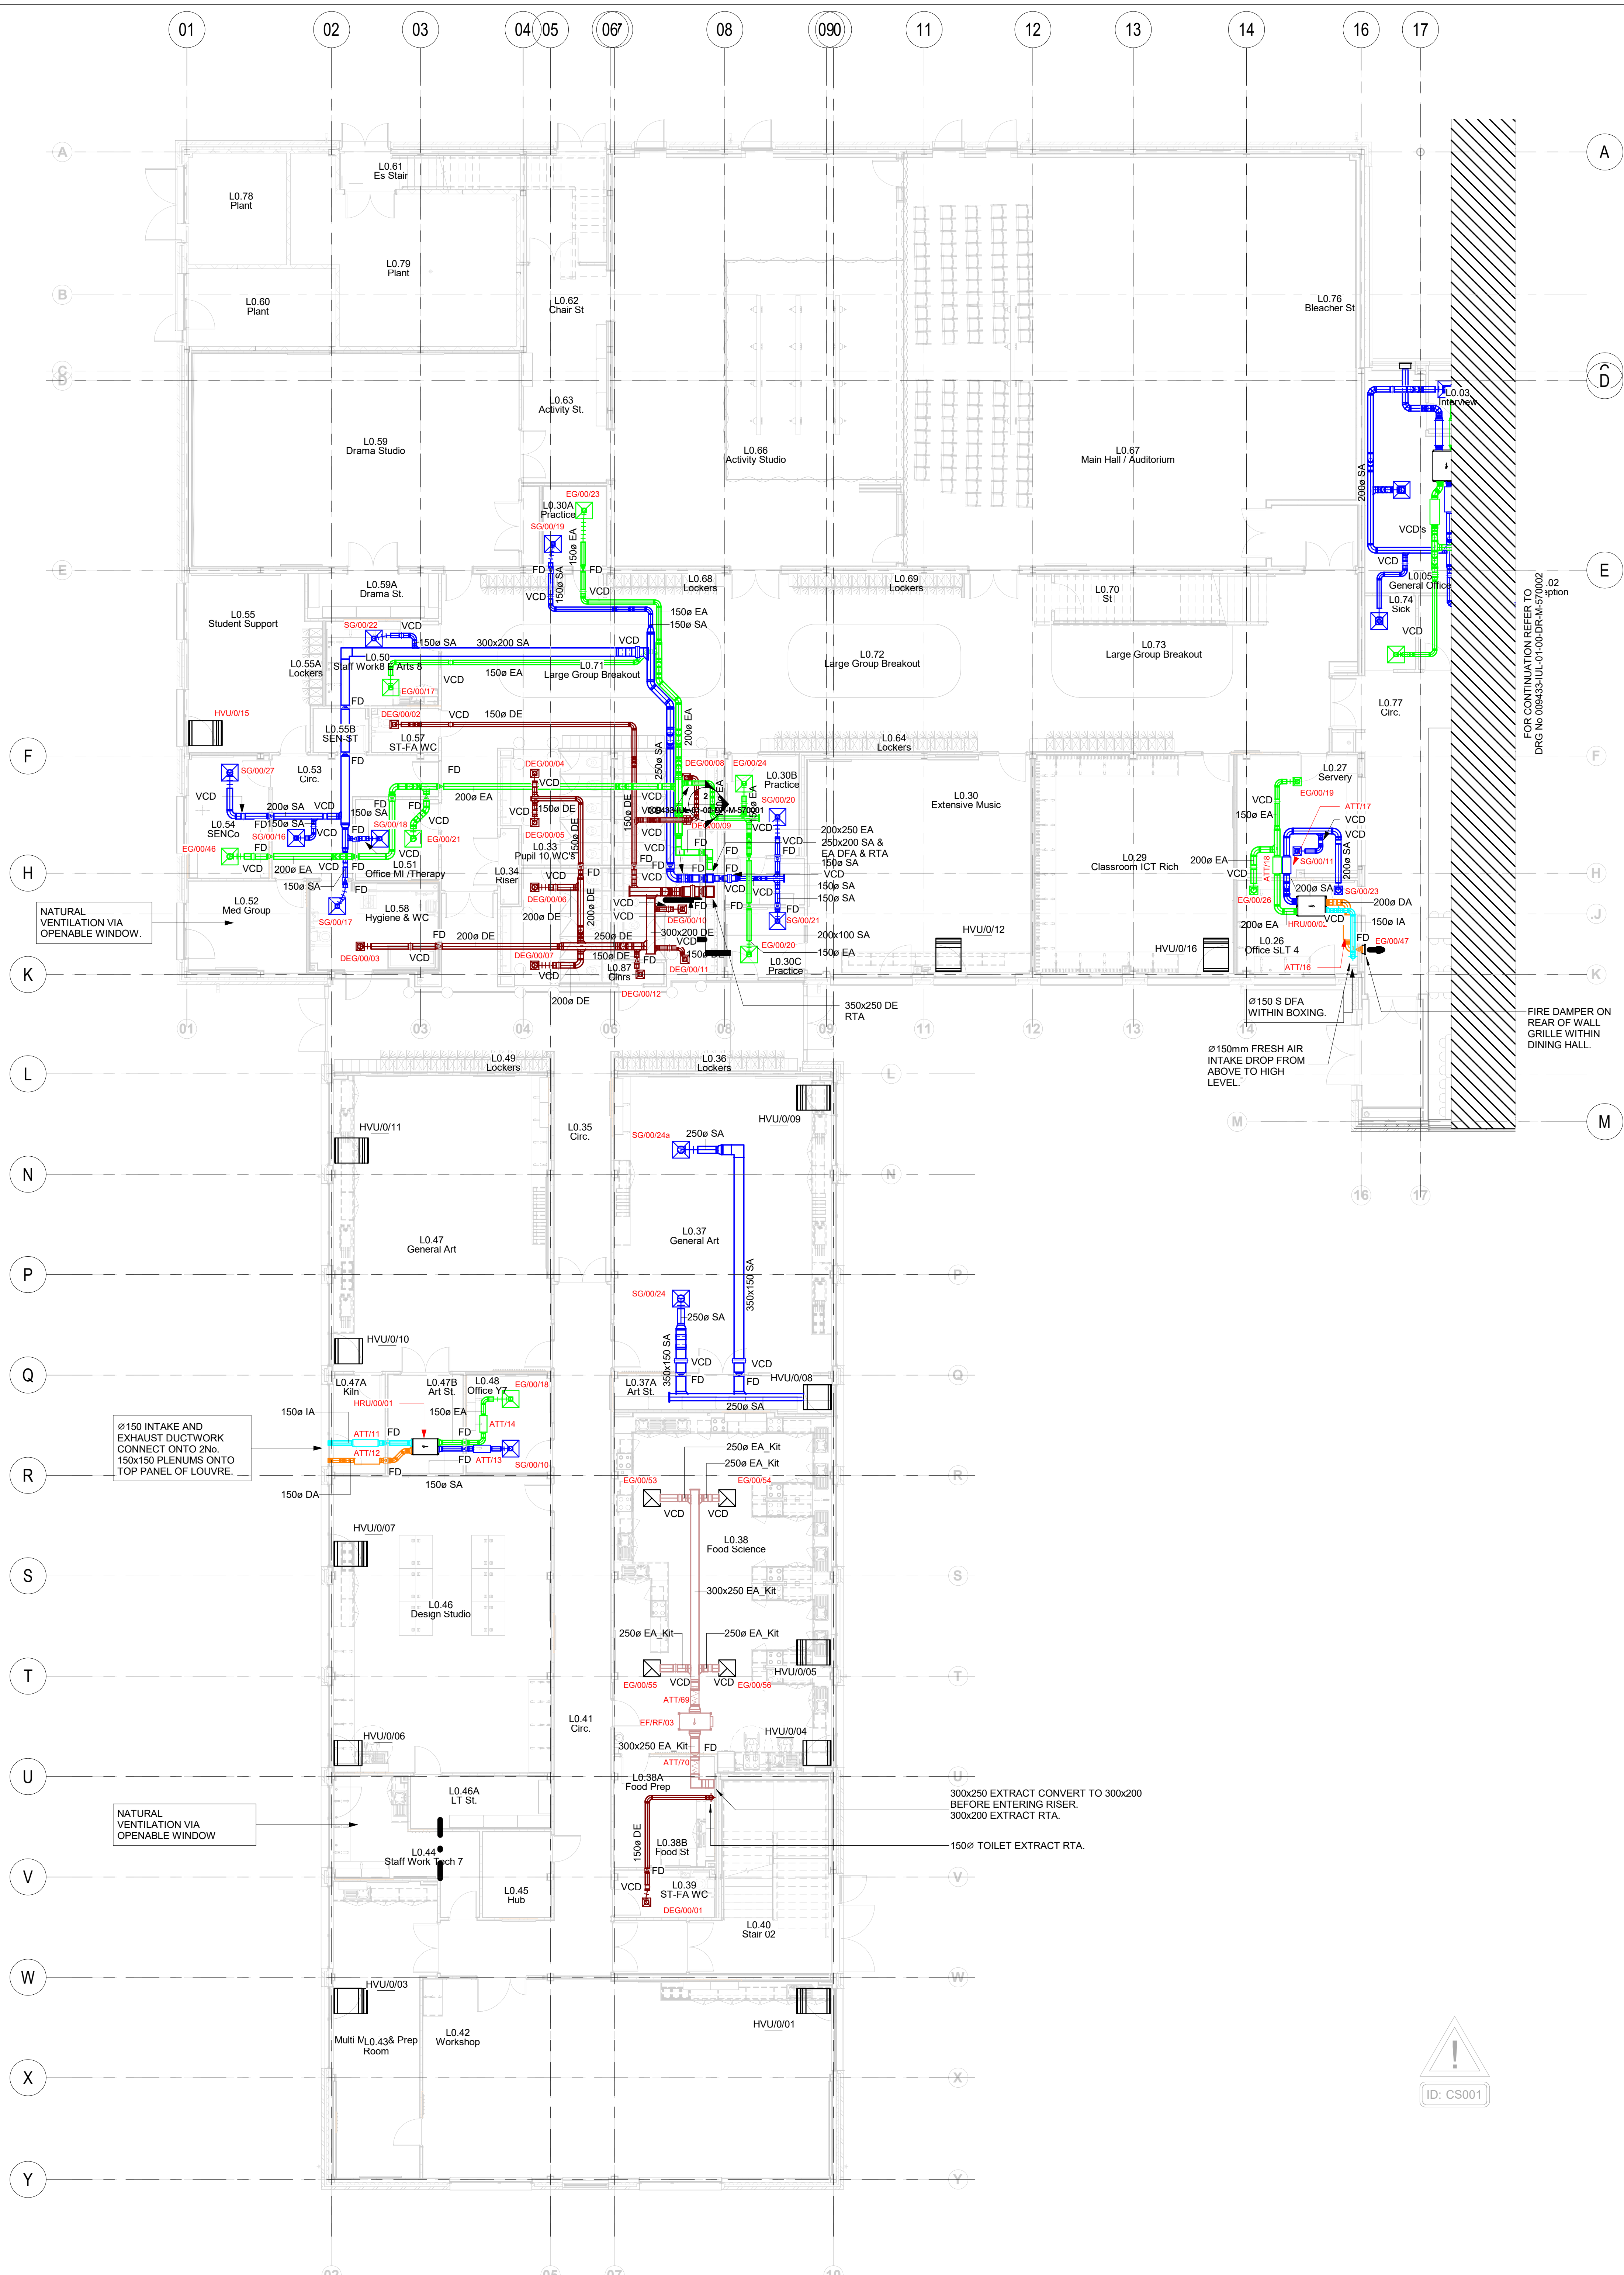

Safety, Health and Environmental Information

IN ADDITION TO THE HAZARDS / RISKS NORMALLY ASSOCIATED WITH THE TYPE OF WORK DETAILED ON THIS DRAWING, NOTE THE FOLLOWING:

Construction

Maintenance/Cleaning

Decommissioning/Demolition

IT IS ASSUMED THAT ALL WORKS WILL BE CARRIED OUT BY A COMPETENT CONTRACTOR WORKING, WHERE APPROPRIATE, TO AN APPROVED METHOD STATEMENT. THIS IS NOT AN EXHAUSTIVE LIST AND REFERENCE SHOULD BE MADE TO THE HEALTH AND SAFETY FILE.

NOTES:
1. THIS DRAWING IS TO BE READ IN CONJUNCTION WITH THE PROJECT SPECIFIC M&S SPECIFICATIONS AND THE PROJECT SPECIFIC DESIGNER'S RISK ASSESSMENTS.
2. ALL DUCTWORK THROUGH FIRE COMPARTMENTATION TO HAVE FIRE DAMPERS.

Rev

Description

By

App

Date

C06

UPDATED TO SUIT REVISED FIRE LAYOUTS

A.W.

G.G.

13.06.22

C05

FOOD SCIENCE VENTILATION ADDED

A.W.

G.G.

17.05.22

C04

CONSTRUCTION ISSUE - MAIN RISER SIZES AMENDED

A.W.

G.G.

11.02.22

C03

GENERAL CO-ORDINATION

A.W.

G.G.

04.01.22

C02

GENERAL CO-ORDINATION EXERCISE

A.W.

G.G.

12.11.21

C01

ISSUED FOR CONSTRUCTION

A.W.

G.G.

06.09.21

P01

CP ISSUE 1

A.W.

G.G.

14.05.21

LINK

MEP CONSULTING ENGINEERS

Client

MANCHESTER CITY COUNCIL

Project Title

BELLE VUE CO-OP ACADEMY

Drawing Title

LEVEL 00
VENTILATION
LAYOUT 1 of 2

Scale @ A0

1:100

Description/Issued For

CONSTRUCTION

Status

S4


Drawing Number

009433-IUL-01-00-DR-M-570001


Revision

C06

1. THIS DRAWING IS TO BE READ IN CONJUNCTION WITH THE PROJECT SPECIFIC M&E SPECIFICATIONS AND THE PROJECT SPECIFIC DESIGNERS RISK ASSESSMENTS.

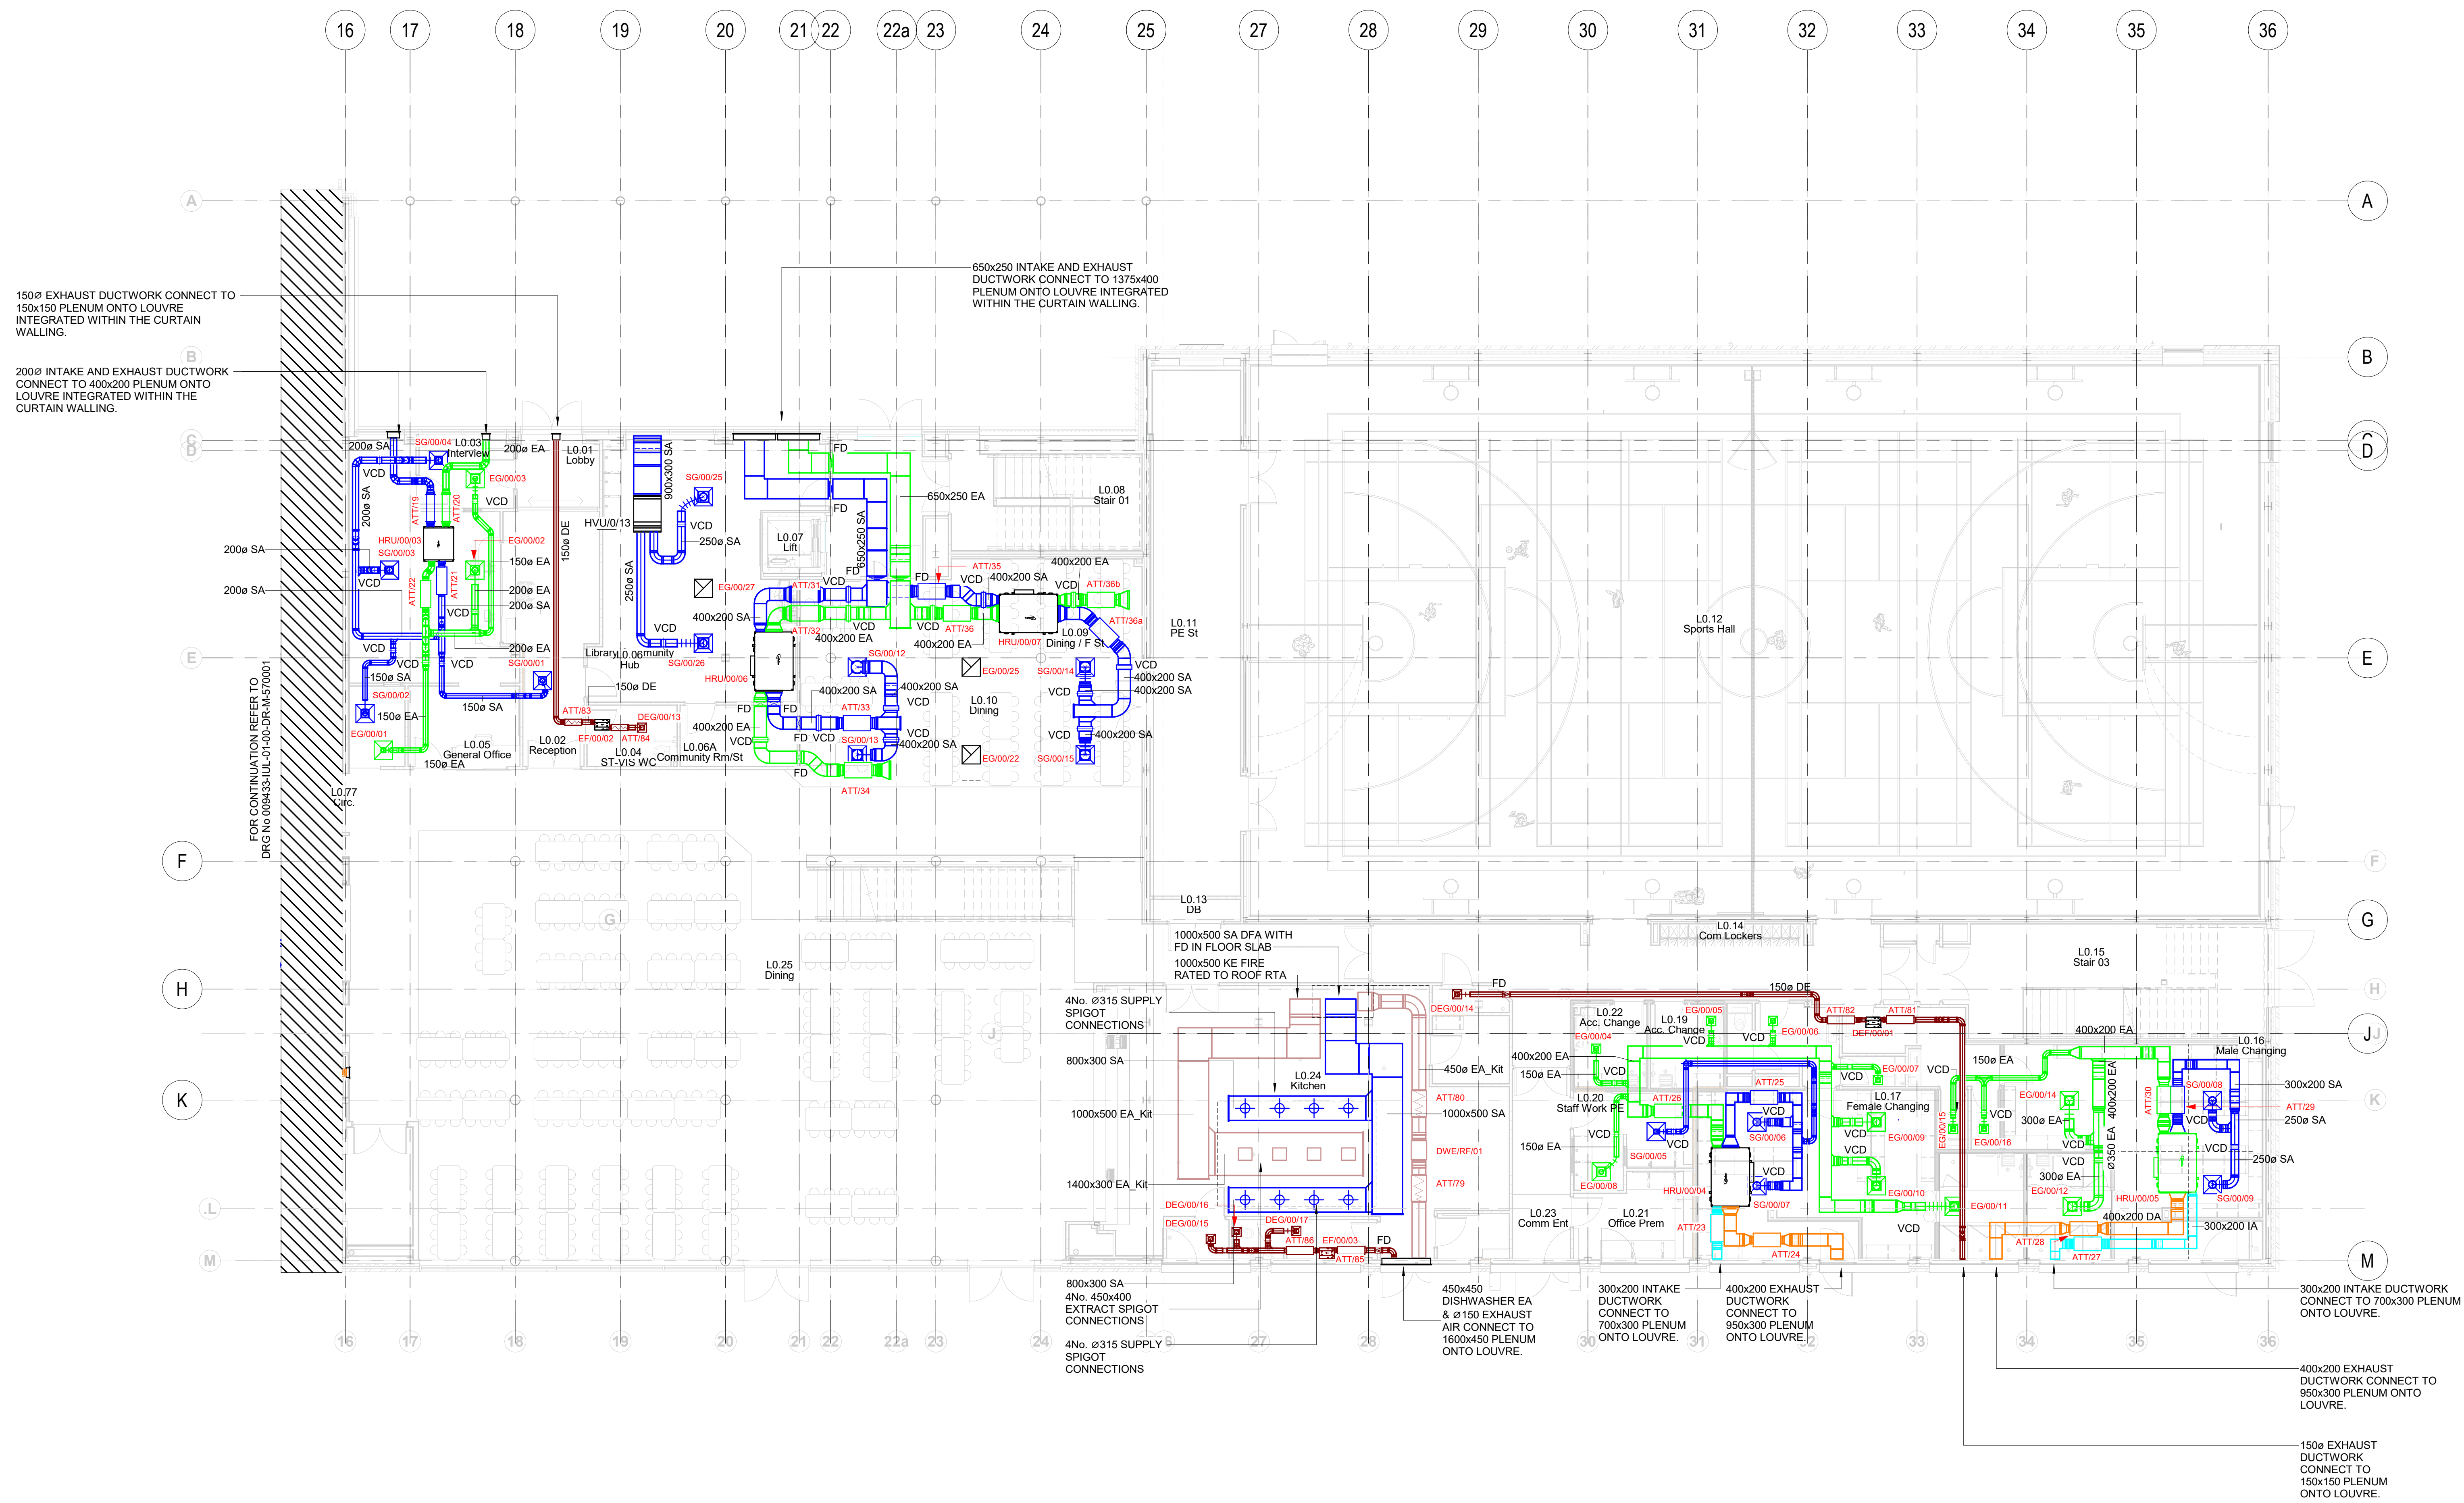

C04	CONSTRUCTION ISSUE - MAIN RISER SIZES AMENDED	A.W	G.G	11.02.22
C03	GENERAL CO-ORDINATION	A.W	G.G	04.01.22
C02	GENERAL CO-ORDINATION EXERCISE	A.W	G.G	12.11.21
C01	ISSUED FOR CONSTRUCTION	A.W	G.G	08.08.21
P01	CP ISSUE 1	A.W	G.G	14.05.21
Rev	Description	By	App	Date

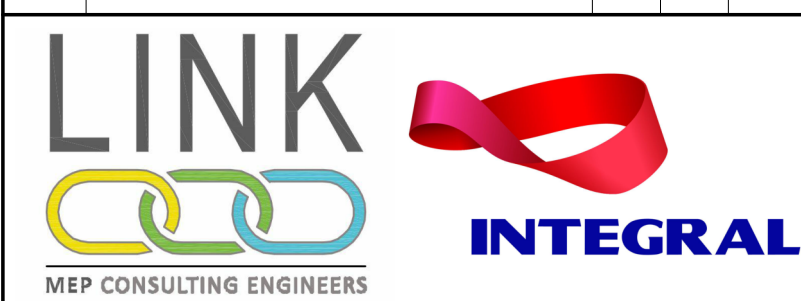

Client

MANCHESTER CITY COUNCIL



Project Title

BELLE VUE CO-OP ACADEMY

Drawing Title

LEVEL 00
VENTILATION
LAYOUT 2 of 2

Scale @ A0 1:100	Description/Issued For CONSTRUCTION	Status S4
Drawing Number 009433-IUL-01-00-DR-M-570002		Revision C04

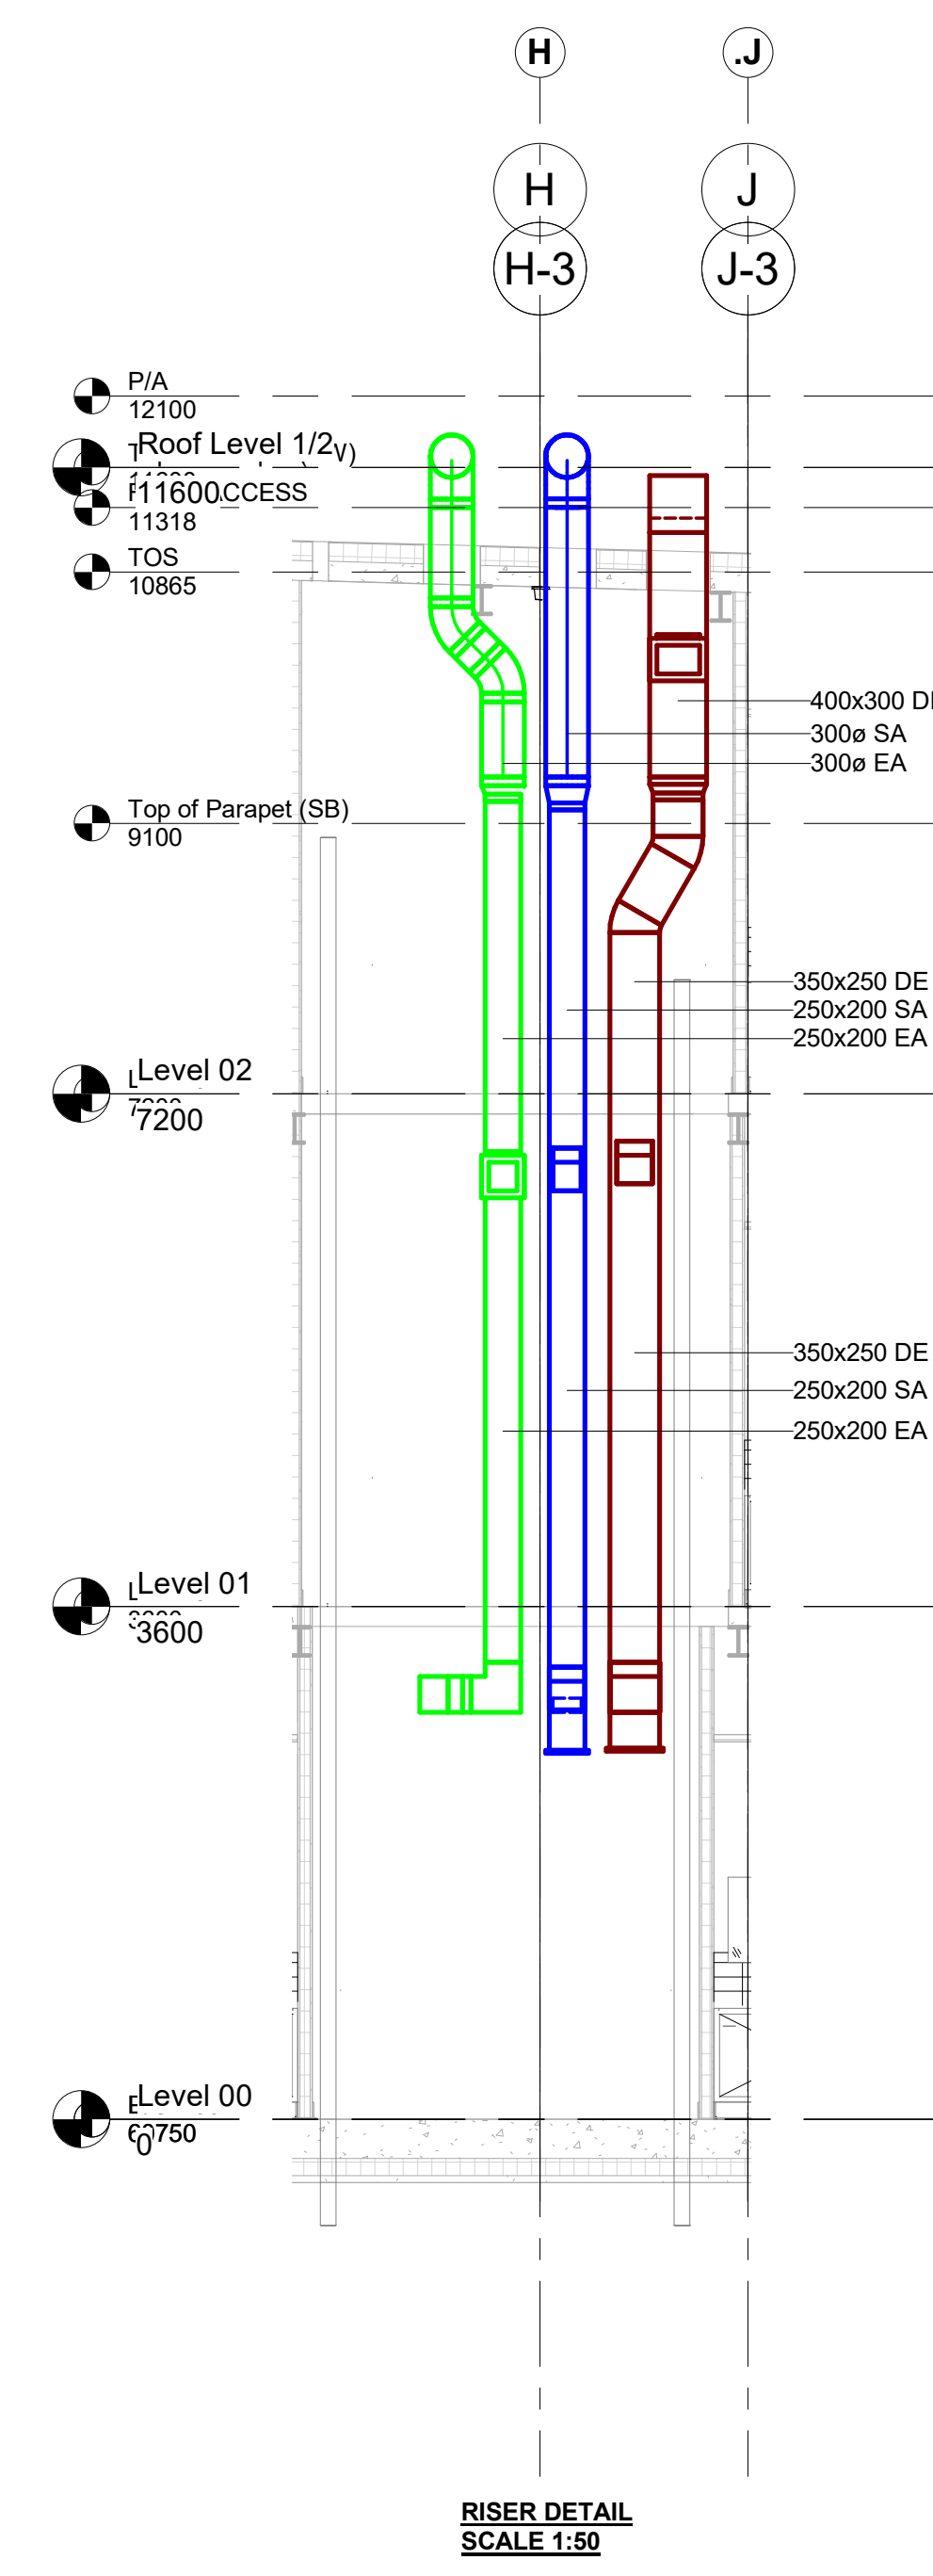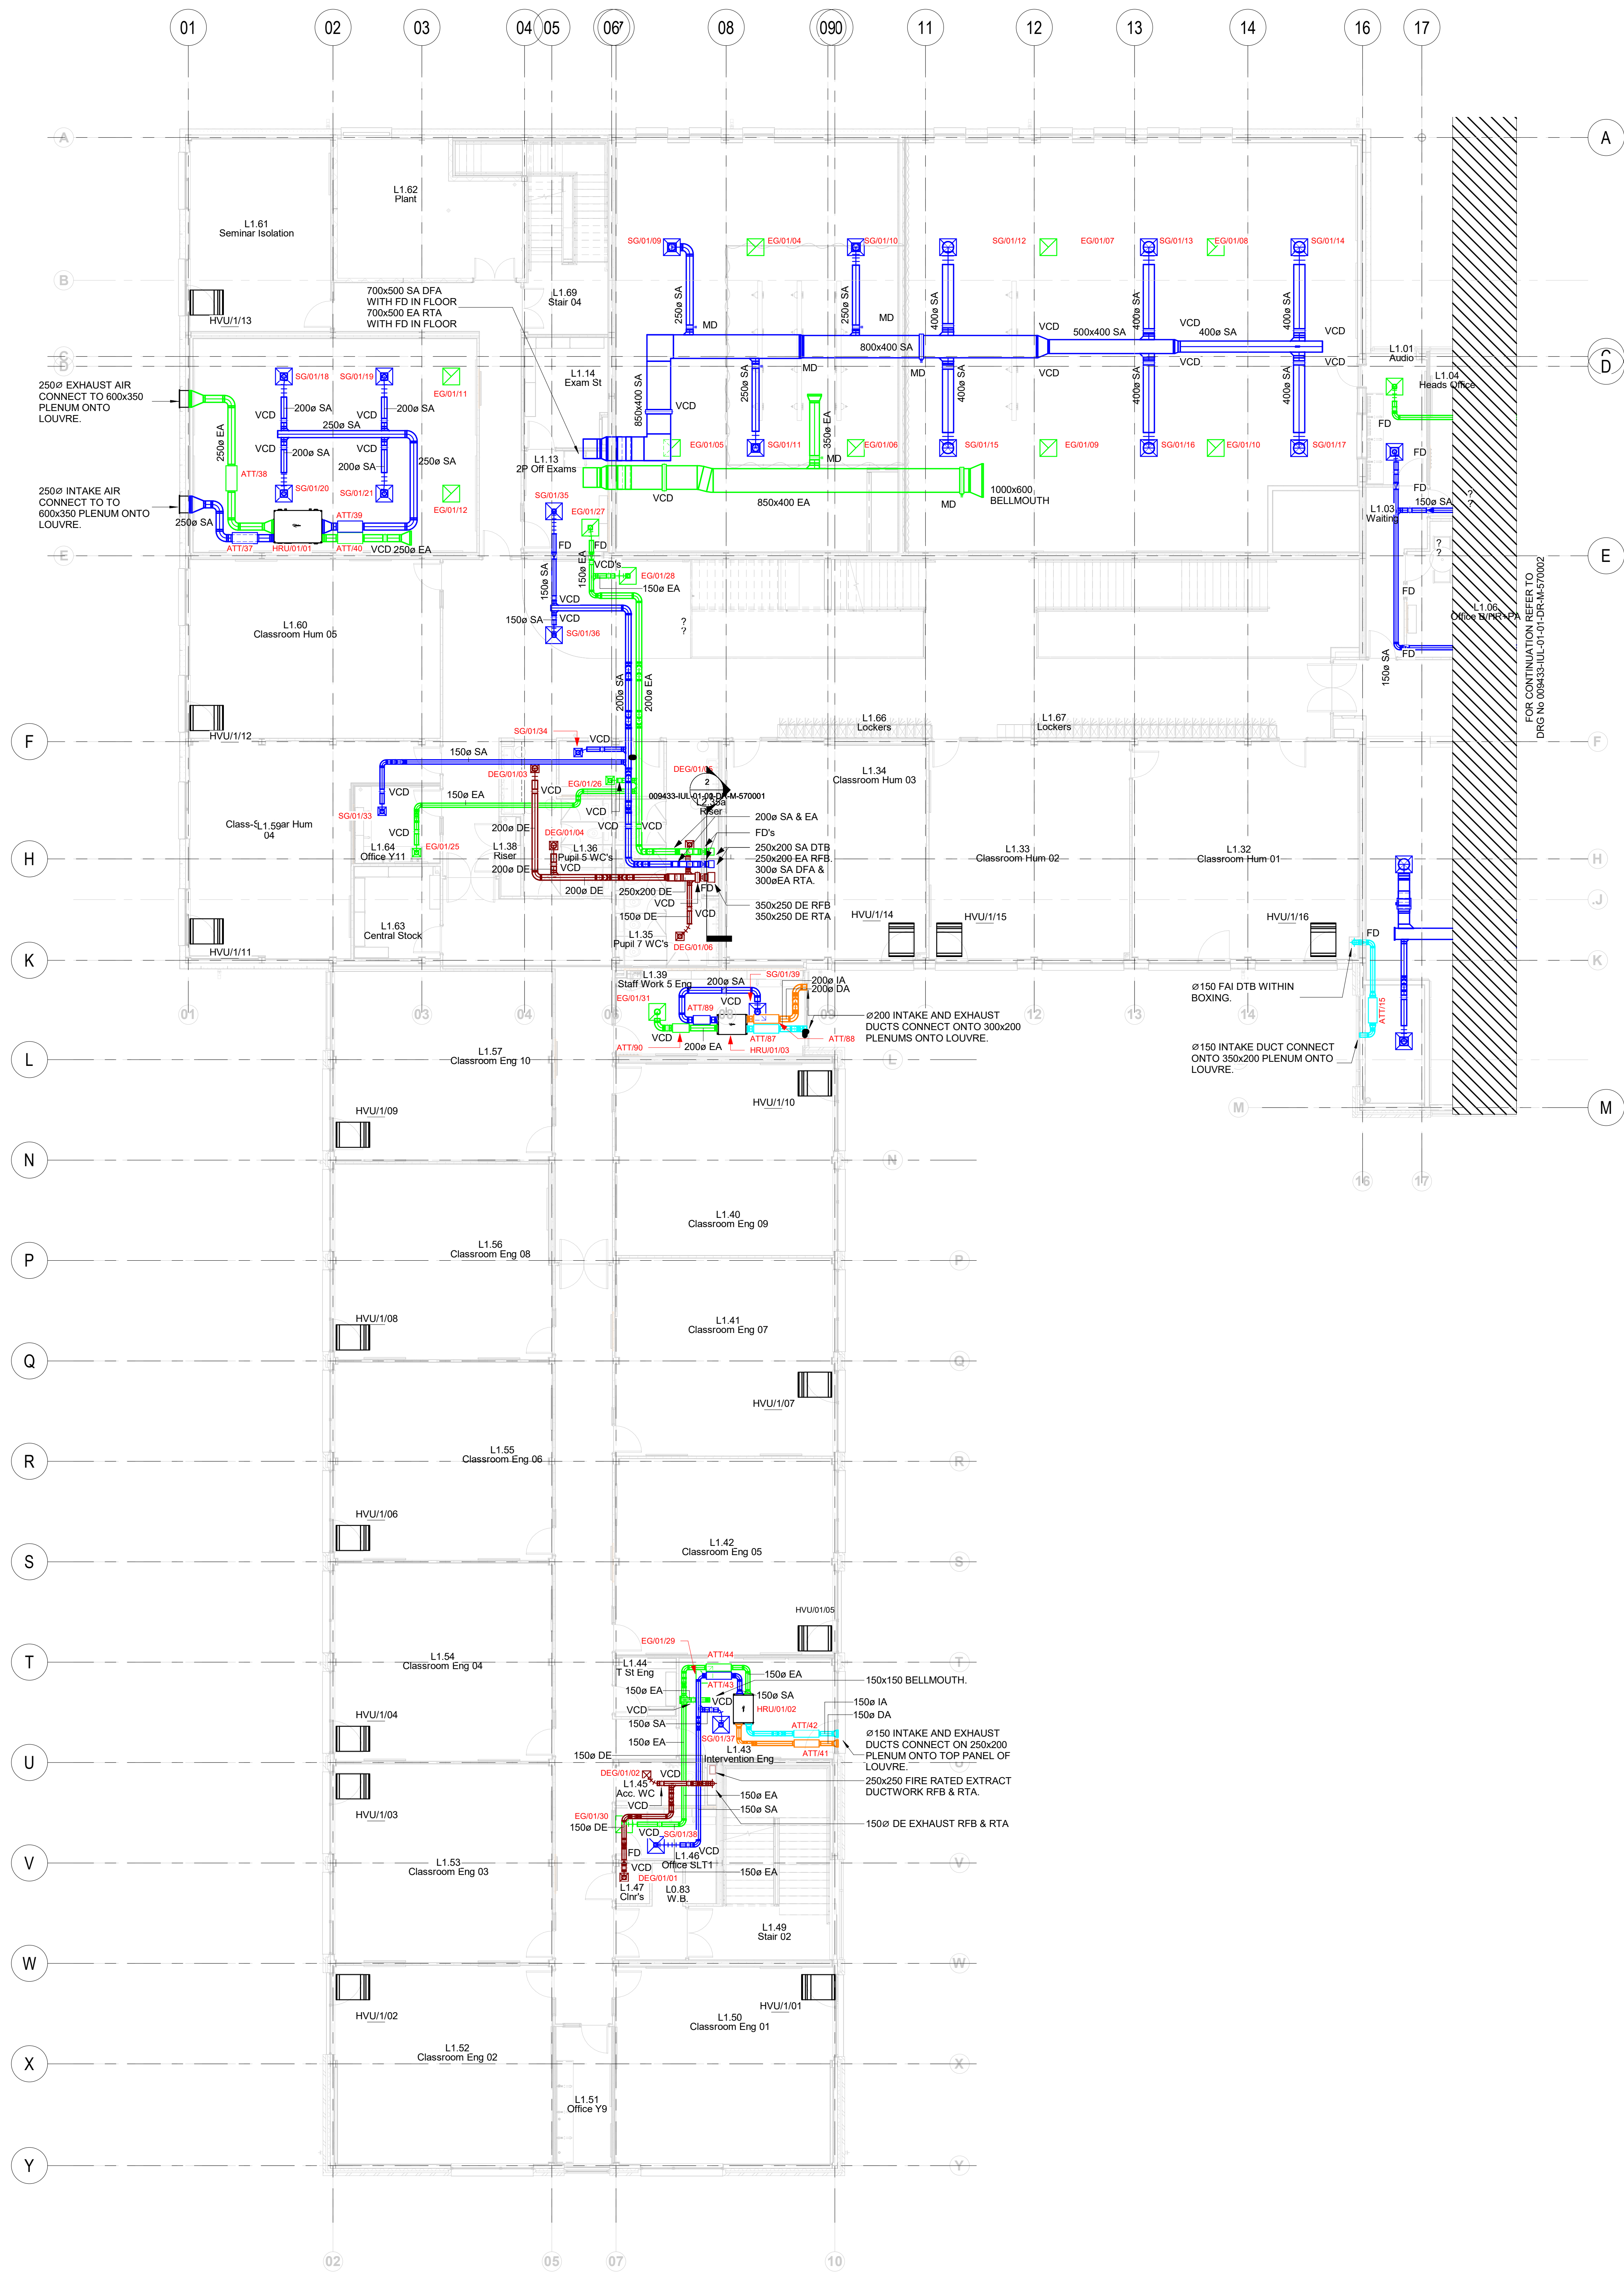


Safety, Health and Environmental Information			
IN ADDITION TO THE HAZARDS / RISKS NORMALLY ASSOCIATED WITH THE TYPE OF WORK DETAILED ON THIS DRAWING, NOTE THE FOLLOWING:			
Construction			
Maintenance/Cleaning			
Decommissioning/Demolition			

NOTES:



1. THIS DRAWING IS TO BE READ IN CONJUNCTION WITH THE PROJECT SPECIFIC M&S SPECIFICATIONS AND THE PROJECT SPECIFIC DESIGNERS RISK ASSESSMENTS.

2. ALL DUCTWORK THROUGH FIRE COMPARTMENTATION TO HAVE FIRE DAMPERS.

C06	DUCTWORK SIZES AMENDED TO GRILLES (DEG0103 & 04)	A.W.	G.G.	25.02.22
C04	CONSTRUCTION ISSUE - MAIN RISER SIZES AMENDED	A.W.	G.G.	11.02.22
C03	GENERAL CO-ORDINATION	A.W.	G.G.	04.01.22
C02	GENERAL CO-ORDINATION EXERCISE	A.W.	G.G.	12.11.21
C01	ISSUED FOR CONSTRUCTION	A.W.	G.G.	06.09.21
P01	CP ISSUE 1	A.W.	G.G.	14.05.21

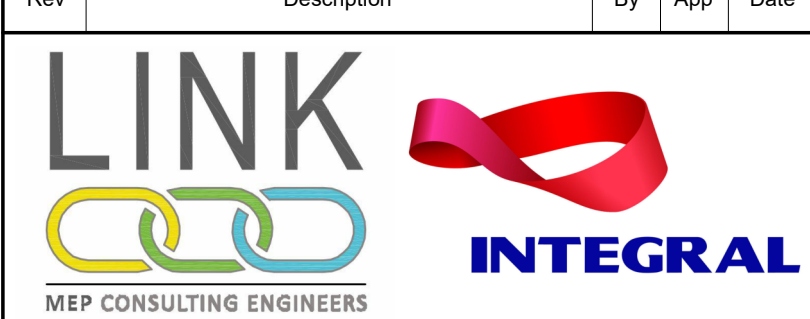


Client			
MANCHESTER CITY COUNCIL			
Project Title			
BELLE VUE CO-OP ACADEMY			
Drawing Title			
LEVEL 01 VENTILATION LAYOUT 1 of 2			
Scale @ A0	Description/Issued For	Status	
1:100	CONSTRUCTION	S4	
Drawing Number	Revision		
009433-IUL-01-01-DR-M-570001	C05		

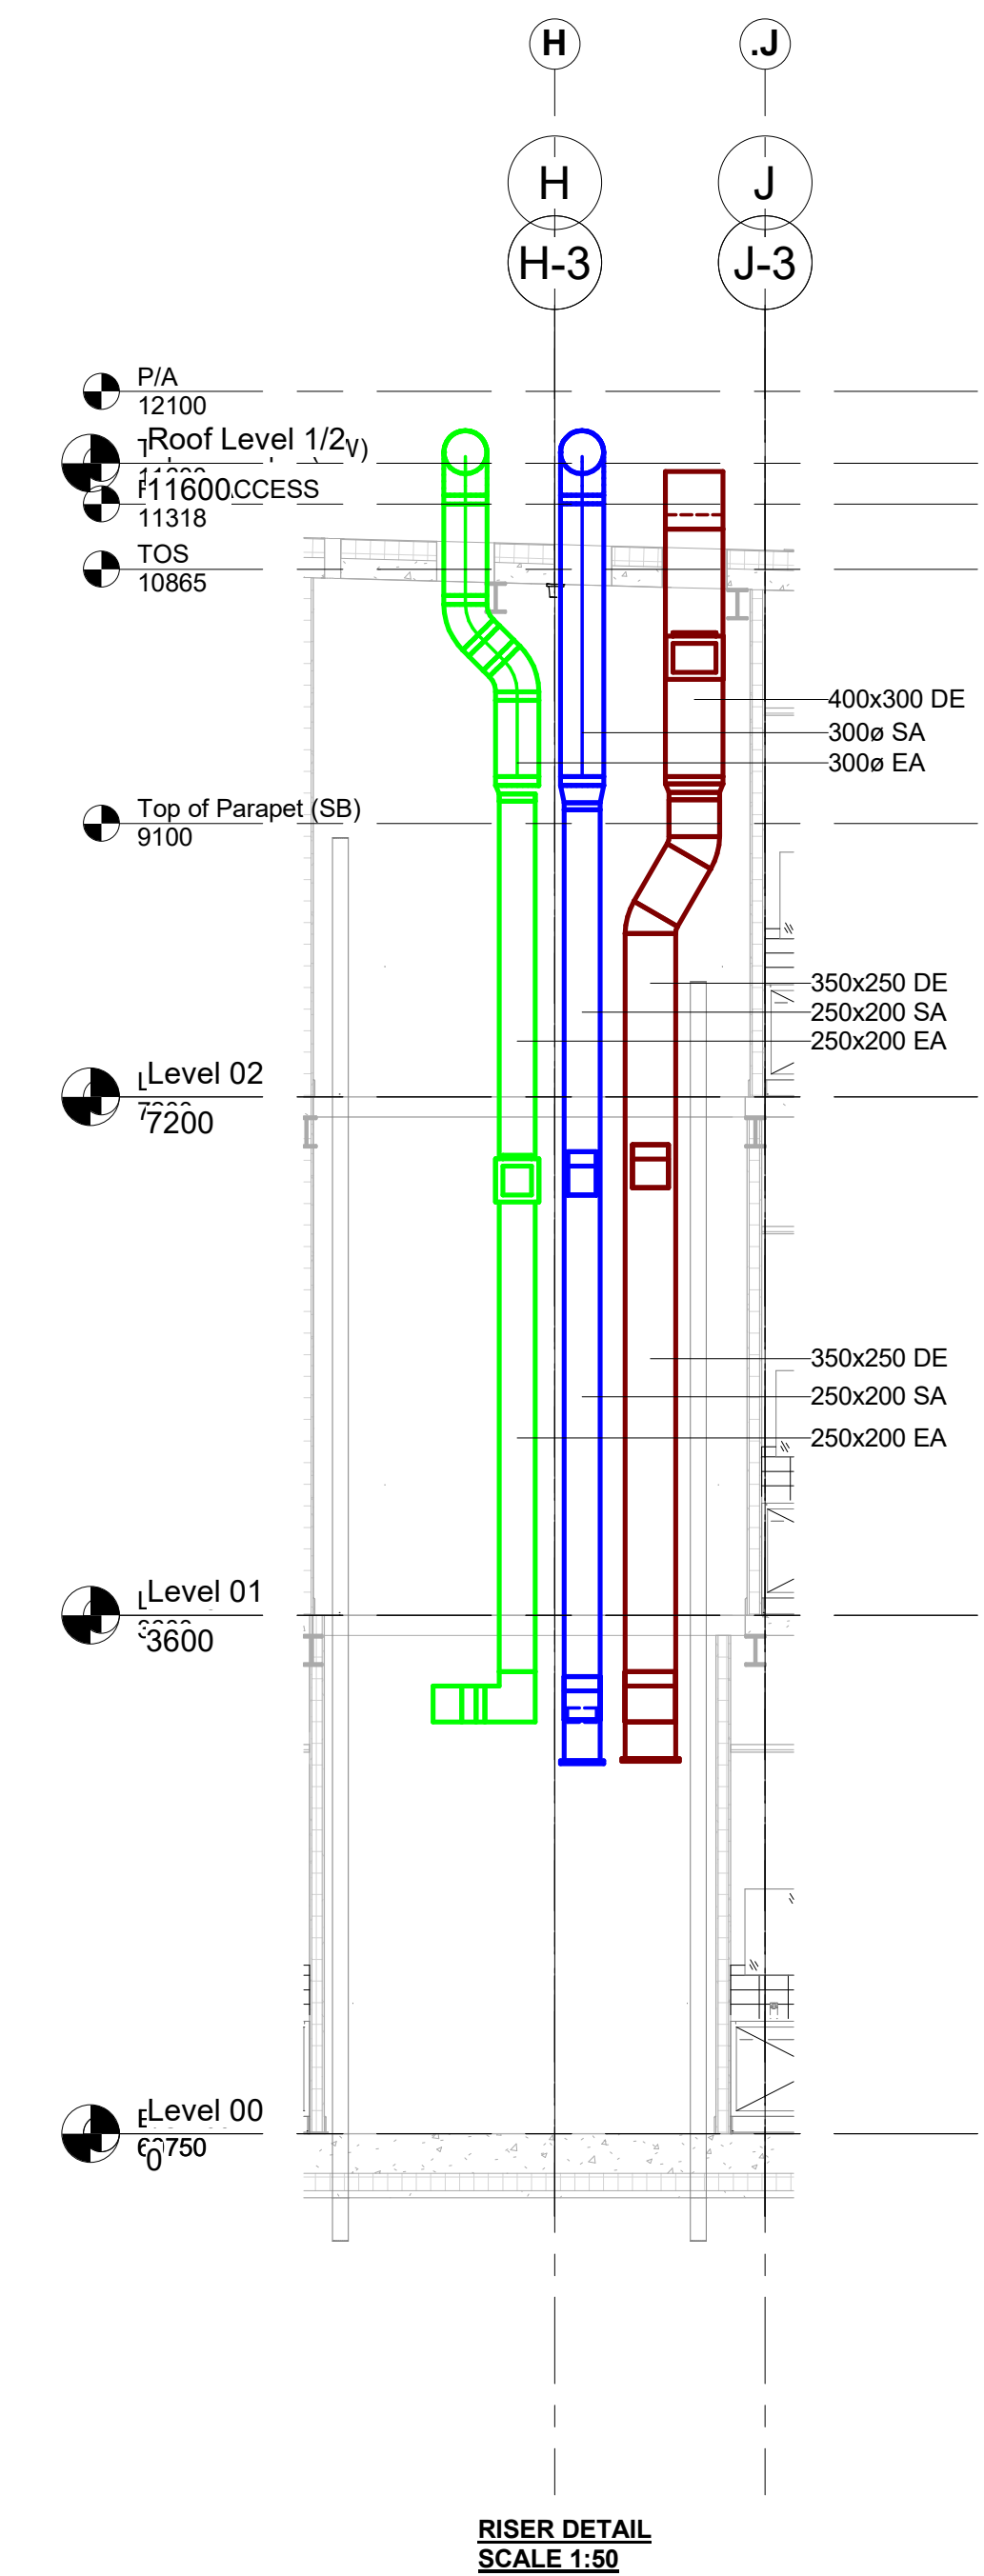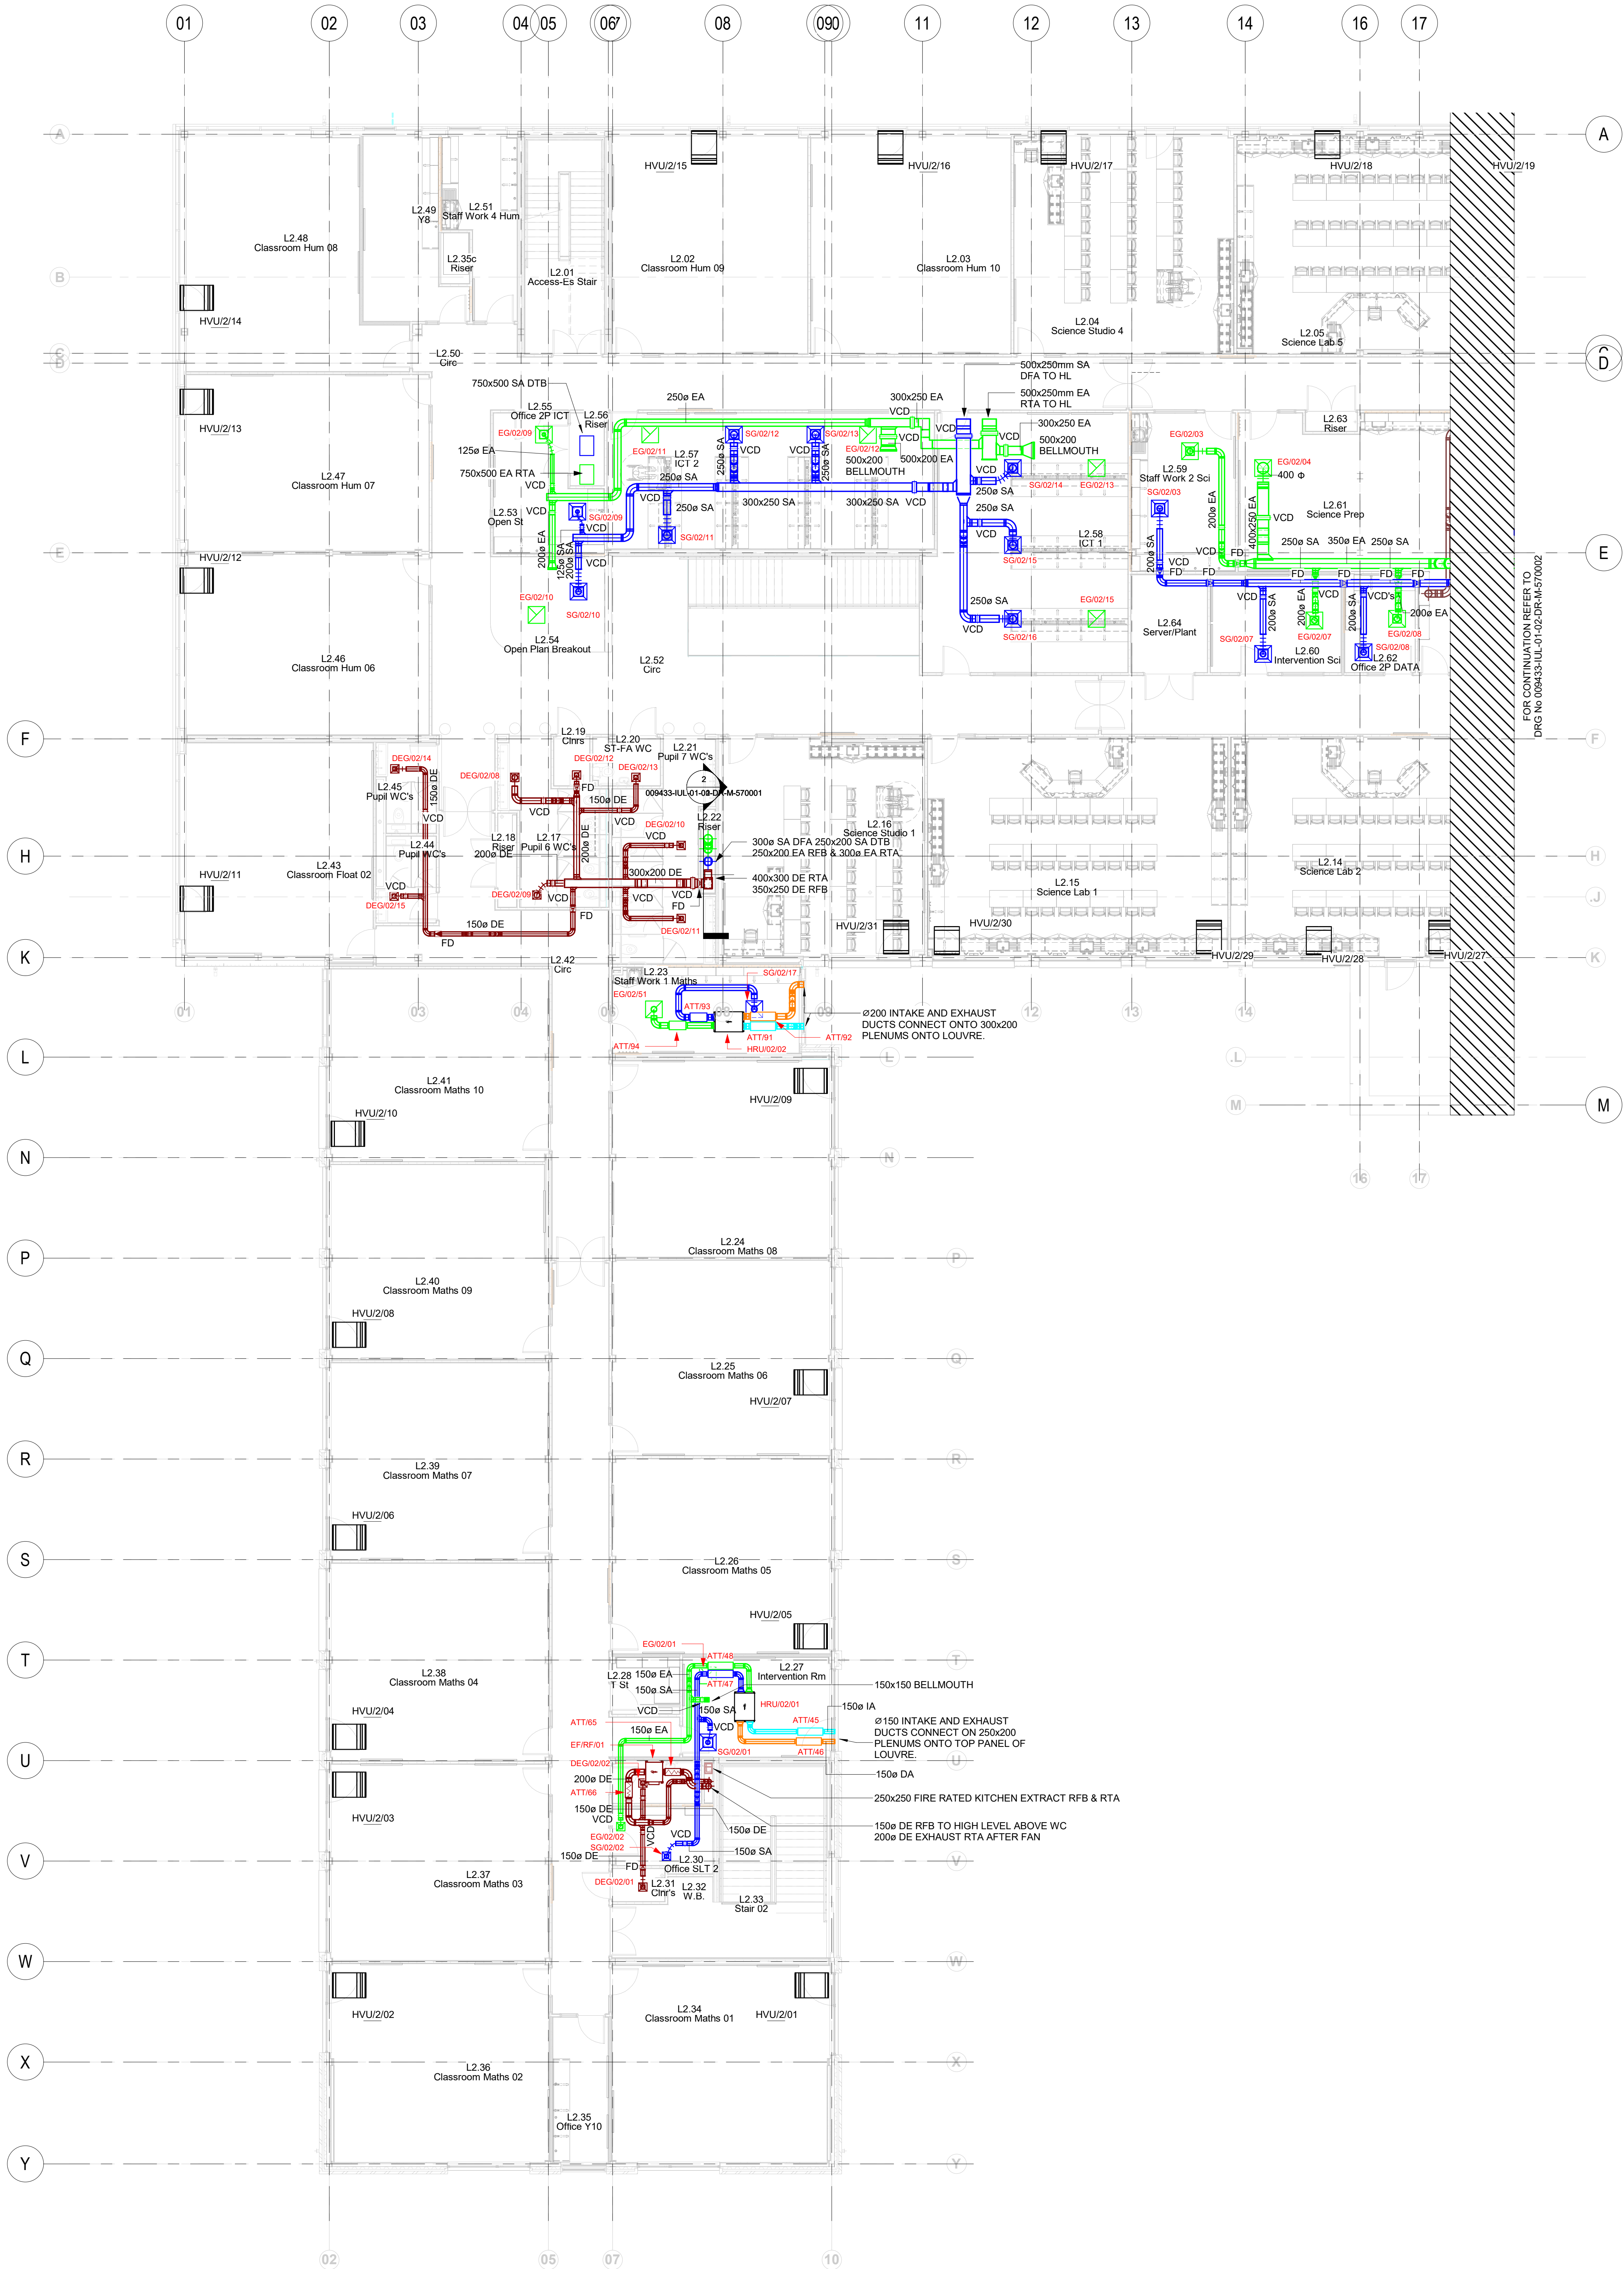

Safety, Health and Environmental Information			
IN ADDITION TO THE HAZARDS / RISKS NORMALLY ASSOCIATED WITH THE TYPE OF WORK DETAILED ON THIS DRAWING, NOTE THE FOLLOWING:			
Construction			
Maintenance/Cleaning			
Decommissioning/Demolition			
IT IS ASSUMED THAT ALL WORKS WILL BE CARRIED OUT BY A COMPETENT CONTRACTOR WORKING, WHERE APPROPRIATE, TO AN APPROVED METHOD STATEMENT. THIS IS NOT AN EXHAUSTIVE LIST AND REFERENCE SHOULD BE MADE TO THE HEALTH AND SAFETY FILE.			

- NOTES:
- THIS DRAWING IS TO BE READ IN CONJUNCTION WITH THE PROJECT SPECIFIC M&S SPECIFICATIONS AND THE PROJECT SPECIFIC DESIGNERS RISK ASSESSMENTS.
 - ALL DUCTWORK THROUGH FIRE COMPARTMENTATION TO HAVE FIRE DAMPERS.

Rev	Description	By	App	Date
C04	CONSTRUCTION ISSUE - MAIN RISER SIZES AMENDED	A.W.	G.G.	11.02.22
C03	GENERAL CO-ORDINATION	A.W.	G.G.	04.01.22
C02	GENERAL CO-ORDINATION EXERCISE	A.W.	G.G.	12.11.21
C01	ISSUED FOR CONSTRUCTION	A.W.	G.G.	06.09.21
P01	CP ISSUE 1	A.W.	G.G.	14.05.21

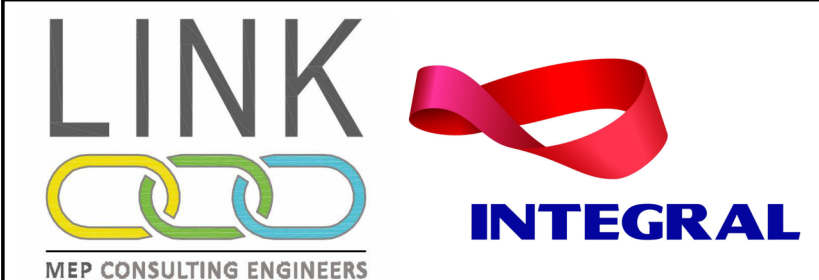

Client		MANCHESTER CITY COUNCIL	
Project Title		BELLE VUE CO-OP ACADEMY	
Drawing Title		LEVEL 02 VENTILATION LAYOUT 1 of 2	
Scale @ A0	Description/Issued For	Status	
1:100	CONSTRUCTION	S4	
Drawing Number	Revision		
009433-IUL-01-02-DR-M-570001	C04		

Safety, Health and Environmental Information

IN ADDITION TO THE HAZARDS / RISKS NORMALLY ASSOCIATED WITH THE TYPE OF WORK DETAILED ON THIS DRAWING, NOTE THE FOLLOWING:

Construction


Maintenance/Cleaning

Decommissioning/Demolition

IT IS ASSUMED THAT ALL WORKS WILL BE CARRIED OUT BY A COMPETENT CONTRACTOR WORKING, WHERE APPROPRIATE, TO AN APPROVED METHOD STATEMENT. THIS IS NOT AN EXHAUSTIVE LIST AND REFERENCE SHOULD BE MADE TO THE HEALTH AND SAFETY FILE.


NOTES:

- THIS DRAWING IS TO BE READ IN CONJUNCTION WITH THE PROJECT SPECIFIC M&S SPECIFICATIONS AND THE PROJECT SPECIFIC DESIGNERS RISK ASSESSMENTS.
- ALL DUCTWORK THROUGH FIRE COMPARTMENTATION TO HAVE FIRE DAMPERS.

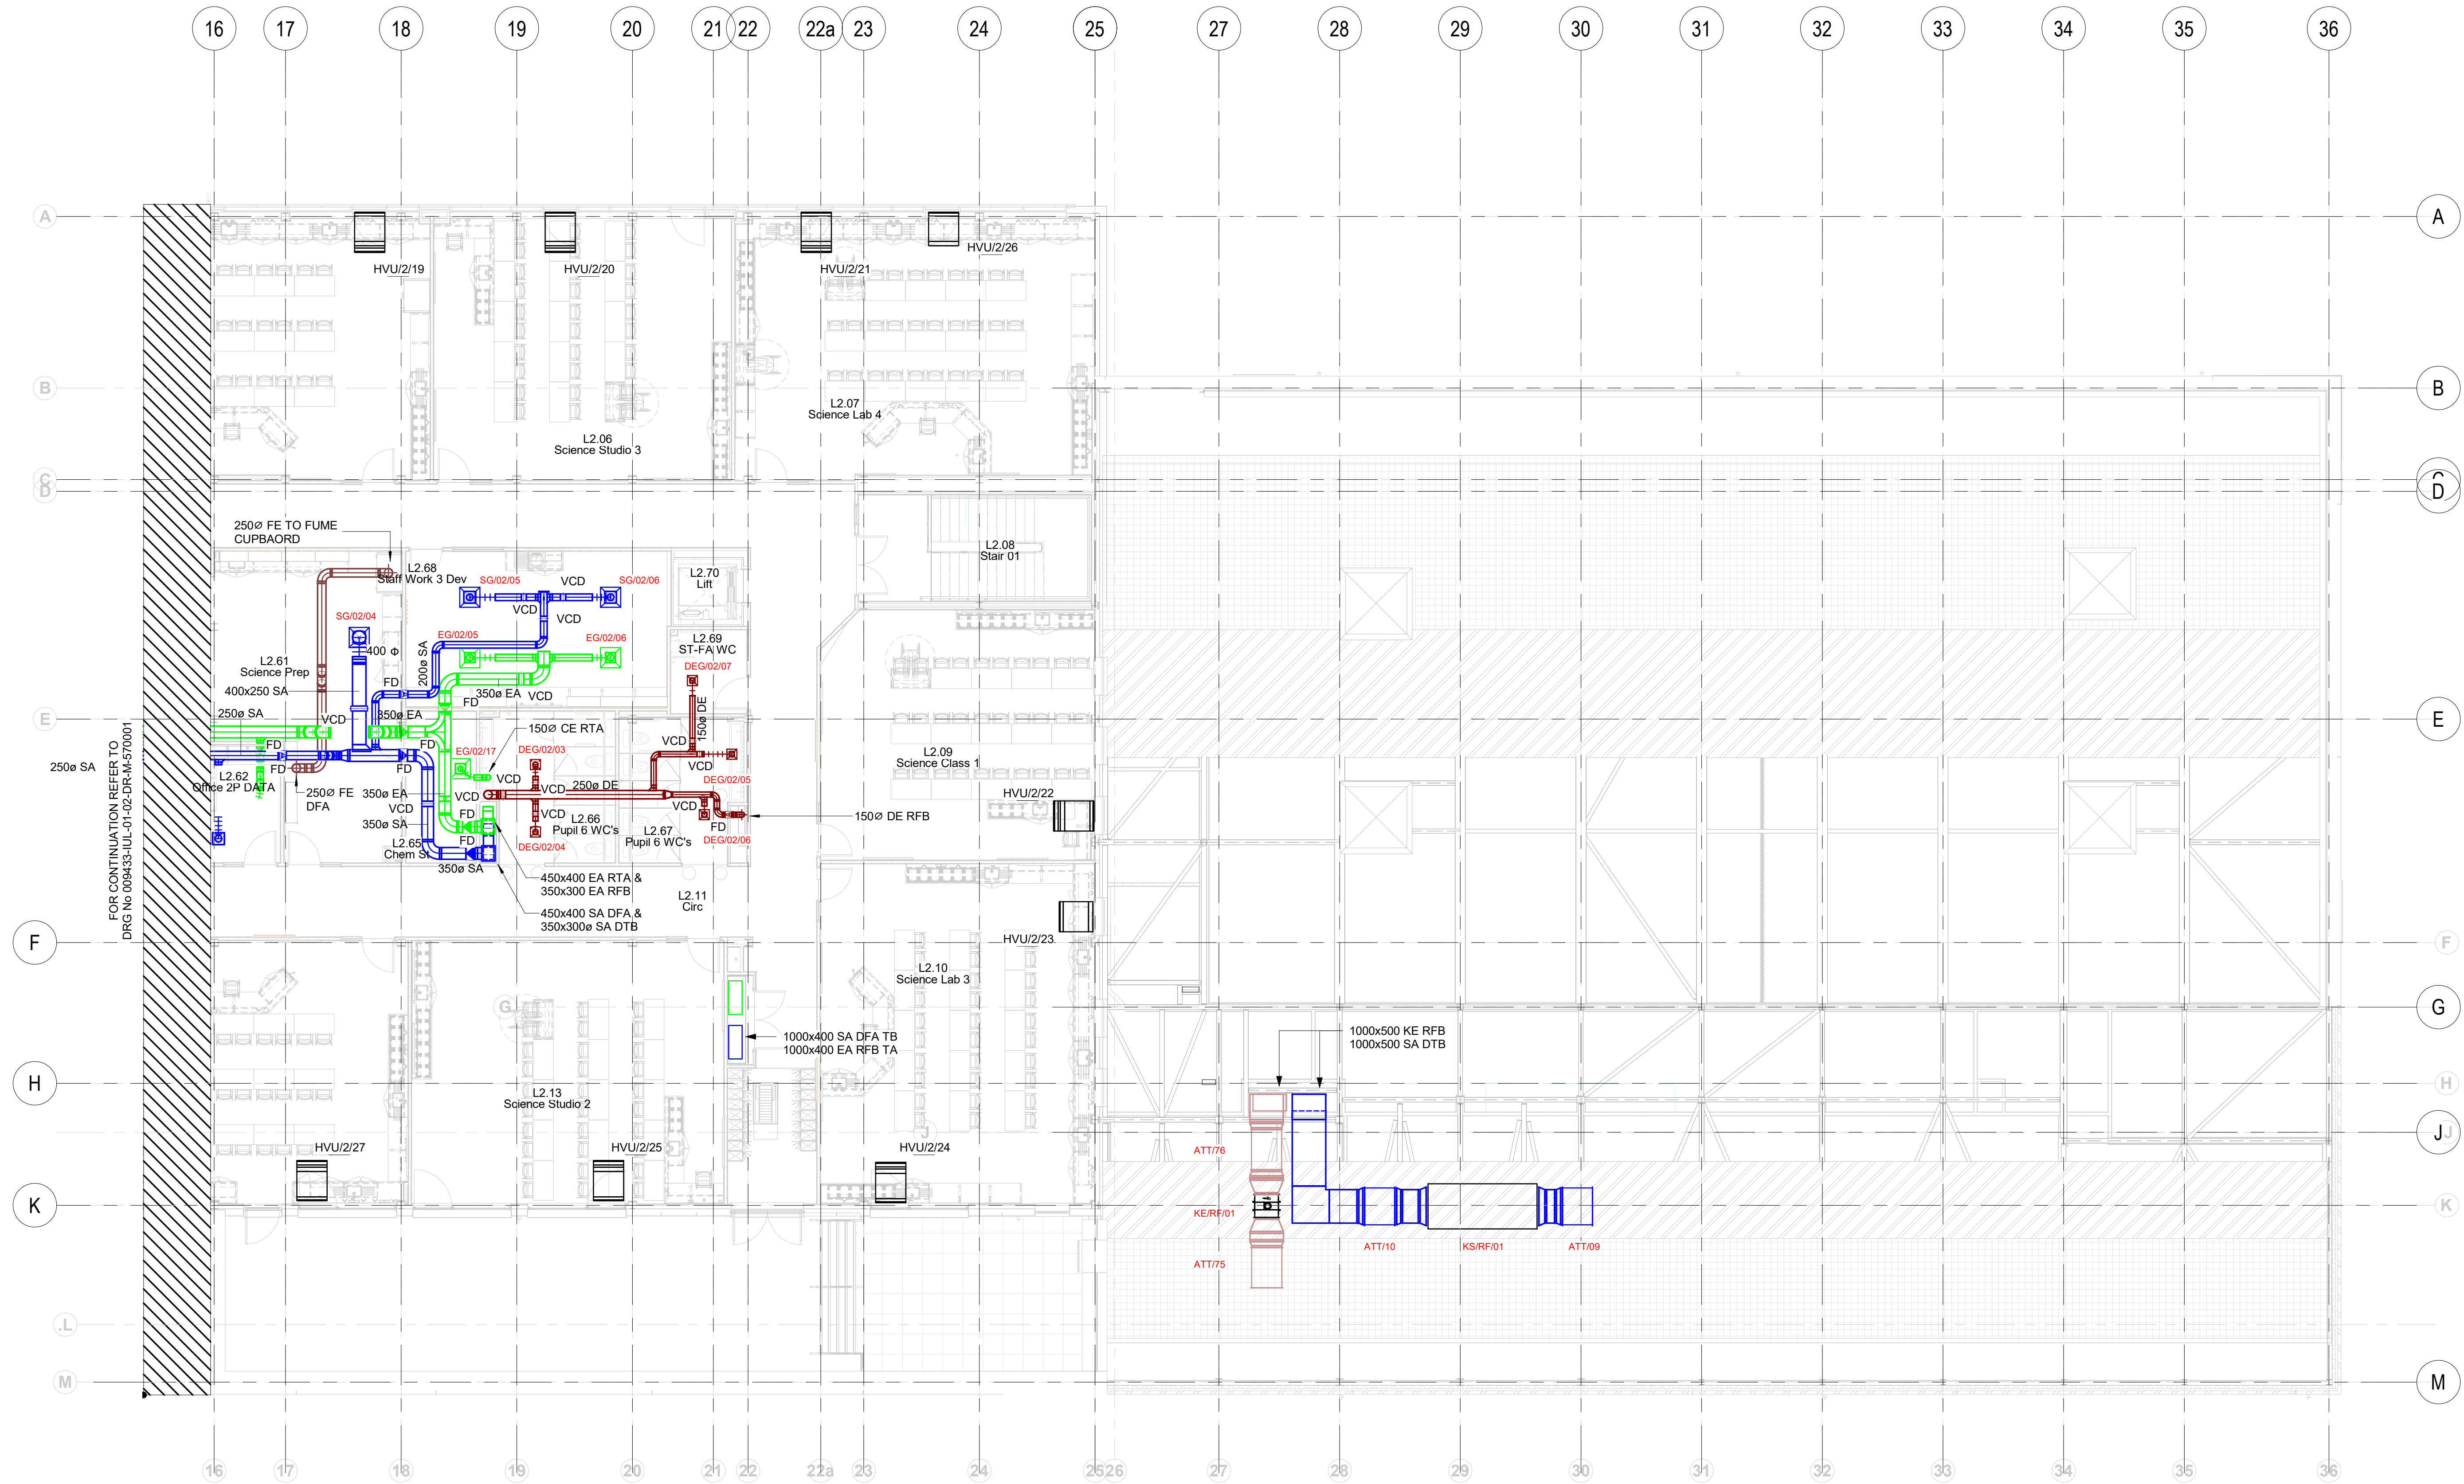

C04	CONSTRUCTION ISSUE - MAIN RISER SIZES (AMENDED)	A.W.	G.G.	11.02.22
C03	GENERAL CO-ORDINATION	A.W.	G.G.	04.01.22
C02	GENERAL CO-ORDINATION EXERCISE	A.W.	G.G.	12.11.21
C01	ISSUED FOR CONSTRUCTION	A.W.	G.G.	06.09.21
P01	CP ISSUE 1	A.W.	G.G.	14.05.21

Rev	Description	By	App	Date
-----	-------------	----	-----	------

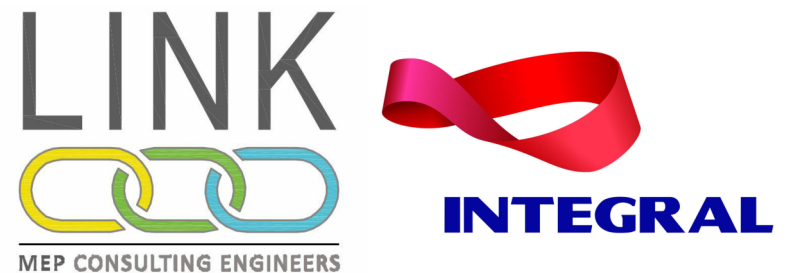


Client
MANCHESTER CITY COUNCIL

Project Title
BELLE VUE CO-OP ACADEMY

Drawing Title
LEVEL 02
VENTILATION
LAYOUT 2 of 2

Scale @ A0	Description/Issued For	Status
1:100	CONSTRUCTION	S4
Drawing Number	Revision	
009433-IUL-01-02-DR-M-570002	C04	

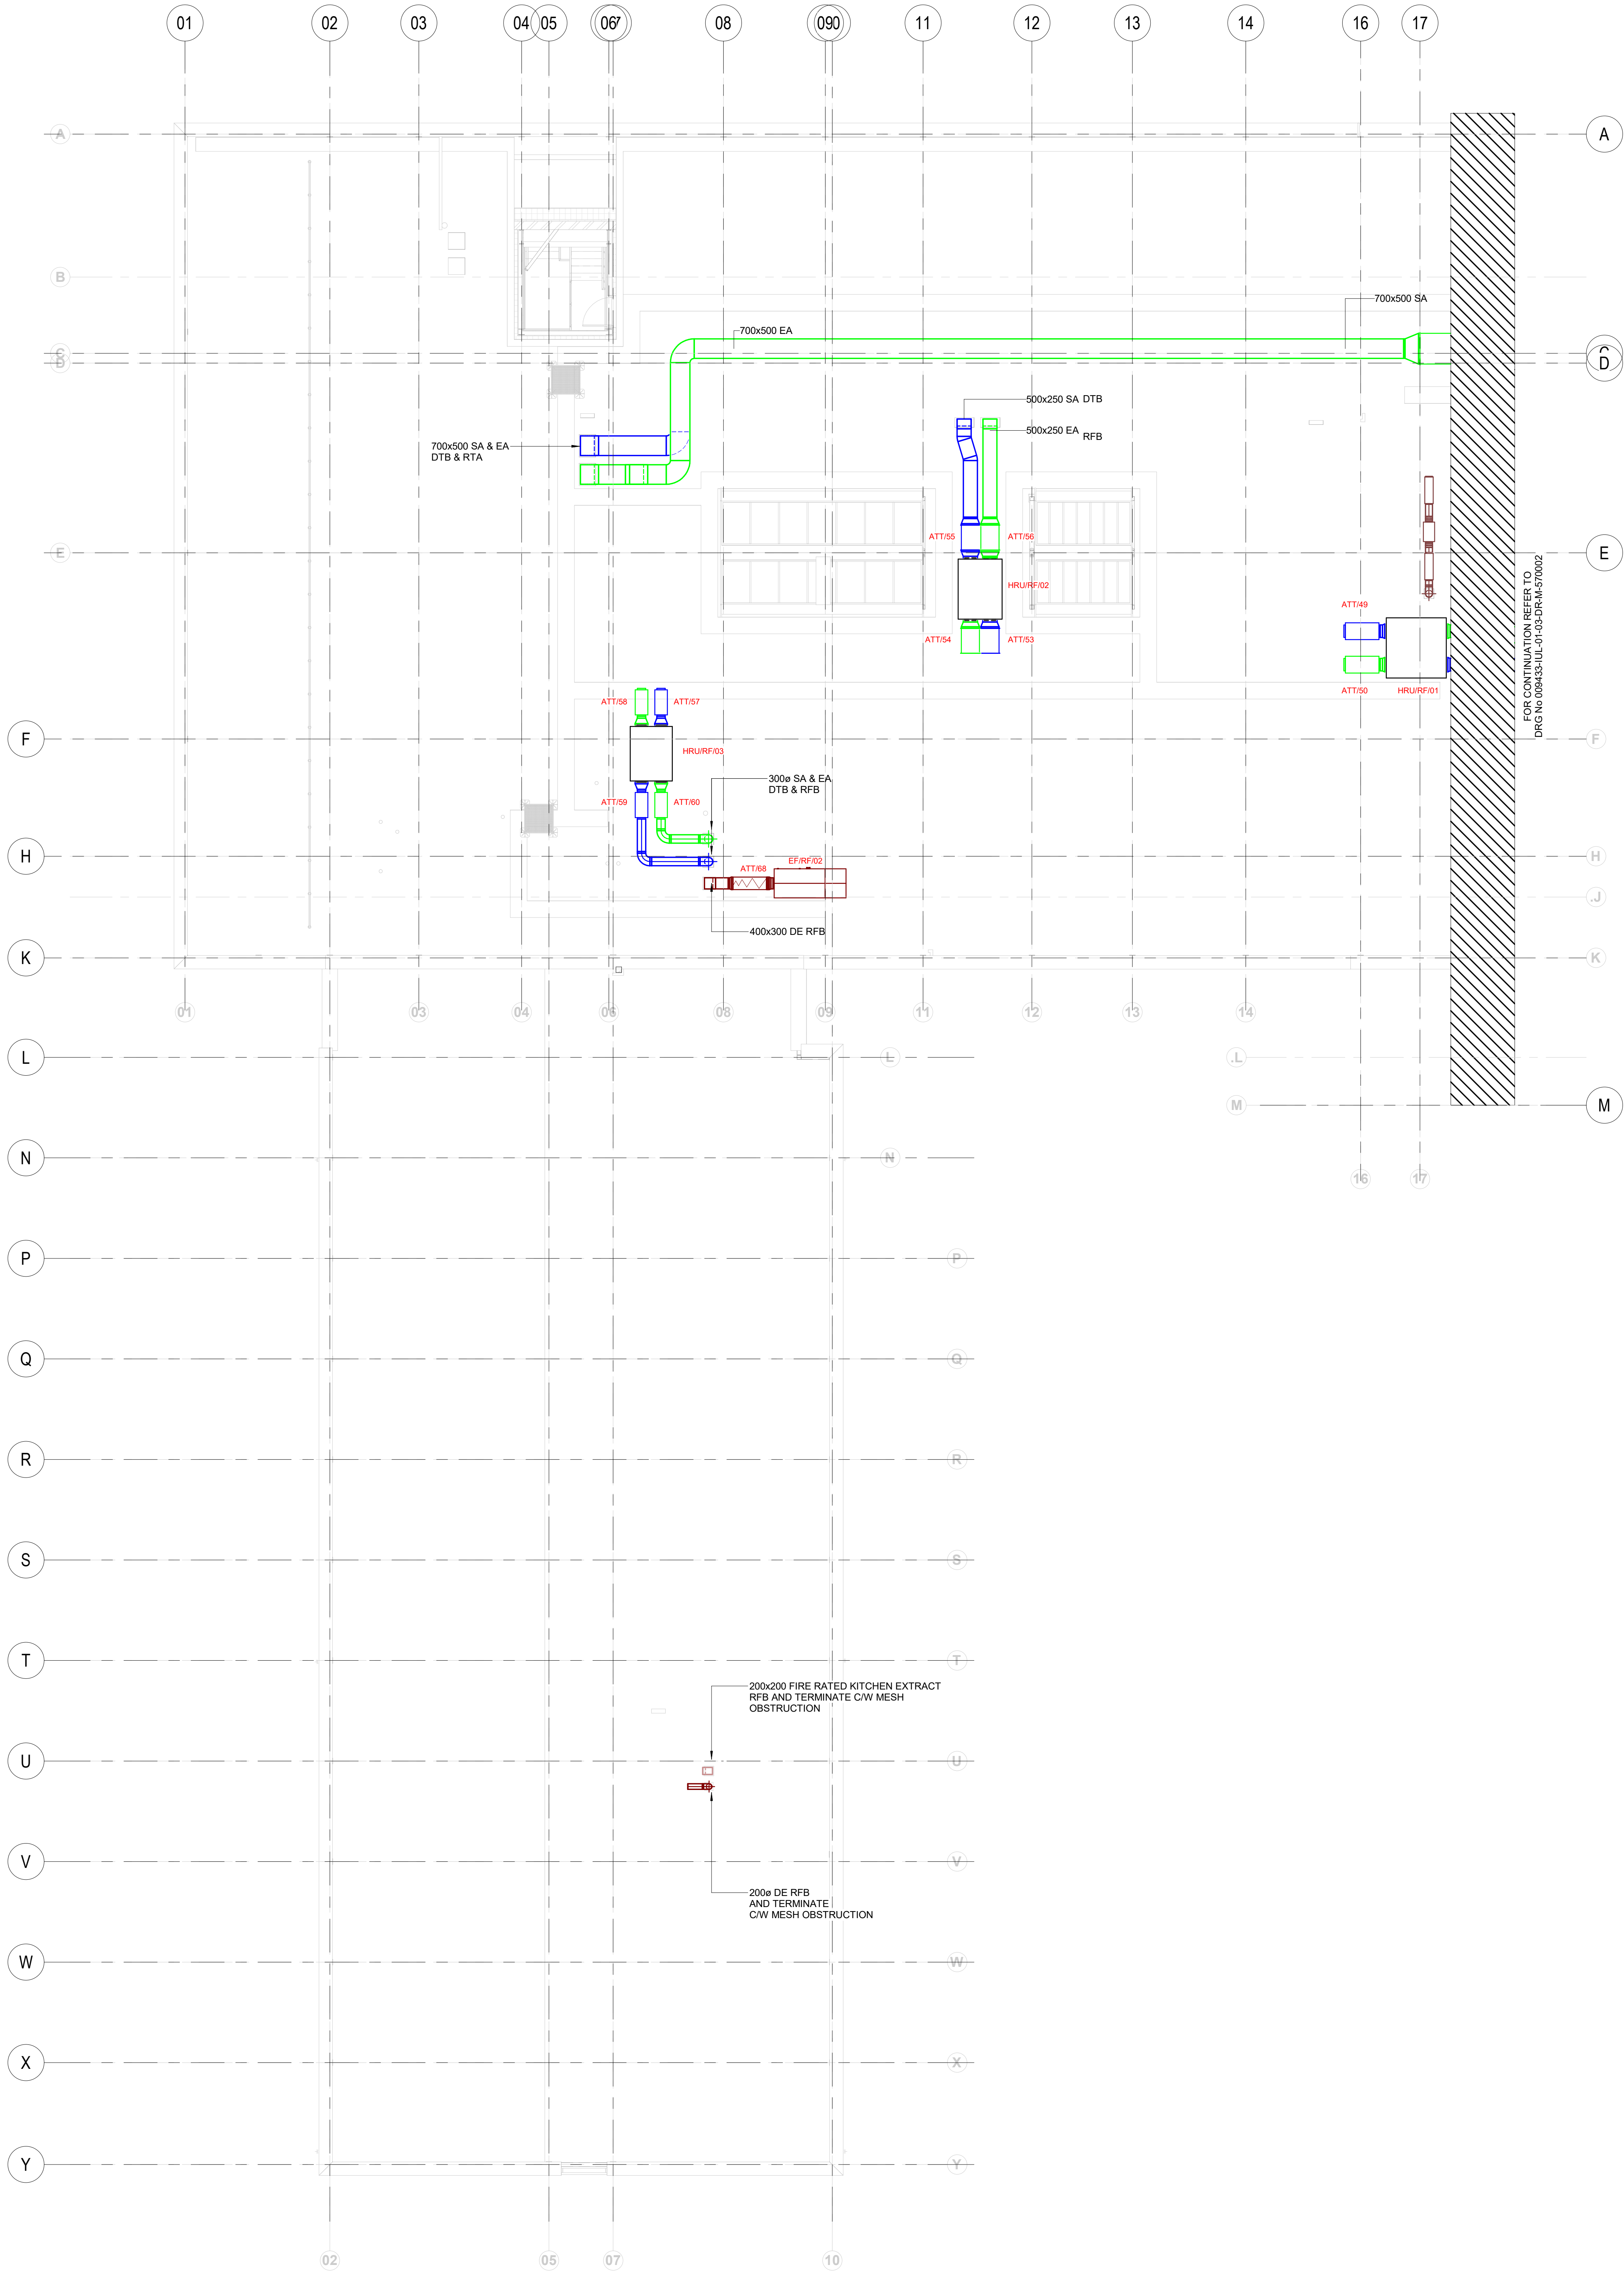

Safety, Health and Environmental Information		
IN ADDITION TO THE HAZARDS / RISKS NORMALLY ASSOCIATED WITH THE TYPE OF WORK DETAILED ON THIS DRAWING, NOTE THE FOLLOWING:		
Construction		
Maintenance/Cleaning		
Decommissioning/Demolition		
IT IS ASSUMED THAT ALL WORKS WILL BE CARRIED OUT BY A COMPETENT CONTRACTOR WORKING, WHERE APPROPRIATE, TO AN APPROVED METHOD STATEMENT. THIS IS NOT AN EXHAUSTIVE LIST AND REFERENCE SHOULD BE MADE TO THE HEALTH AND SAFETY FILE.		

- NOTES:
1. THIS DRAWING IS TO BE READ IN CONJUNCTION WITH THE PROJECT SPECIFIC M&S SPECIFICATIONS AND THE PROJECT SPECIFIC DESIGNERS RISK ASSESSMENTS.
 2. ALL DUCTWORK THROUGH FIRE COMPARTMENTATION TO HAVE FIRE DAMPERS.

C04	CONSTRUCTION ISSUE - MAIN RISER SIZES AMENDED	A.W.	G.G.	11.02.22
C03	GENERAL CO-ORDINATION	A.W.	G.G.	04.01.22
C02	GENERAL CO-ORDINATION EXERCISE	A.W.	G.G.	12.11.21
C01	ISSUED FOR CONSTRUCTION	A.W.	G.G.	06.09.21
P01	CP ISSUE 1	A.W.	G.G.	14.05.21

Rev	Description	By	App	Date
LINK MEP CONSULTING ENGINEERS INTEGRAL MEP CONSULTING ENGINEERS				

Client	MANCHESTER CITY COUNCIL		
Project Title	BELLE VUE CO-OP ACADEMY		
Drawing Title	LEVEL 03 VENTILATION LAYOUT 1 of 2		
Scale @ A0	Description/Issued For	Status	
1:100	CONSTRUCTION	S4	
Drawing Number	Revision		
009433-IUL-01-03-DR-M-570001	C04		

Safety, Health and Environmental Information

IN ADDITION TO THE HAZARDS / RISKS NORMALLY ASSOCIATED WITH THE TYPE OF WORK DETAILED ON THIS DRAWING, NOTE THE FOLLOWING:

Construction


Maintenance/Cleaning

Decommissioning/Demolition

IT IS ASSUMED THAT ALL WORKS WILL BE CARRIED OUT BY A COMPETENT CONTRACTOR WORKING, WHERE APPROPRIATE, TO AN APPROVED METHOD STATEMENT. THIS IS NOT AN EXHAUSTIVE LIST AND REFERENCE SHOULD BE MADE TO THE HEALTH AND SAFETY FILE.


NOTES:

1. THIS DRAWING IS TO BE READ IN CONJUNCTION WITH THE PROJECT SPECIFIC M&S SPECIFICATIONS AND THE PROJECT SPECIFIC DESIGNERS RISK ASSESSMENTS.
2. ALL DUCTWORK THROUGH FIRE COMPARTMENTATION TO HAVE FIRE DAMPERS.

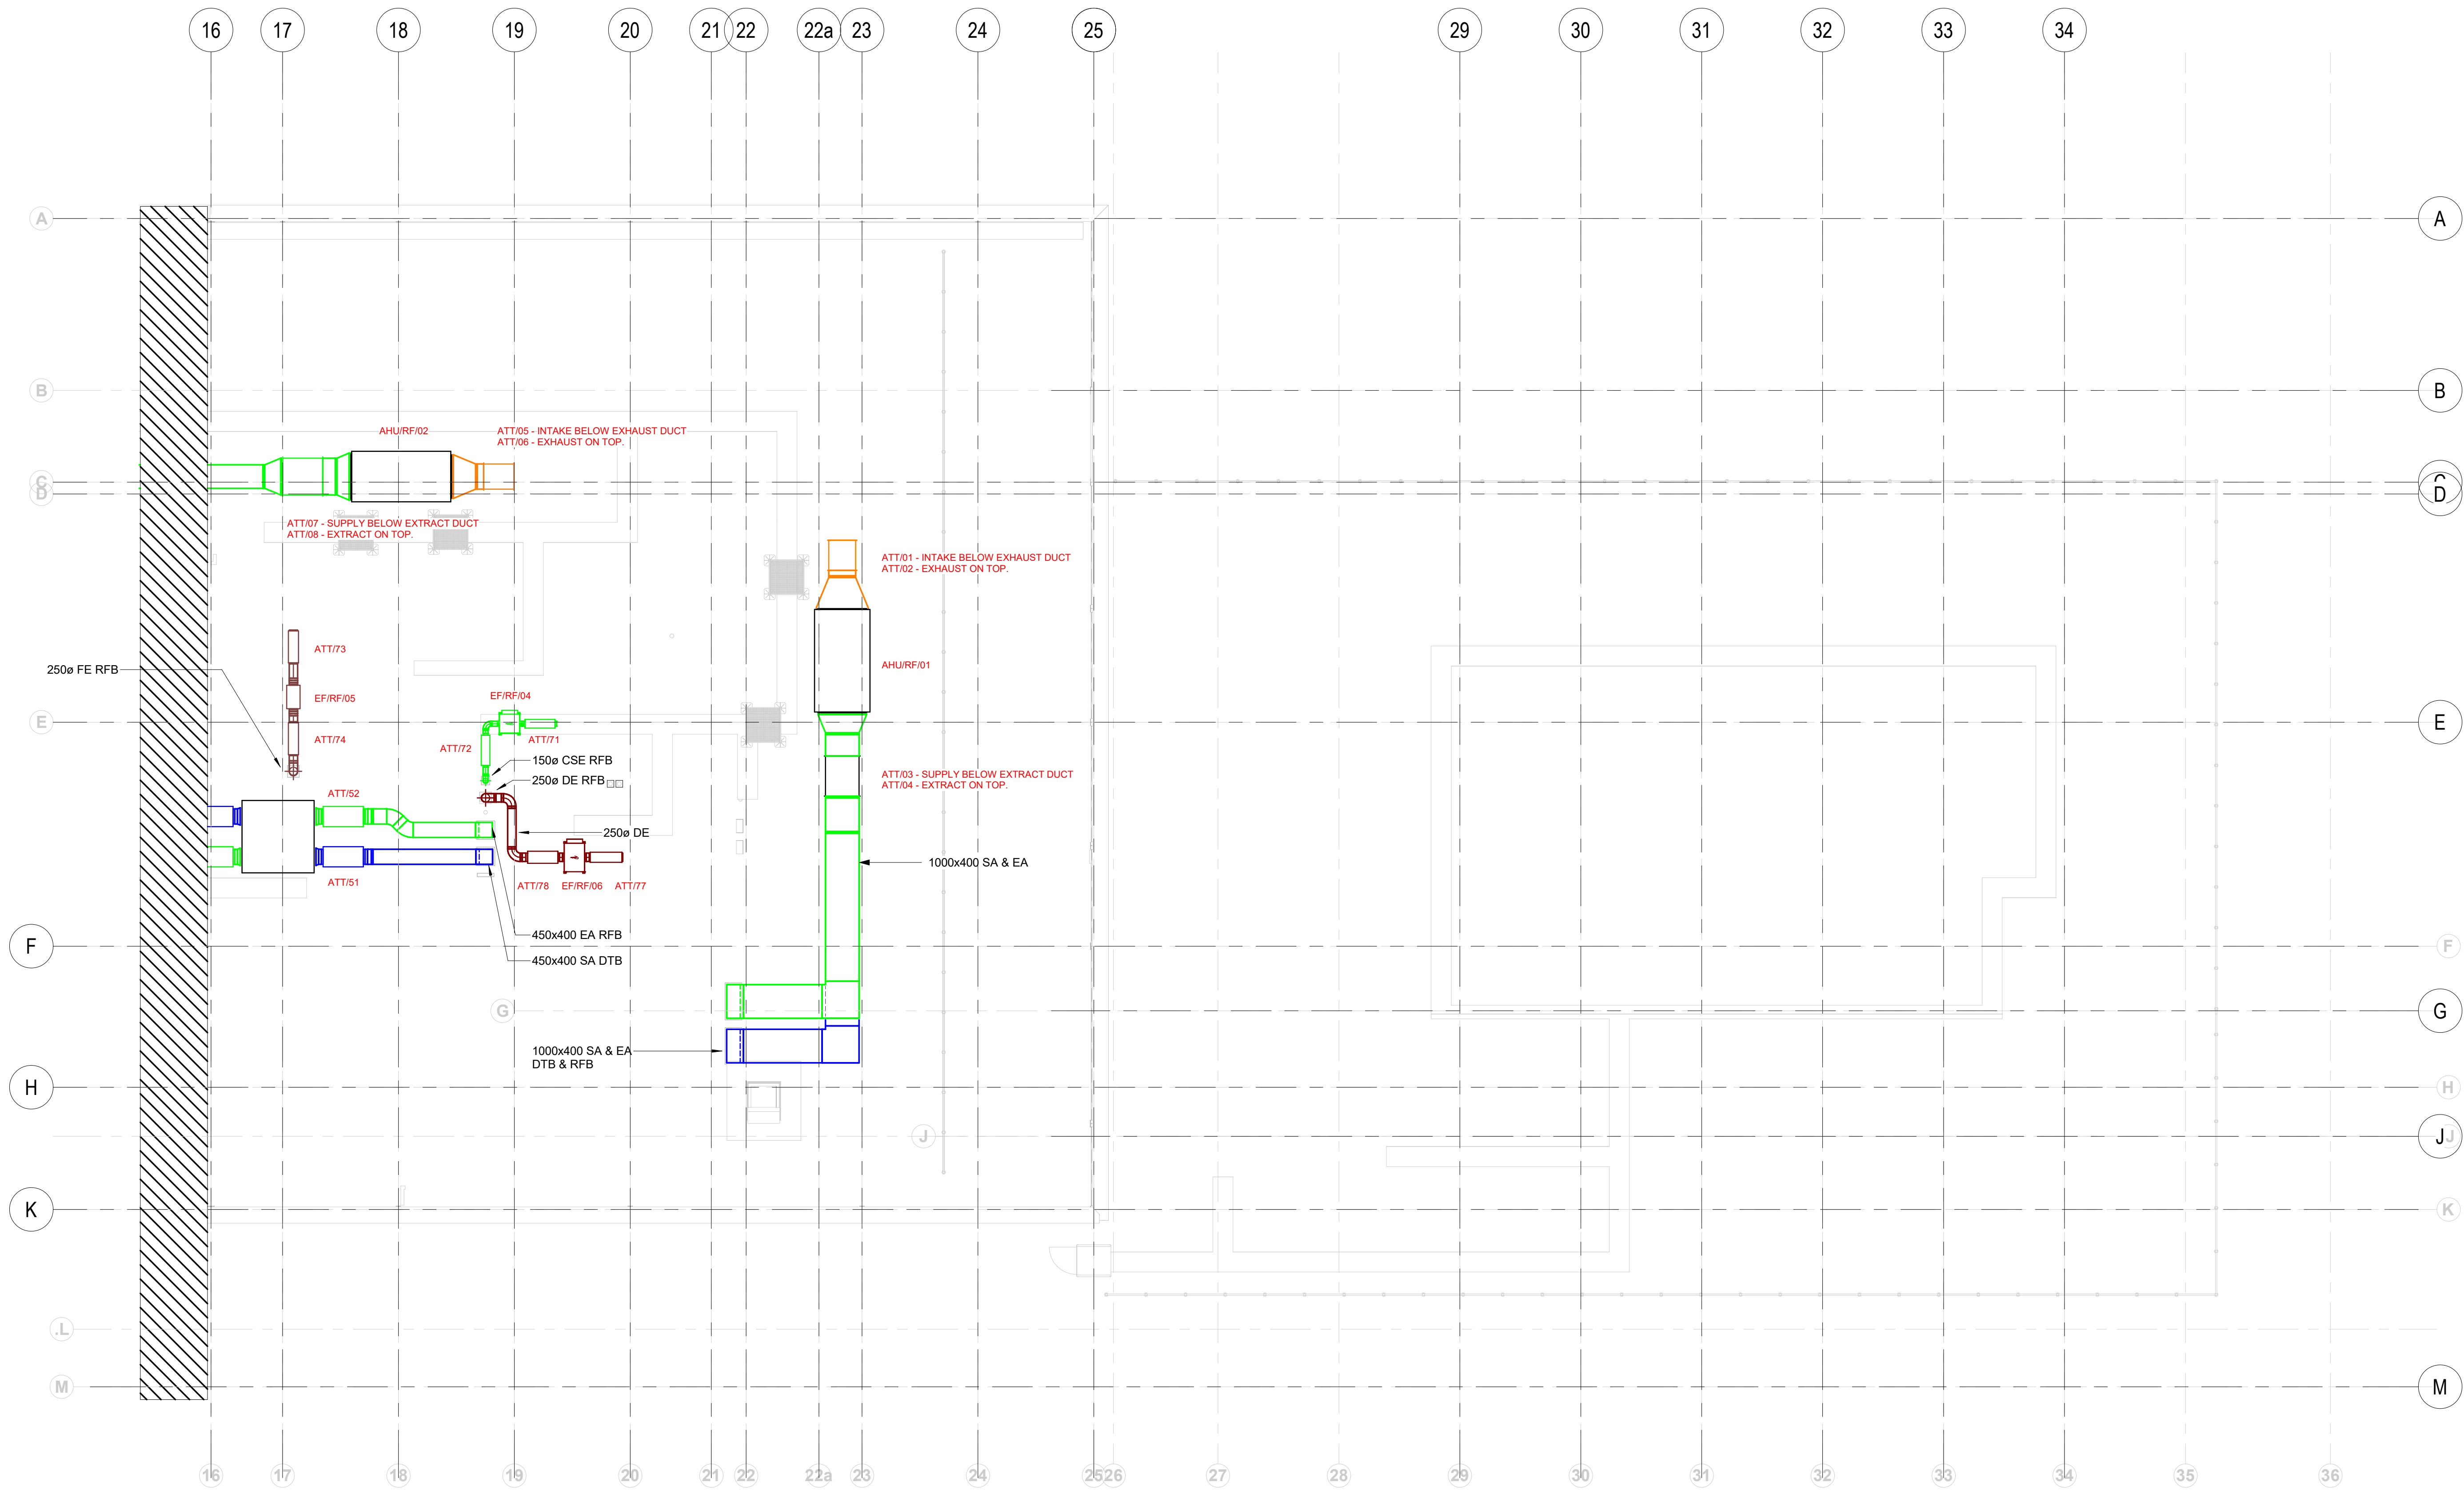

C04	CONSTRUCTION ISSUE - MAIN RISER SIZES AMENDED	A.W.	G.G.	11.02.22
C03	GENERAL CO-ORDINATION	A.W.	G.G.	04.01.22
C02	GENERAL CO-ORDINATION EXERCISE	A.W.	G.G.	12.11.21
C01	ISSUED FOR CONSTRUCTION	A.W.	G.G.	06.09.21
P01	CP ISSUE 1	A.W.	G.G.	14.05.21

Rev	Description	By	App	Date
-----	-------------	----	-----	------

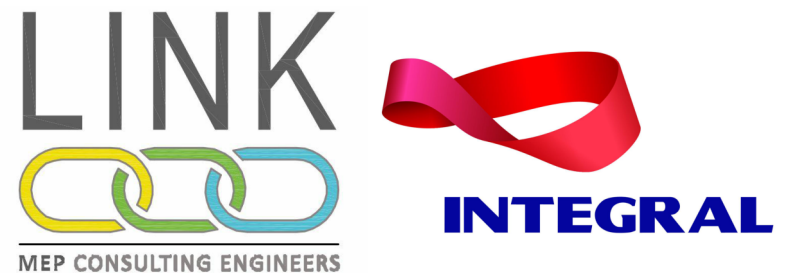

Client
MANCHESTER CITY COUNCIL

Project Title
BELLE VUE CO-OP ACADEMY

Drawing Title
LEVEL 03
VENTILATION
LAYOUT 2 of 2

Scale @ A0	Description/Issued For	Status
1:100	CONSTRUCTION	S4
Drawing Number	Revision	
009433-IUL-01-03-DR-M-570002	C04	