




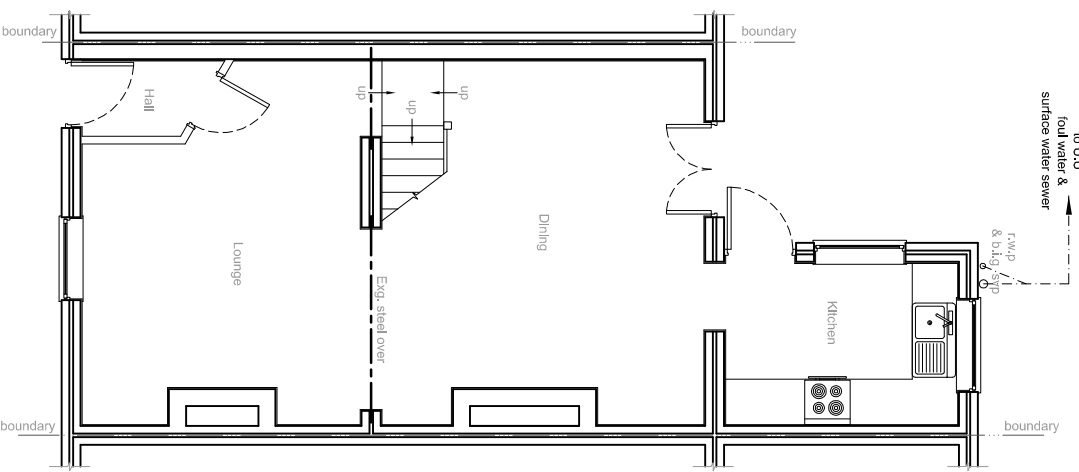


EXISTING GROUND FLOOR PLAN
Scale 1:100

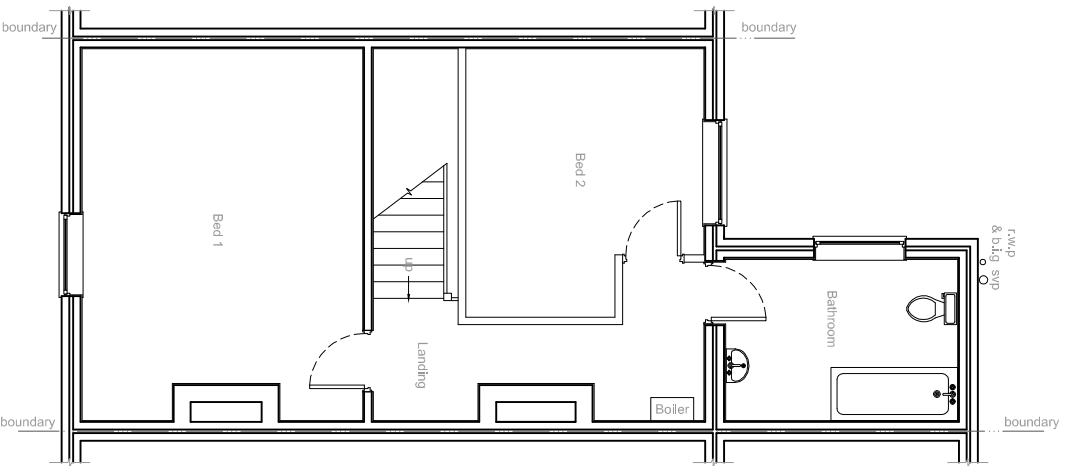


EXISTING FIRST FLOOR PLAN
Scale 1:100

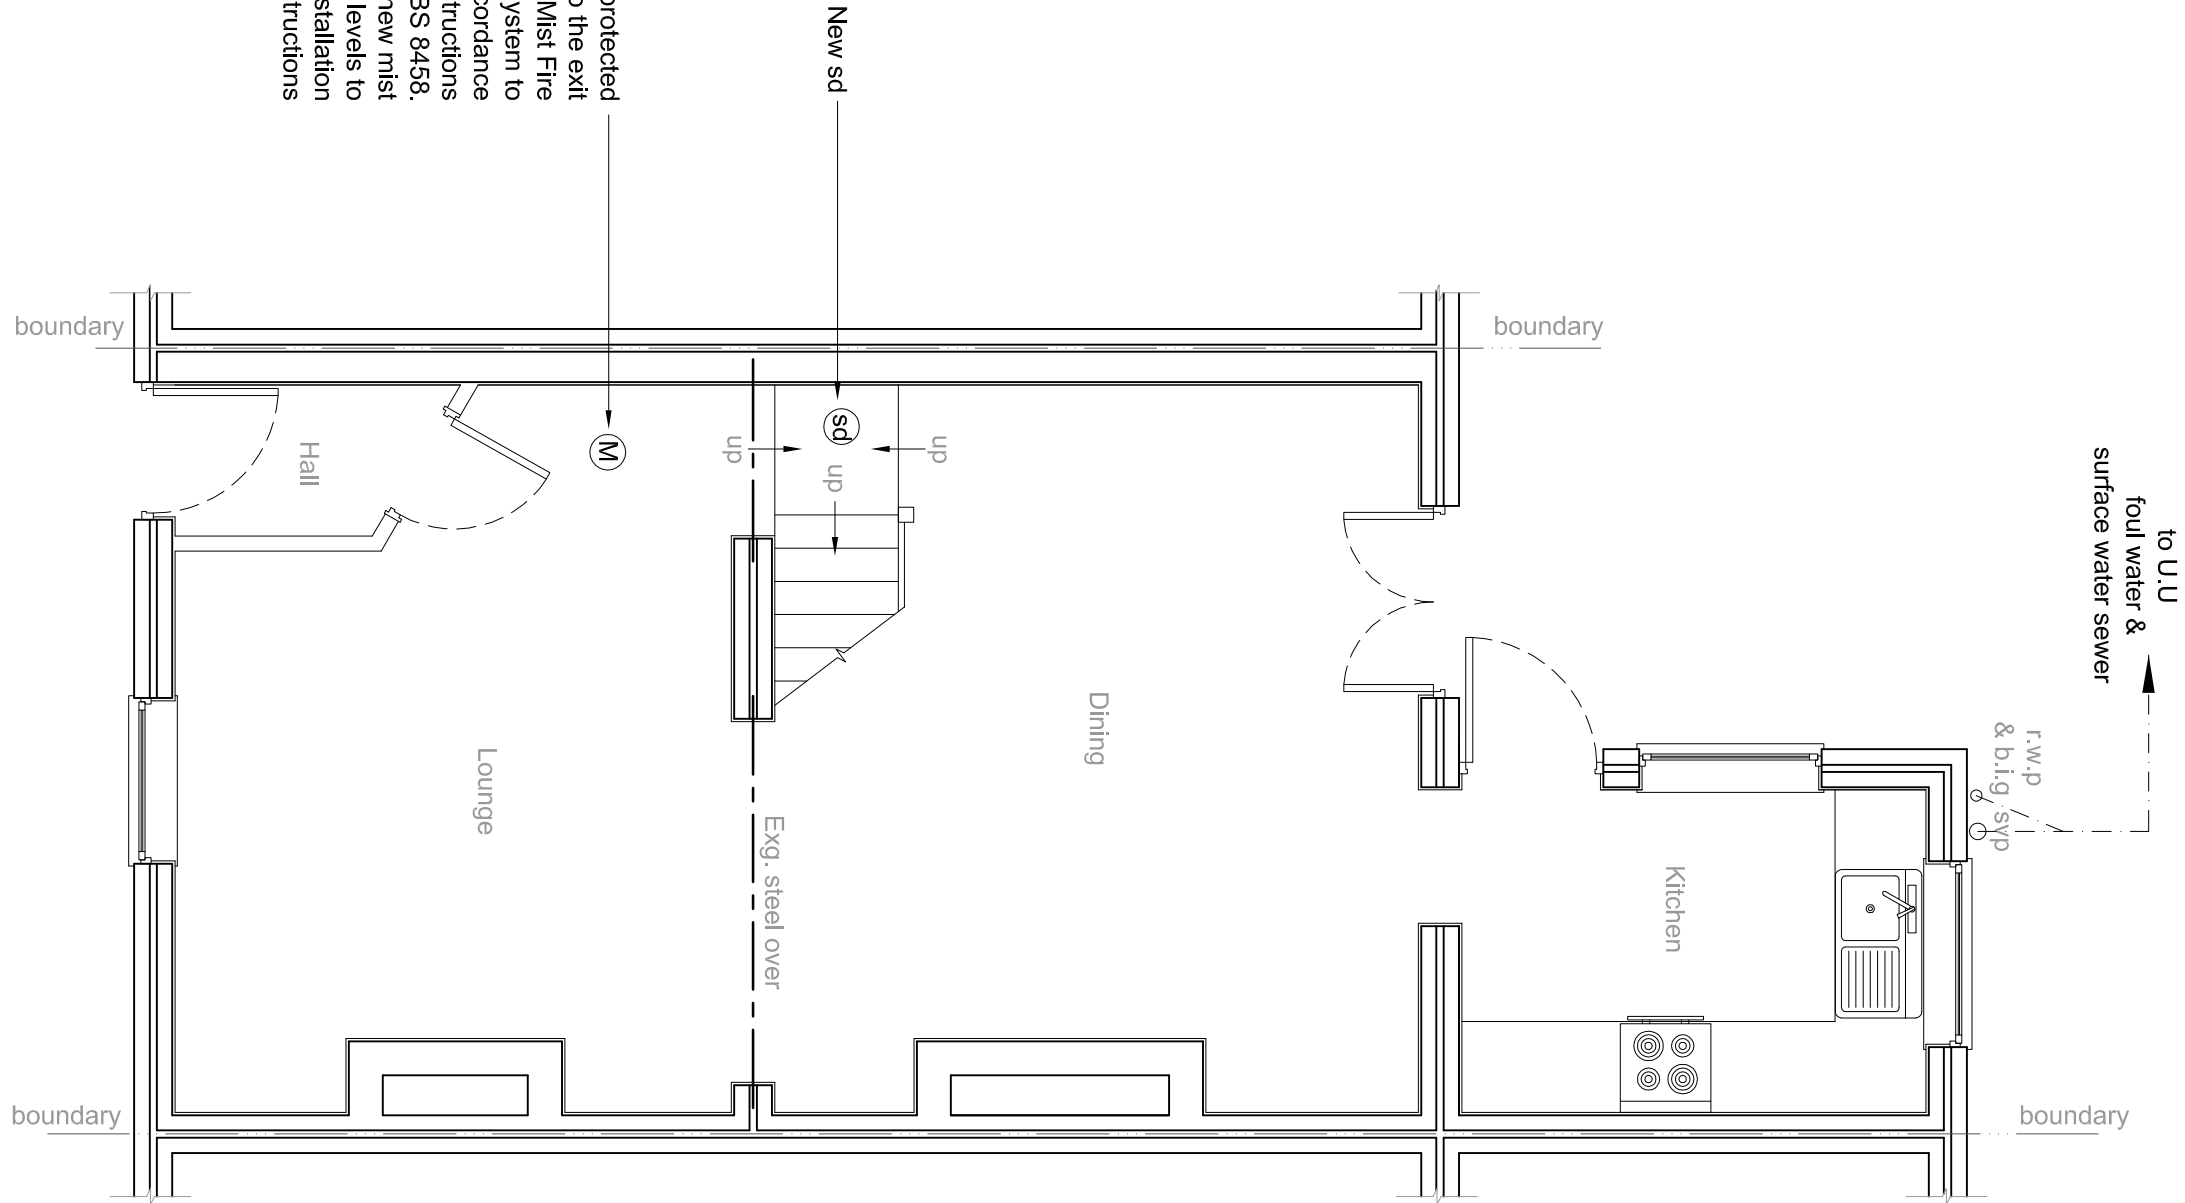

PROPOSED GROUND FLOOR PLAN
Scale 1:50

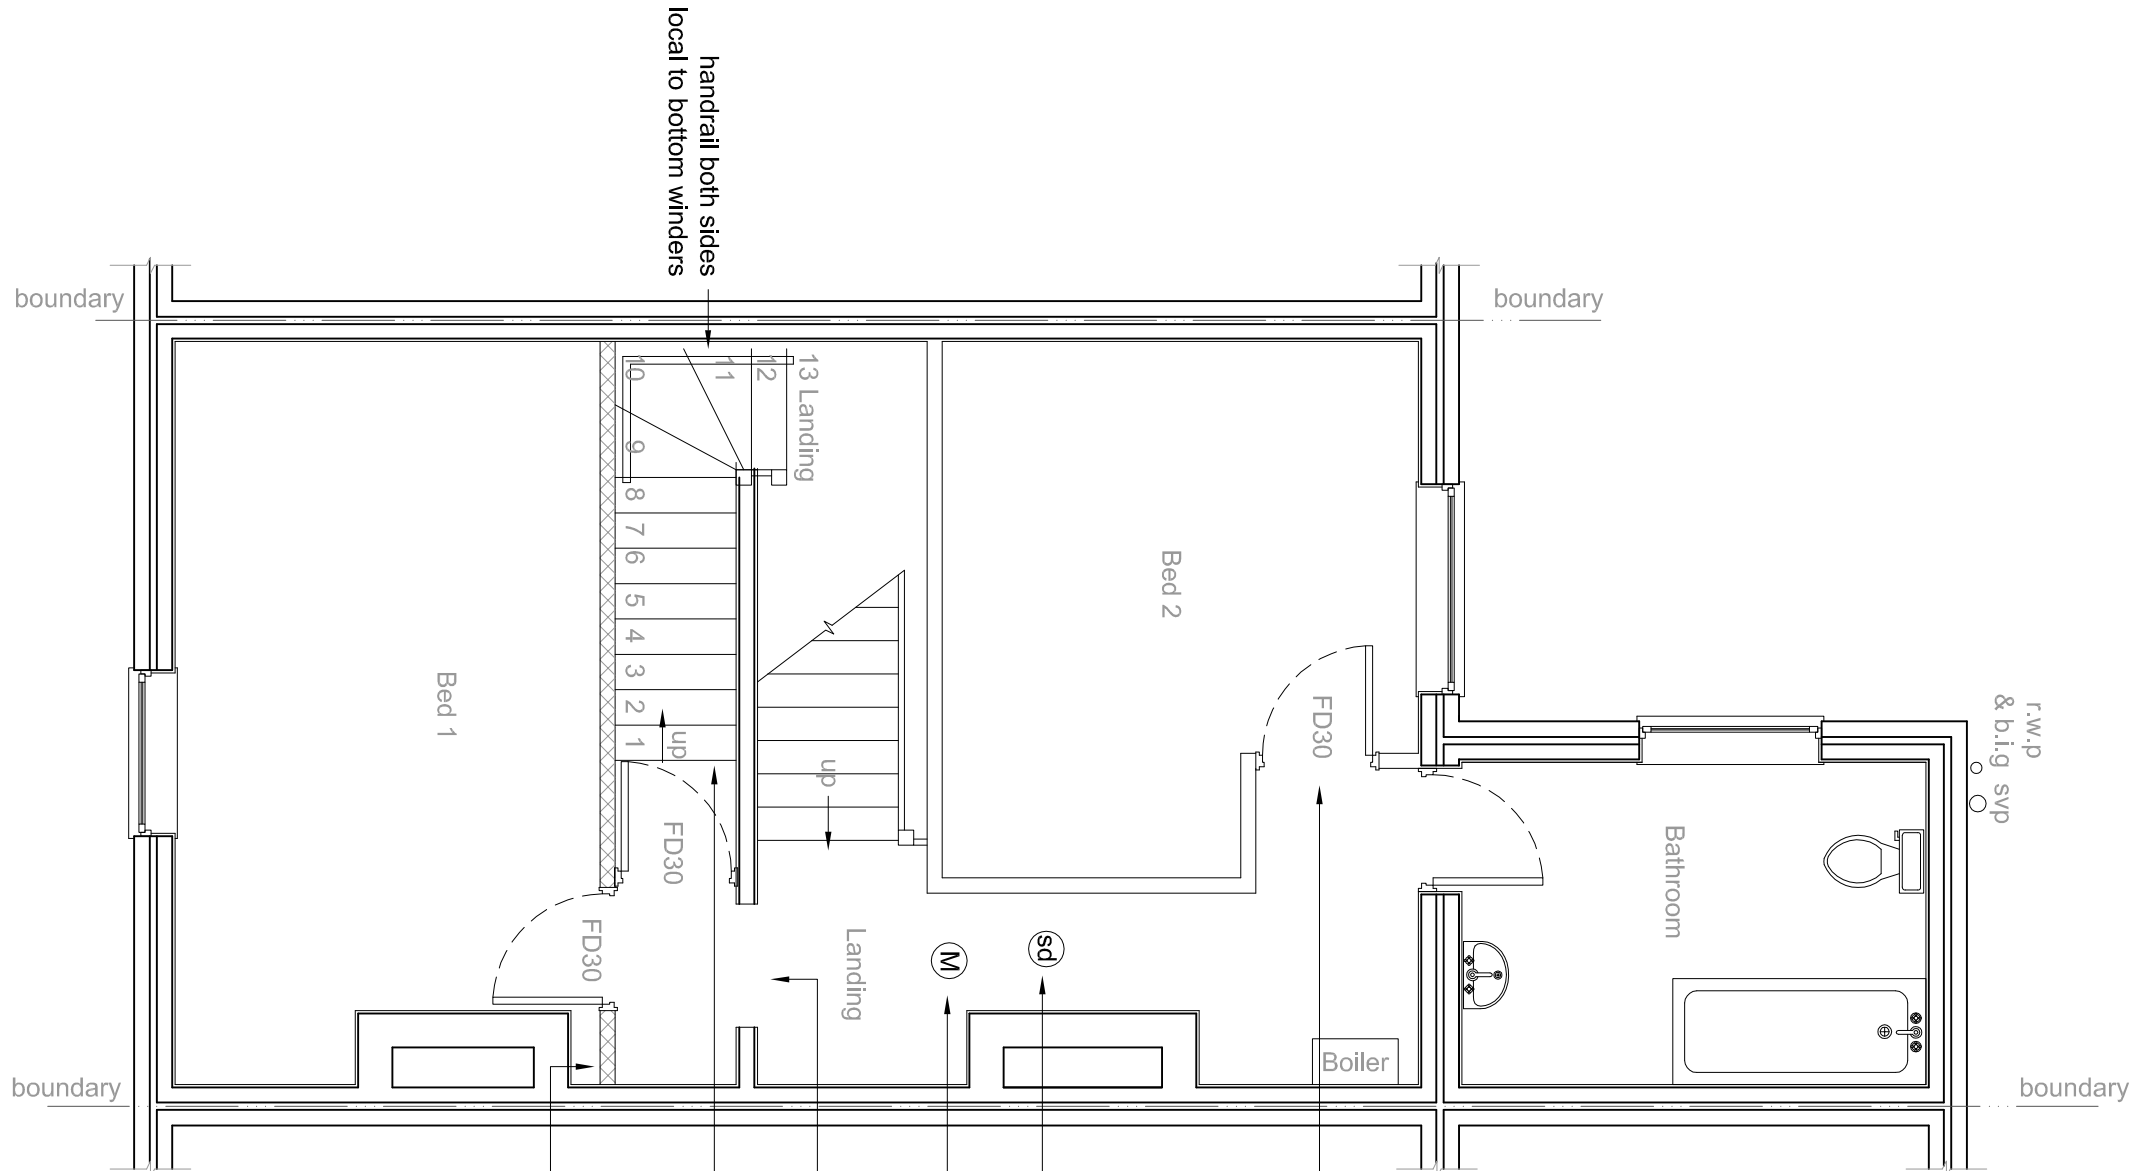

PROPOSED FIRST FLOOR PLAN
Scale 1:50

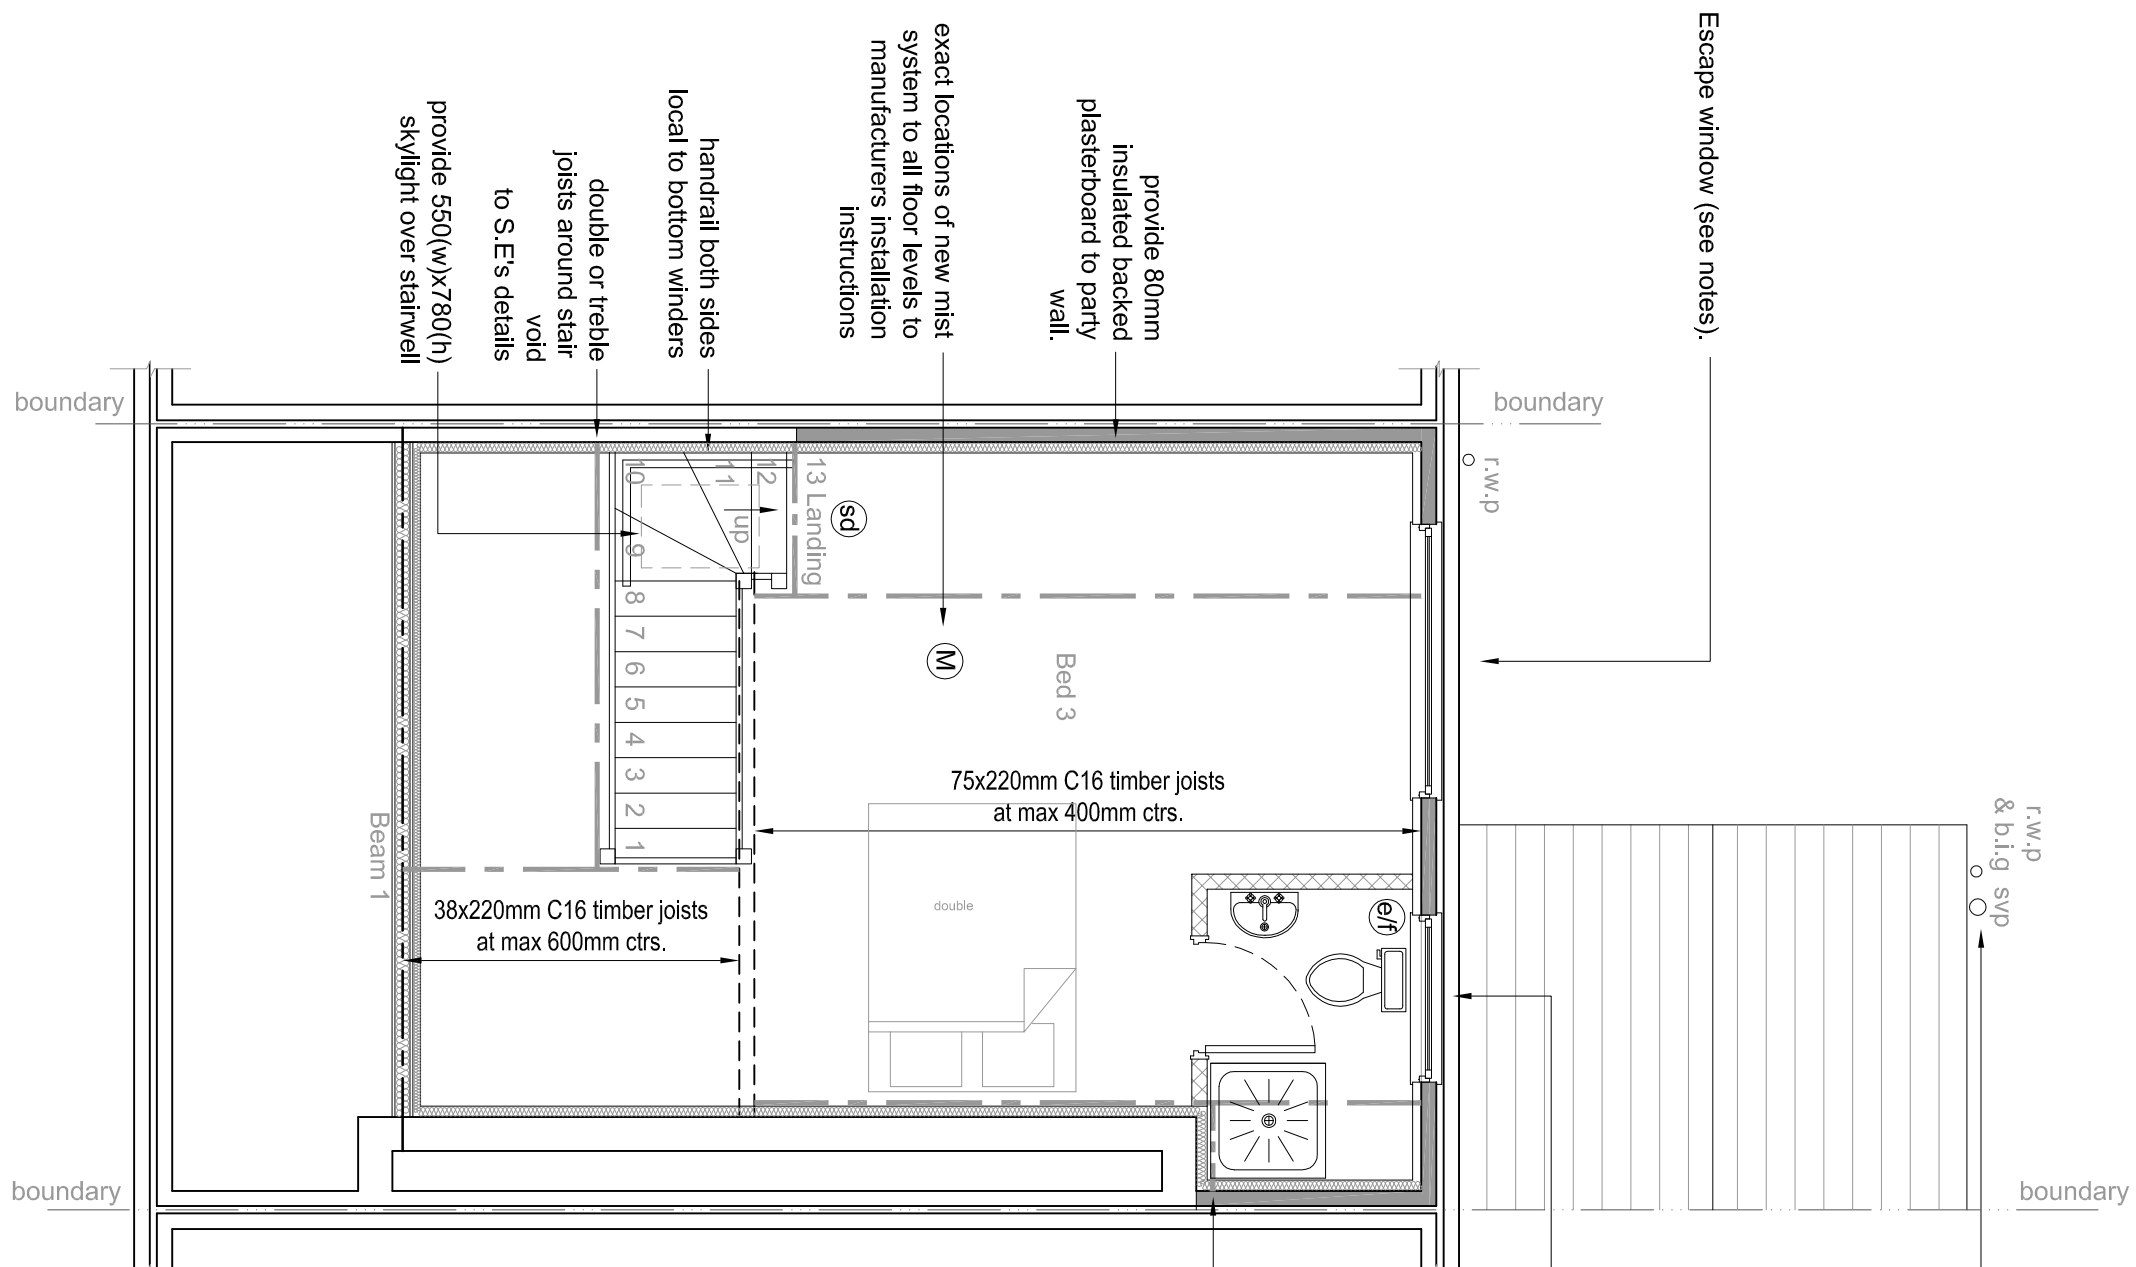

PROPOSED LOFT FLOOR PLAN
Scale 1:50

KEY	
Foul water & Surface water drains	l.w & s.w
Rain water pipe	r.w.p
Back inlet gully	b.l.g
Soil vent pipe	s.v.p
Soil stack	s.s
Manhole	MH
Inspection chamber	I.C
Mechanical extractor fans to be ducted to outside air, capable of 15 litres per second (lps) flow rate utility rooms, 30 litres per second (lps) flow rate w.c. with 15 litres per second (lps) flow rate below door. Only install an e/f if appliance in the same room is a sealed unit	e/f
Self contained mains operated interlinked smoke alarms fixed to each floor level in main circulation areas.	sd
Structural Engineer	S.E
Timber stud wall provide sound deadening quilt to bedrooms finished with 15mm plasterboard & skim	
Dormer cheeks, see specification on section A-A	
30 mins fire door complete with intumescent strips to frame	FD30
Water Mist Fire Suppression Sprinkler System to be installed in strict accordance with manufacturers instructions to BS 84453.	M

DWG No. M20 6UB23/02
TITLE FLOOR PLANS

PROJECT Proposed Development to 123 Whitechapel Street M20 6UB
CLIENT Mrs. P. Newbury
DATE 20/10/2022
SCALE AT ALL AS SHOWN