


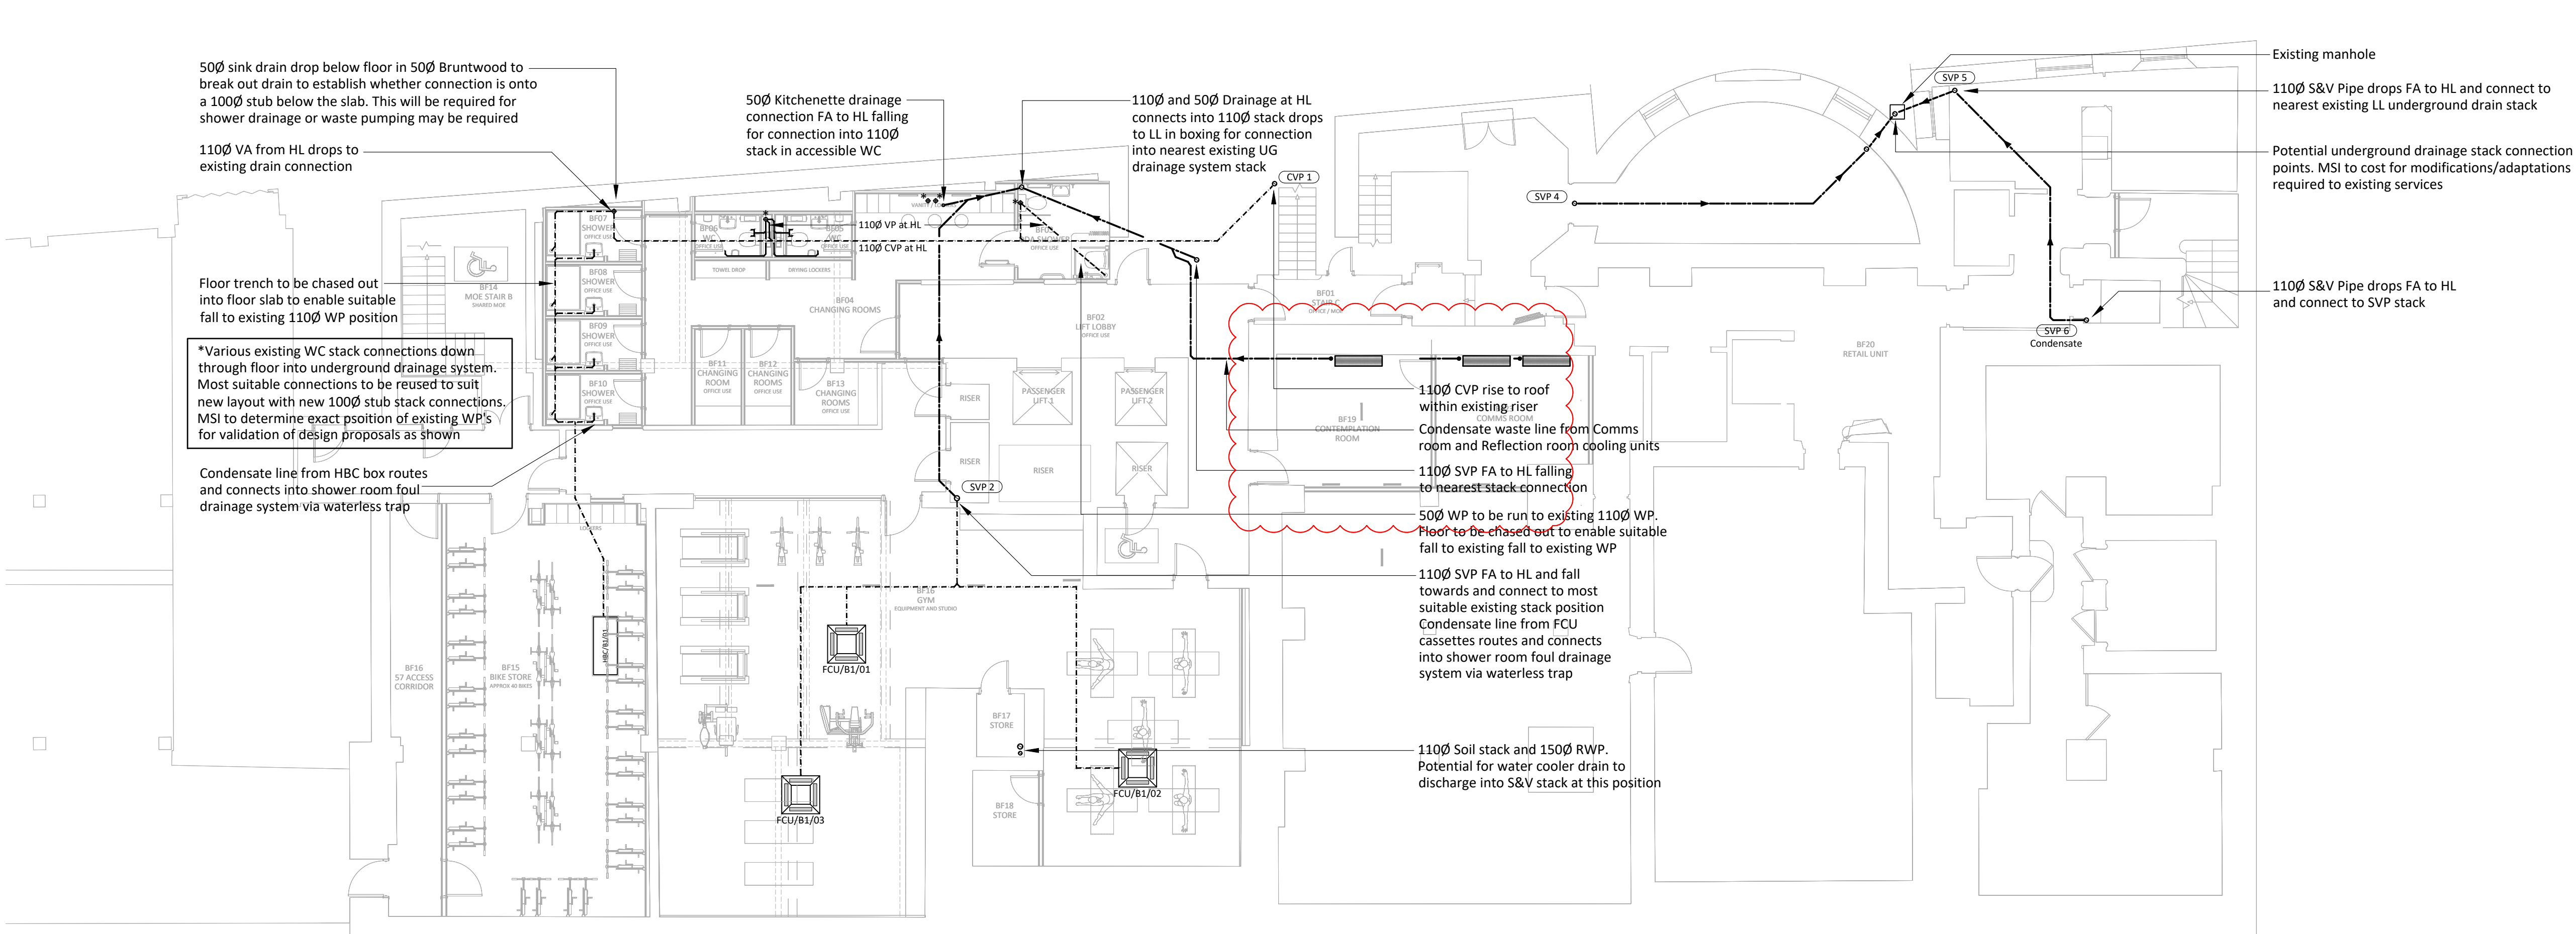


Do not scale from this drawing.
Verify dimensions by site measurement.
Read this drawing in conjunction with the latest architectural and structural drawings.
This drawing is based on the following information:-

Notes

- 1. This drawing to be read in conjunction with all mechanical, electrical & public health drawings for this contract.
- 2. All services work to be carried out in accordance with the relevant Engineering Specification for this contract.

Drainage Layout

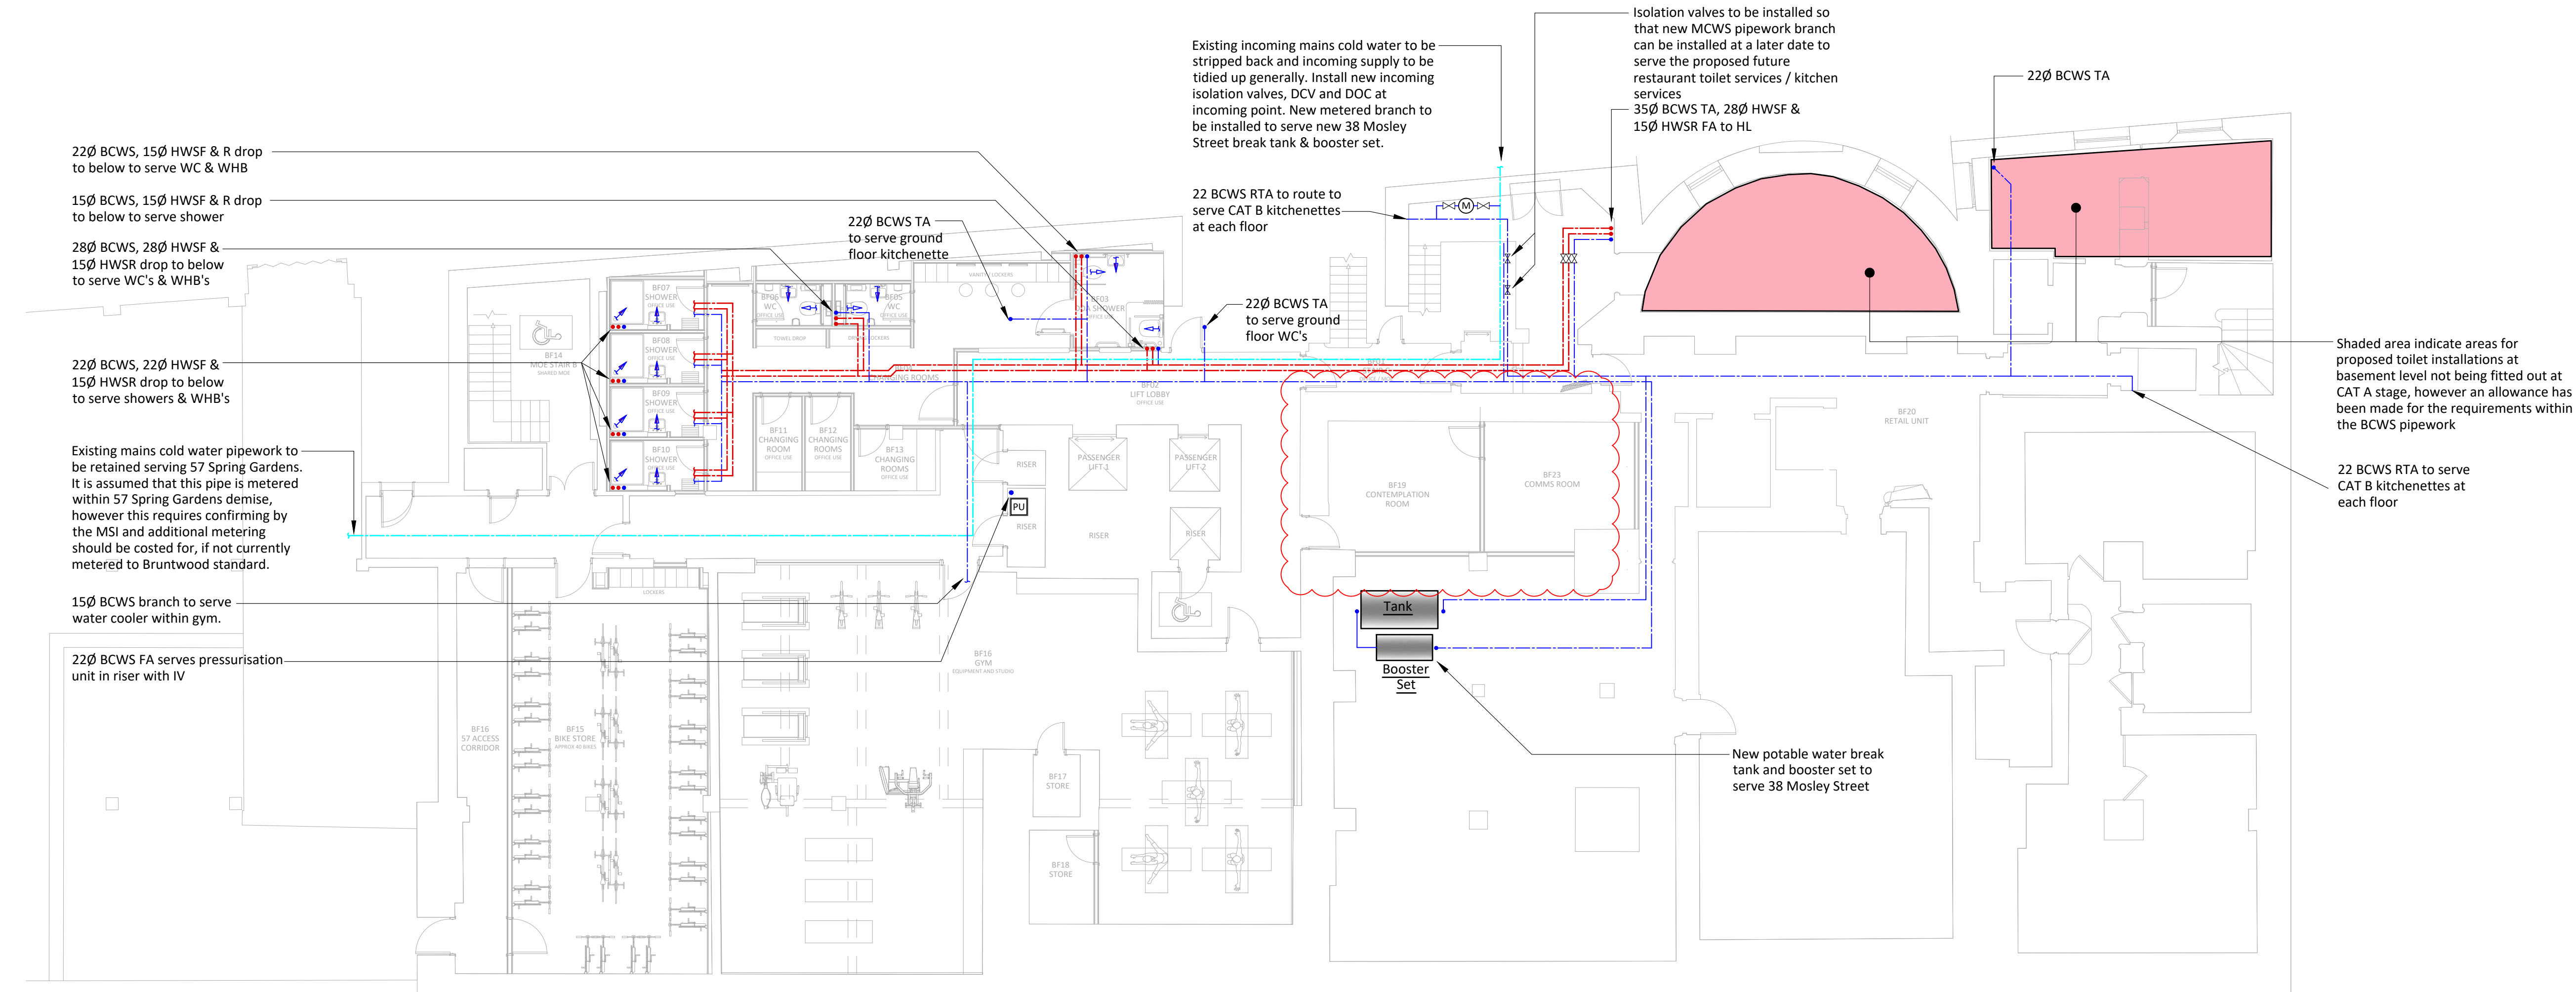

04	09/09/22	CAT A / B Contractor Issue	MR	SH
03	23/05/22	Stage 4 Tender Update.	MR	SH
02	29/04/22	Stage 4 Tender Issue.	MR	SH
01	31/03/22	Stage 3 Issue.	RG	SH
Revision	Date	Description	Drawn	Checked



hilsonmoran.com info@hilsonmoran.com

Client

Bruntwood

Project
38-42 Mosley Street
Grade 2* Listed Building Refurbishment

Drawing Title
Public Health Services
Basement Level
Domestic Hot & Cold Water and Above
Ground Waste Services Layout

Scale	Sheet Size	Checked	Approved
1:100	A1	SH	SR

Status
For Information 27618
Drawing No. 27618-HM-ZZ-B1-DR-PH-1200 Rev 04