


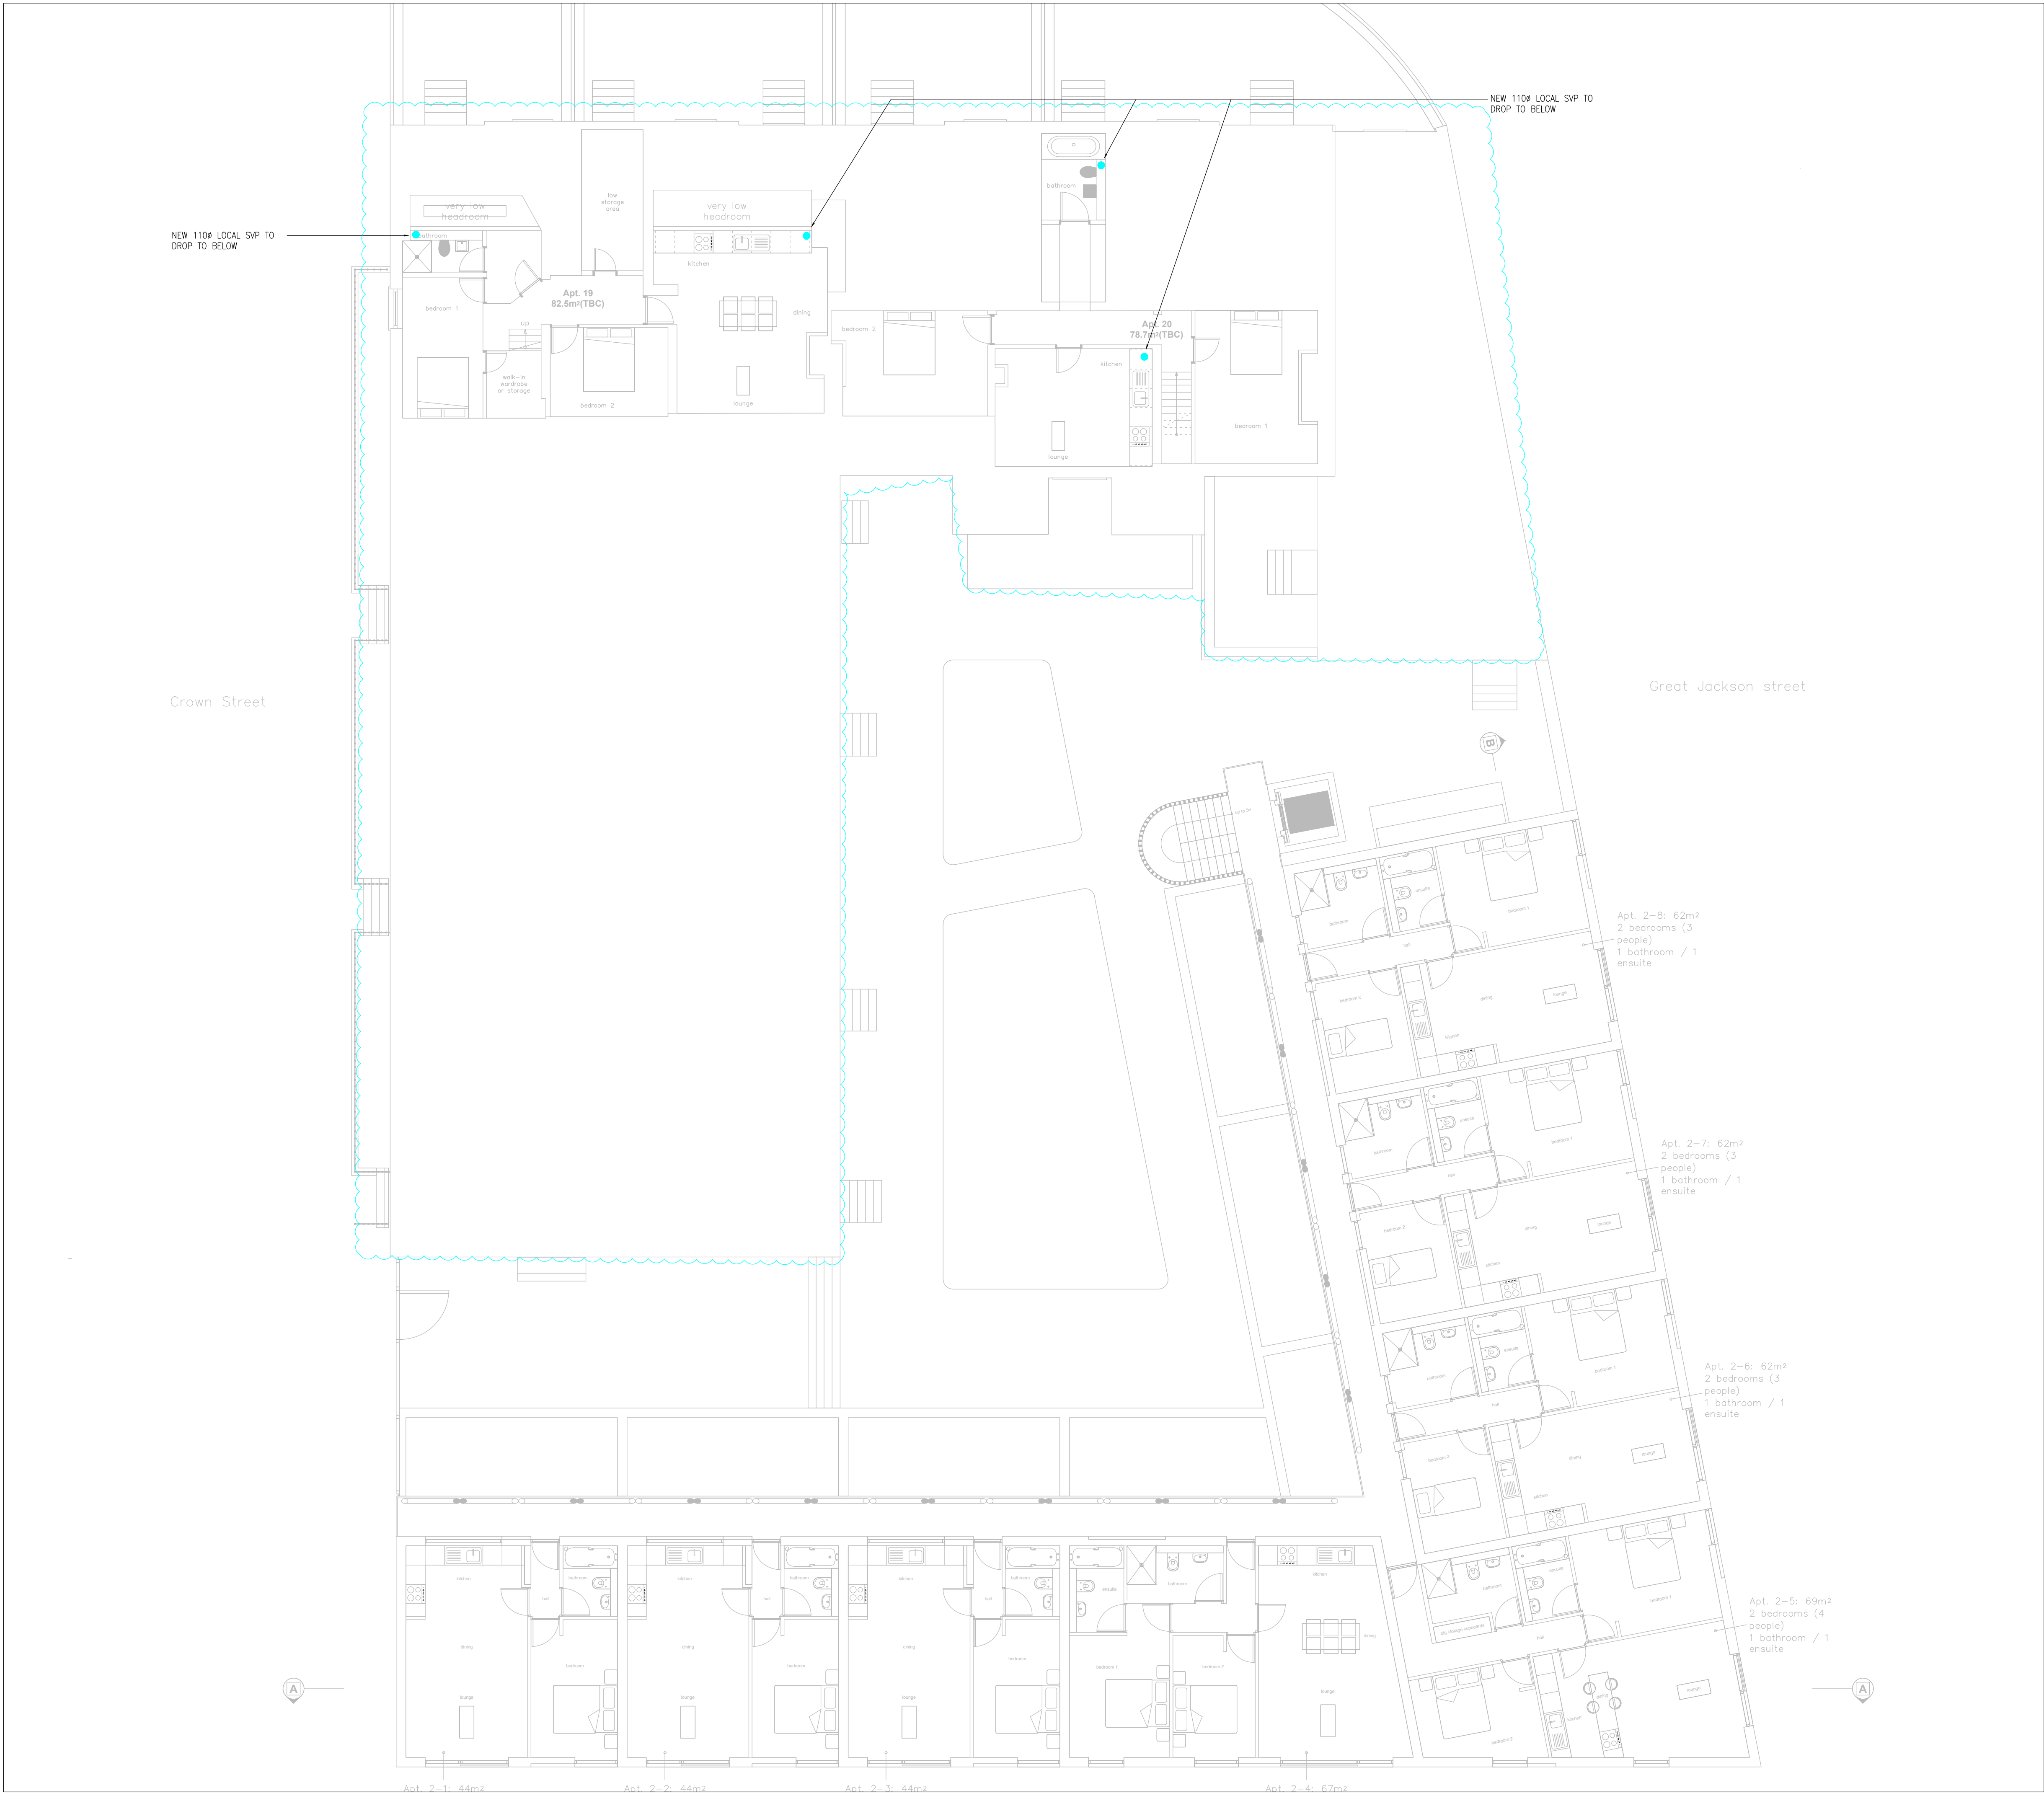

- NOTES:
1. THIS DRAWING SHALL BE READ IN CONJUNCTION WITH THE ARCHITECTURAL HERITAGE REPORT AND ALL RELEVANT PROJECT INFORMATION.
 2. ALL DRAINAGE MUST AVOID DISTURBING HERITAGE DETAILS. FINAL POSITION OF DISTRIBUTING DRAINAGE PIPEWORK TO BE COORDINATED WITH THE HERITAGE DETAILS AND ARCHITECTS LAYOUTS.
 3. ALL ABOVE GROUND DRAINAGE TO COMPLY WITH EN12056, BS8301 AND APPROVED DOCUMENT H IN ALL RESPECTS AND TO THE SATISFACTION OF THE LOCAL DRAINAGE AND ENVIRONMENTAL INSPECTOR AND THE SERVICES ENGINEER.
 4. DRAINAGE DETAILED ON THIS DRAWING IS FOR INTERNAL ABOVE GROUND DRAINAGE INSTALLATION. ALL DRAINAGE BELOW GROUND FLOOR SLAB SHALL BE DESIGNED BY THE STRUCTURAL/CIVIL ENGINEER.
 5. ABOVE GROUND CONNECTIONS SHALL CONNECT TO BELOW GROUND SYSTEM BY CONNECTION PIECE PROVIDED BY THE STRUCTURAL ENGINEER.
 6. ALL TRAPS SHALL BE ANTI-SYPHON WITH MINIMUM 75MM SEAL.
 7. STACK TO BE VENTILATED TO ATMOSPHERE WHERE POSSIBLE, TERMINATING WITH A WEATHERPROOF VENT TERMINAL.
 8. ALL NEW SVP'S AND OFFSETS IN CEILING VOID WITHIN COMMON AREAS AND LIVING QUARTERS TO BE ACOUSTICALLY TREATED

- LEGEND
- PROPOSED LOCAL SVP DROPPING FROM LOW LEVEL ON SECOND FLOOR TO FIRST FLOOR
 - PROPOSED LOCAL SVP DROPPING FROM THIRD FLOOR TO SECOND FLOOR
 - ☁ DENOTES HERITAGE TOWNHOUSE ZONE. ALL DRAINAGE WITHIN THIS AREA MUST AVOID DISTURBING HERITAGE DETAILS. FINAL POSITION OF DROPPING DRAINAGE PIPEWORK TO BE COORDINATED WITH THE HERITAGE DETAILS.

Date	Description	Rev	By
Revision Description			



hulley & kirkwood
consulting engineers

Manchester Office
2 Commercial Street
Castlefield
Manchester
M15 4RQ
Tel No: 0161 832 2030
E: hk.manchester@hulley.co.uk

...Making Buildings Work

Project:
Bridgewater House

Drawing Title:
Mechanical Engineering Services
Bridgewater House, Second Floor
Indicative Heritage Drainage Layout

Drawing Number:
50958(52)003

Revision:

Date:	28/06/2022
Scale:	1:100
Drawn By:	T.Sugden
CAD Dwg File:	50958(52)003.dwg
Arch. Base Dwg:	

Issue Status:
For Information