



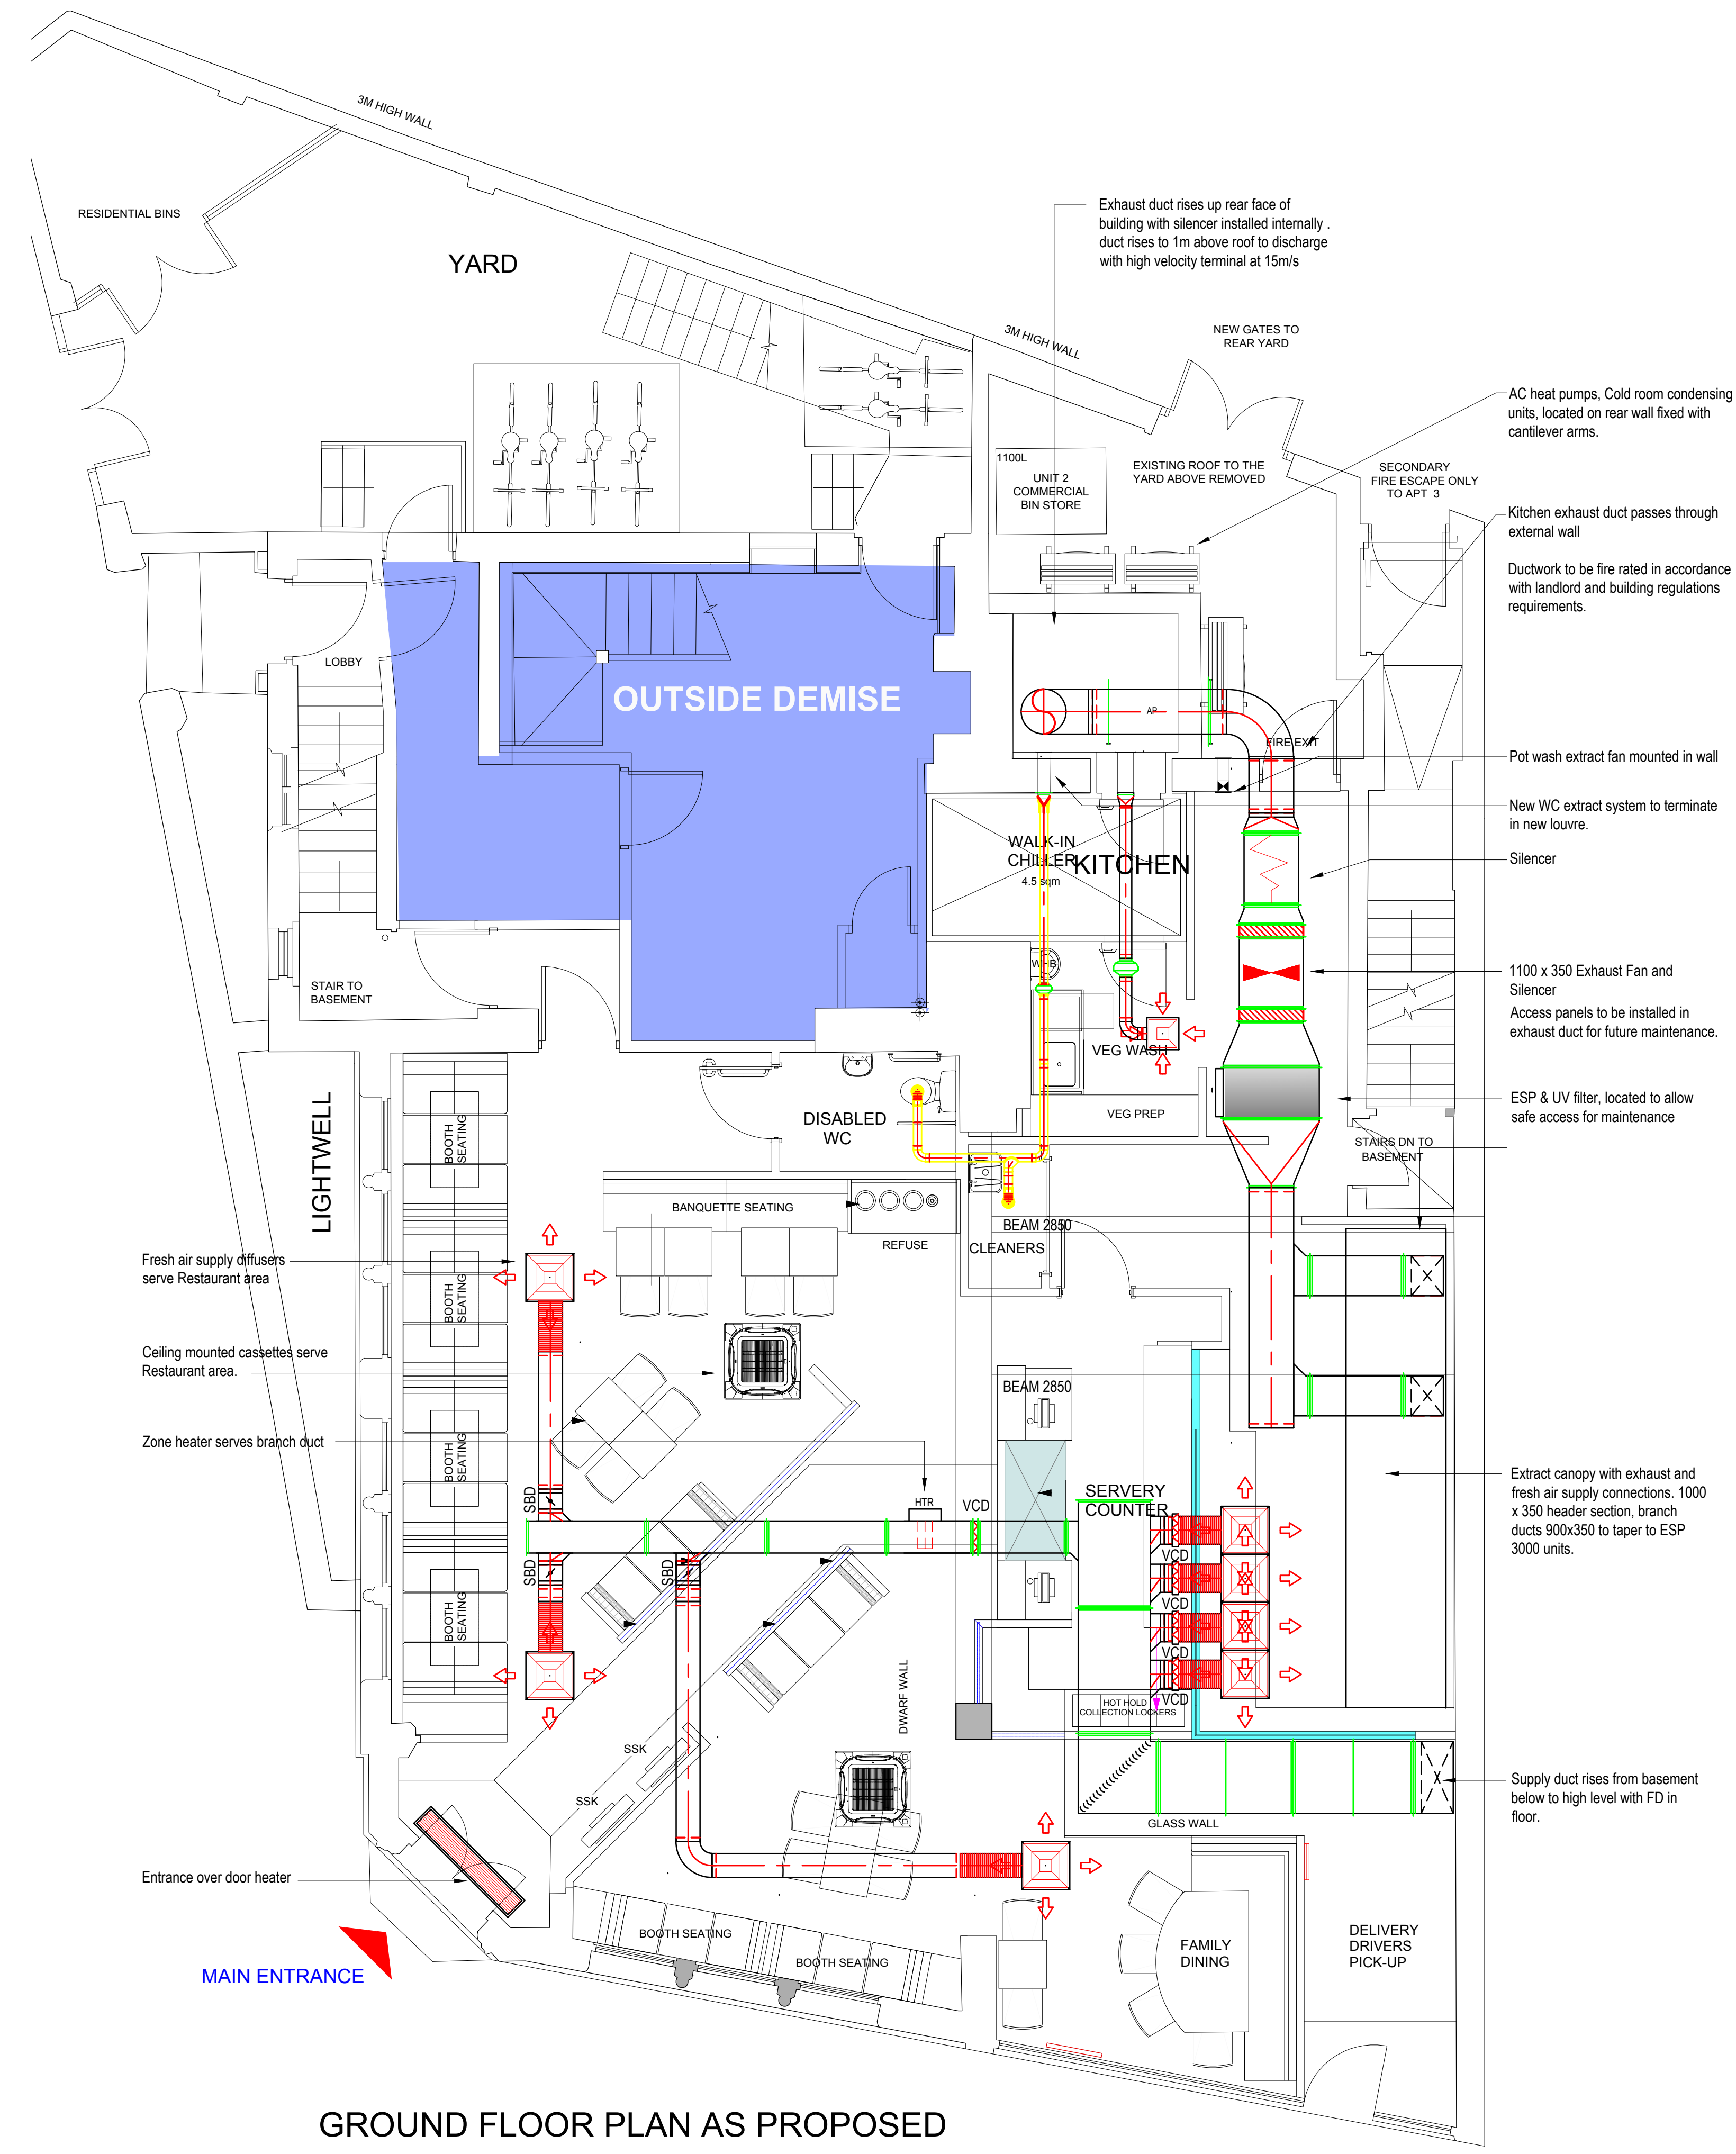

GROUND FLOOR PLAN AS PROPOSED

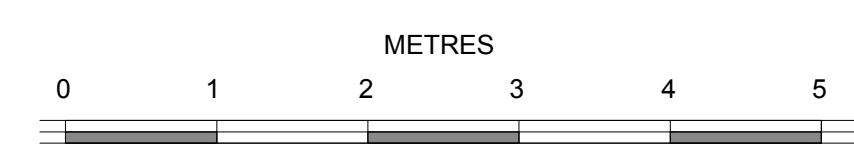

NOTES & REVISIONS

Rev.	Date.	Amendment
------	-------	-----------



Unit 9, Markfield Industrial Estate
Hill Lane Close, Markfield, Leicestershire, LE67 9PY
Tel: - 01530 245 777 Fax: - 01530 245 888
Email: - info@mcveigh-aircon.co.uk

Installed Kitchen Extract services for GDK Store
311-313 Wilmslow Road,
Fallowfield,
Manchester,
M14 6NW

Drawn By: - SB	Checked By: - SB
Scale: - 1:50 @ A0	Date: -15/09/2022
Drawing No: - E54520-3	Rev: -

© 1999 This drawing is copyright of McVeigh Technical Solutions Ltd. It may not be reproduced in whole or in part without the prior written consent of the company. All dimensions to be checked on site before works commence. This drawing is only to be used in conjunction with drawing notes and specification and is in keeping with current CDM Regulations.