


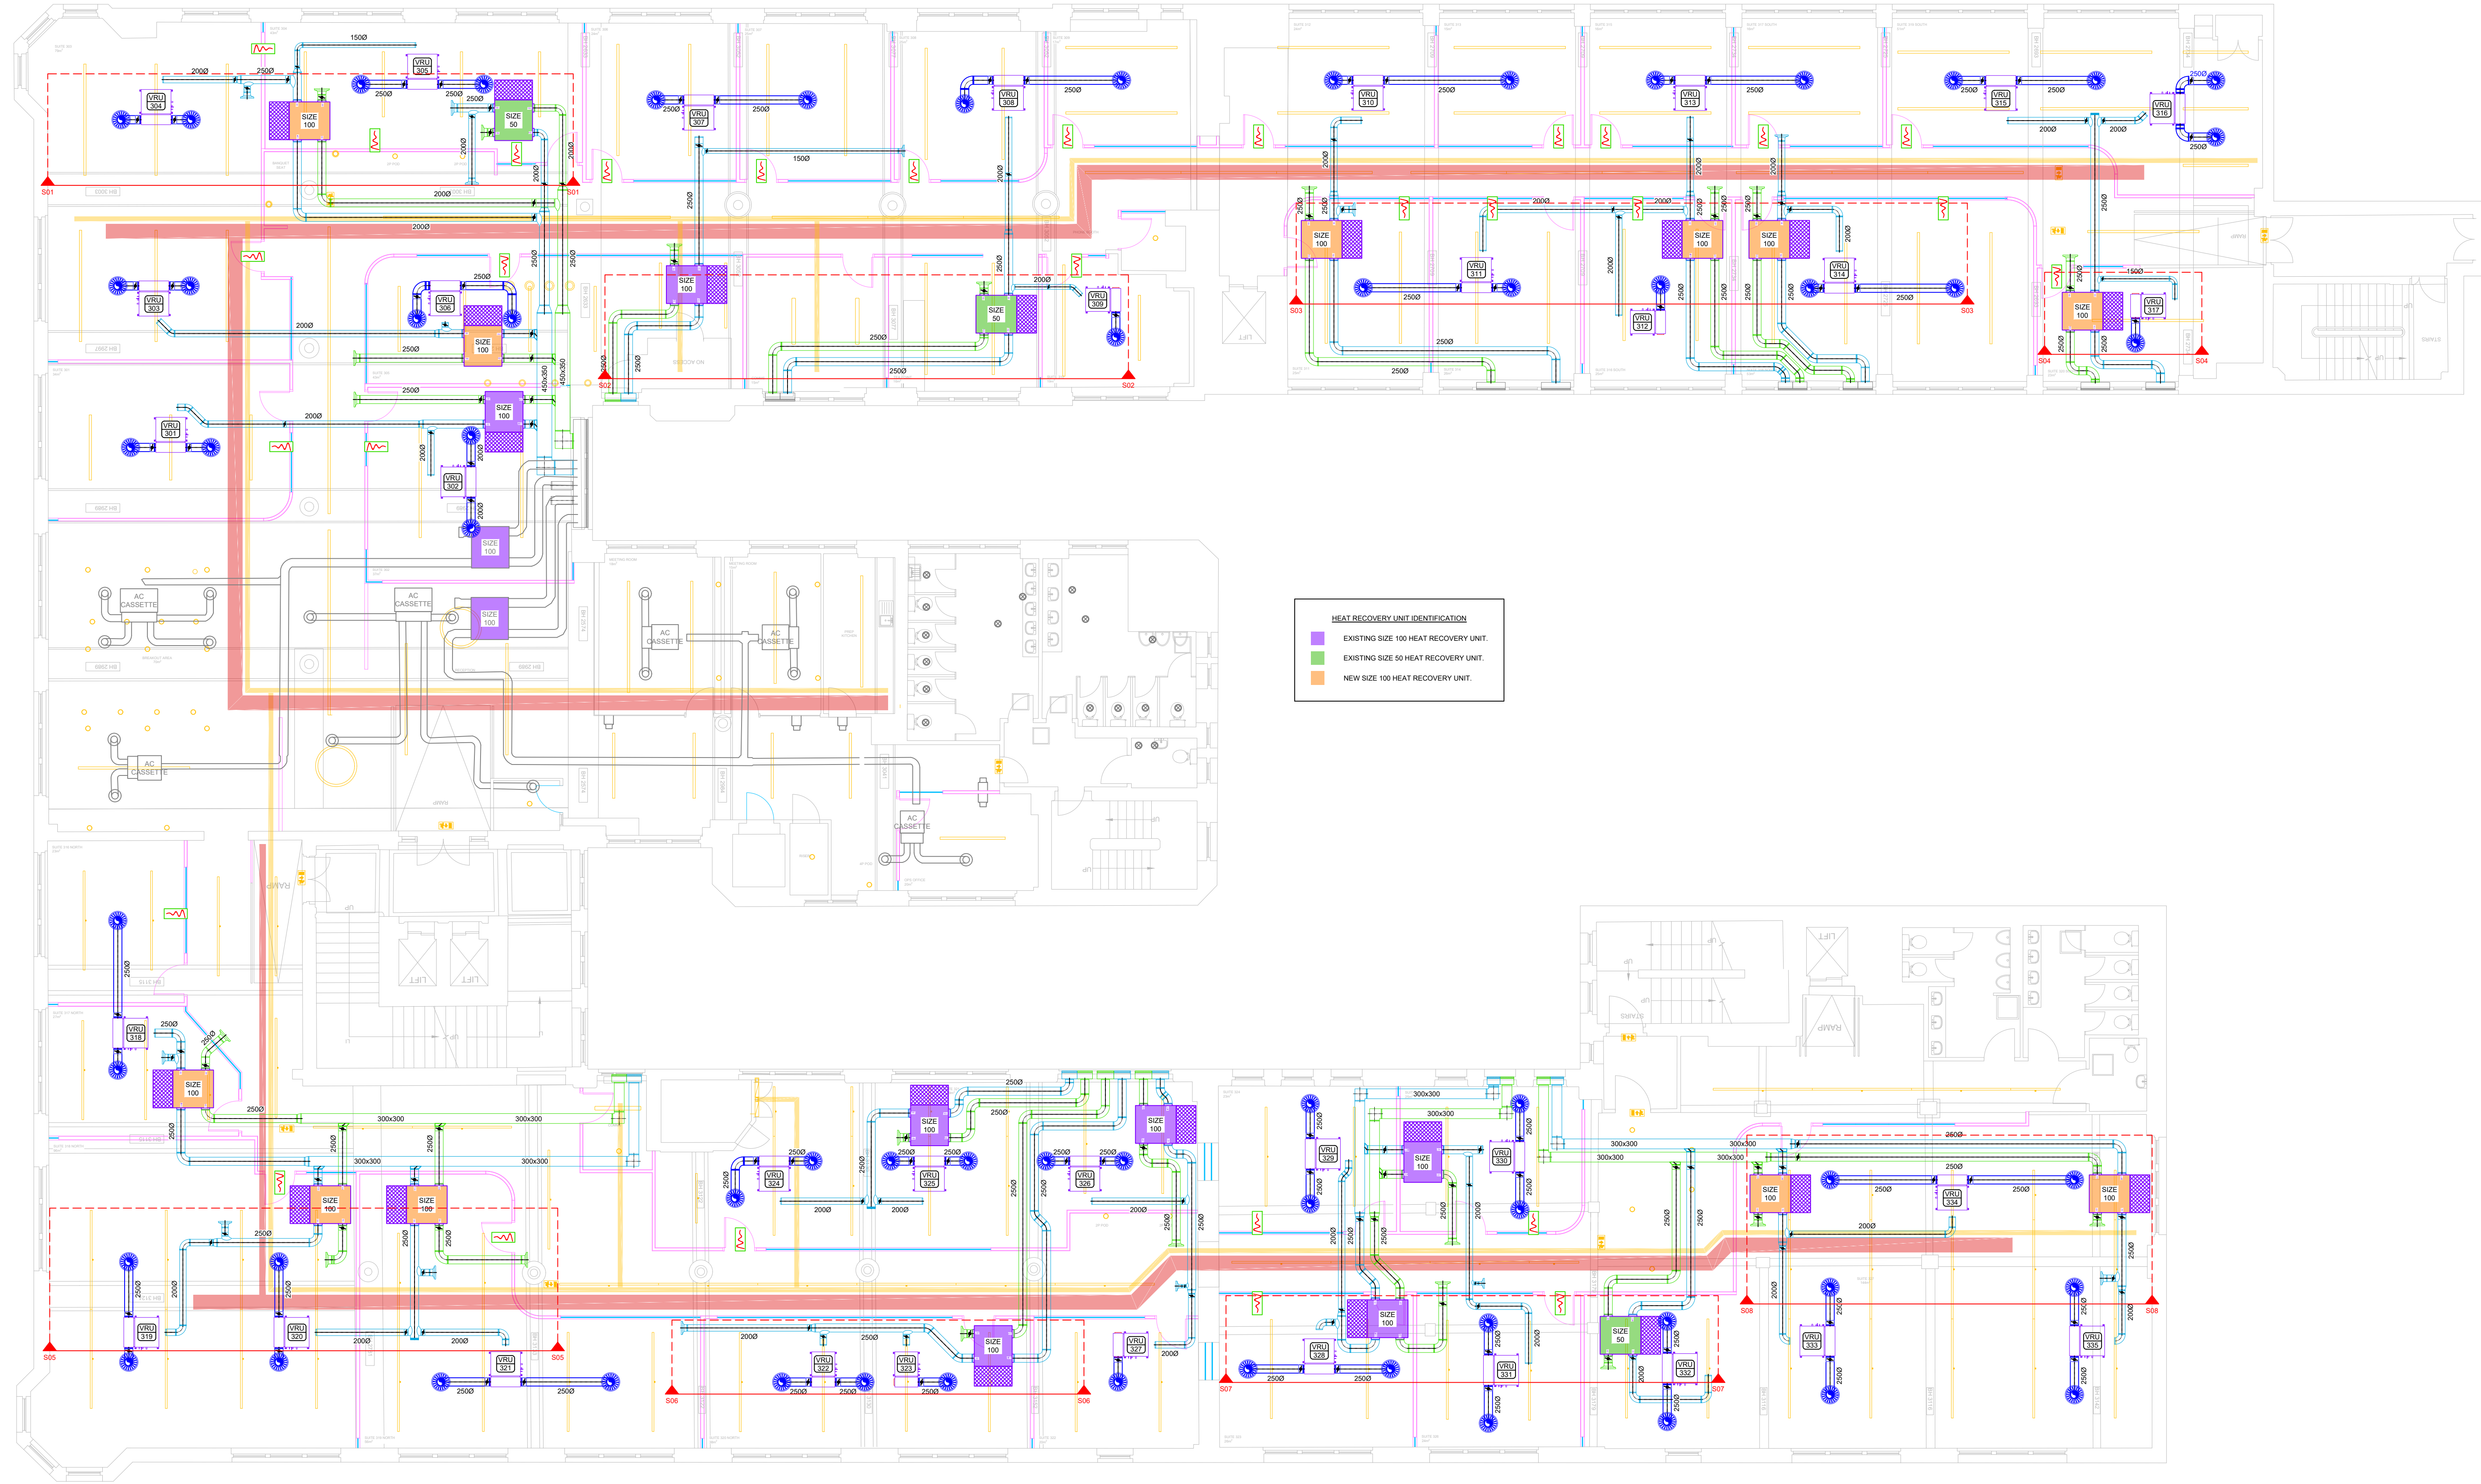

HEAT RECOVERY UNIT IDENTIFICATION

- EXISTING SIZE 100 HEAT RECOVERY UNIT.
- EXISTING SIZE 50 HEAT RECOVERY UNIT.
- NEW SIZE 100 HEAT RECOVERY UNIT.

- LEGEND:
- SQUARE DIFFUSER
 - REMOVABLE RETURN GRILLE
 - SWIRL GRILLE
 - CIRCULAR SWIRL GRILLE
 - EGGCRATE GRILLE
 - LECU GRILLE
 - CIRCULAR AIR VALVE
 - LINEAR DIFFUSER
 - BELLMOUTH
 - SUPPLY LOUVER
 - EXTRACT LOUVER
 - FIRE DAMPER
 - PRIMARY SUPPLY
 - EXTRACT / RETURN AIR
 - EXISTING
 - REMOVED / RELOCATED
 - DTB / RTA
 - DTL / RTL
 - VOLUME CONTROL DAMPER
 - BACKDRAUGHT DAMPER
 - CROSSTALK ATTENUATOR
 - IN LINE FAN
 - TWIN FAN
 - AC CONTROLLER
 - CENTRAL CONTROLLER
 - FAN CONTROLLER
 - ACCESS HATCH
 - HEAT RECOVERY UNIT
 - FAN COIL UNIT
 - AC CASSETTE
 - WALL MOUNTED FAN COIL
 - OUTDOOR CONDENSING UNIT
 - BRANCH CONTROLLER
 - PANEL HEATER / RADIATOR
 - PIPEWORK CONTAINMENT

REV	DESCRIPTION	DATE
P01	PRELIMINARY ISSUE	21.10.2022
P02	PRELIMINARY ISSUE	24.10.2022
P03	SECTION LINES ADDED	25.10.2022

DRAWING STATUS

PRELIMINARY



Unit 4a
Zebra Court
Greenside Way
Manchester
M24 1UN

0161 655 0290
info@pulseprojectsolutions.com
www.pulseprojectsolutions.com

PROJECT MANAGER	DESIGN
MIKE MCCORMACK	ARRON BUTLER
SCALE @A1	DRAWN BY
1:100	JORDAN TAYLOR

DATE 19.10.2022

PROJECT
TOOTAL BUILDING
LEE HOUSE
GREAT BRIDGEWATER STREET
MANCHESTER
M1 5JW

DRAWING TITLE
LEVEL 03
AC & VENTILATION LAYOUT

DRAWING NO.	REV
P2245-PPS-XX-03-DR-M-5901	P03