



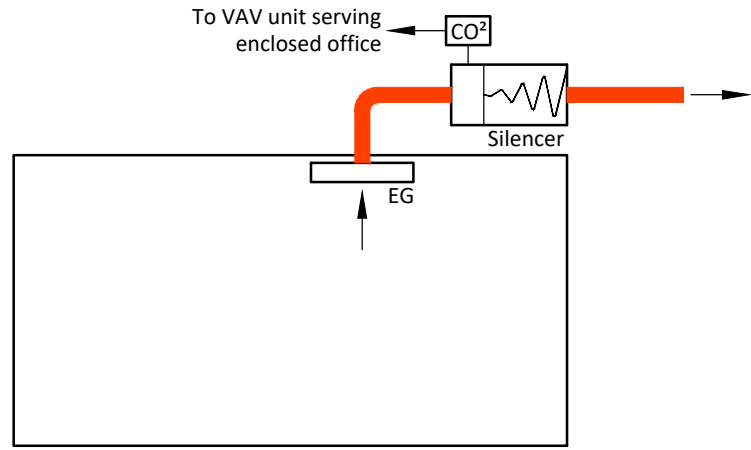

Typical Detail Of Extract Return Leg From Enclosed Office Spaces (N.T.S.)

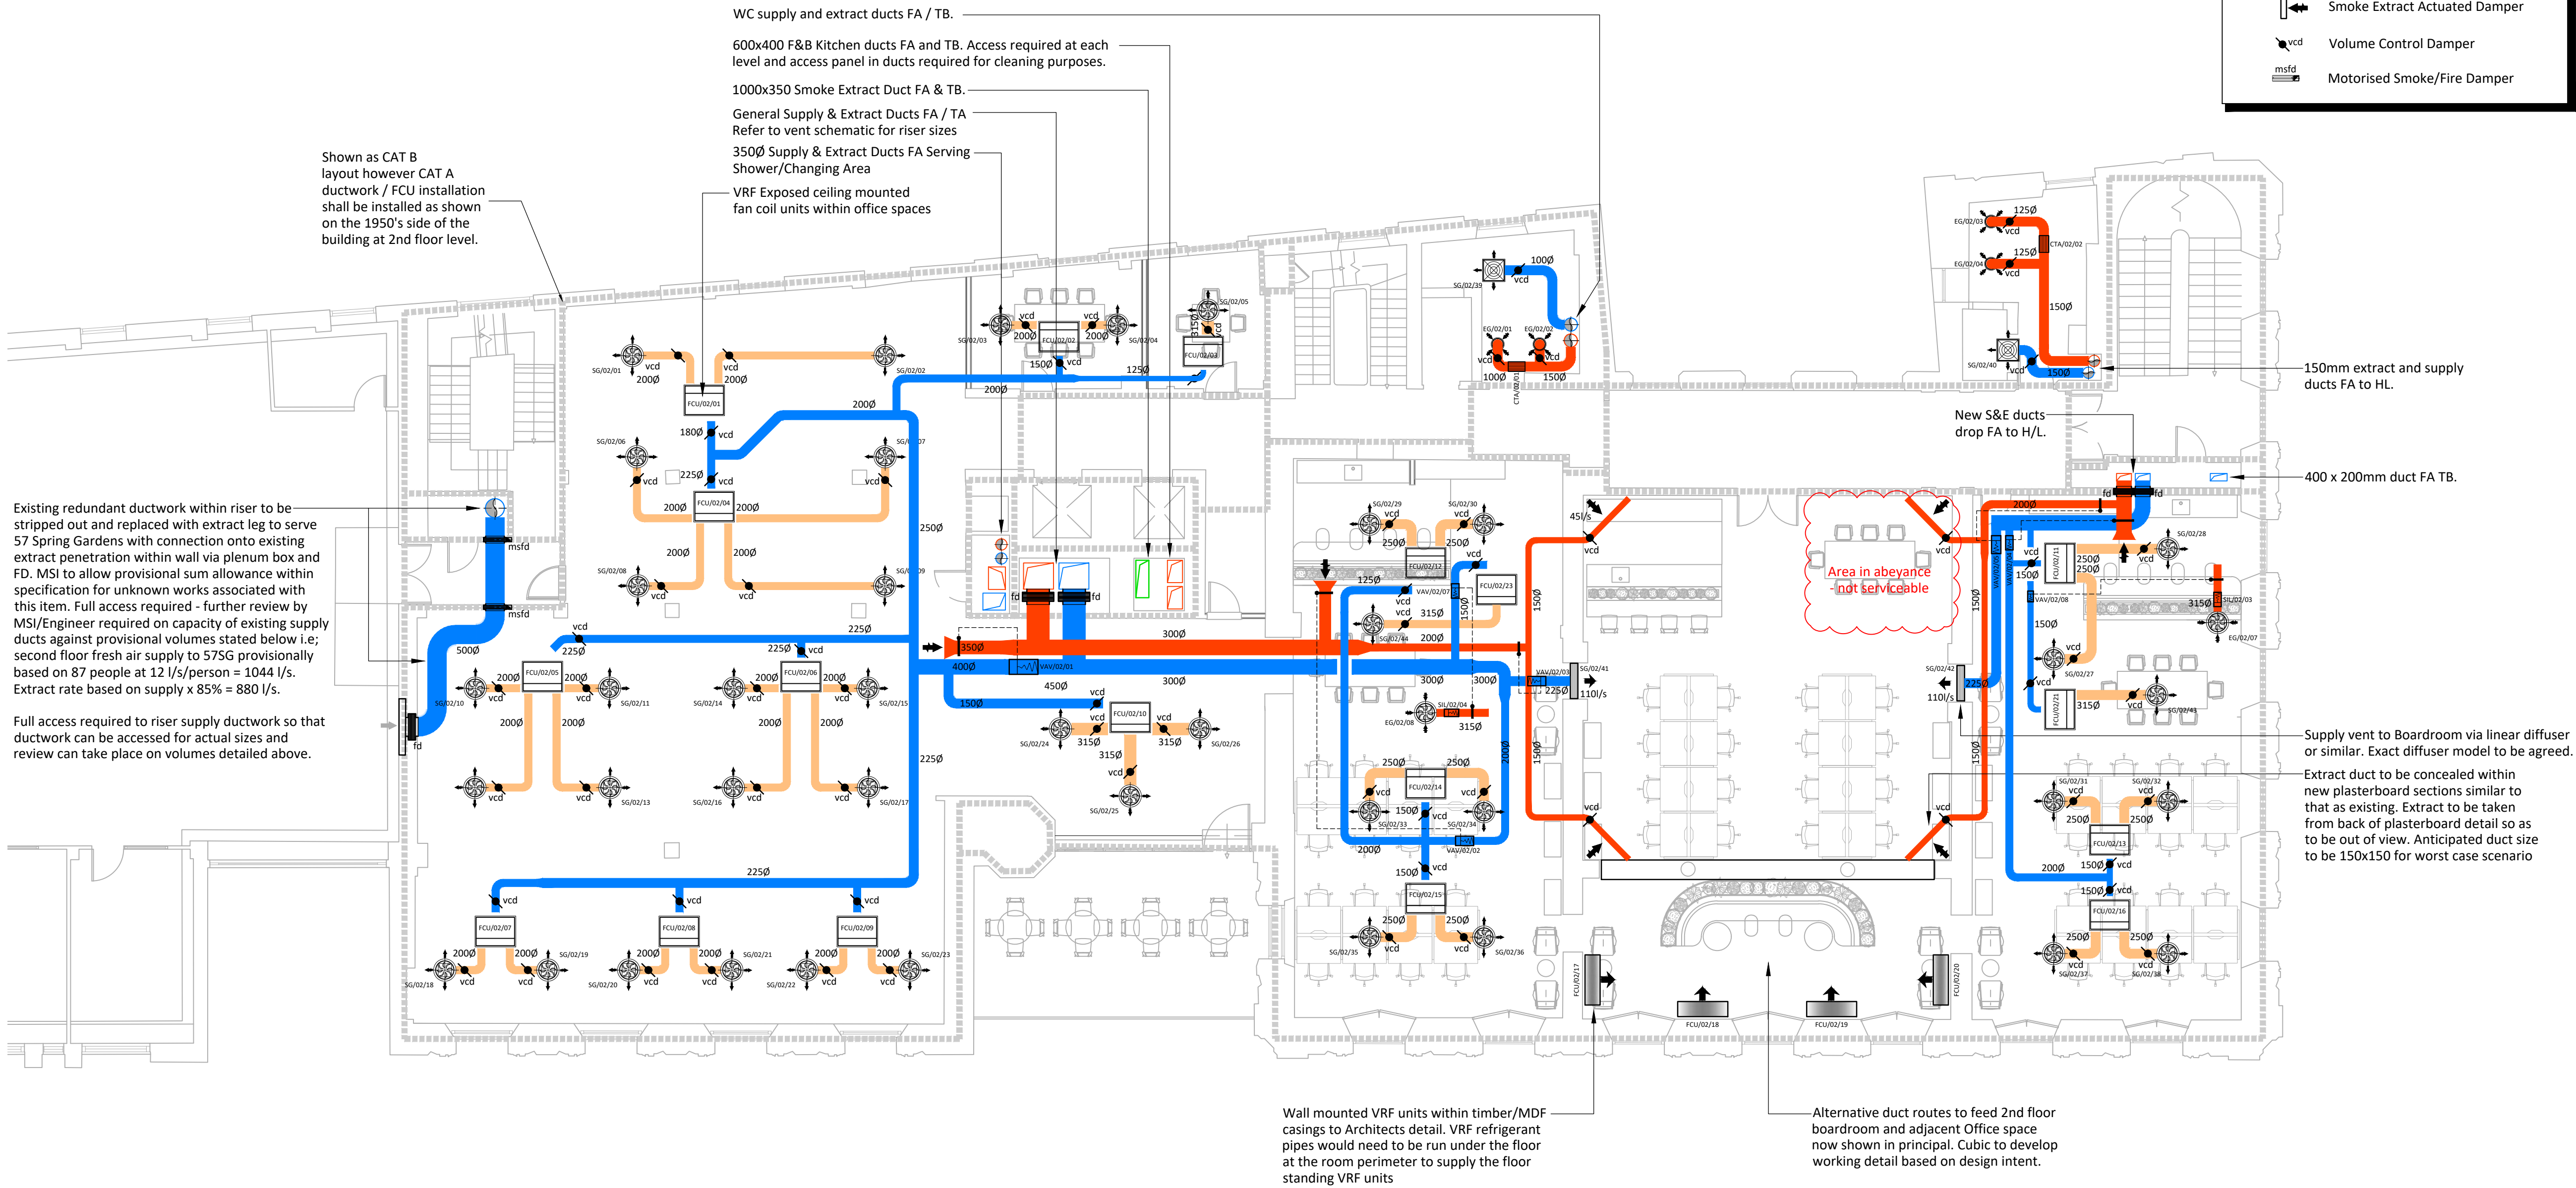

LEGEND:

- Fan Coil Unit
- Supply Air Diffuser
- Extract Air Diffuser
- General Extract Ductwork
- General Supply Ductwork
- Smoke Extract Ductwork
- Secondary Ductwork
- Indicates Fire Compartmentation
- Smoke Extract Actuated Damper Supply Makeup Route
- Smoke Extract Actuated Damper
- Volume Control Damper
- Motorised Smoke/Fire Damper

Do not scale from this drawing.
Verify dimensions by site measurement.
Read this drawing in conjunction with the latest architectural and structural drawings.
This drawing is based on the following information:-

- Notes**
- This drawing to be read in conjunction with all mechanical, electrical & public health drawings for this contract.
 - All services work to be carried out in accordance with the relevant Engineering Specification for this contract.
 - All existing Mechanical Services installations shall be isolated, disconnected and stripped out throughout the entire building unless stated otherwise. All stripped out materials to be disposed of in accordance with WEEE regulations.

07	16/09/22	FCU'S 01,02 & 03 relocated	PS	RB
06	09/09/22	CAT B Contractor Issue WC vent reviewed	SH	SH
05	12/08/22	CAT B Issue For Planning.	MR	SH
04	10/06/22	Planning updated issue.	MR	SH
03	20/05/22	Stage 4 Tender Update.	MR	SH
02	29/04/22	Stage 4 Tender Issue.	MR	SH
01	31/03/22	Stage 3 Issue.	RG	SH
Revision	Date	Description	Drawn	Checked

H|M

hilsonmoran.com info@hilsonmoran.com

Client

Bruntwood

Project

38-42 Mosley Street
Grade 2* Listed Building Refurbishment

Drawing Title

Mechanical Services
Second Floor
Ventilation Layout

Scale	Sheet Size	Checked	Approved
1:100	A1	SH	SR
Status	HM Project No.		
FOR INFORMATION			27618
Drawing No.	Rev		
27618-HM-ZZ-02-DR-MS-2203			07