


File ref - c:\users\dwalker\onedrive - amey plc\desktop\nov 21\exchange st\msl-12-24502531-rev.f.dwg

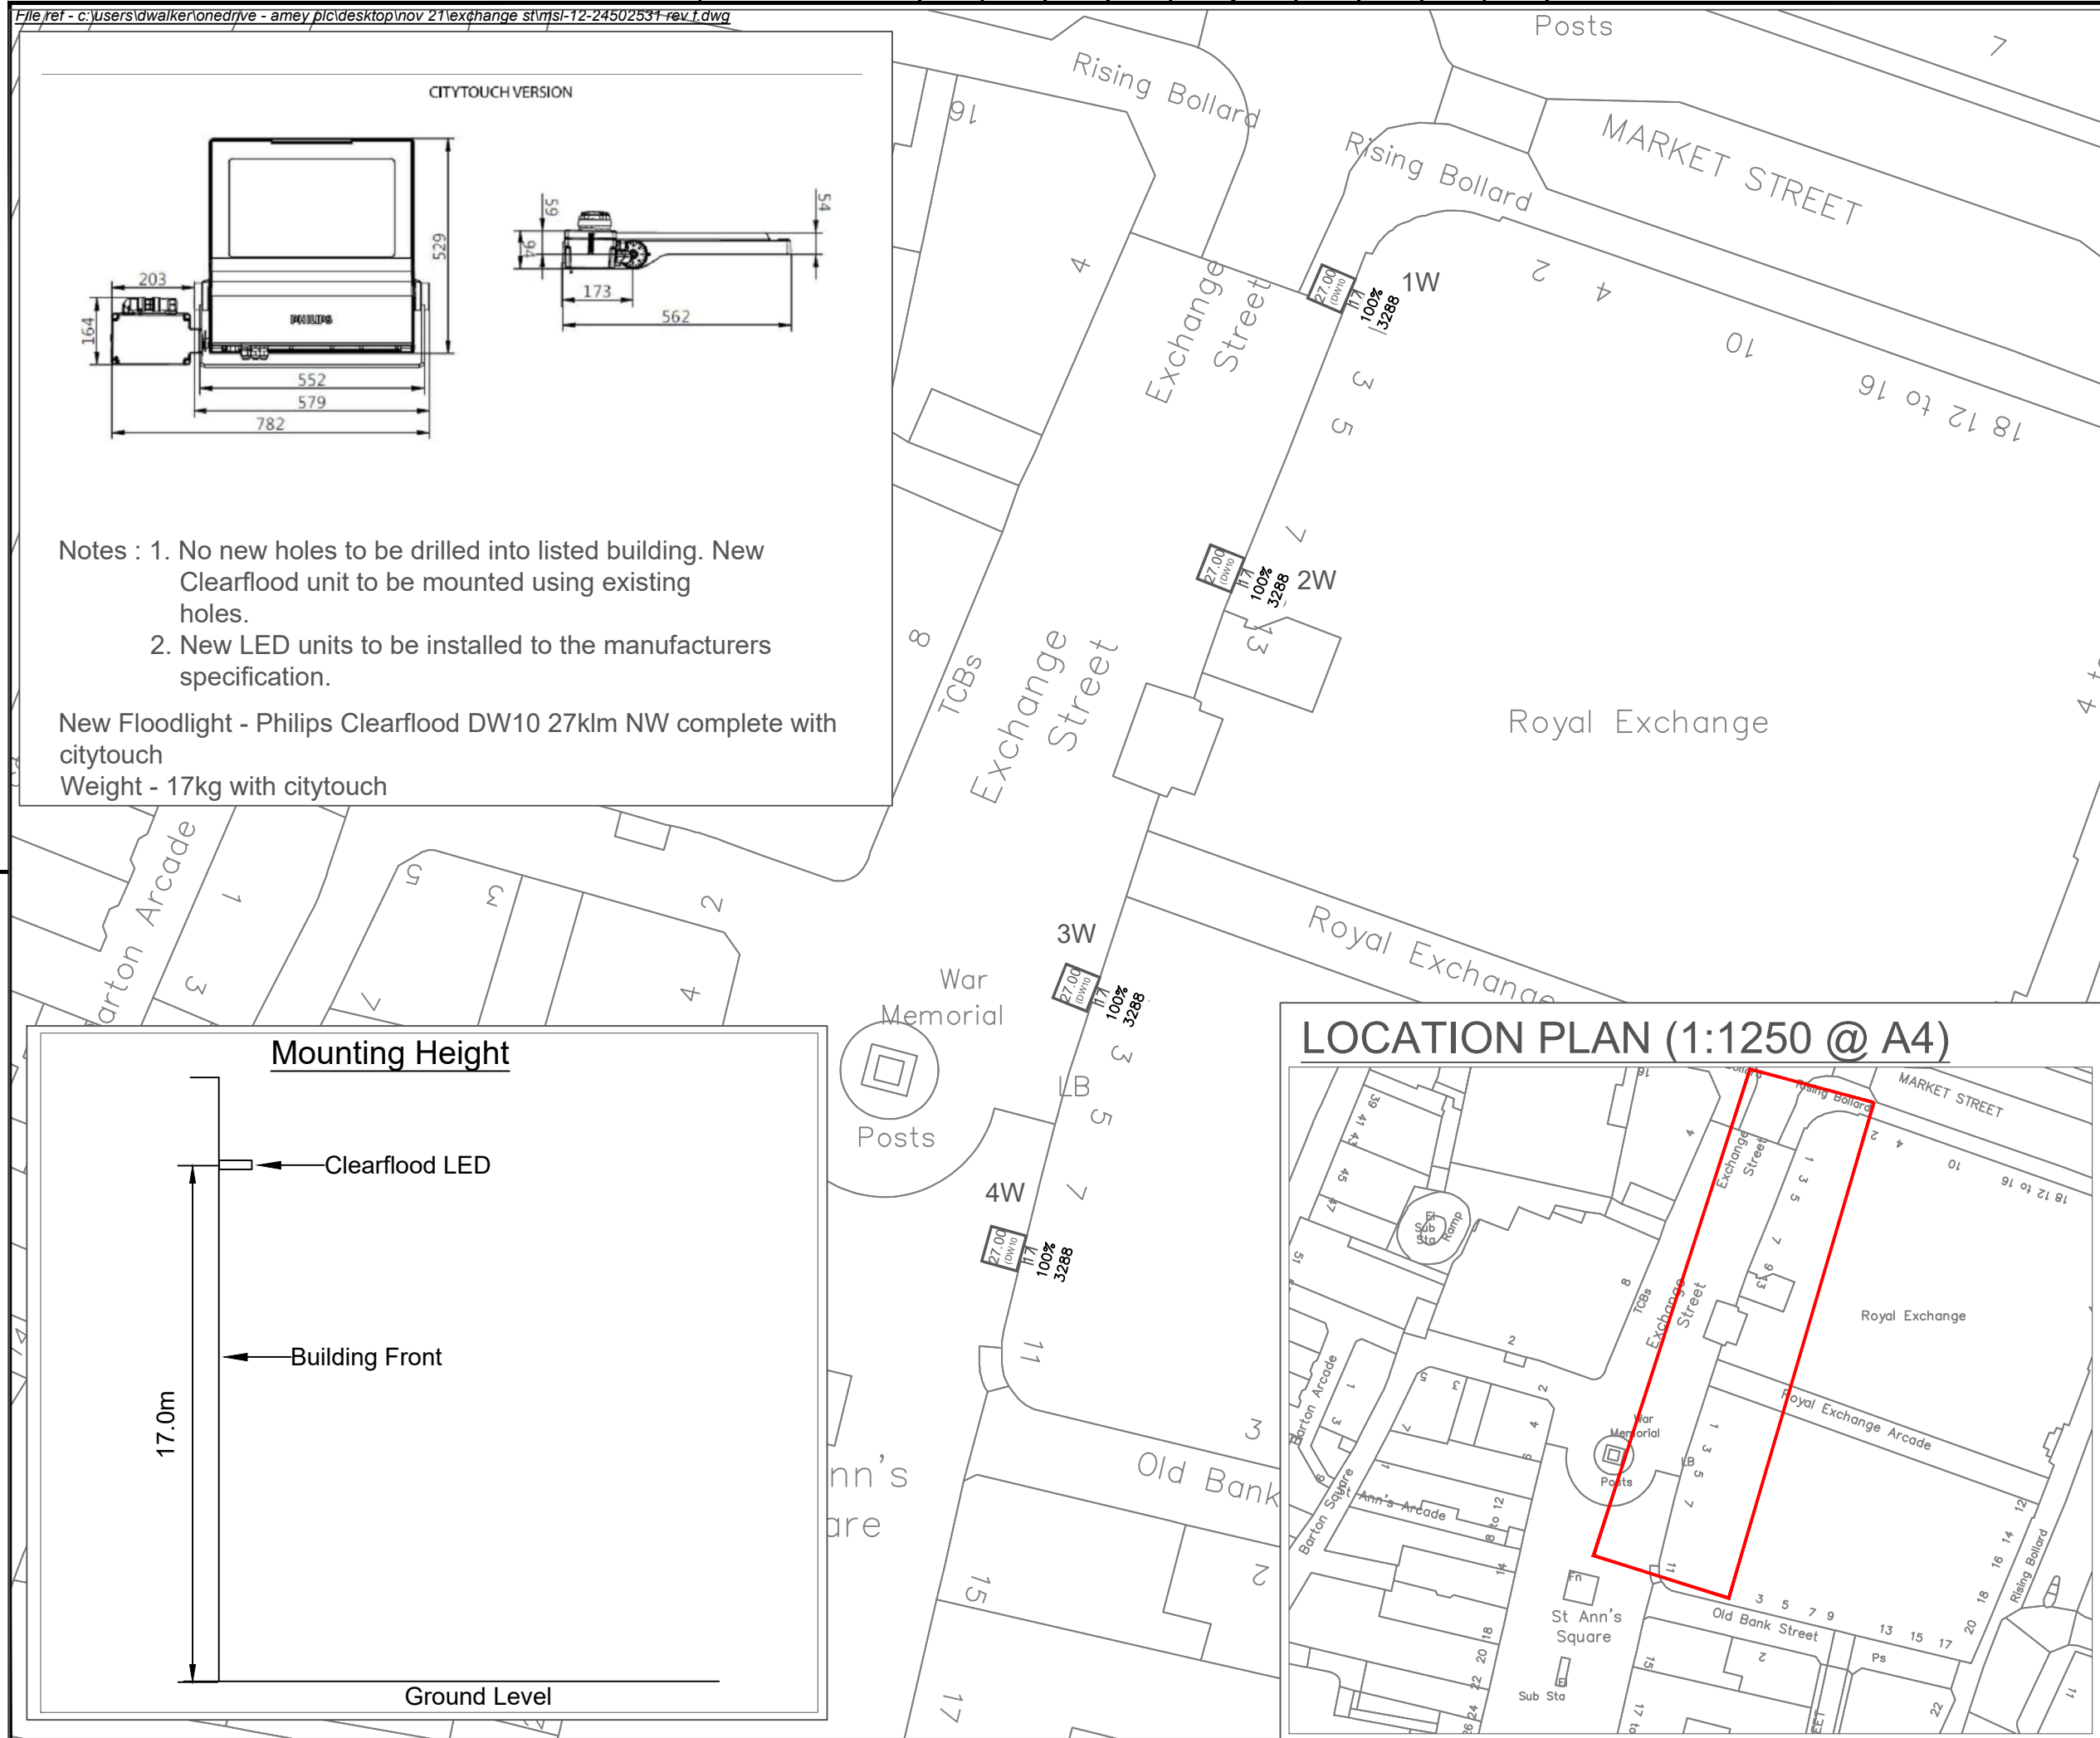

Notes : 1. No new holes to be drilled into listed building. New Clearflood unit to be mounted using existing holes.
2. New LED units to be installed to the manufacturers specification.

New Floodlight - Philips Clearflood DW10 27klm NW complete with citytouch
Weight - 17kg with citytouch

**DESIGN HAZARDS**
(The following information has been collected from Preconstruction Information and Amey Process CDM Hazard Management Process.)

NOTE:
Structural check of all columns must be undertaken prior to installation of new luminaire to confirm asset is capable of carrying change in weight / wind loading

DESIGN CLASS APPLIED:
City Centre - C2

1.0klm
(DM50)

10

90%

240

← LUMEN OUTPUT / OPTIC

← COLUMN HEIGHT

← DIMMING PROFILE

← CALCULATION NUMBER

F	Updated as per comments from MCC	DJW	DJW	JUL 2022
E	Note updated	DJW	DJW	FEB 2022
D	Wall brackets 1-4 changed to Clearfloods	DJW	CR	NOV 2021
C	Columns 1-3 Klm amended	CR	KP	NOV 2020
B	Columns 1-3 added	CR	KP	APR 2020
Rev	Revision details	Chkd	Appd	Date
Designed: DJW		Date: JAN 2018		
Drawn: CJM		Date: OCT 2017		
Checked: CR		Date: JAN 2018		
Approved: IE		Date: JAN 2018		

Copyright © Amey


www.amey.co.uk

Client


MANCHESTER CITY COUNCIL

Project Name

**EXCHANGE STREET
CITY CENTRE
MANCHESTER**

Drawing Title

**Street Lighting
PROPOSED ROAD
LIGHTING LAYOUT**

Original Drg Size : A3	Scale : 1:500
Dimensions : m	Tile No : 52

Drawing Status	Suitability
DOCUMENTATION	A

Drawing No	Revision
MSL-12-24502531	F