

 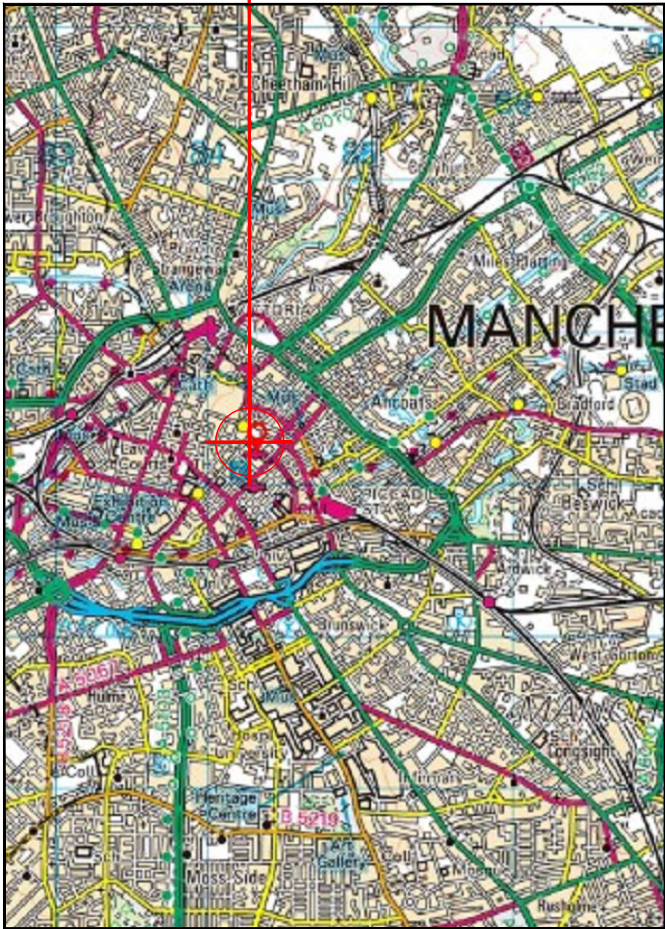


SITE LOCATION

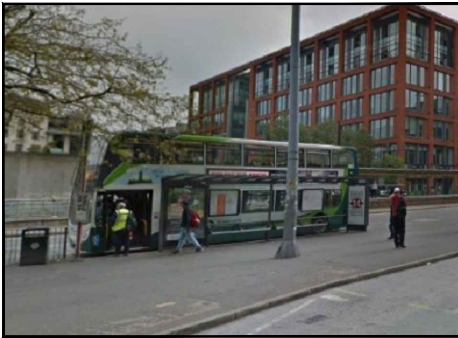


Reproduced by permission of Ordnance Survey on behalf of the Controller of Her Majesty's Stationery Office
All rights reserved. © Crown Copyright licence no. 100022432

SITE AREA PLAN




SITE PHOTOGRAPH

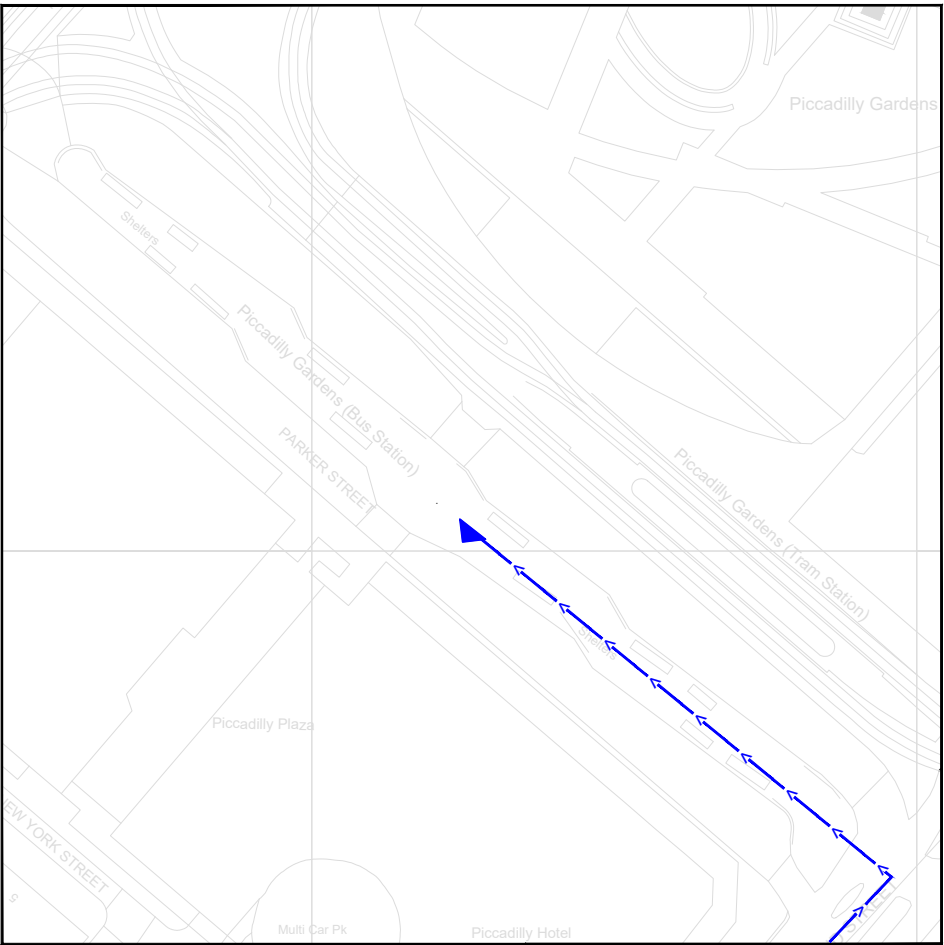

Reproduced by permission of Ordnance Survey on behalf
of the Controller of Her Majesty's Stationery Office
All rights reserved. © Crown Copyright licence no. 100022432

NGR E: 384325 N: 398203

 SITE LOCATION PLAN



GOOGLE MAPS QR CODE

GOOGLE MAPS - <https://goo.gl/maps/pUrDKkMLqPEzTUmHA>

GOOGLE STREETVIEW -<https://goo.gl/maps/MSMC9vZJekjVUXZq9>

NOTES:

1. ALL DIMENSIONS IN MM UNLESS OTHERWISE NOTED.

DIRECTIONS TO SITE:

Head South-West on M60 and take junction 24 exit A57/M67 towards M'cr City Centre. After 0.4miles , at the Denton roundabout take the third exit onto Ardwick Green S/A6 and continue to follow A6. Continue onto Minshull Street to George Street. Use the middle lane to turn left onto Minshull street and after 0.2miles turn left onto Portland Street/A5103. After 433 ft turn right onto Charlotte street and then turn right onto George street . At the end of the road turn right onto New York Street and then Left onto Portland Street . Site will be on left hand side , Bus access only .

Access Route To Site:



Master:	MBNL / EE / H3G:	Project:	Purpose of Issue:	Issue:
M001	H3G	DENSIFICATION SW	Planning	A
Date:	19/08/2022	Revision / Upgrade Description:		
Drawn:	S.Booth	First Issue - Site nomination dated: TBC		
Checked:	G.Thomas			
Approved:	G.Thomas			



Hutchison 3G UK Limited
Green Park, 450 Longwater Avenue
Reading, RG30 3UR
Tel: 01628 765 000
Fax: 01628 765 001

H3G Base Station Information line:
0845 6043000
Available 8am-8pm Monday to Friday

Design Consultant & Principal Contractor:



Unit E, Madison Place, Northampton Road,
Manchester, M40 5AG
Tel: 0161 785 4500 Fax: 0161 785 4501
Web: www.clarke-telecom.com

Site Name:
PICCADILLY GARDENS SW'S

Site ID:
MAN24497

Address:
PICCADILLY GARDENS SW'S
PARKER STREET
PICCADILLY GARDENS
MANCHESTER
M1 1AF


Title:
002 SITE LOCATION PLAN

Project:
H3G DENSIFICATION STREETWORKS

Purpose of Issue:
PLANNING

EE Cell ID:	MBNL Cell ID:	3UK Cell ID:
-	-	MAN24479

Master Drawing No:	Issue:
MAN24479_B35_GA_A	A

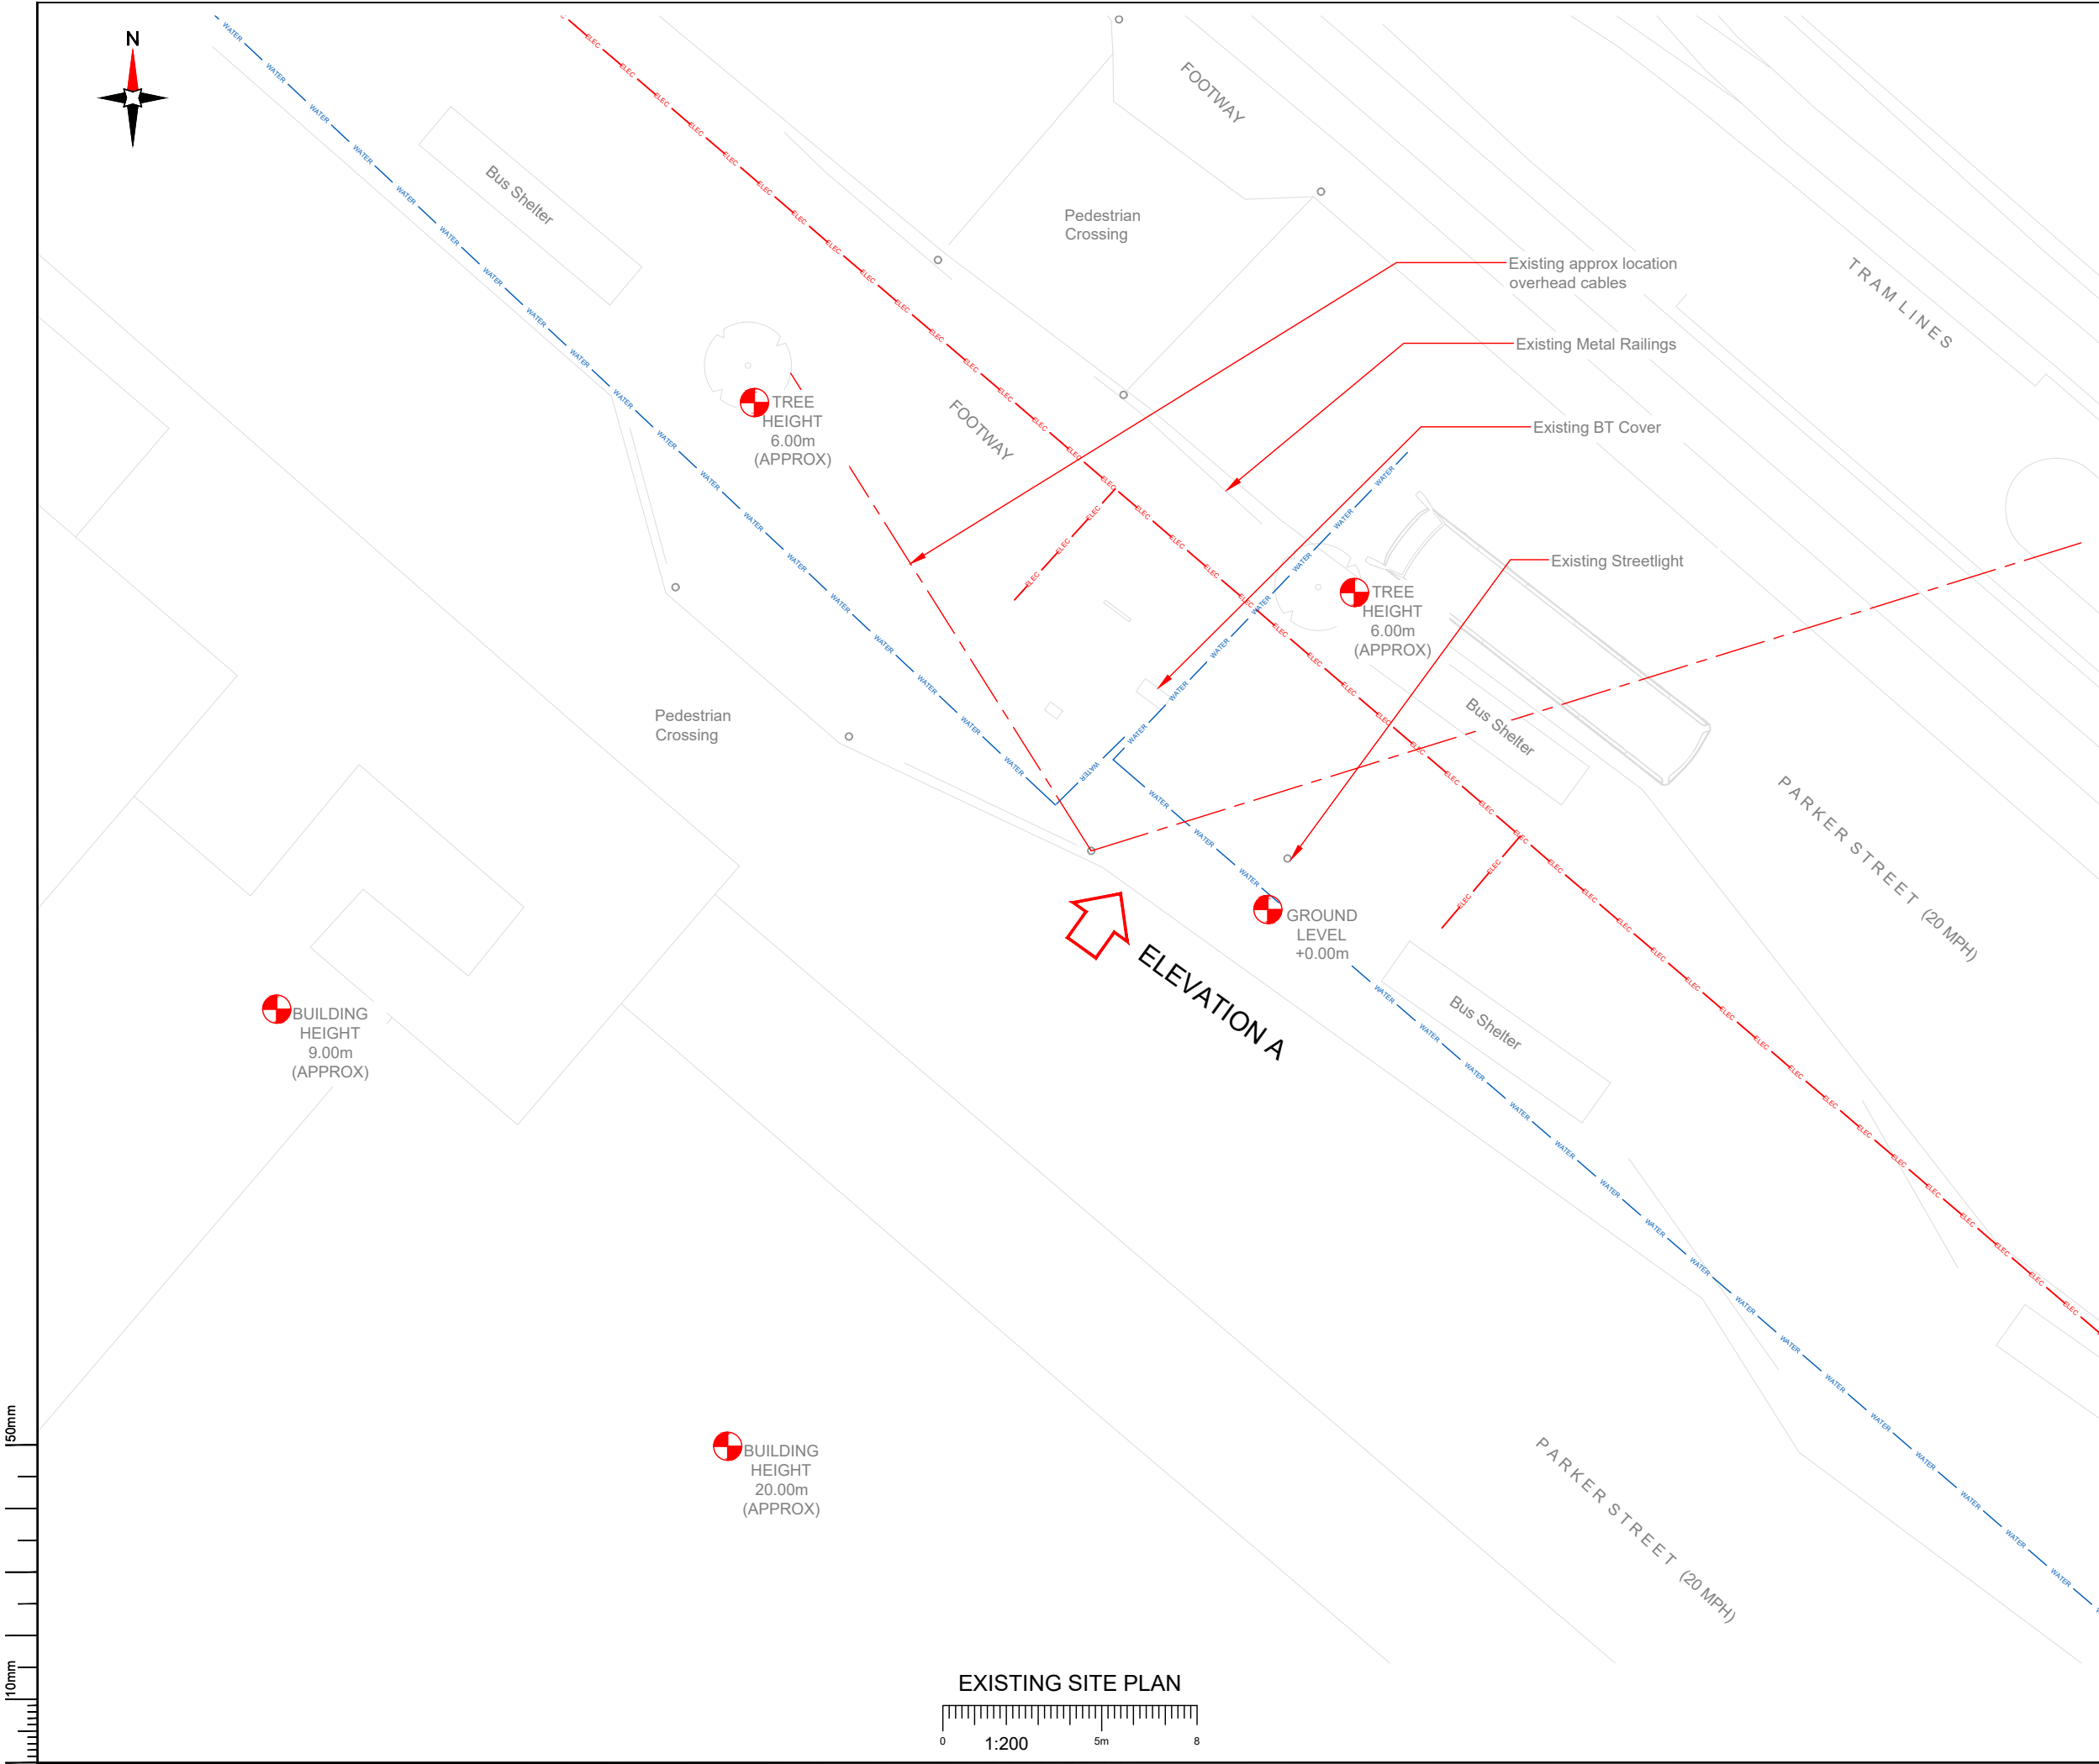

NOTES:

1. ALL DIMENSIONS IN MM UNLESS OTHERWISE NOTED.

SERVICES:

WATER

WATER

WATER

WATER

HV

HV

HV

HV

GAS

GAS

GAS

GAS

TELECOMS

TELECOMS

TELECOMS

TELECOMS

?

?

?

?

ELEC

ELEC

ELEC

ELEC

NOTES:

Stats to be reviewed prior to any build works commencing.Radar Scan TBC.

Hutchison 3G UK Limited
Green Park, 450 Longwater Avenue
Reading, RG30 3UR
Tel: 01628 765 000
Fax: 01628 765 001

 

H3G Base Station Information line:
0845 6043000
Available 8am-8pm Monday to Friday

Unit E, Madison Place, Northampton Road,
Manchester, M40 5AG
Tel: 0161 785 4500 Fax: 0161 785 4501
Web: www.clarke-telecom.com

100mm

50mm

10mm

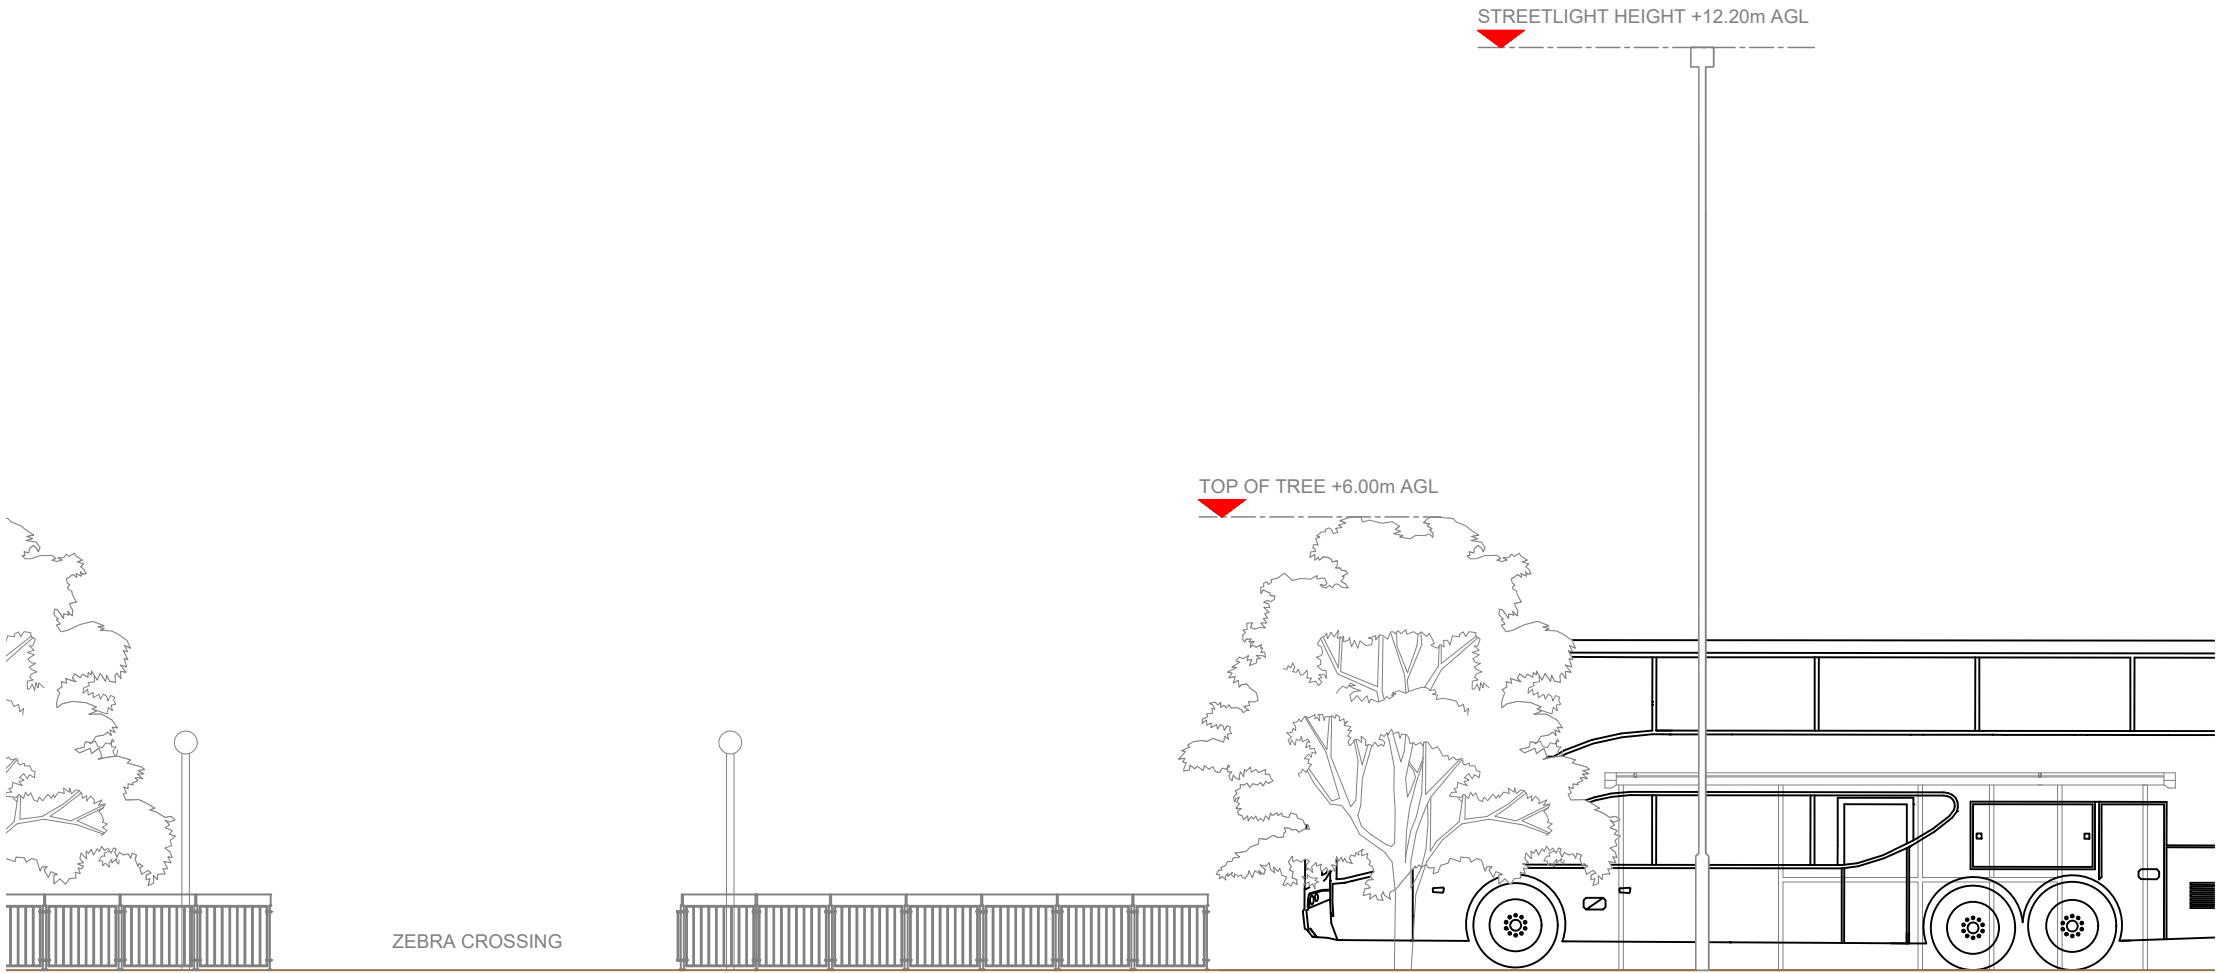

NOTES:

1. ALL DIMENSIONS IN MM UNLESS OTHERWISE NOTED.

Master:	MBNL / EE / H3G:	Project:	Purpose of Issue:	Issue:
M001	H3G	DENSIFICATION SW	Planning	A
Date:	19/08/2022	Revision / Upgrade Description:		
Drawn:	S.Booth	First Issue - Site nomination dated: TBC		
Checked:	G.Thomas			
Approved:	G.Thomas			



Hutchison 3G UK Limited
Green Park, 450 Longwater Avenue
Reading, RG30 3UR
Tel: 01628 765 000
Fax: 01628 765 001

H3G Base Station Information line:
0845 6043000
Available 8am-8pm Monday to Friday

Design Consultant & Principal Contractor:

CLARKE
telecom

Unit E, Madison Place, Northampton Road,
Manchester, M40 5AG
Tel: 0161 785 4500 Fax: 0161 785 4501
Web: www.clarke-telecom.com

Site Name:

PICCADILLY GARDENS SW'S

Site ID:

MAN24497

Address:

PICCADILLY GARDENS SW'S
PARKER STREET
PICCADILLY GARDENS
MANCHESTER
M1 1AF

Title:

150 EXISTING H3G SITE ELEVATION

Project:


H3G DENSIFICATION STREETWORKS

Purpose of Issue:

PLANNING



EE Cell ID:	MBNL Cell ID:	3UK Cell ID:
-	-	MAN24479

Master Drawing No:	Issue:
MAN24479_B35_GA_A	A

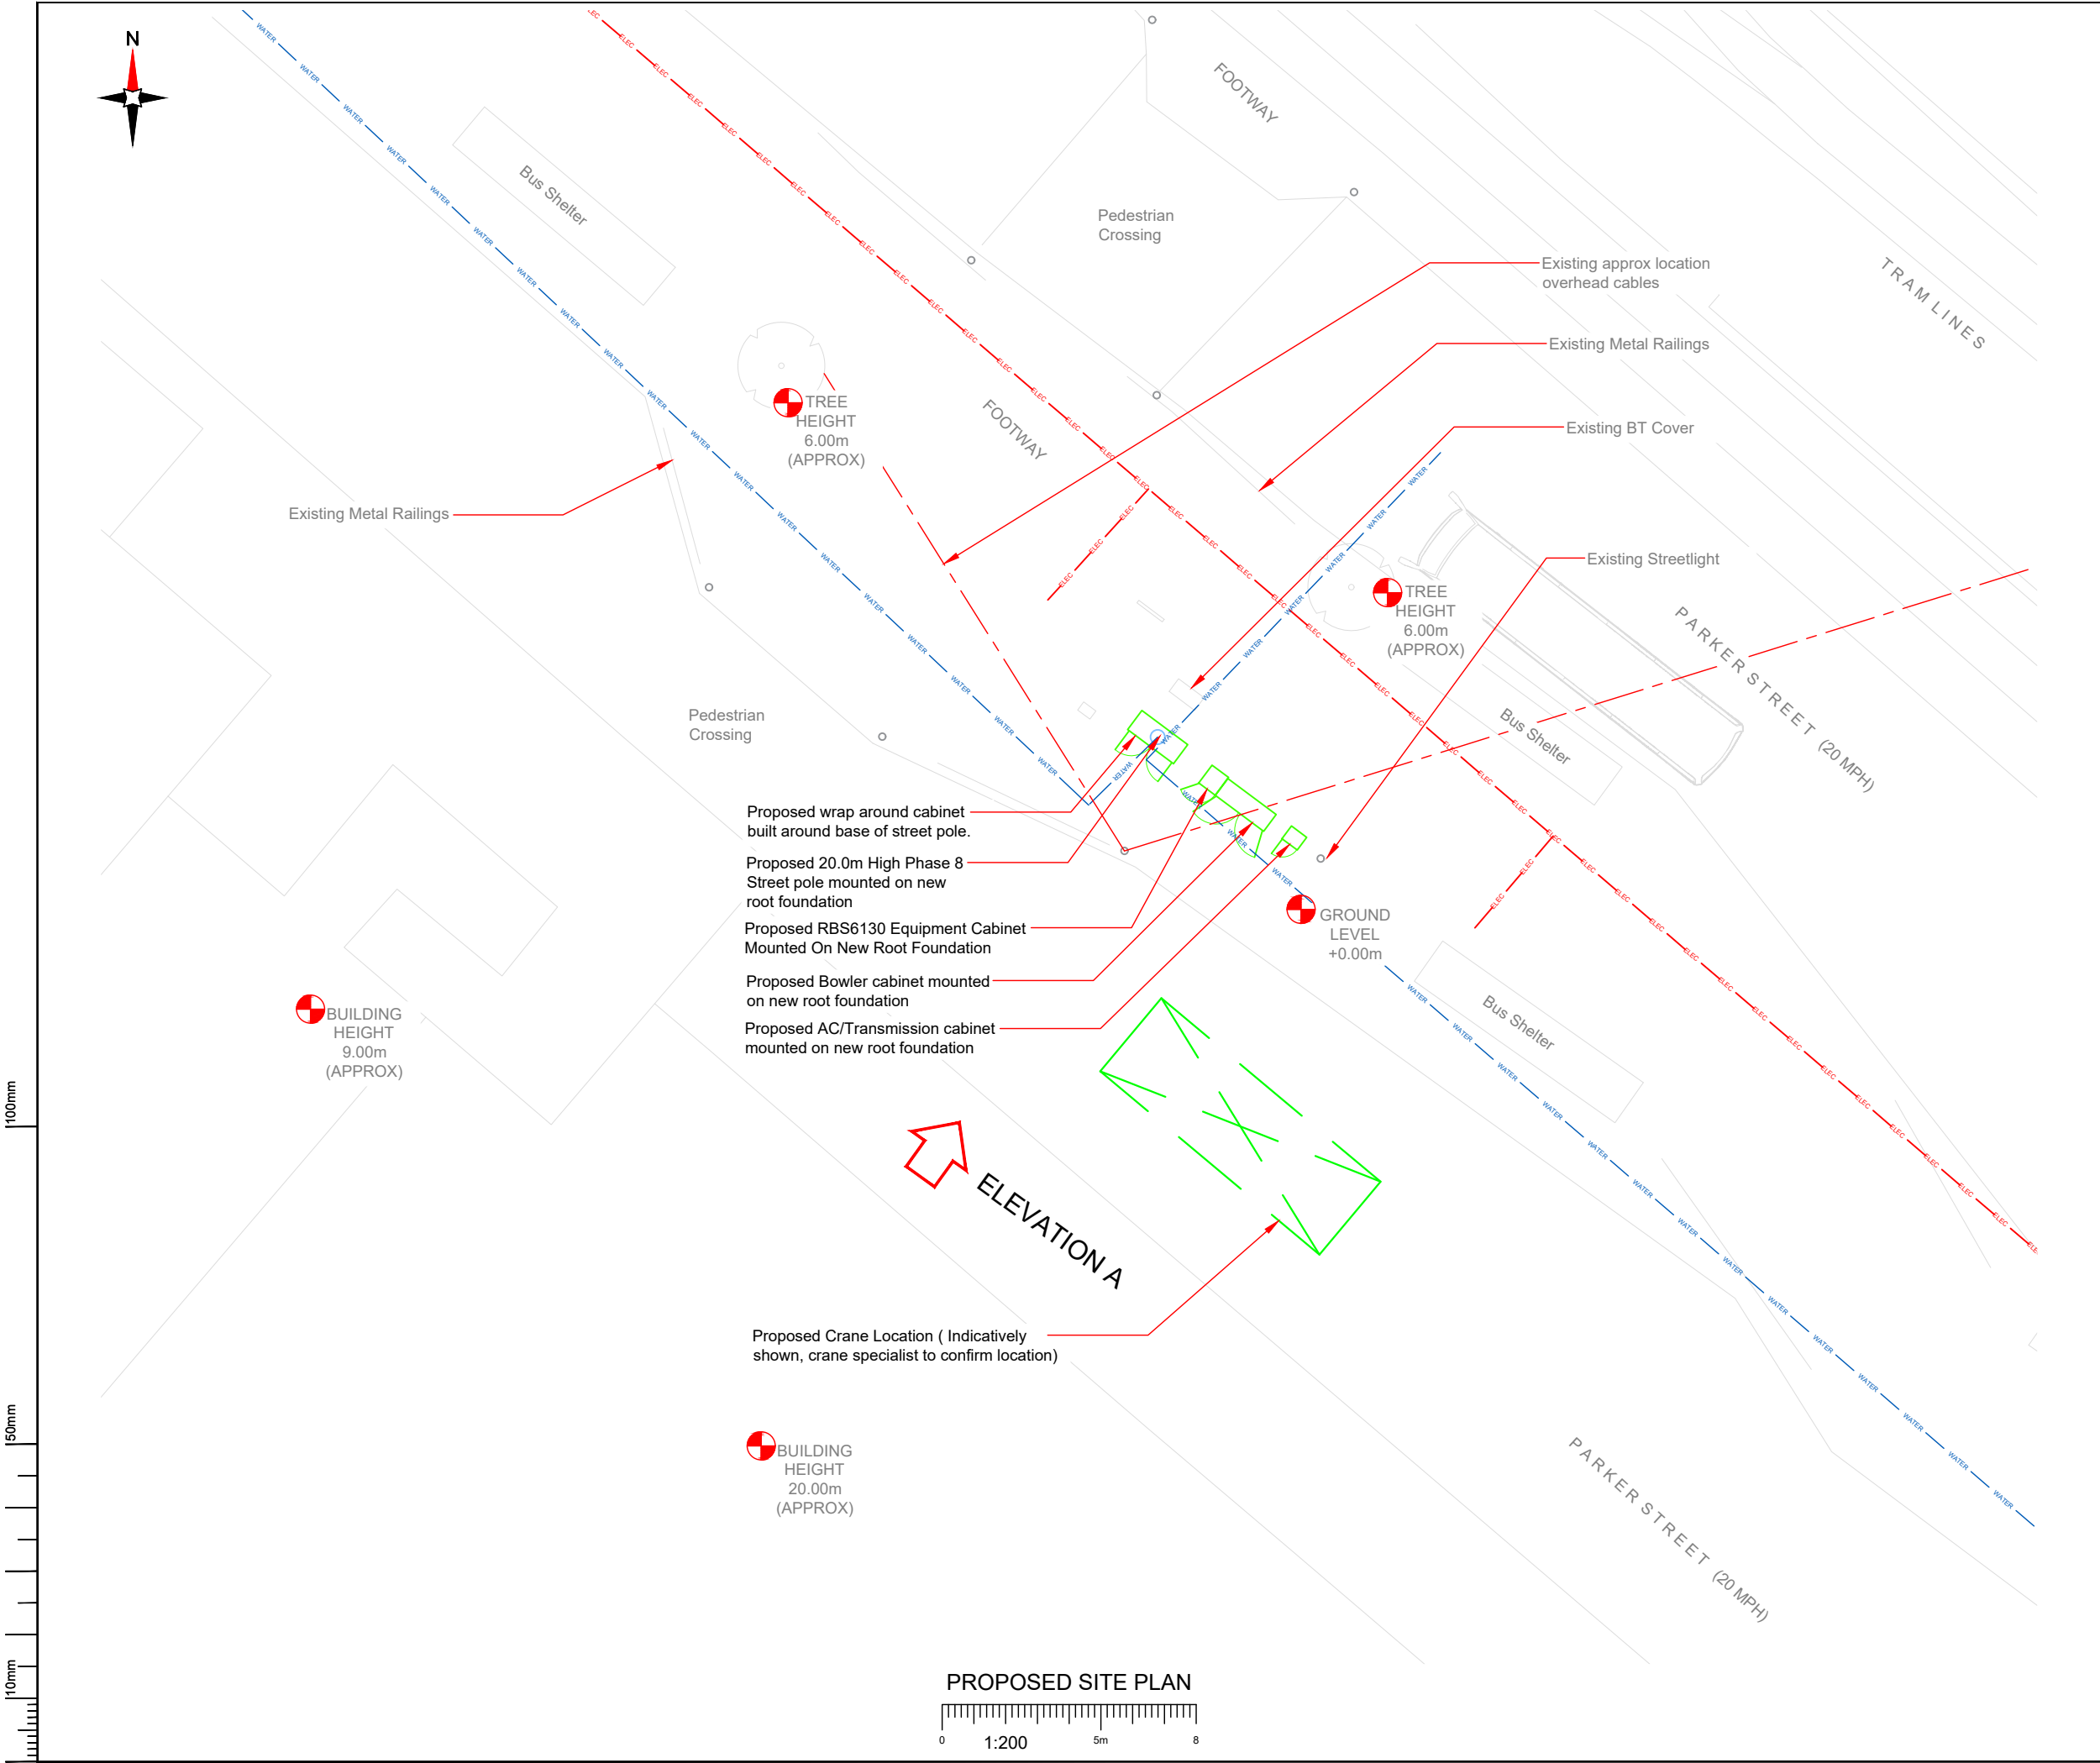

NOTES:

1. ALL DIMENSIONS IN MM UNLESS OTHERWISE NOTED.

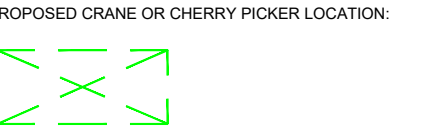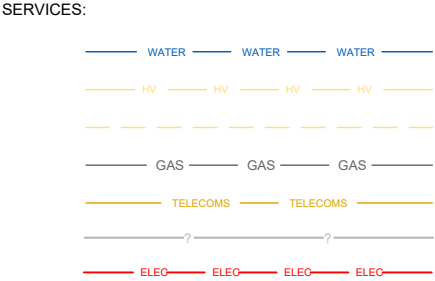

NOTES:

Stats to be reviewed prior to any build works commencing.Radar Scan TBC.

Master:	MBNL / EE / H3G:	Project:	Purpose of Issue:	Issue:
M001	H3G	DENSIFICATION SW	Planning	A
Date:	19/08/2022	Revision / Upgrade Description:		
Drawn:	S.Booth	First Issue - Site nomination dated: TBC		
Checked:	G.Thomas			
Approved:	G.Thomas			



Hutchison 3G UK Limited
Green Park, 450 Longwater Avenue
Reading, RG30 3UR
Tel: 01628 765 000
Fax: 01628 765 001

H3G Base Station Information line:
0845 6043000
Available 8am-8pm Monday to Friday


Design Consultant & Principal Contractor:

CLARKE telecom

Unit E, Madison Place, Northampton Road,
Manchester, M40 5AG
Tel: 0161 785 4500 Fax: 0161 785 4501
Web: www.clarke-telecom.com

Site Name:	PICCADILLY GARDENS SW'S		
Site ID:	MAN24497		
Address:	PICCADILLY GARDENS SW'S PARKER STREET PICCADILLY GARDENS MANCHESTER M1 1AF		
Title:	210 PROPOSED H3G SITE PLAN		
Project:	H3G DENSIFICATION STREETWORKS		
Purpose of Issue:	PLANNING		
EE Cell ID:	MBNL Cell ID:	3UK Cell ID:	
-	-	MAN24479	
Master Drawing No:			Issue:
MAN24479_B35_GA_A			A

100mm
50mm
10mm

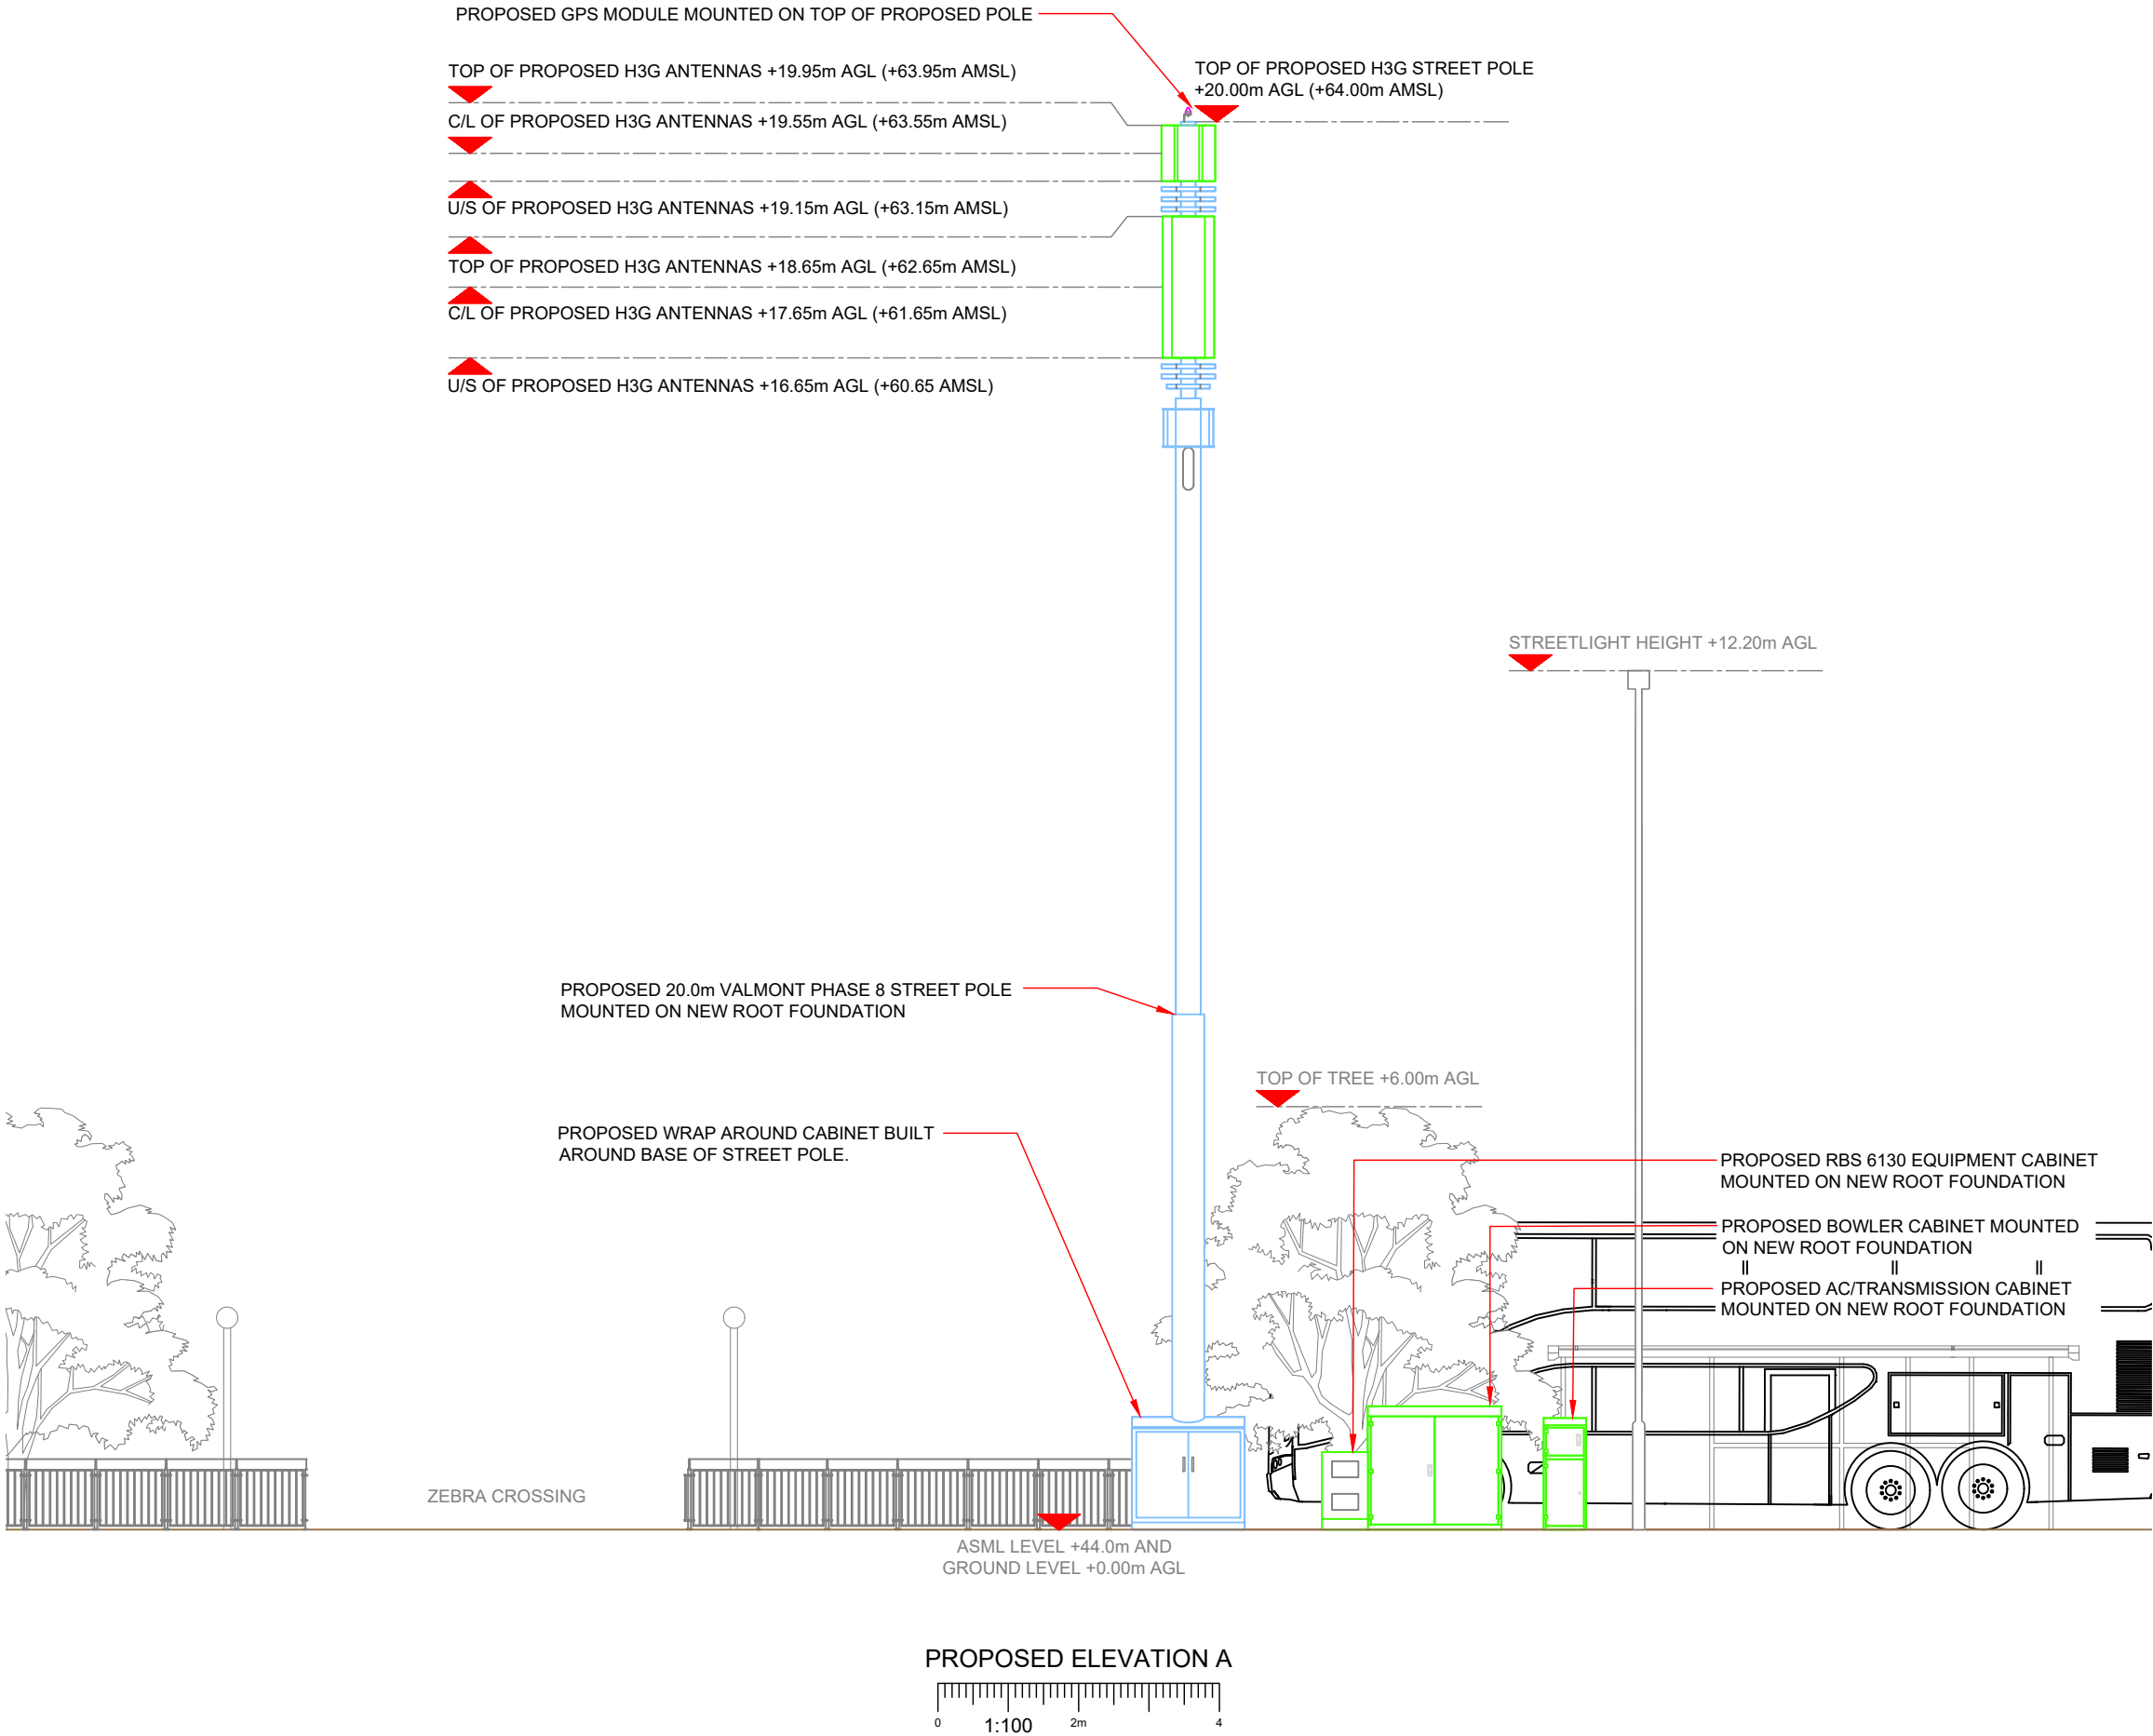

NOTES:
1. ALL DIMENSIONS IN MM UNLESS OTHERWISE NOTED.

Master:	MBNL / EE / H3G:	Project:	Purpose of Issue:	Issue:
M001	H3G	DENSIFICATION SW	Planning	A
Date:	19/08/2022	Revision / Upgrade Description:		
Drawn:	S.Booth	First Issue - Site nomination dated: TBC		
Checked:	G.Thomas			
Approved:	G.Thomas			

Hutchison 3G UK Limited
Green Park, 450 Longwater Avenue
Reading, RG30 3UR
Tel: 01628 765 000
Fax: 01628 765 001

H3G Base Station Information line:
0845 6043000
Available 8am-8pm Monday to Friday

Design Consultant & Principal Contractor:

Unit E, Madison Place, Northampton Road,
Manchester, M40 5AG
Tel: 0161 785 4500 Fax: 0161 785 4501
Web: www.clarke-telecom.com

Site Name:
PICCADILLY GARDENS SW'S

Site ID:
MAN24497

Address:
PICCADILLY GARDENS SW'S
PARKER STREET
PICCADILLY GARDENS
MANCHESTER
M1 1AF

Title:
260 PROPOSED H3G SITE ELEVATION

Project:
H3G DENSIFICATION STREETWORKS

Purpose of Issue:
PLANNING

EE Cell ID: -	MBNL Cell ID: -	3UK Cell ID: MAN24479
------------------	--------------------	--------------------------

Master Drawing No:
MAN24479_B35_GA_A

Issue:
A