



REV	DATE	DESCRIPTION	BY	ENG
P01	27/10/2021	INITIAL ISSUE	AL	AL
P02	10/11/2021	COLLUM ISSUE, XREF CHANGED, AMENDED, LEGEND ADDED.	AL	AL
P03	12/11/2021	NOTES CHANGED, ROOF VOID VENTILATION TRANSFERRED TO DRG AMENDED TO SUIT ROOM LAYOUT CHANGES.	AL	AL
P04	01/12/2021	SERVICES AMENDED AROUND SECOND FLOOR CORRIDOR ARRANGEMENTS AND DESIGNATIONS CHANGED.	AL	AL
P06	25/07/2022	SUITABILITY CHANGED TO S3	AL	AL

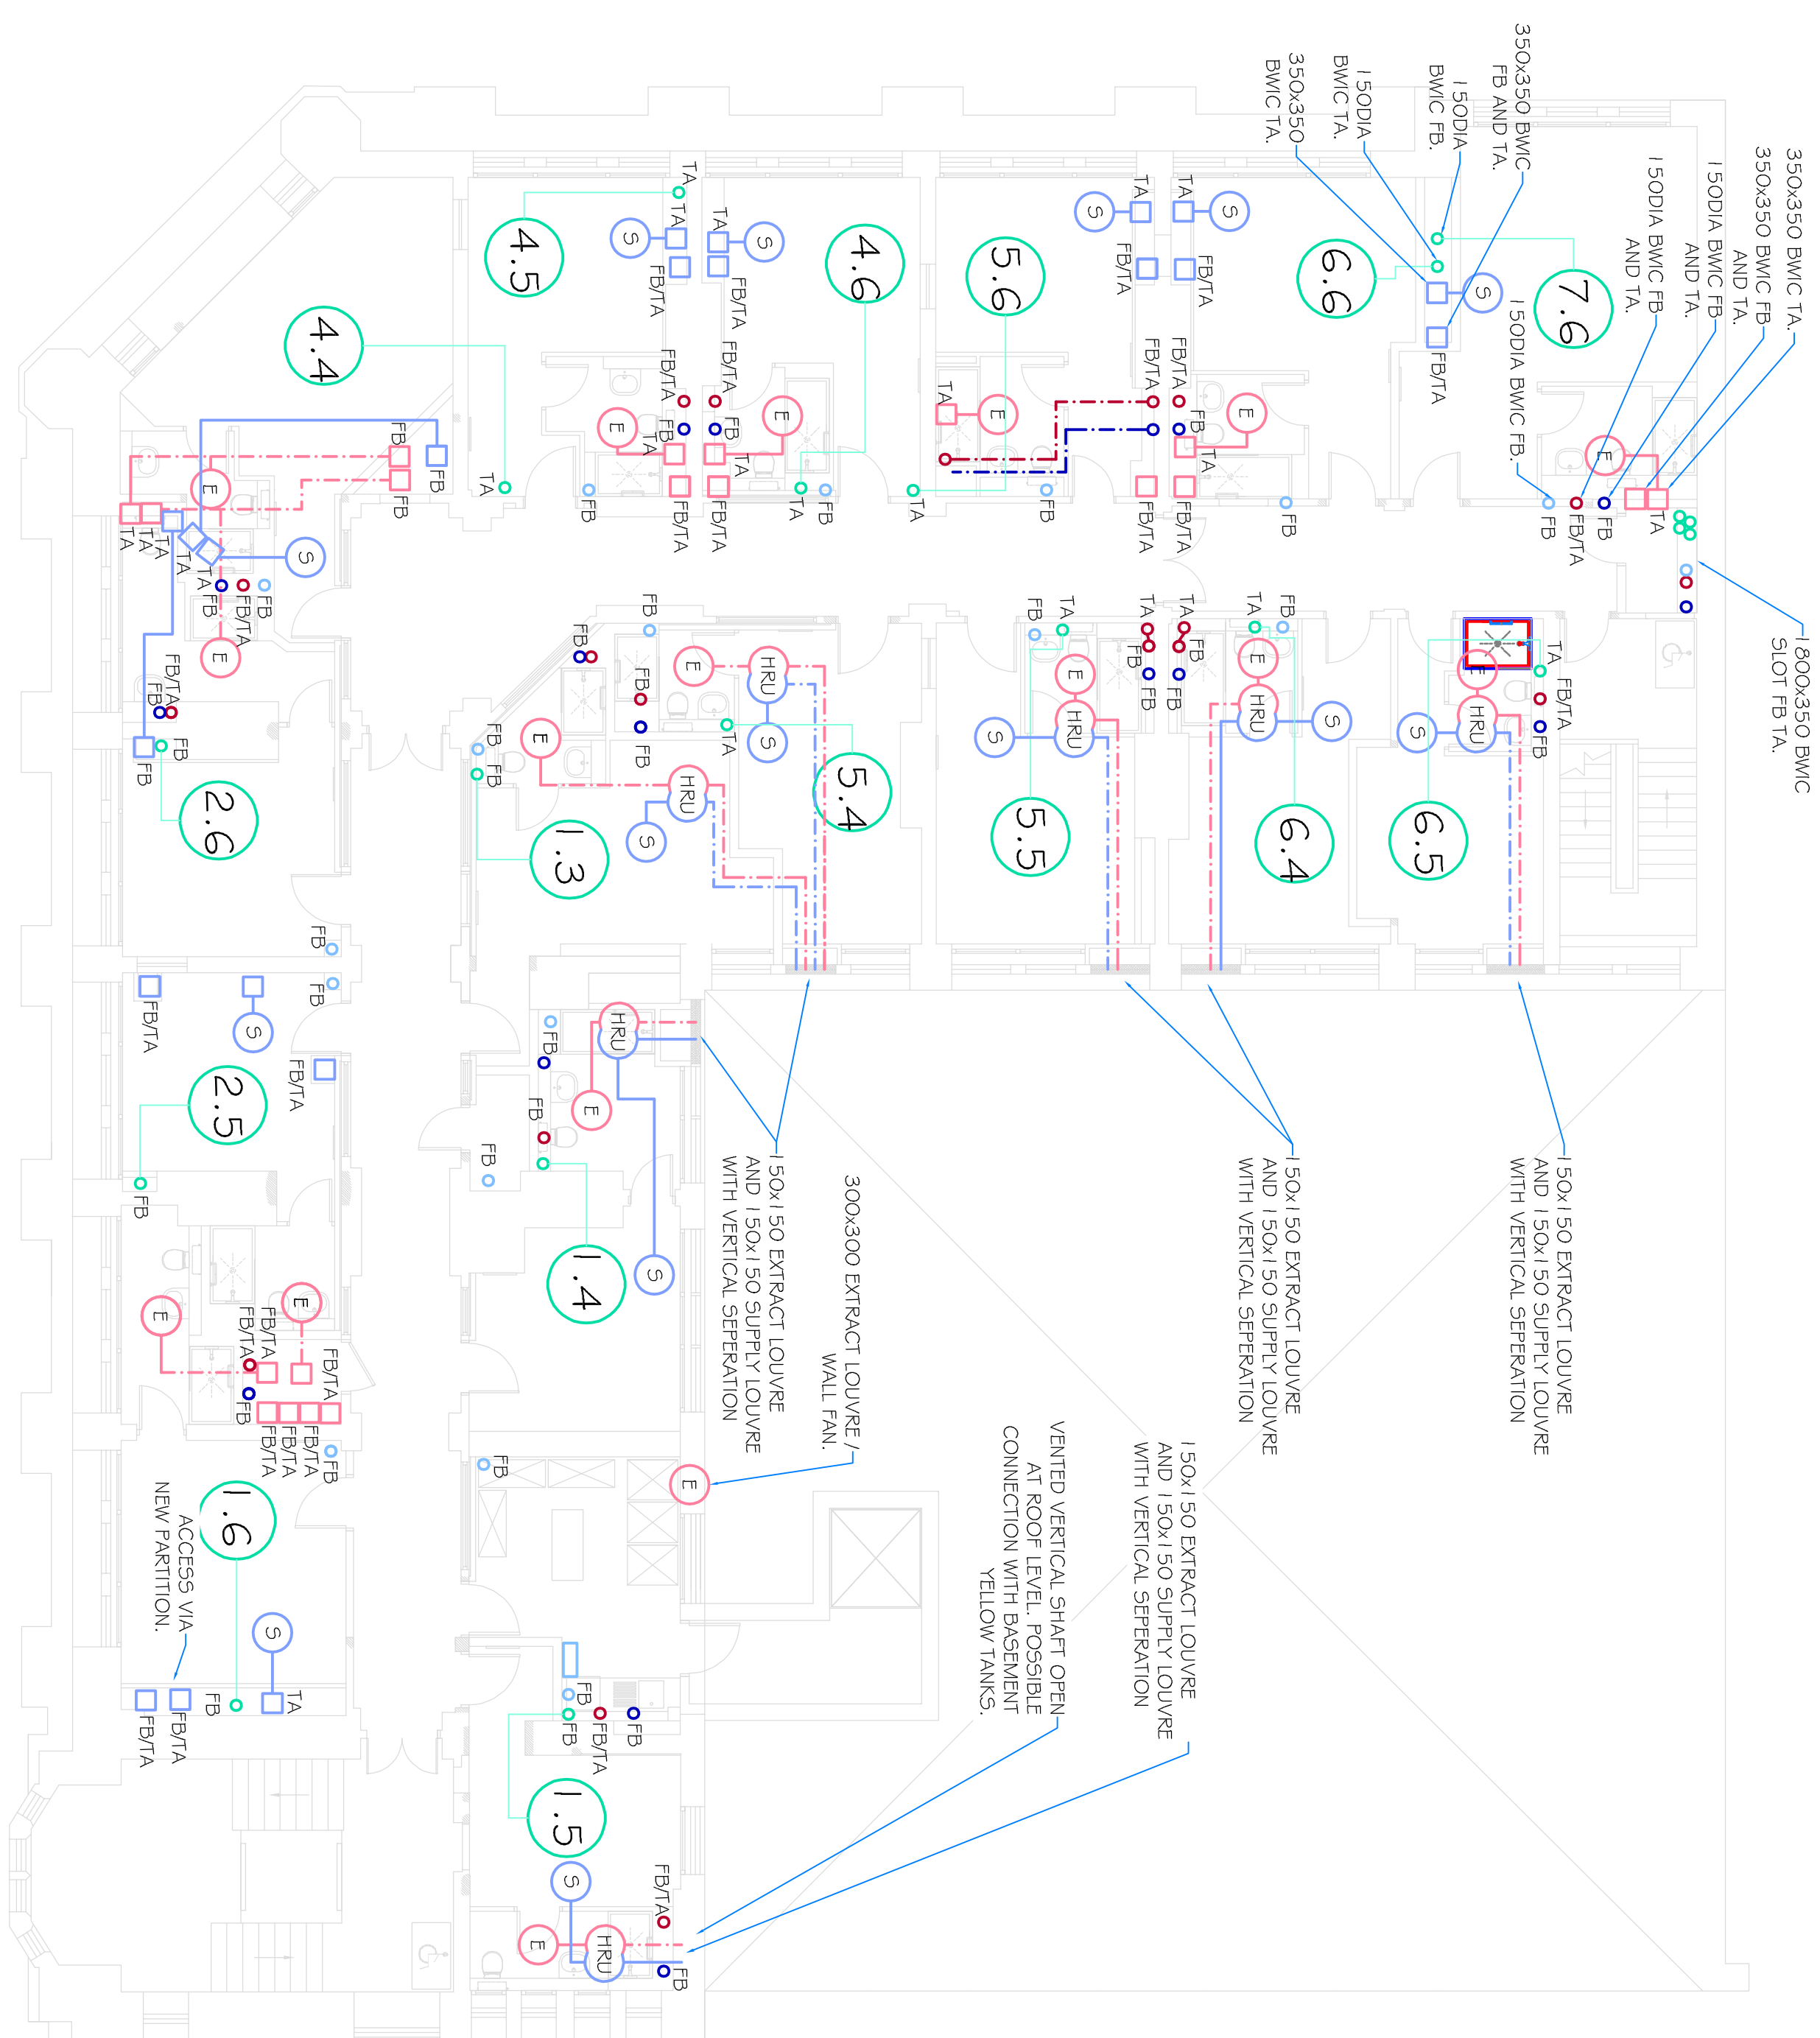

CONCEPT SERVICES:
BOOSTED COLD WATER SERVED FROM SECOND FLOOR
HOT WATER RETURN RISE TO FOURTH FLOOR
AIR CONDITIONING REFRIGERANT PIPEWORK FROM FOURTH FLOOR VIA
ROOF MOUNTED 400 MCUS
BATHROOM EXTRACT ALONG FRONT FACE TO DISCHARGE VIA LOUVER
BATHROOM EXTRACT ALONG REAR FACE TO DISCHARGE VIA LOUVER
RECOVER LINE DUCTS FROM TO AND FROM ROOMS
FIRE DAMPERS AT FLOOR LEVEL WITH ACCESS THROUGH NEW
CONSTRUCTION PARTITIONS AND FLOORS
ELECTRICAL DISTRIBUTION FROM SECOND FLOOR RISING TO EACH ROOM.

1:100 FOURTH FLOOR

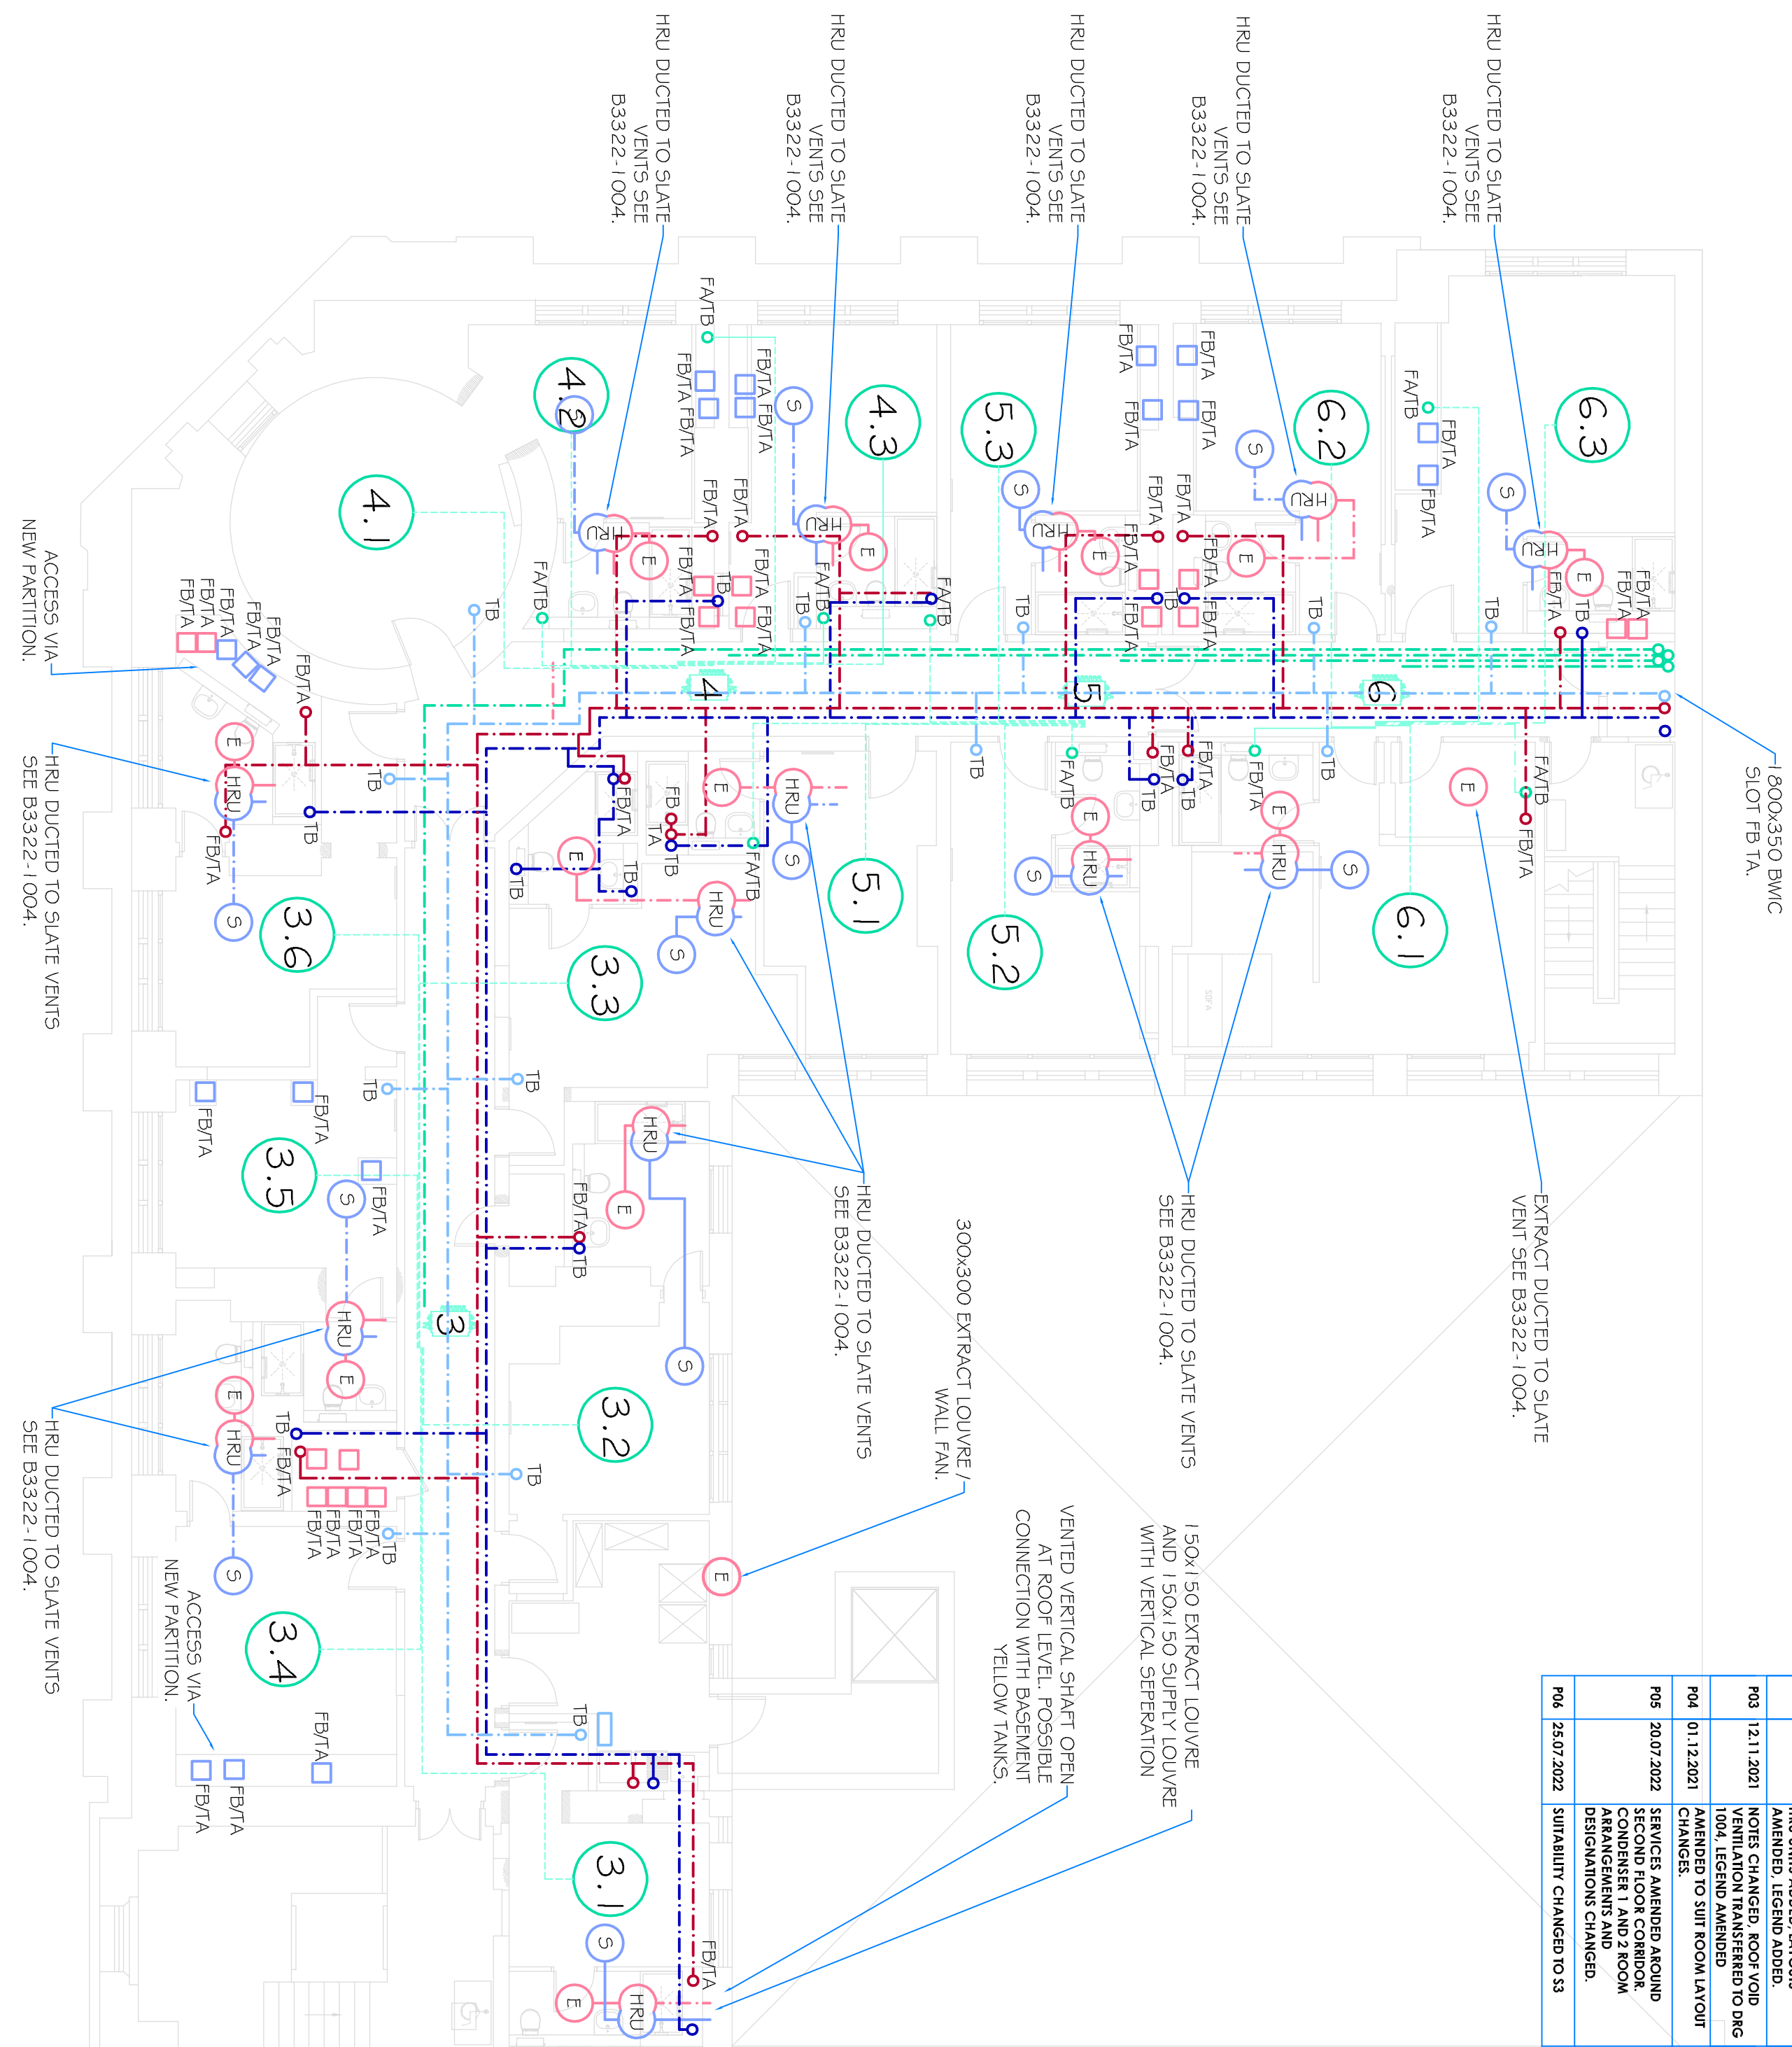


CONCEPT SERVICES:
BOOSTED COLD WATER SERVED FROM BASEMENT ROUTED VIA
STAIRWELL RISER WITH MAIN RUN ALONG VIA ROOF VOID DROPS TO
FOURTH FLOOR ROOMS
HOT WATER RETURN RISES TO ROOF VOID, ROUTED TO REAR YARD
CALORIFIERS VIA STAIRWELL RISER
AIR CONDITIONING REFRIGERANT PIPEWORK FROM REAR YARD
CONDENSORS TO FOURTH FLOOR CEILING VOID WITH 400 MCUS
ALL FOURTH FLOOR BEDROOMS AND SOME OF THE THIRD FLOOR
BEDROOMS EXTRACT ALONG FRONT FACING ROOMS RISES FROM THIRD
FLOOR, TO ROOF VOID CONNECT TO CENTRAL HEAT RECOVERY UNIT TO
EXTRACT SYSTEM
BATHROOM EXTRACT ALONG REAR FACING TO ROOF VOID HEAT
RECOVERY UNITS TO SLATE VENTS
SUPPLY TO FRONT FACING ROOMS FROM ROOF MOUNTED CENTRAL
HEAT RECOVERY UNIT
FIRE DAMPERS AT FLOOR LEVEL WITH ACCESS THROUGH NEW
CONSTRUCTION PARTITIONS AND FLOORS
ELECTRICAL DISTRIBUTION FROM BASEMENT TO ROOF VOID TO EACH
ROOM.

1.4 AIR CONDITIONING INTERNAL UNIT RECESSED/ SURFACE TBC,
1 CONDENSER RET, 1 6 MCU GKOUT RET

- 350x350 BWC EXTRACT VENTILATION
- 350x350 BWC SUPPLY VENTILATION
- 150 DIA BWC REFRIGERANT PIPEWORK
- 150 DIA BWC COLD WATER PIPEWORK
- 150 DIA BWC HOT WATER PIPEWORK
- 150 DIA BWC ELECTRICAL RISER
- COLD WATER SERVICE (CWS) PIPE
- HOT WATER SERVICE (HWS) PIPE
- REFRIGERANT PIPEWORK (2 PIPS) (AC)
- EXTRACT DUCT
- SUPPLY DUCT
- ELECTRICAL TRUNKING / CABLE TRAY / BASKET
- FB FROM BELOW BWC IN FLOOR
- FA FROM ABOVE BWC IN CEILING
- TB TO ABOVE BWC IN CEILING
- TB TO BELOW BWC IN CEILING

Scale
1 2 3 4 5

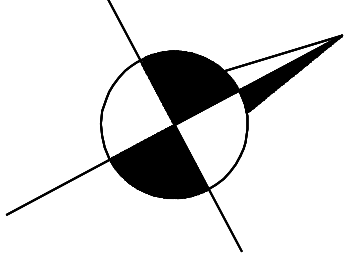

M&E SERVICES INSTALLATION SERVICE ALLOCATION FEASIBILITY

Job No.	Originator	Zone	Level	Type	Room
B3322	BMT	ZZ	03-04	DR	ME
System Classification	Drawing No.	Subsidiary	Revision		
PM_10_20_30-1003	S3	P06			
Drawn By	Drawn Date	Scale	Scale		
AL	27/10/2021	1:100	1:100		AL



920B MELTON ROAD
THURKASTON
LEICESTER
LE11 6BU
TEL: 01533 441033
E-MAIL: sales@bmt-engineering.co.uk

Client
MITCHELLS & BUTTERS Pte
BMT Project No./ Project Title
B3322 / ICC MANCHESTER
Project Address
INN KEEPER'S COLLECTION
1-3 YORK STREET
MANCHESTER

