
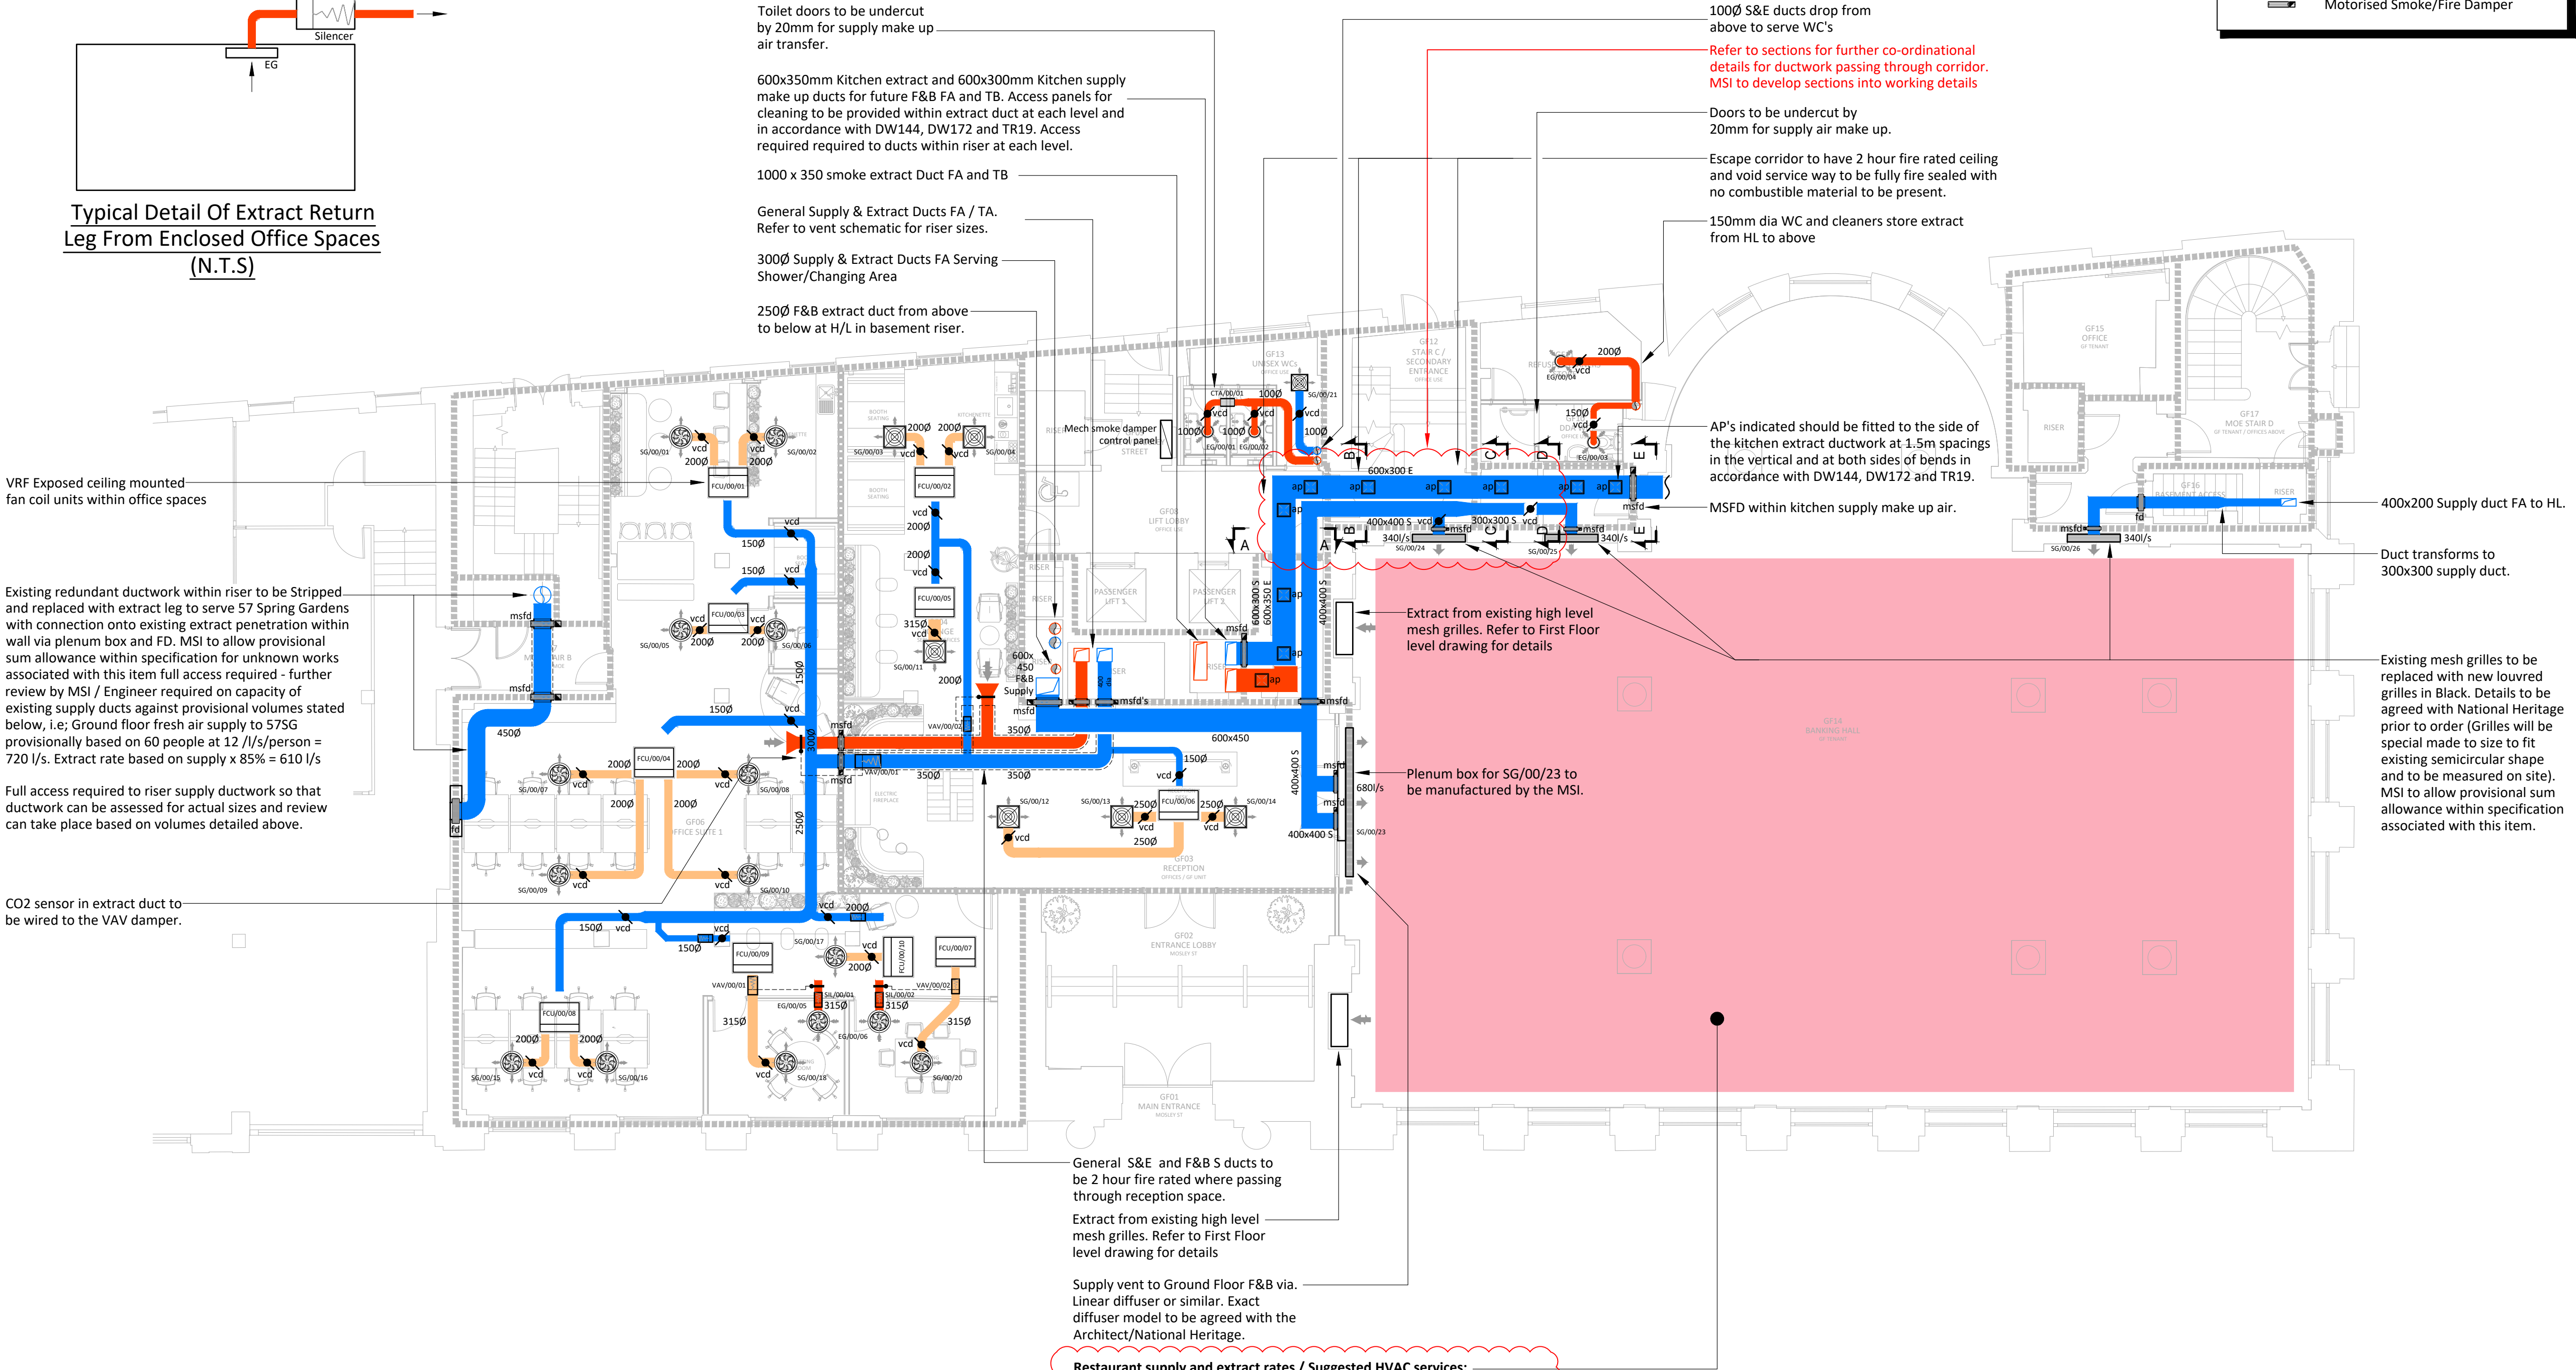
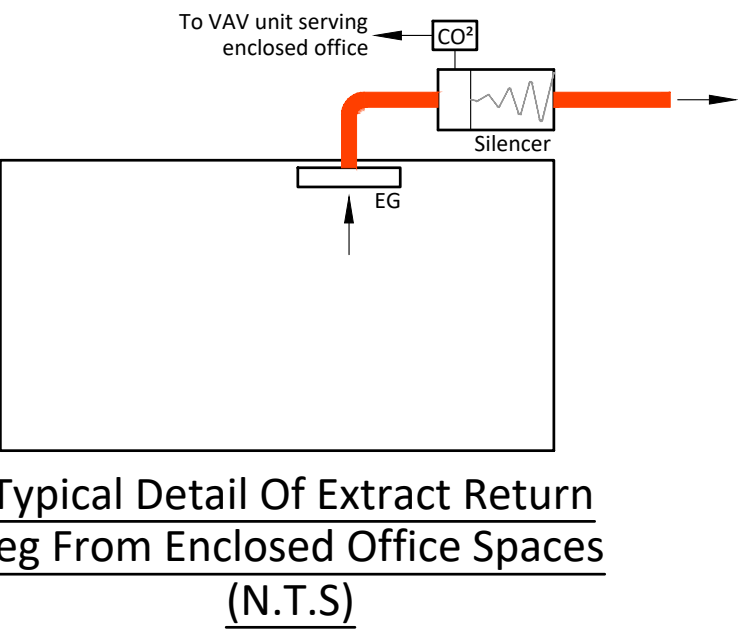


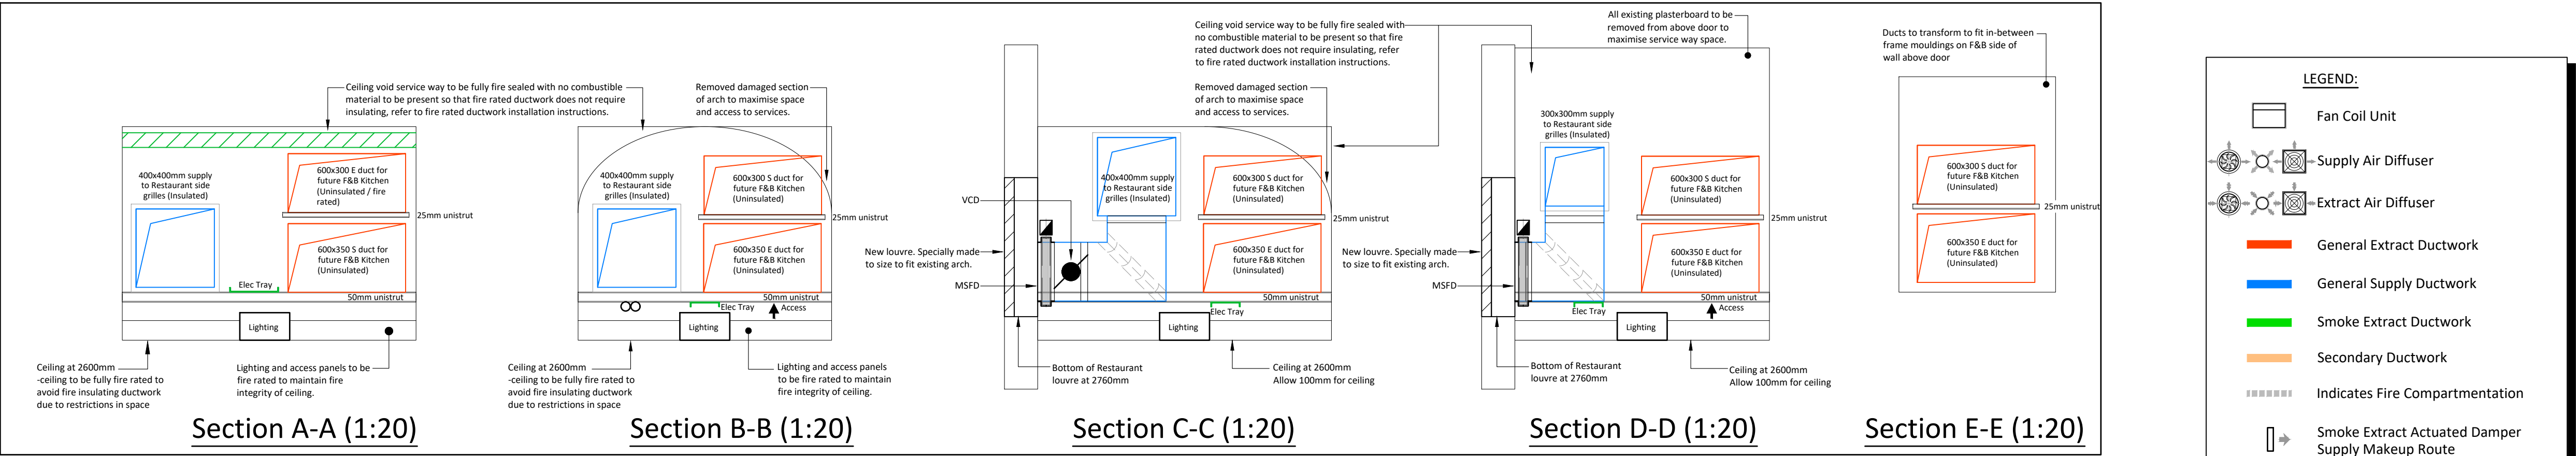

Restaurant supply and extract rates / Suggested HVAC services:
Occupancy 170 people.
Ventilation:
Based on 10 l/s/p = 1700 l/s or 1.7m³/s
Cooling:
Cooling discounted for the size of space and heavyweight structure of the building. Internal summertime heat gains may rise to high level where extract vent can take warm vitiated air away. Some cooling introduced as a peak lopping scenario at height of summer but based on volumes required for ventilation air only.

Do not scale from this drawing.
Verify dimensions by site measurement.
Read this drawing in conjunction with the latest architectural and structural drawings.
This drawing is based on the following information:-

- Notes**
- This drawing to be read in conjunction with all mechanical, electrical & public health drawings for this contract.
 - All services work to be carried out in accordance with the relevant Engineering Specification for this contract.

05	09/09/22	CAT B Contractor Issue WC / Clnrs Store Vent reviewed	SH	SH
04	12/08/22	CAT B Issue For Planning.	MR	SH
03	20/05/22	Stage 4 Tender Update.	MR	SH
02	29/04/22	Stage 4 Tender Issue.	MR	SH
01	31/03/22	Stage 3 Issue.	RG	SH
Revision	Date	Description	Drawn	Checked

HIM
hilsonmoran.com info@hilsonmoran.com
Client
Bruntwood

Project
38-42 Mosley Street
Grade 2* Listed Building Refurbishment

Drawing Title
Mechanical Services
Ground Floor
Ventilation Layout

Scale	Sheet Size	Checked	Approved
1:100	A1	SH	SR
Status	HM Project No.		
FOR INFORMATION			27618
Drawing No.	Rev		
27618-HM-ZZ-GF-DR-MS-2201			05