
 


SITE LOCATION

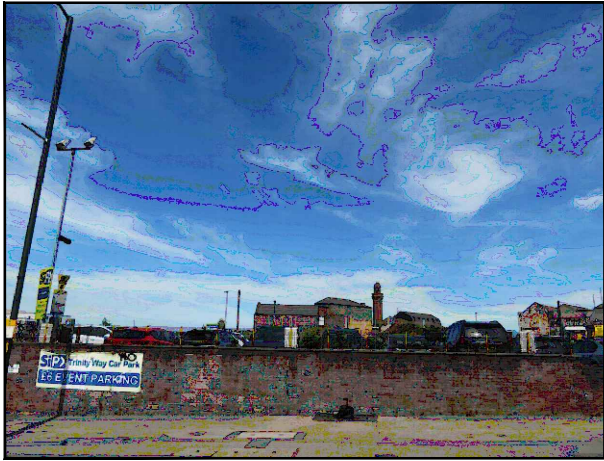


Reproduced by permission of Ordnance Survey on behalf of the Controller of Her Majesty's Stationery Office
All rights reserved. © Crown Copyright licence no. 100062043

SITE AREA PLAN




SITE PHOTOGRAPH

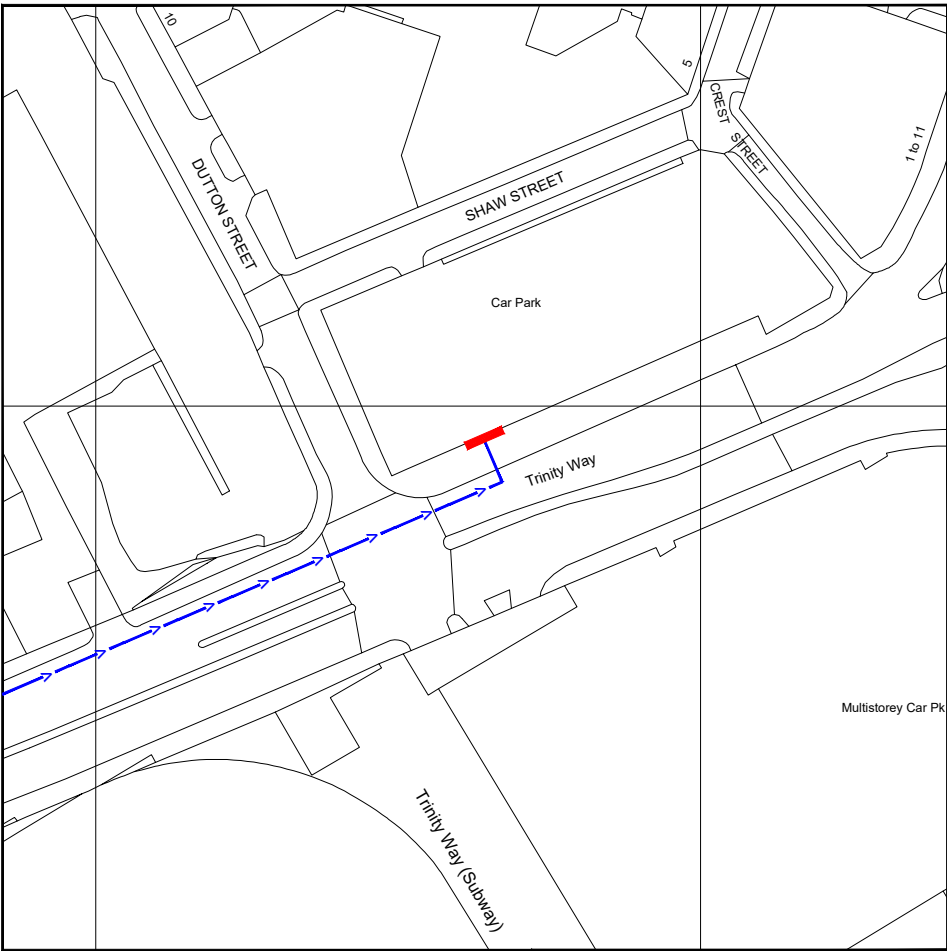

Reproduced by permission of Ordnance Survey on behalf of
the Controller of Her Majesty's Stationery Office
All rights reserved. © Crown Copyright licence no. 100062043

NGR E: 383963 N: 399196

 SITE LOCATION PLAN



GOOGLE MAPS QR CODE

GOOGLE MAPS - <https://goo.gl/maps/83sujpbdnvPnjXzD9>

GOOGLE STREETVIEW - <https://goo.gl/maps/jfoKWsZipyuUpe5Q8>

NOTES:

1. ALL DIMENSIONS IN MM UNLESS OTHERWISE NOTED.

DIRECTIONS TO SITE:

Head north on M56. Keep right at the fork to stay on M56. Continue onto Princess Pkwy/A5103. Keep right to stay on Princess Pkwy/A5103. Continue straight onto Princess Rd/A5103. Use the left lane to continue on Medlock St Jct/A5103. Slight left to stay on Medlock St Jct/A5103. Merge onto A57(M)/A635(M). Continue onto Dawson St/Egerton St/Ring Rd/A57. Slight right onto Ring Rd/A6042. Turn left onto Ring Rd/A34/A6042. Follow Trinity Way and site location is on the left hand side.

Site Provider's
Property Boundary:



Access Route To Site:



Access Route:



Master:	MBNL / EE:	Project:	Purpose of Issue:	Issue:
M001	MBNL	3UK DNSW	Planning	A
Date:	15/08/2022	Revision / Upgrade Description:		
Drawn:	CDN	First Issue - Site nomination dated: TBC		
Checked:	DH			
Approved:	SD			

CK Hutchison
Networks (UK)
Limited

Great Brighams Mead,
Vastern Road, Reading,
Berkshire, England,
RG1 8DJ

Design Consultant & Principal Contractor:



WHP Telecoms

Unit 1 Maple Park,
Low Fields Avenue, Leeds
LS12 6HH

Tel: 01133023550
e-mail: info@whptelecoms.com

Site Name:
TRINITY WAY STREETWORKS

Site ID:
MAN24137

Address:
TRINITY WAY,
STRANGWAYS,
MANCHESTER,
GREATER MANCHESTER,
M3 1LD

Title:
002 SITE LOCATION PLAN

Project:
3UK DNSW

Purpose of Issue:
PLANNING

EE Cell ID:	MBNL Cell ID:	Cell ID:
87405	MAN616	M1433

Master Drawing No:	Issue:
MAN24137_M001	A

1. ALL DIMENSIONS IN MM UNLESS OTHERWISE NOTED.

Design Consultant & Principal Contractor:

 **WHP Telecoms**
Unit 1 Maple Park,
Low Fields Avenue, Leeds
LS12 6HH

Tel: 01133023550
e-mail: info@whptelecoms.com

Site Name: TRINITY WAY STREETWORKS

Site ID: MAN24137

Address: TRINITY WAY,
STRANGWAYS,
MANCHESTER,
GREATER MANCHESTER,
M3 1LD

Title: 100 EXISTING SITE PLAN

Project:	3UK DNSW
----------	----------

Purpose of Issue:	PLANNING
-------------------	----------



EE Cell ID: 87405	MBNL Cell ID: MAN616	Cell ID: M1433
-----------------------------	--------------------------------	--------------------------

Master Drawing No:	MAN24137 M001	Issue:	A
--------------------	---------------	--------	---

100mm

150mm

 10mm

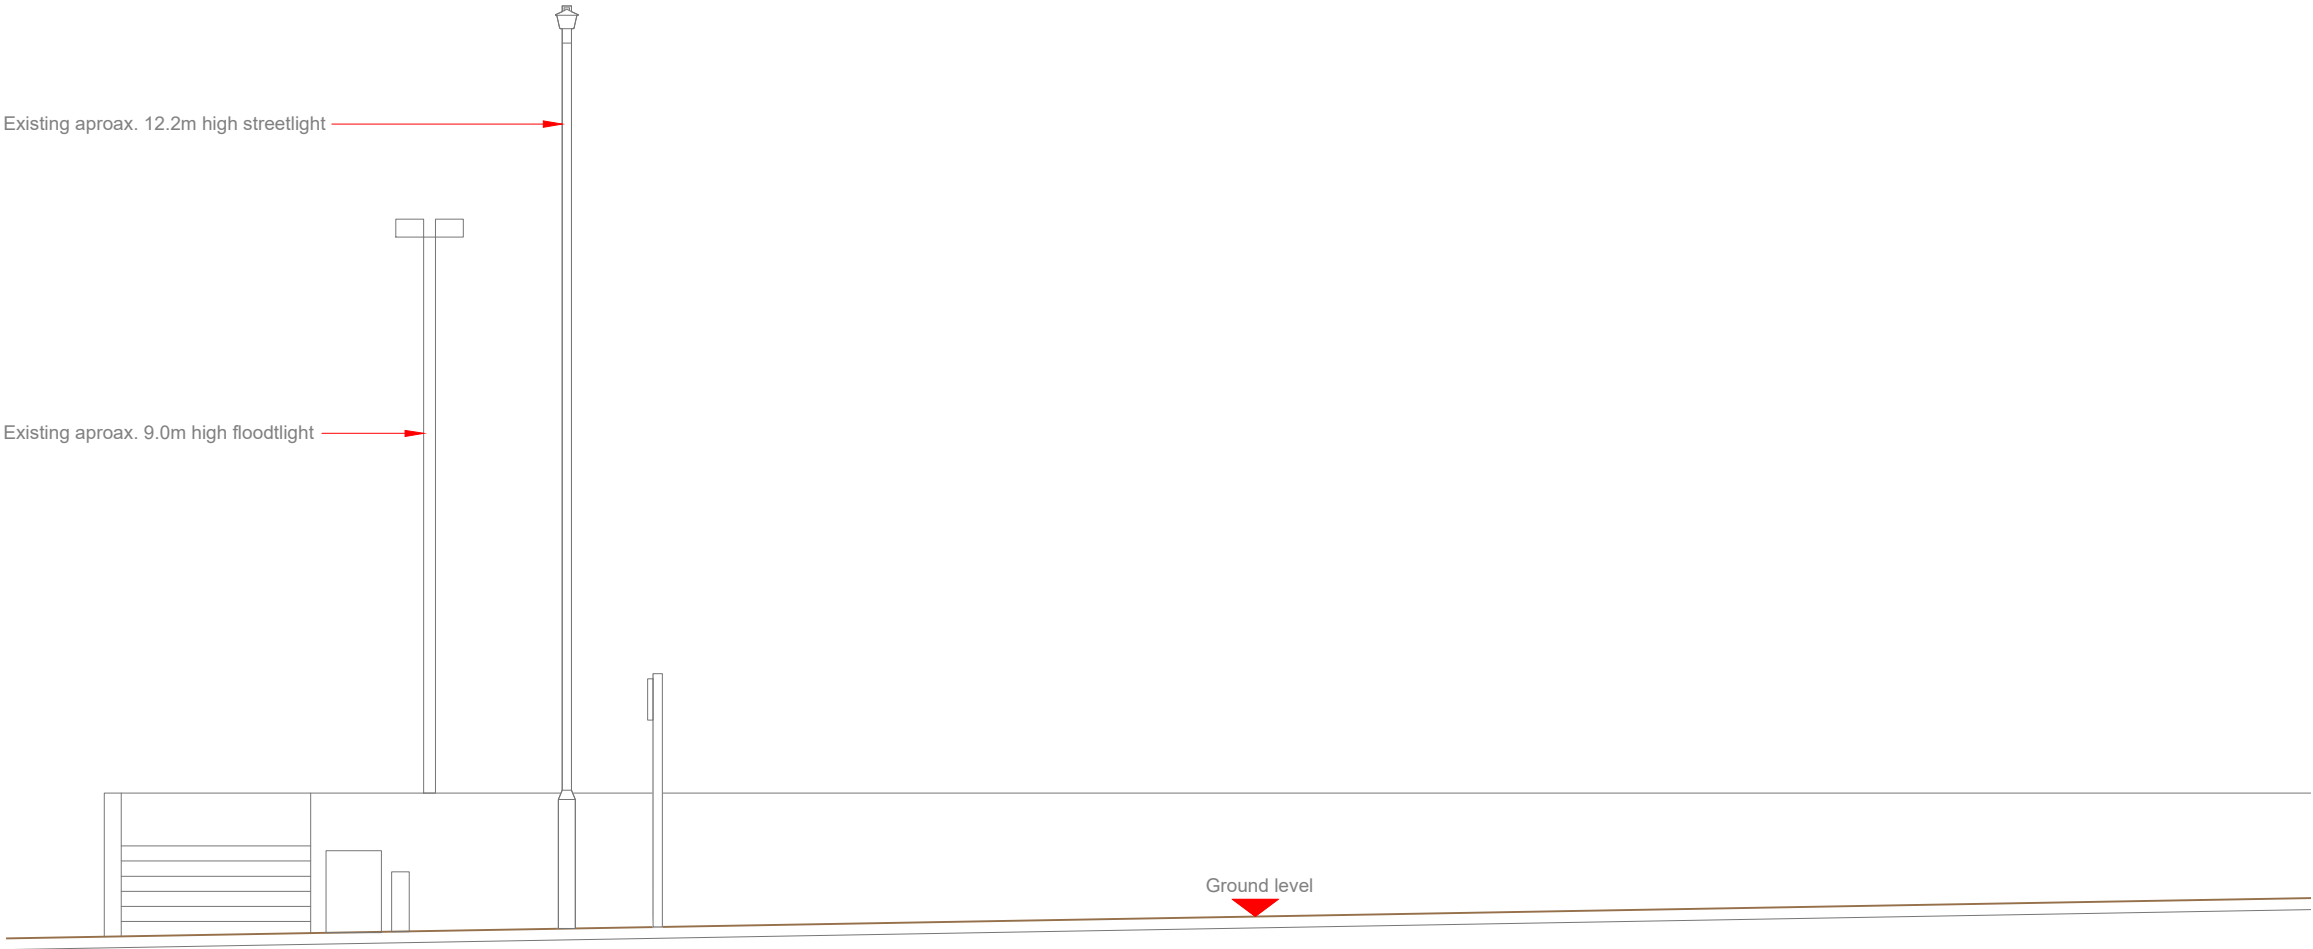

- NOTES:
1. ALL DIMENSIONS IN MM UNLESS OTHERWISE NOTED.

Master:	MBNL / EE:	Project:	Purpose of Issue:	Issue:
M001	MBNL	3UK DNSW	Planning	A
Date:	15/08/2022	Revision / Upgrade Description:		
Drawn:	CDN	First Issue - Site nomination dated: TBC		
Checked:	DH			
Approved:	SD			

CK Hutchison
Networks (UK)
Limited
Great Brighams Mead,
Vastern Road, Reading,
Berkshire, England,
RG1 8DJ

Design Consultant & Principal Contractor:



WHP Telecoms
Unit 1 Maple Park,
Low Fields Avenue, Leeds
LS12 6HH

Tel: 01133023550
e-mail: info@whptelecoms.com

Site Name:
TRINITY WAY STREETWORKS

Site ID:
MAN24137

Address:
TRINITY WAY,
STRANGWAYS,
MANCHESTER,
GREATER MANCHESTER,
M3 1LD

Title:
150 EXISTING ELEVATION A

Project:
3UK DNSW

Purpose of Issue:
PLANNING


EE Cell ID:	MBNL Cell ID:	Cell ID:
87405	MAN616	M1433
Master Drawing No: MAN24137_M001		
Issue: A		




Antenna Aperture ID	Proposed 4G/5G Bearing
A1	0°
B1	120°
C1	240°
A2	0°
B2	120°
C2	240°

NOTES:

1. ALL DIMENSIONS IN MM UNLESS OTHERWISE NOTED.

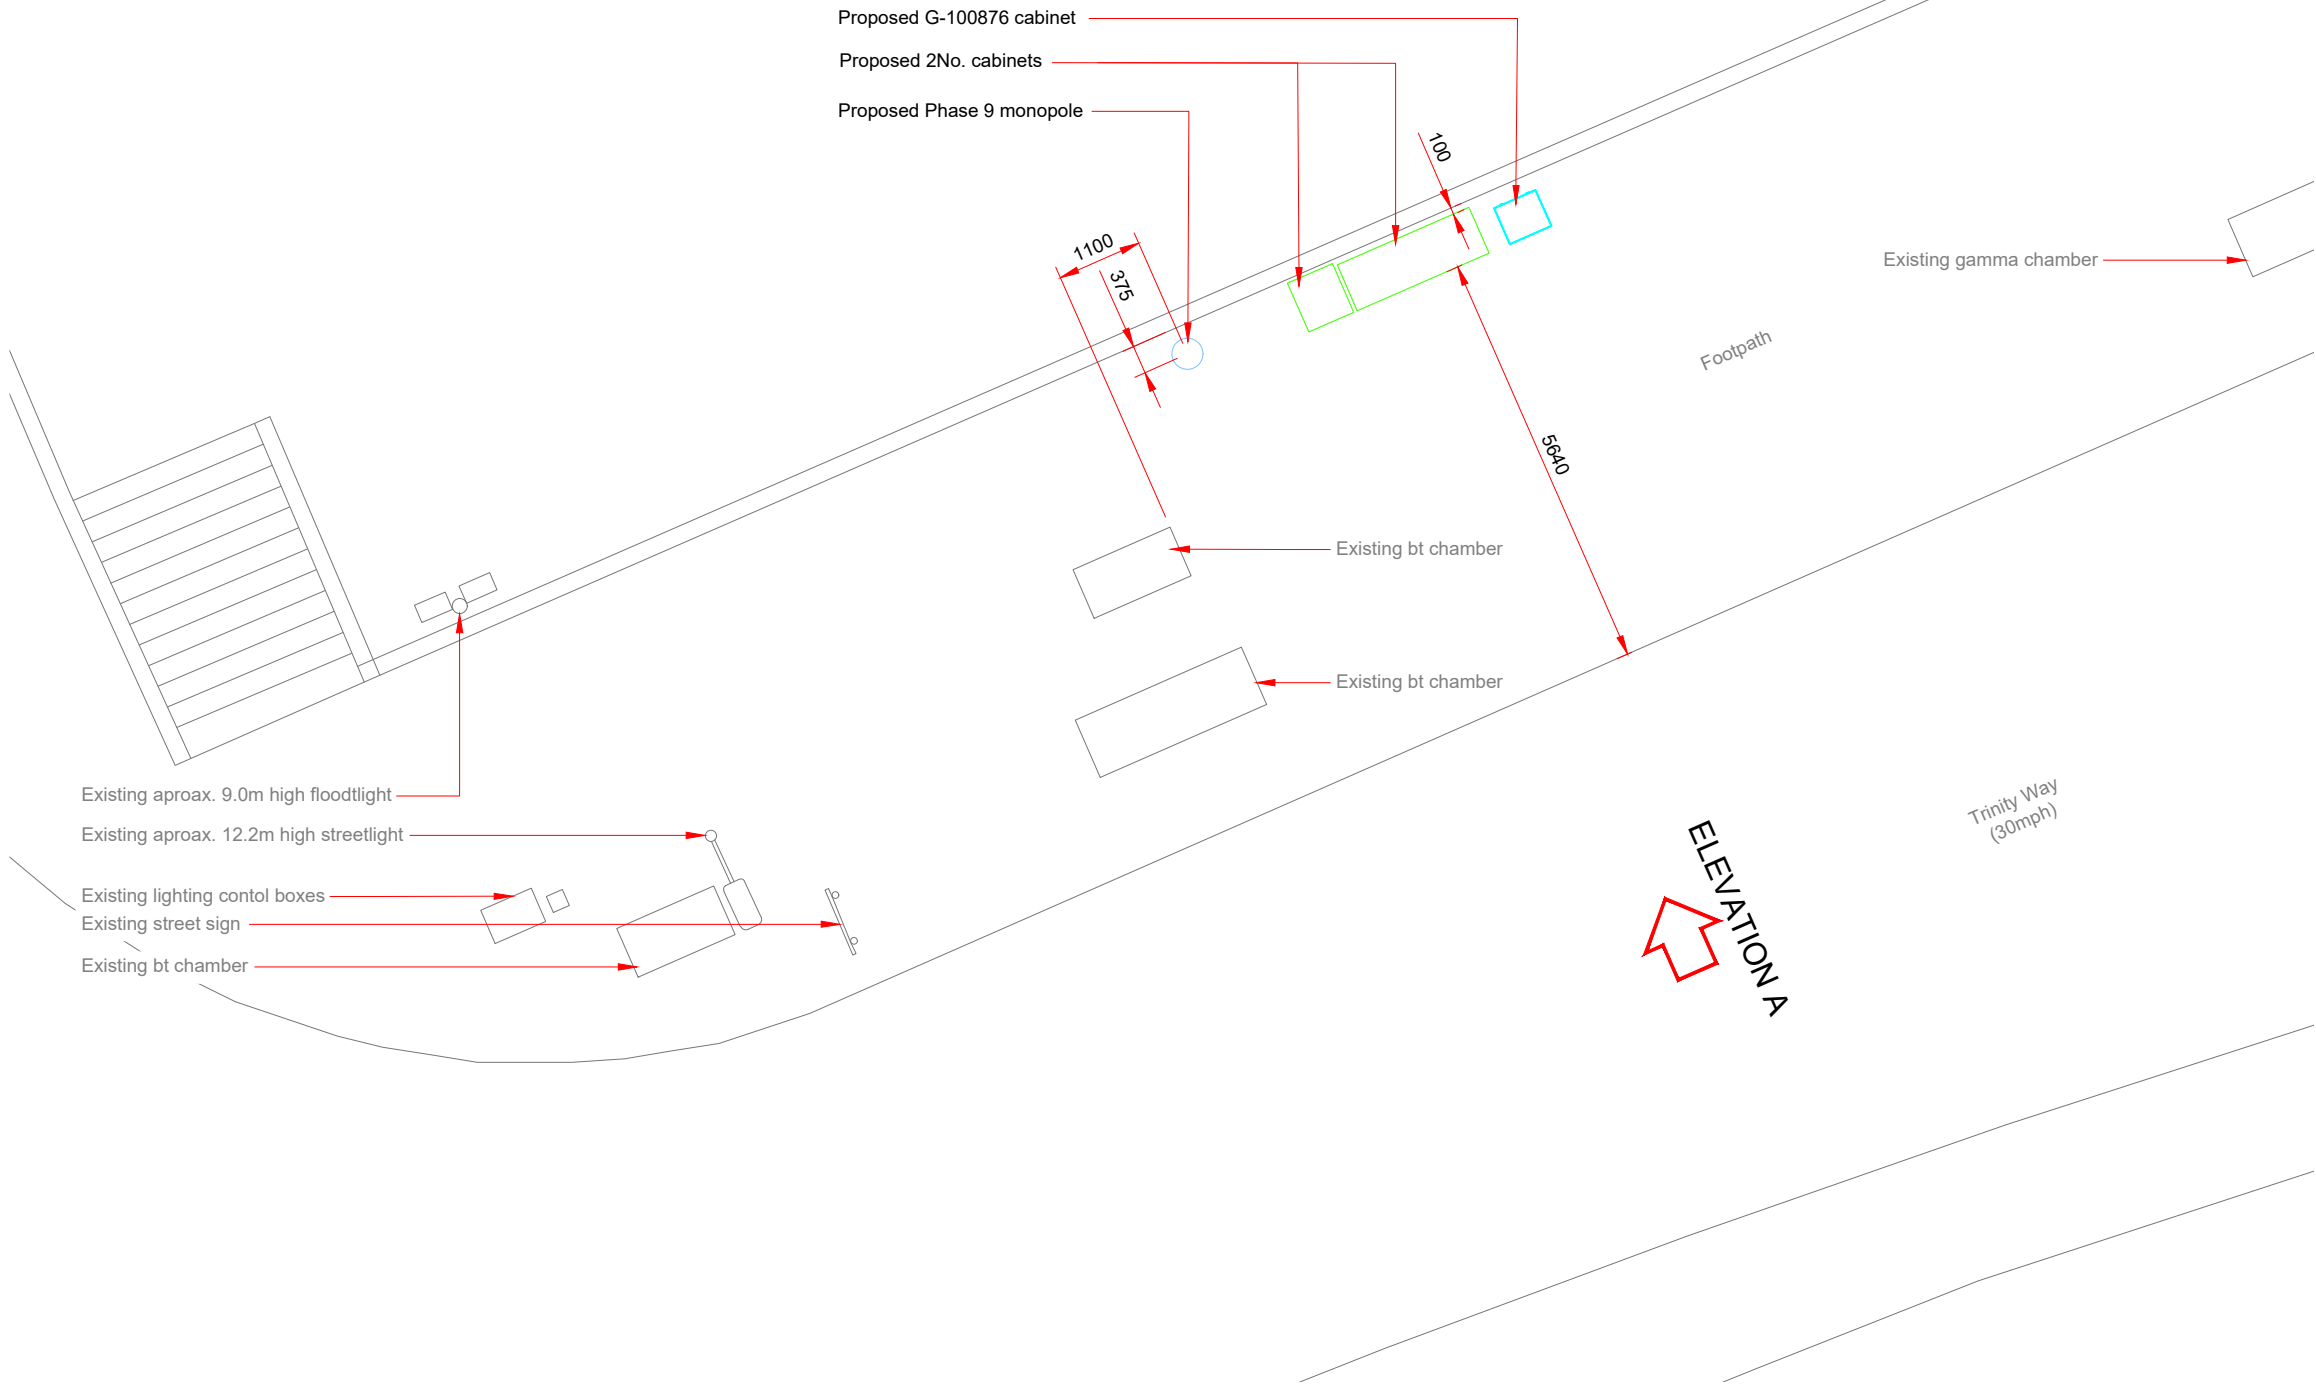

PROPOSED SITE PLAN

 

Master:	MBNL / EE:	Project:	Purpose of Issue:	Issue:
M001	MBNL	3UK DNSW	Planning	A
Date:	15/08/2022	Revision / Upgrade Description:		
Drawn:	CDN	First Issue - Site nomination dated: TBC		
Checked:	DH			
Approved:	SD			

CK Hutchison Networks (UK) Limited

Great Brighams Mead,
Vastern Road, Reading,
Berkshire, England,
RG1 8DJ

Design Consultant & Principal Contractor:



WHP Telecoms

Unit 1 Maple Park,
Low Fields Avenue, Leeds
LS12 6HH


Tel: 01133023550
e-mail: info@whptelecoms.com

Site Name:				TRINITY WAY STREETWORKS			
Site ID:				MAN24137			
Address:				TRINITY WAY, STRANGWAYS, MANCHESTER, GREATER MANCHESTER, M3 1LD			
Title:				210 PROPOSED SITE PLAN			
Project:				3UK DNSW			
Purpose of Issue:				PLANNING			
EE Cell ID:		MBNL Cell ID:		Cell ID:			
87405		MAN616		M1433			
Master Drawing No:						Issue:	
MAN24137_M001						A	


Antenna Aperture ID	Proposed 4G/5G Bearing
A1	0°
B1	120°
C1	240°
A2	0°
B2	120°
C2	240°

NOTES:

1. ALL DIMENSIONS IN MM UNLESS OTHERWISE NOTED.

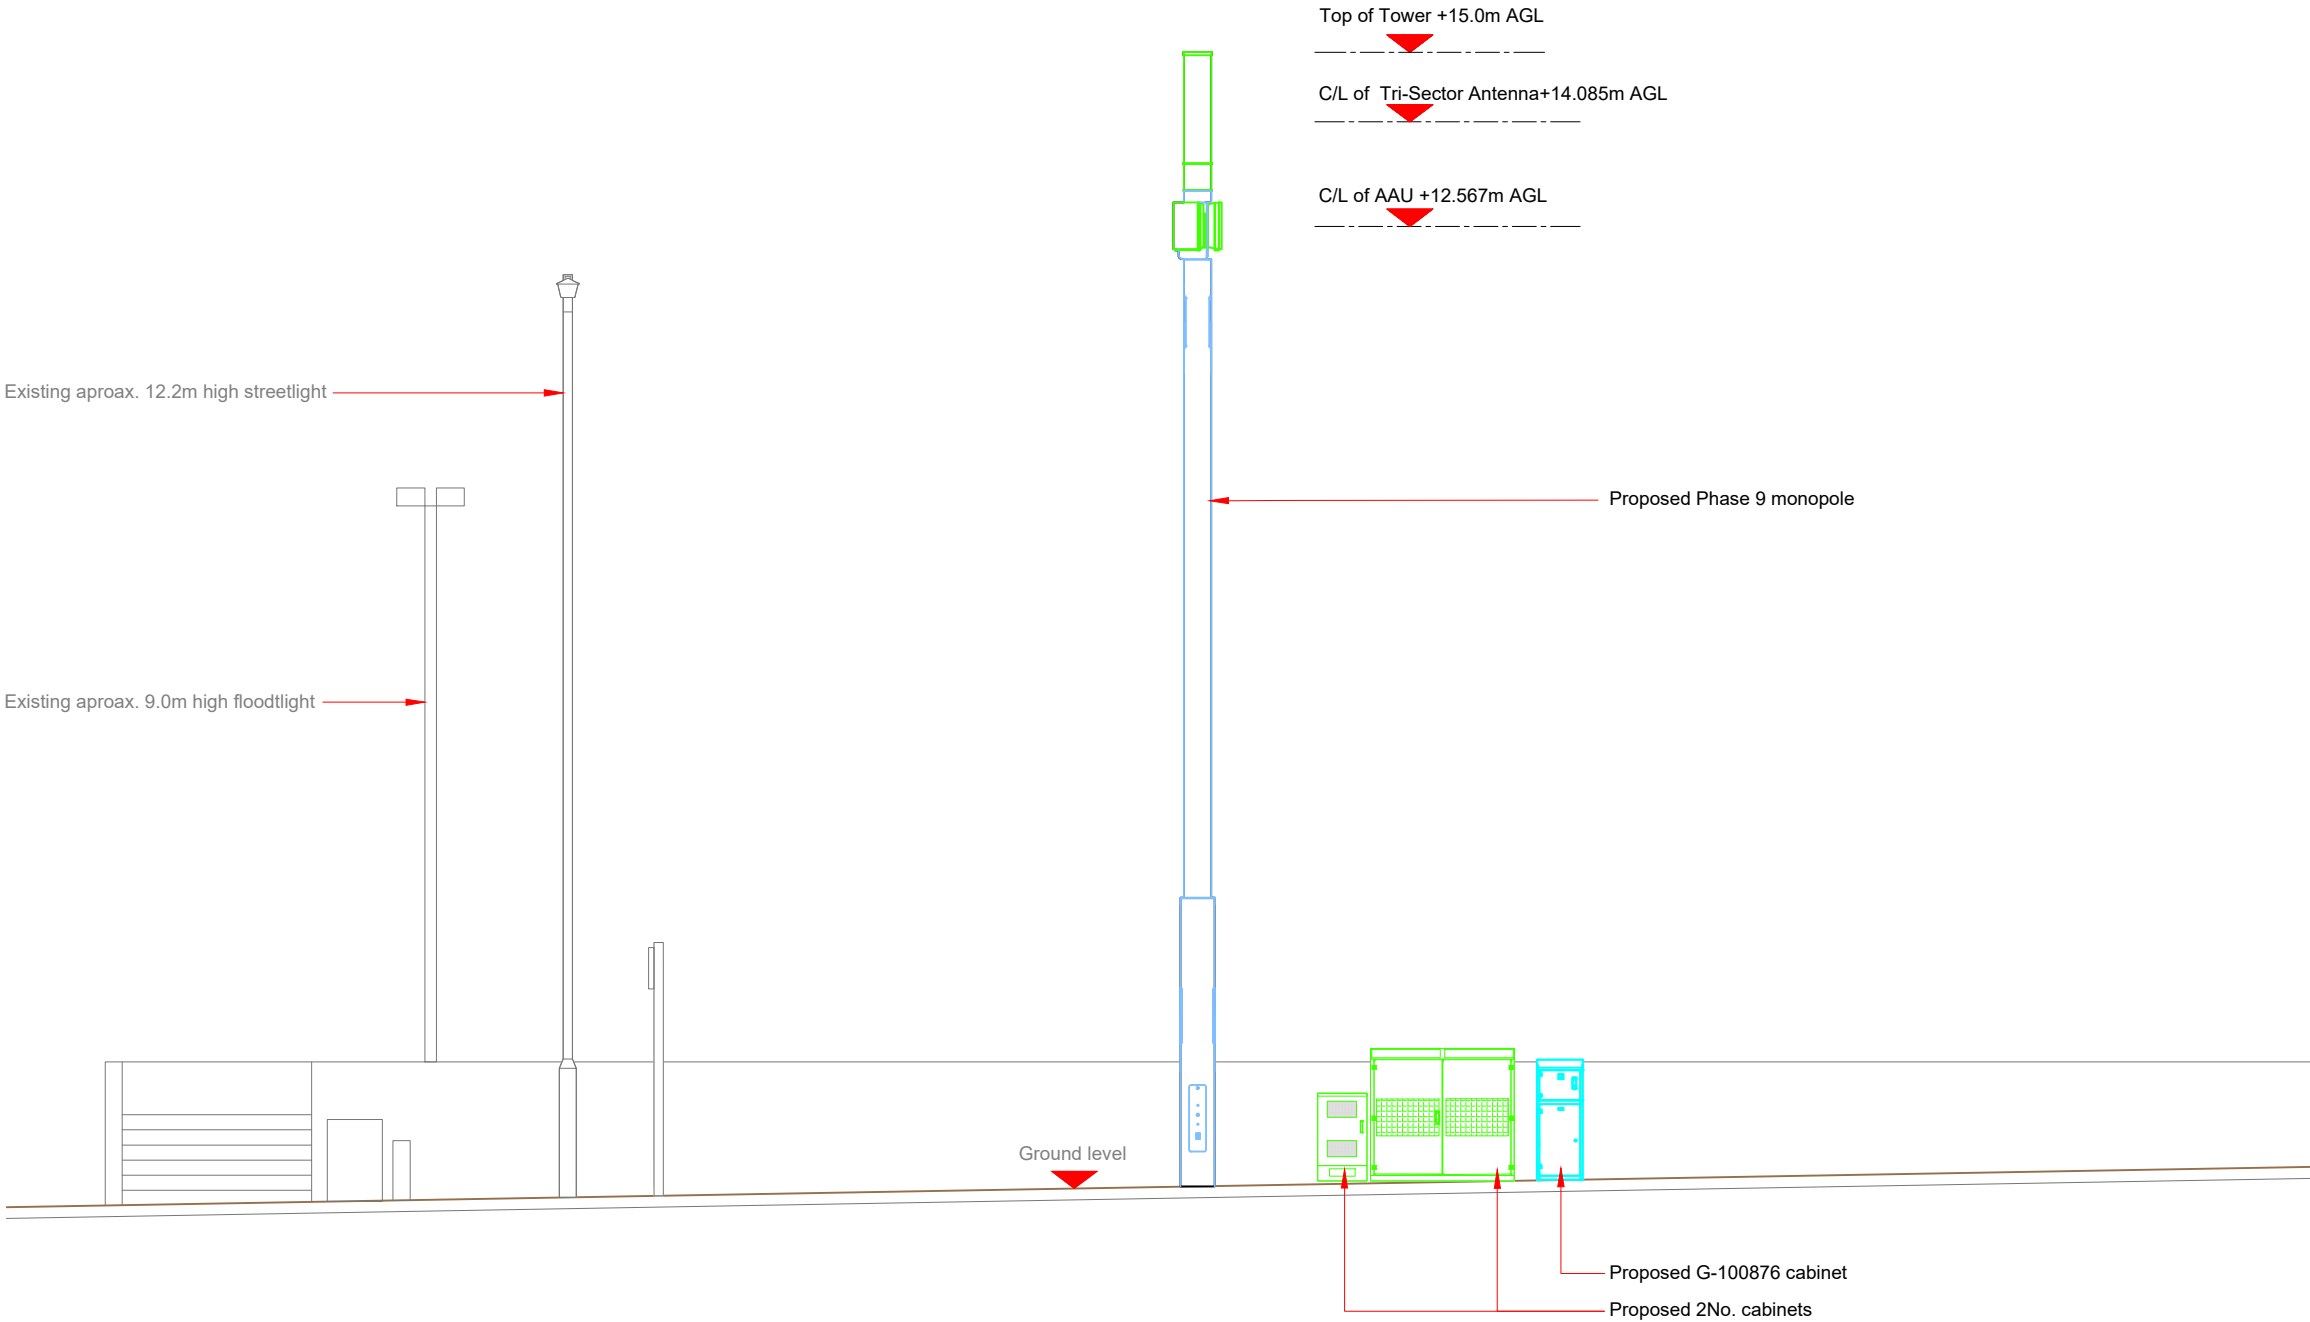

PROPOSED ELEVATION

 

Master: M001	MBNL / EE: MBNL	Project: 3UK DNSW	Purpose of Issue: Planning	Issue: A
Date: 15/08/2022	Revision / Upgrade Description: First Issue - Site nomination dated: TBC			
Drawn: CDN				
Checked: DH				
Approved: SD				
</				